



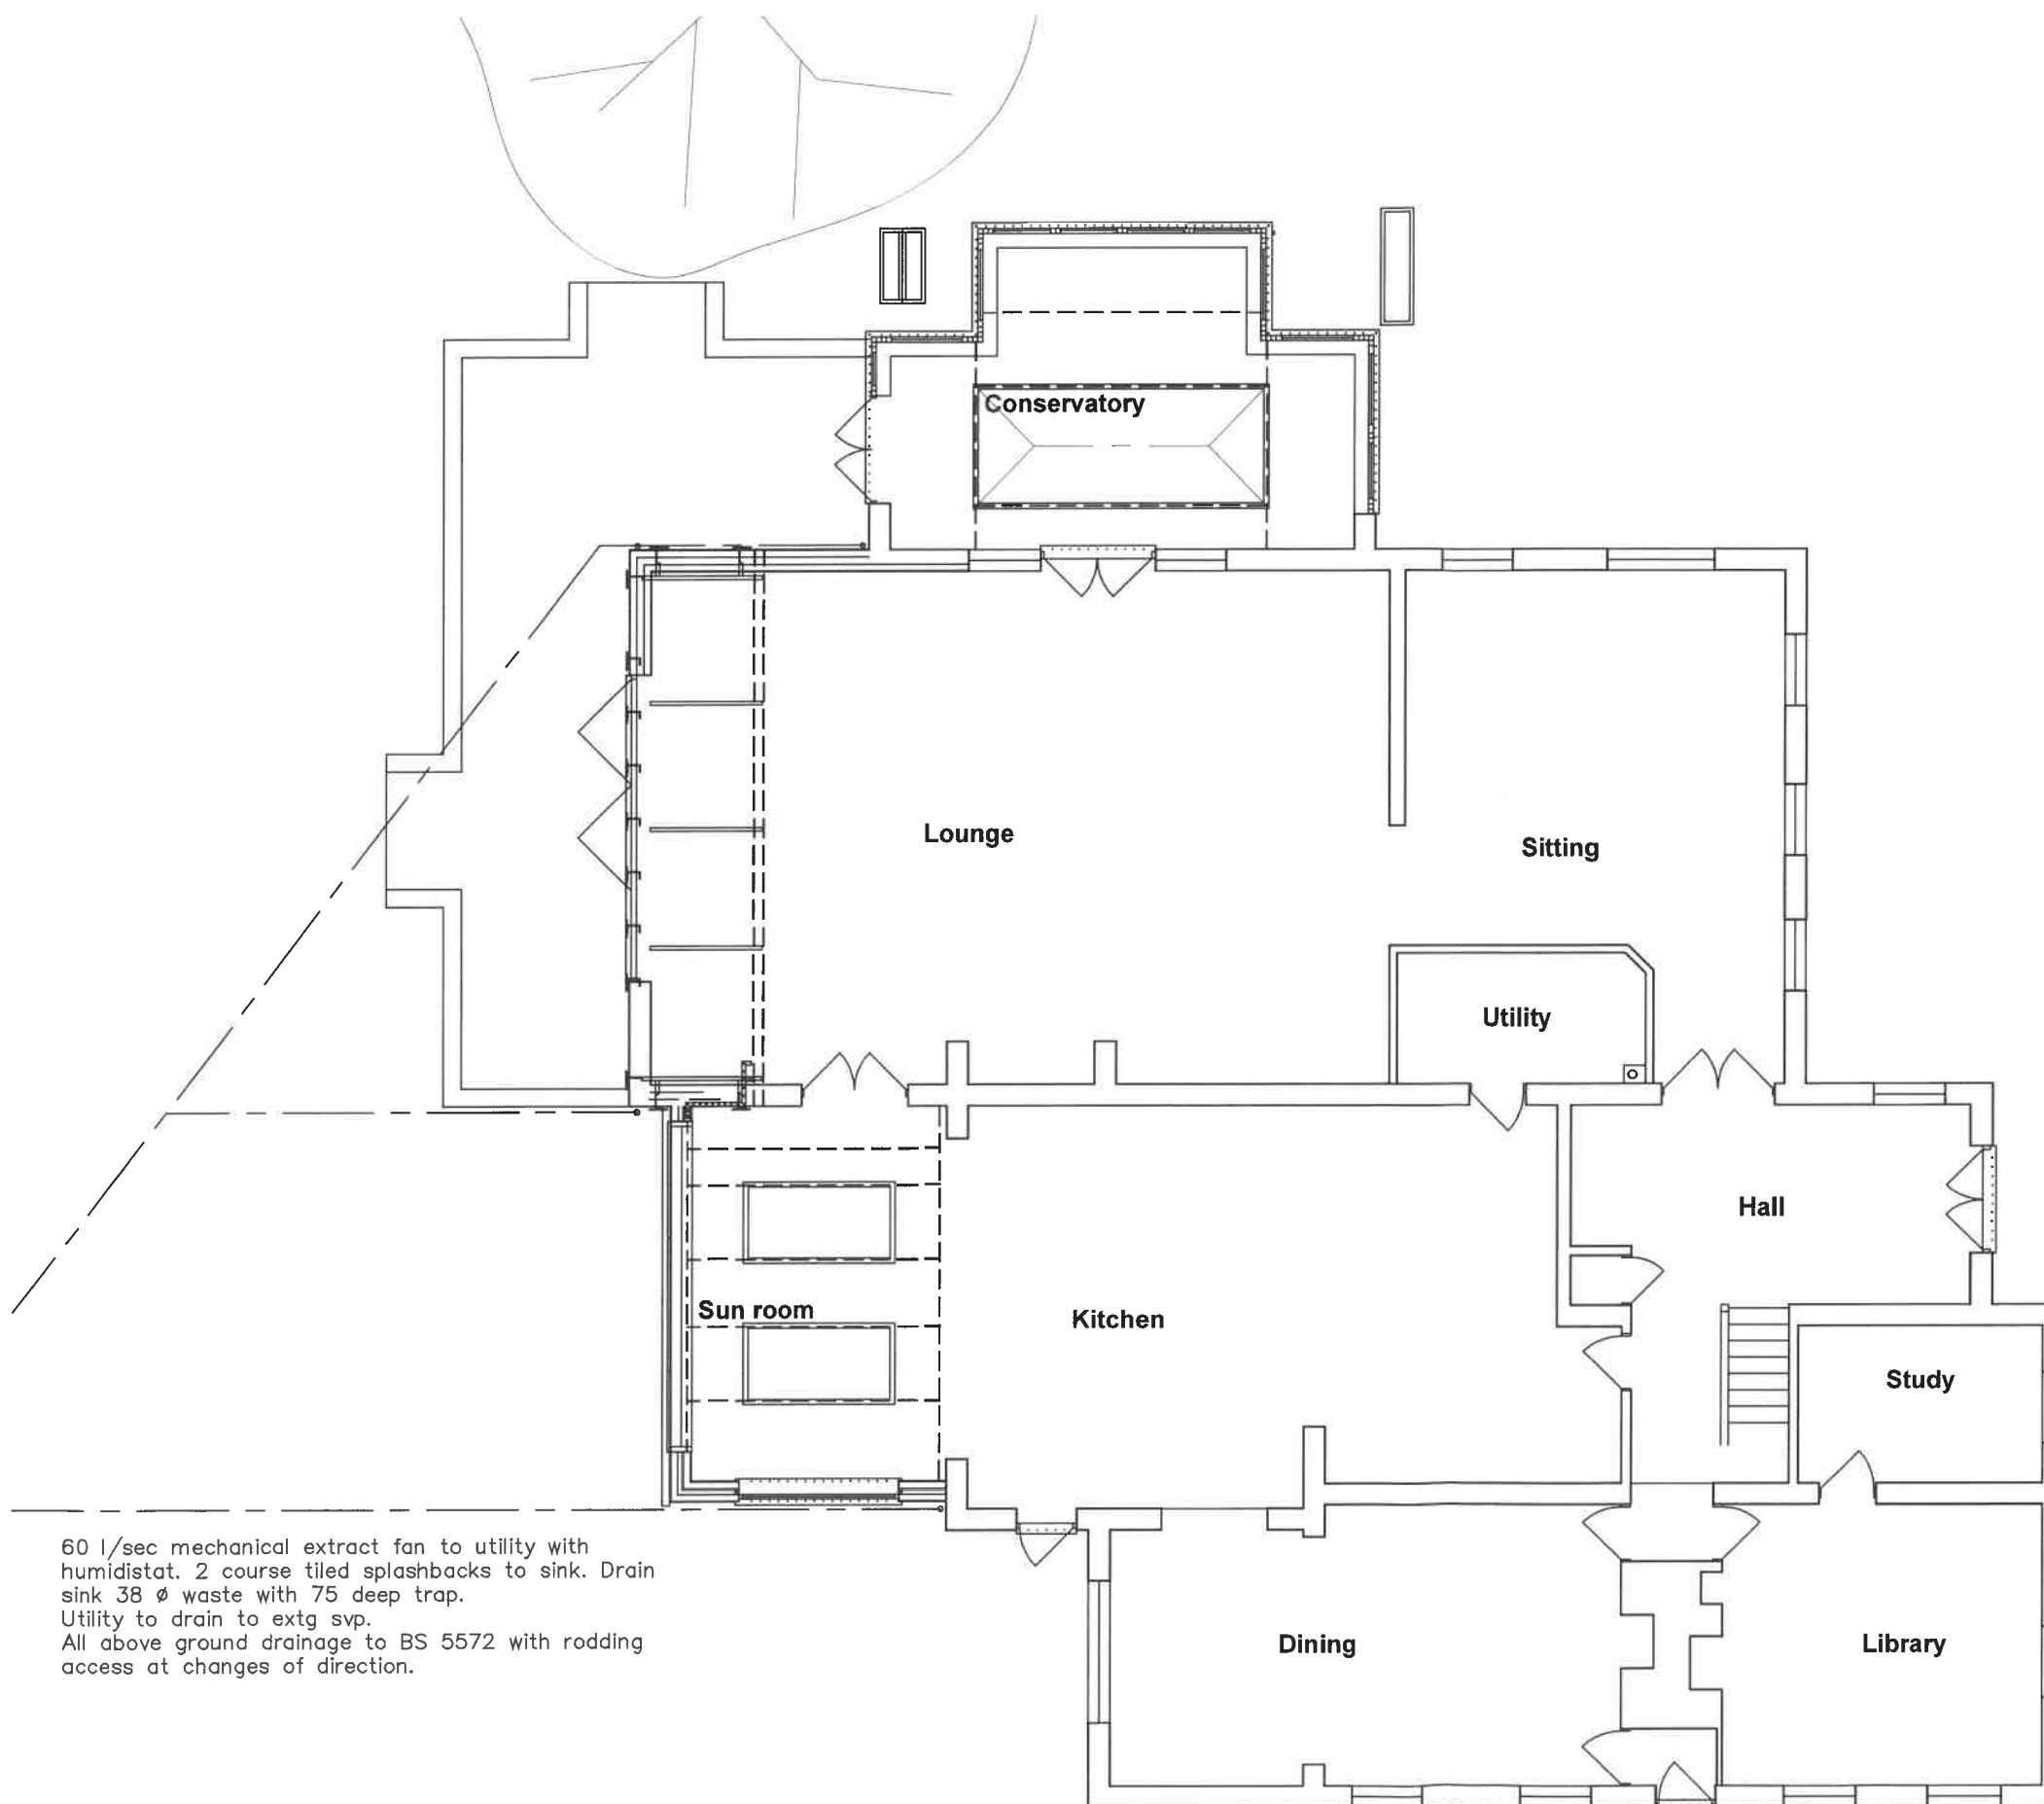

60 l/sec mechanical extract fan to utility with humidistat. 2 course tiled splashbacks to sink. Drain sink 38 Ø waste with 75 deep trap. Utility to drain to extg svp. All above ground drainage to BS 5572 with rodding access at changes of direction.

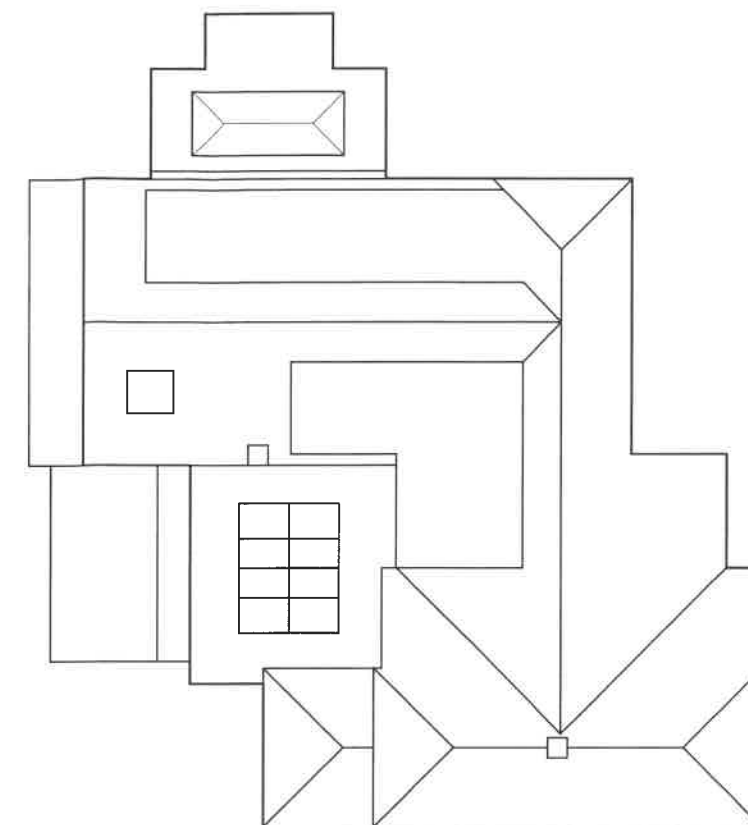

Amendments: —

Bryceson Shaw Surveyors and Design Associates 2 Wellesley Court, Signal Road, Littlehampton, West Sussex BN17 5JW Tel. & Fax 01903 734381 Mobile: 07889 651301 E-mail: brycesonshaw@btinternet.com	
Project: Proposed Sun room; Tortington House, Tortington Lane, Arundel BN18 0BG	
Drawing: Proposed ground floor and roof plans	
For: Mr. Bradley	
Drawn: PKS	Date: August 2013
Scales: 1:100 1:200	No: 1052/01/05/A
To scale when printed on A3	