
 
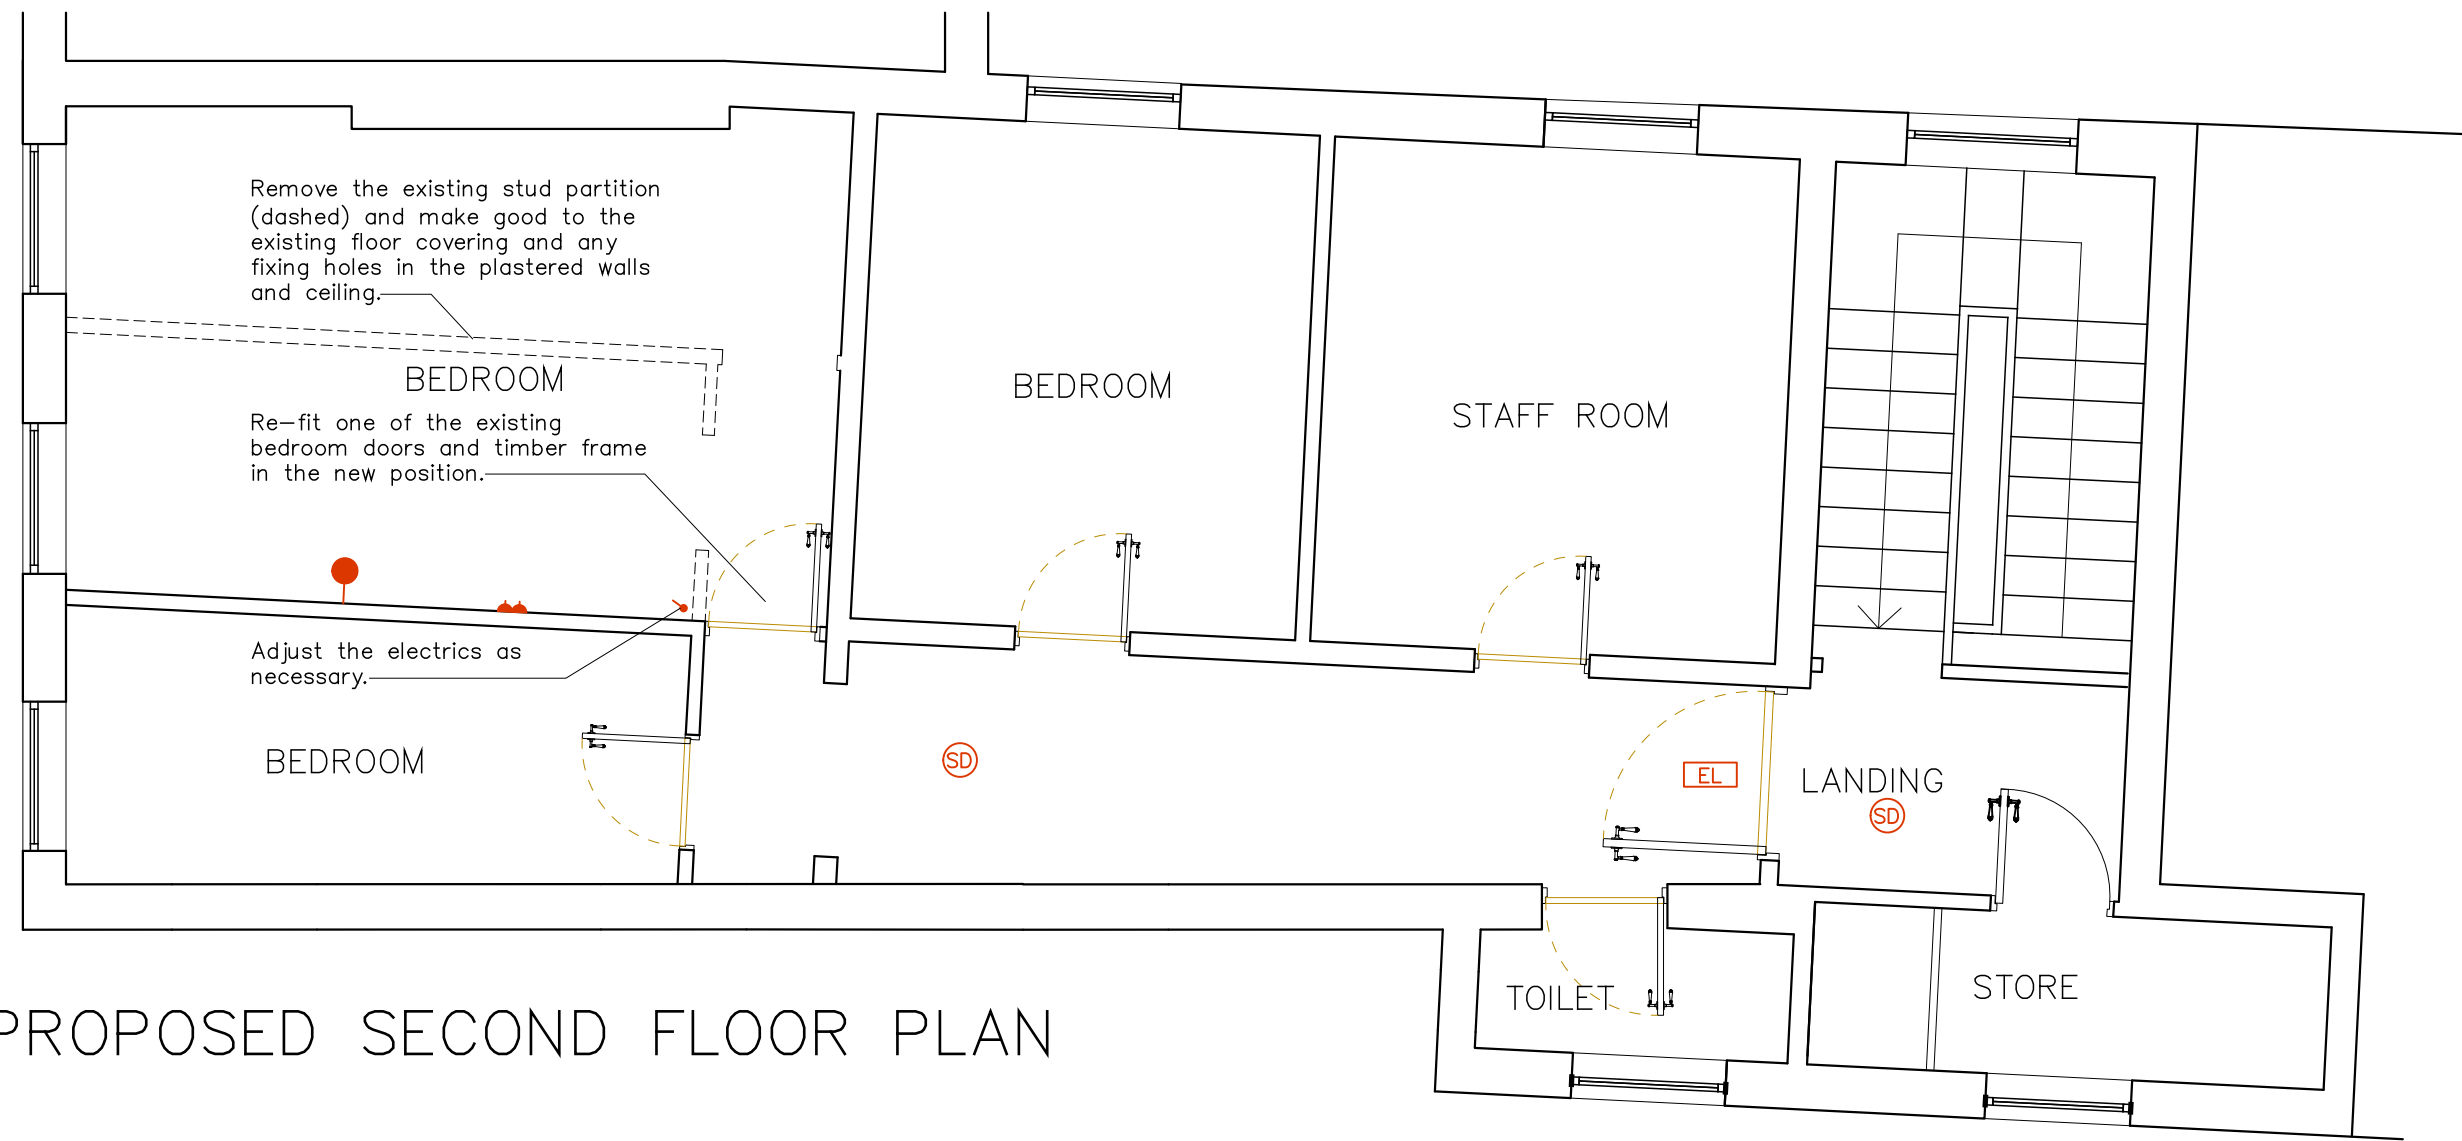




PROPOSED SECOND FLOOR PLAN

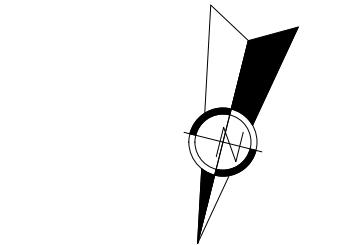

- M&E LEGEND
- STANDARD LIGHT SWITCH
 - INTERNAL WALL LIGHT
 - DOUBLE SOCKET AT LOW LEVEL
 - SD SMOKE DETECTOR
 - EL EMERGENCY LIGHT

PRACTICE NAME JAMES DOLAN ARCHITECT		
TEL: 07505 996340 Email: james.dolan@ntlworld.com		
PROJECT CHINA PALACE 67 HIGH STREET ARUNDEL		
TITLE SECOND FLOOR BEDROOMS		
PROPOSED PLAN		
SCALE 1.50	DATE FEB 2022	DRAWN BY: JD
DWG No. 67HS/2022/03	REVISION	