


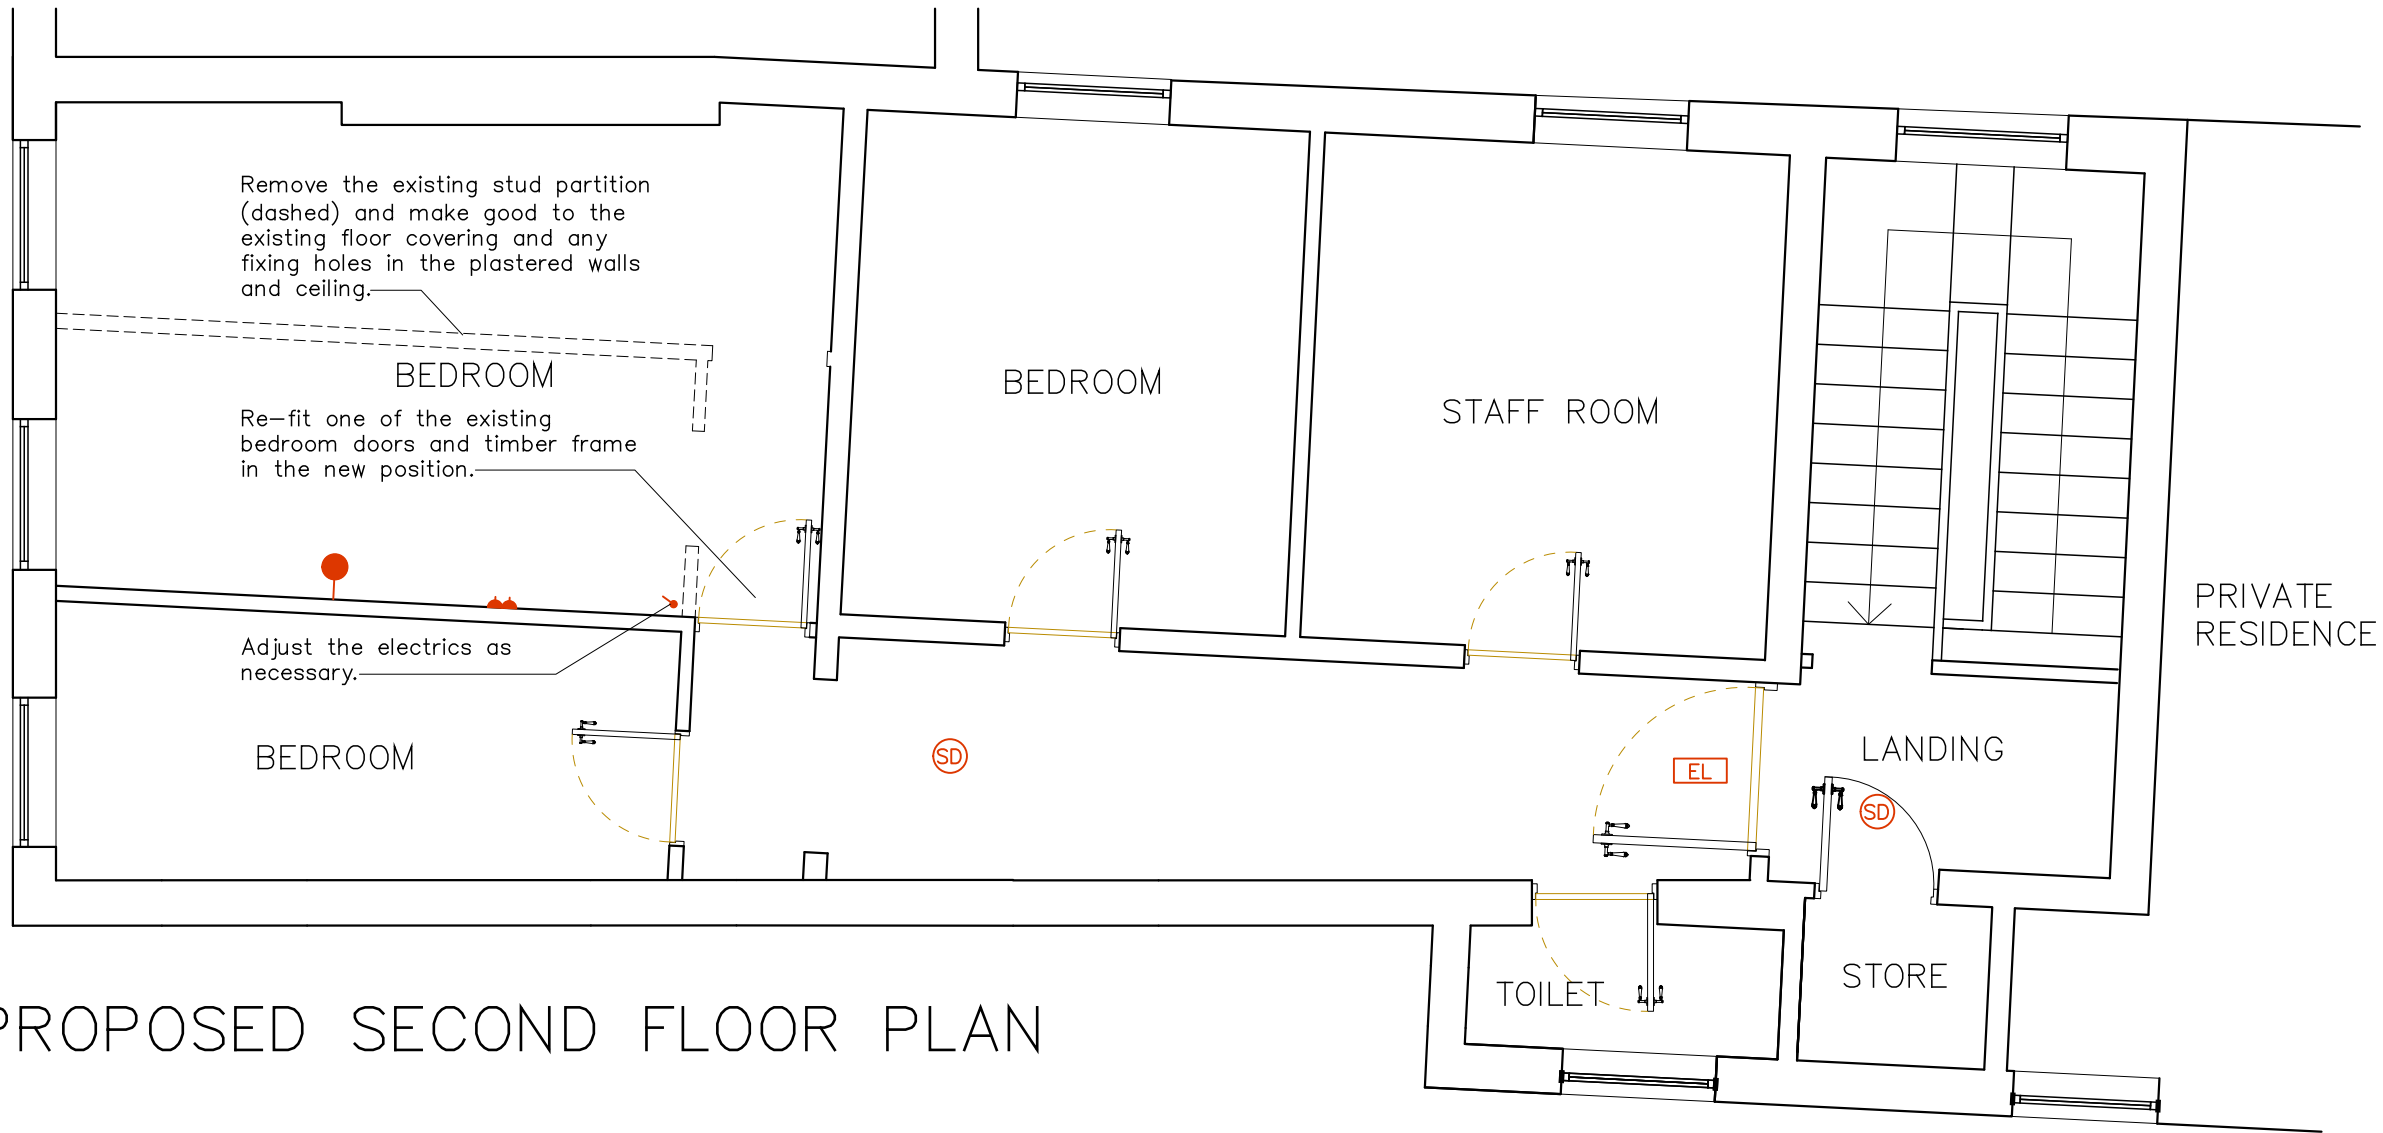

PROPOSED SECOND FLOOR PLAN

0 1 2m

Scale 1:50

M&E LEGEND

- STANDARD LIGHT SWITCH
- INTERNAL WALL LIGHT
- DOUBLE SOCKET AT LOW LEVEL
- SMOKE DETECTOR
- EMERGENCY LIGHT

REV A: APR 2022: SECOND FLOOR PLAN
CORRECTED AT TOP OF STAIRS.

PRACTICE NAME JAMES DOLAN ARCHITECT		
TEL: 07505 996340 Email: james.dolan@ntlworld.com		
PROJECT CHINA PALACE 67 HIGH STREET ARUNDEL		
TITLE SECOND FLOOR BEDROOMS		
PROPOSED PLAN		
SCALE 1.50	DATE FEB 2022	DRAWN BY: JD
DWG No. 67HS/2022/03	REVISION A	