
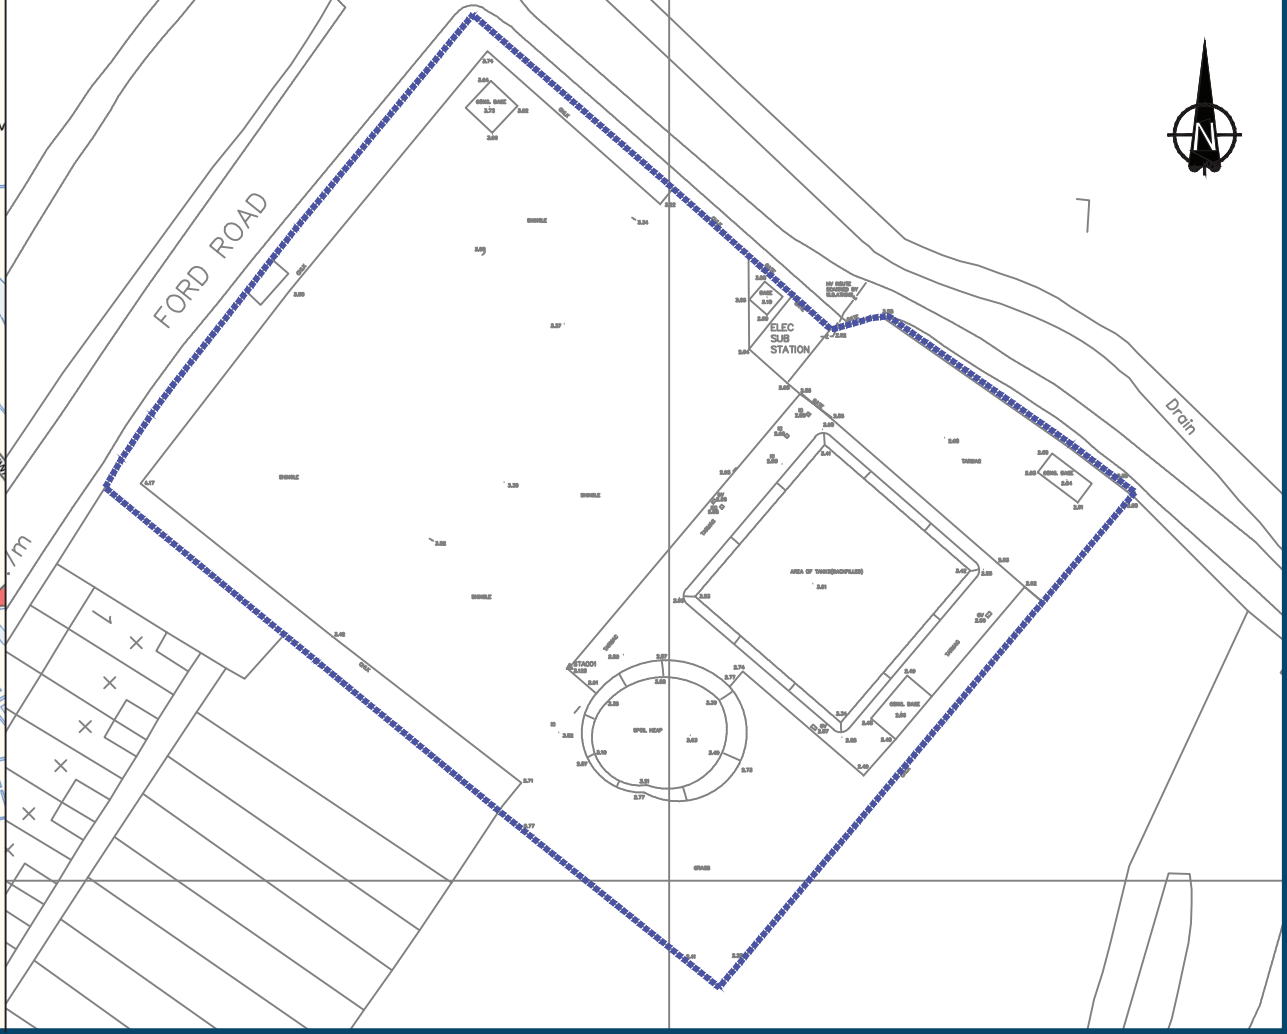


APPENDIX A DRAWINGS

ARUN DISTRICT COUNCIL AB/4521JPL

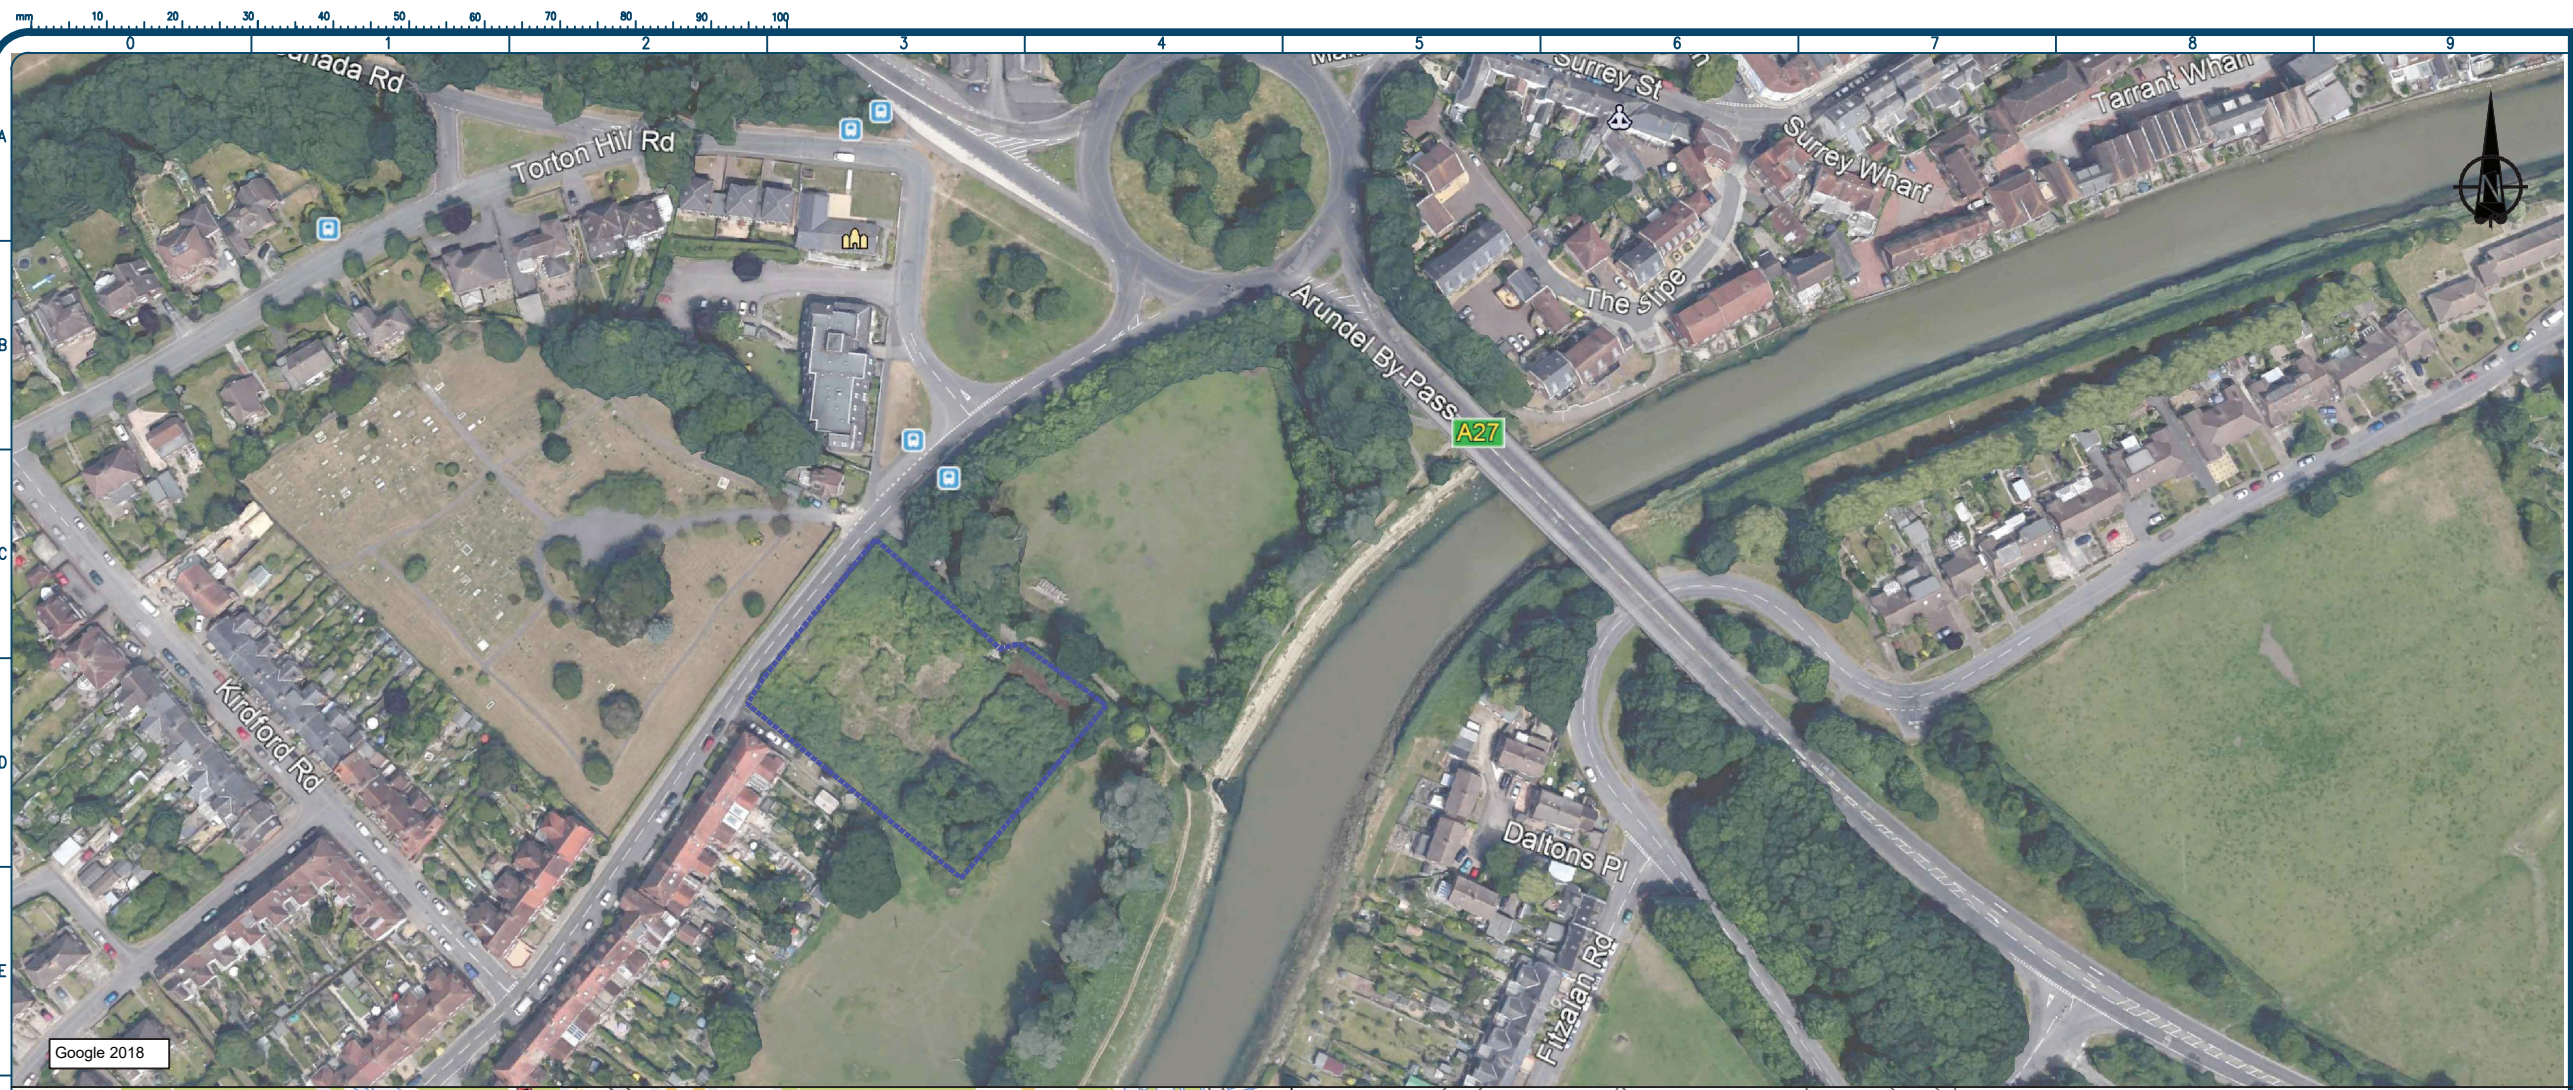

Legend
National Grid Property Holdings Ltd
Site Boundary

0	First Issue	26/10/20
REV	COMMENT	DATE

Celtic enGlobe
Columbus House
Village Way
Cardiff
CF15 7NE
029 2036 8636
Client

enquiries@celtic-ltd.com
www.celtic-ltd.com


nationalgrid

Project
Arundel Gas Works
Ford Road, Arundel
Title
Site Location Plan

Drawn by GEP	Checked Date SG 26/10/20	Authorised Date MH 26/10/20
Original Scale N.T.S	Date 26/10/20	Rev 0
Drawing Number D1820/A1	Paper A3	

Contains Ordnance Survey data © Crown copyright and database right 2016.

CAD REF:-

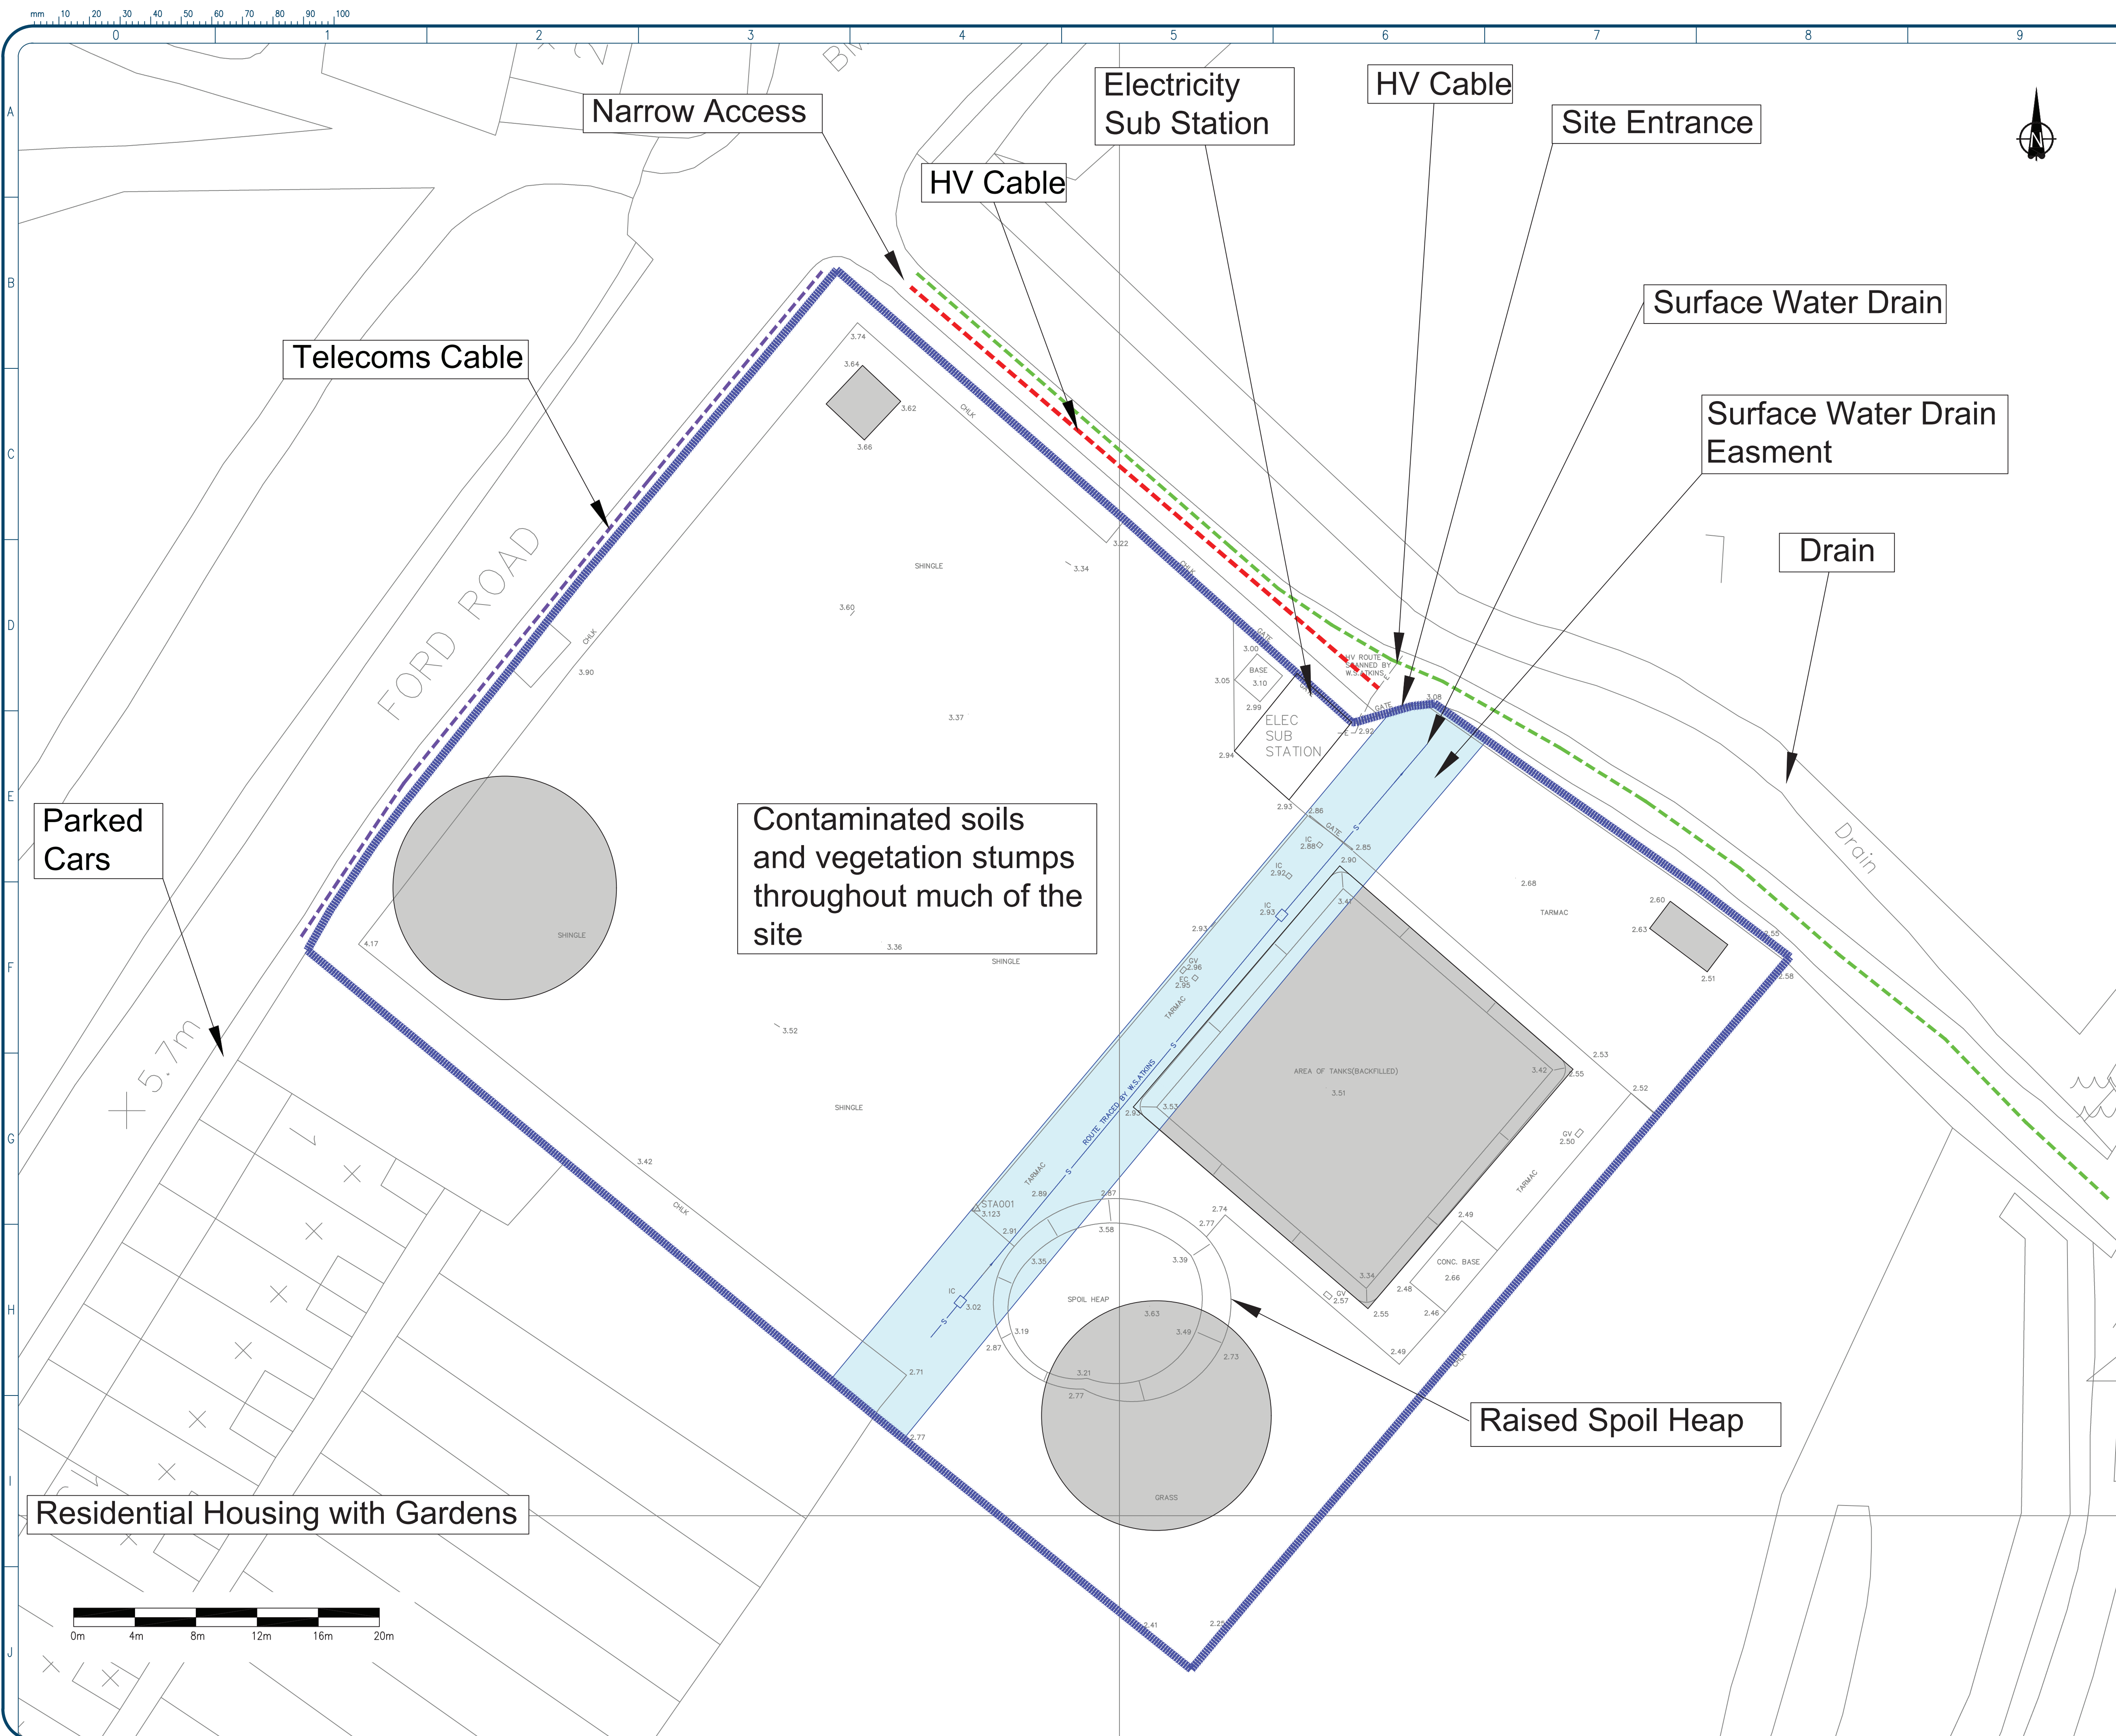

Legend

- National Grid Property Holdings Site Boundary
- Public Right way

0	First Issue	26/10/20
REV	COMMENT	DATE



Columbus House
Village Way
Cardiff
CF15 7NE
029 2036 8636
Client

enquiries@celtic-ltd.com
www.celtic-ltd.com




Project
Arundel Gas Works
Ford Road, Arundel

Title
Site Hazard Plan

Drawn by	Checked	Date	Authorised	Date
GEP	SG	26/10/20	MH	30/11/20

Original Scale	Date	Rev	Paper
1:200	26/10/20	0	A1

Drawing Number
D1820/A2

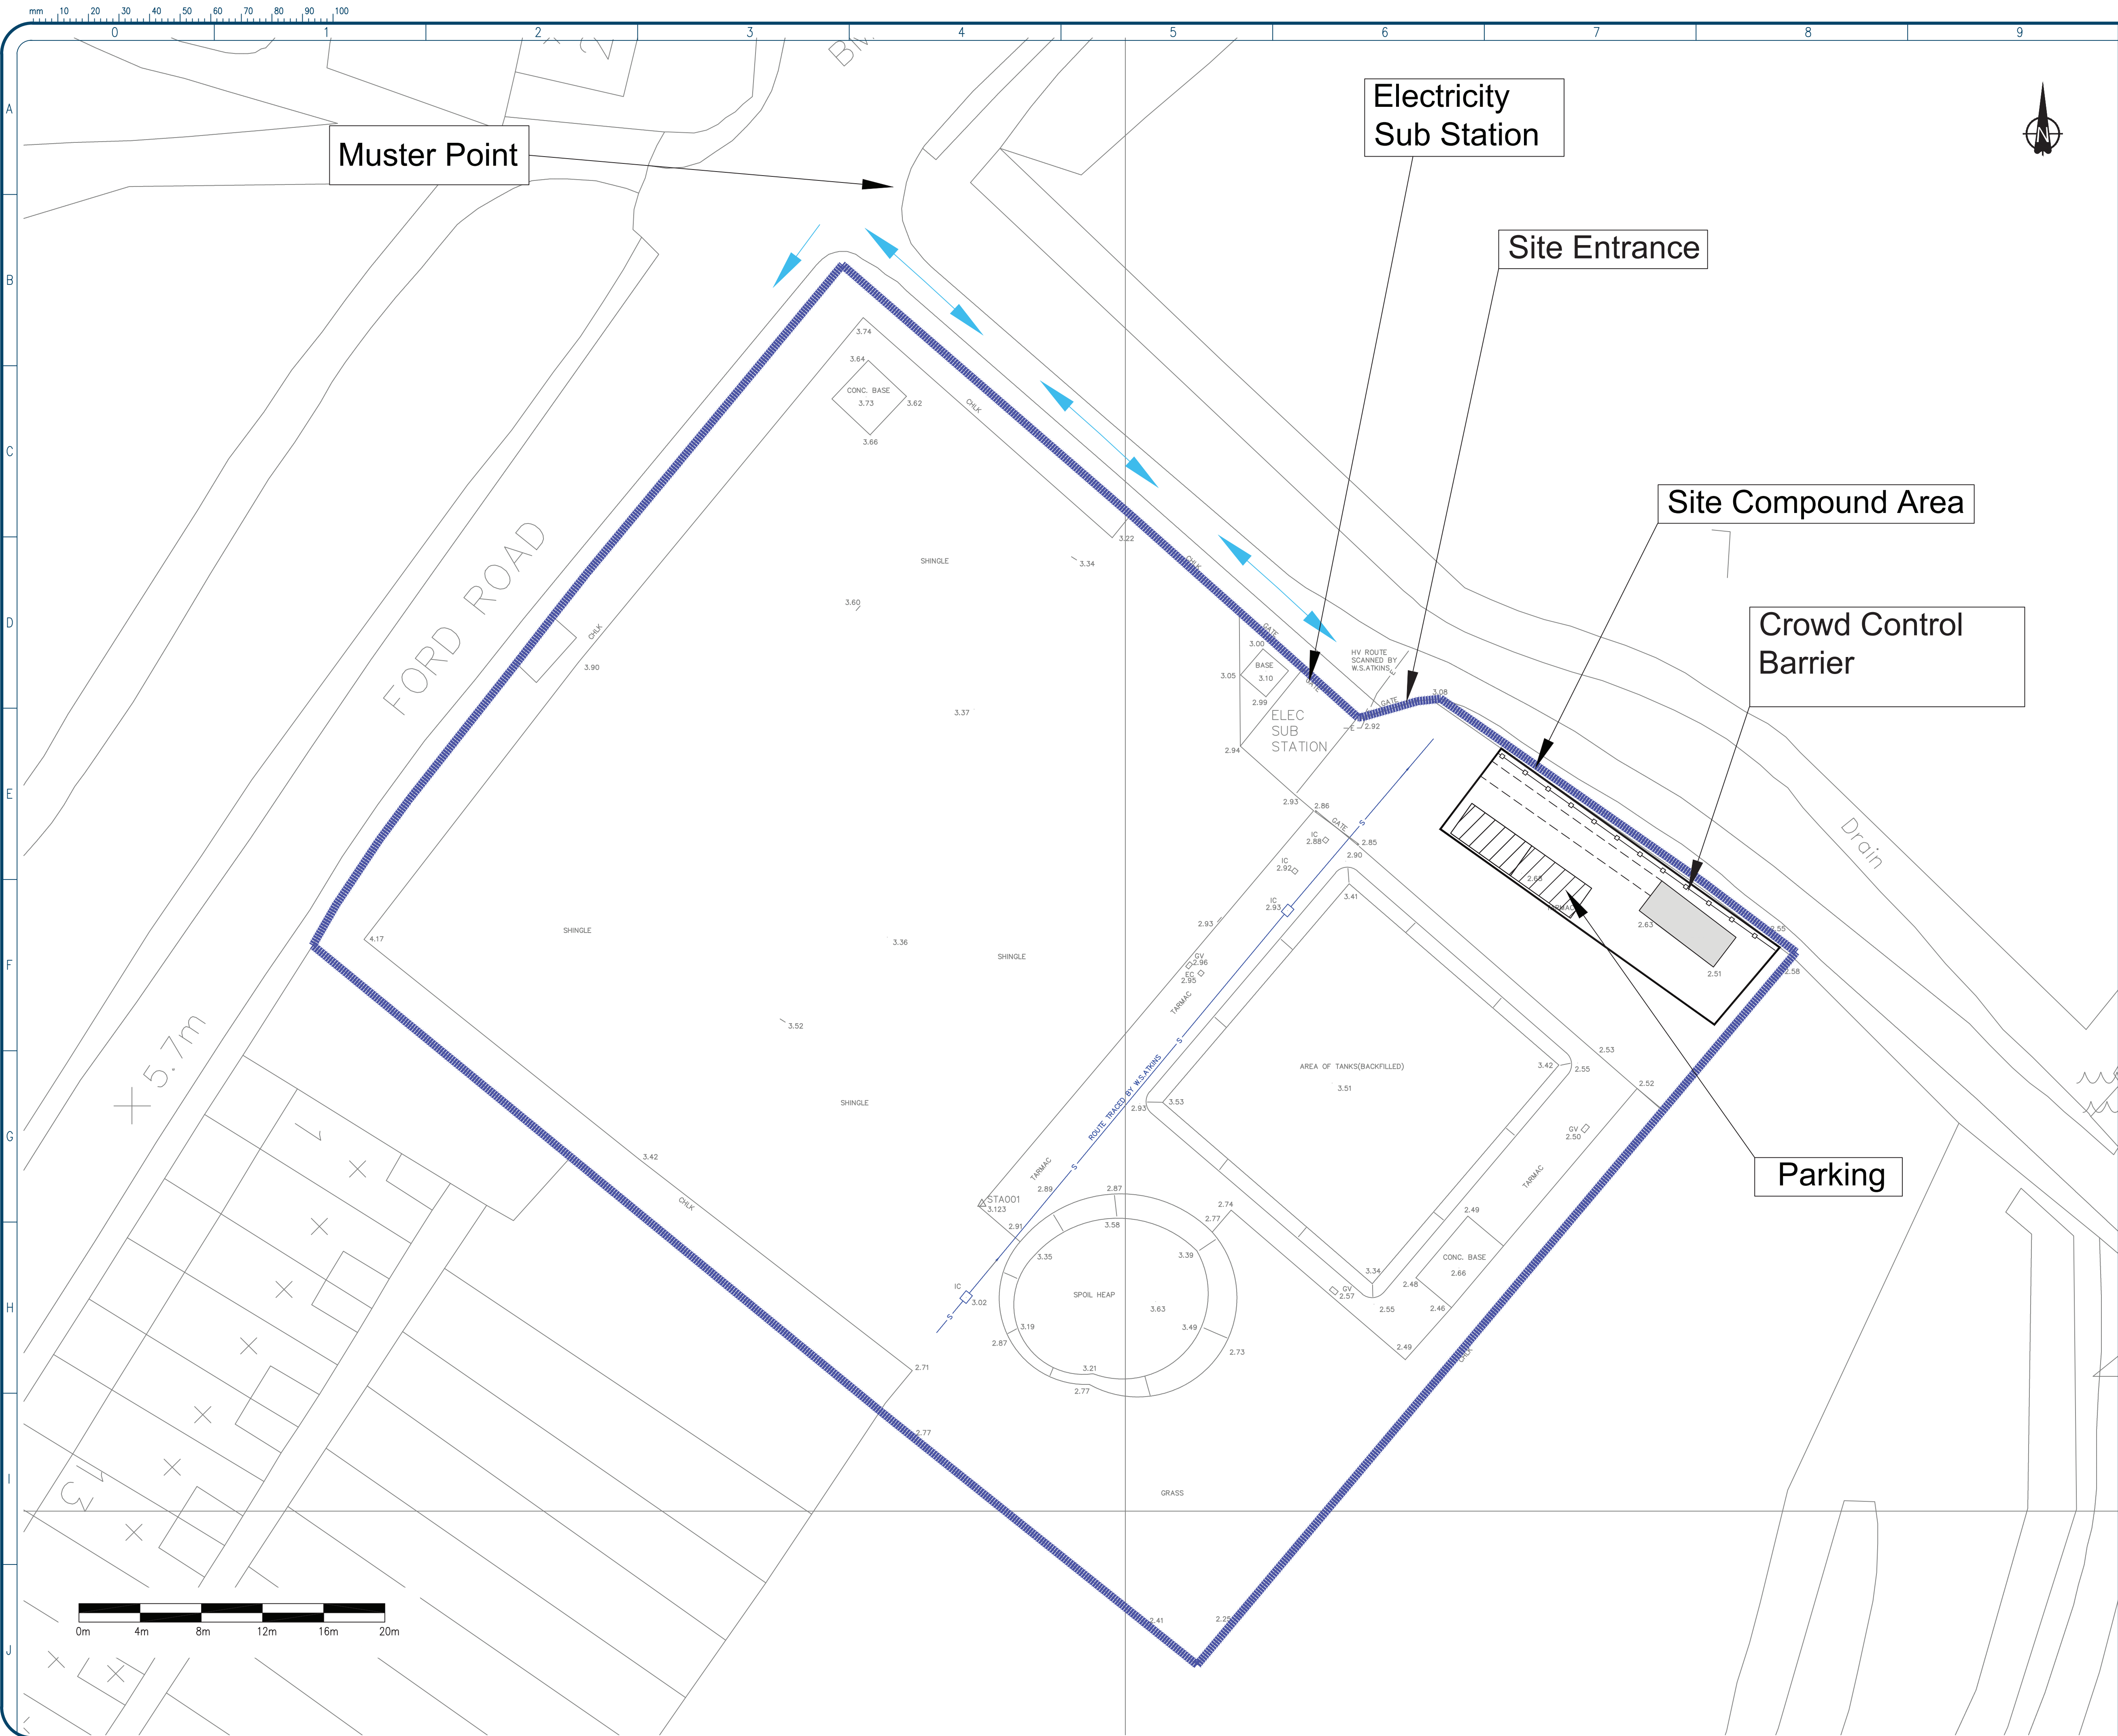

- Legend
- National Grid Property Holdings Site Boundary
 - Celtic Site Compound
 - Welfare Cabin
 - Pedestrian Routes
 - Crowd Control Barrier
 - Access on and off Site

0	First Issue	26/10/20
REV	COMMENT	DATE

Columbus House
Village Way
Cardiff
CF15 7NE
029 2036 8636

enquiries@celtic-ltd.com
www.celtic-ltd.com

Client

Project

Arundel Gas Works
Ford Road, Arundel


Title

Traffic Management Plan

Drawn by CEP	Checked SG	Date 26/10/20	Authorised MH	Date 30/10/20
Original Scale 1:200	Date 26/10/20	Rev 0	Paper A1	

Drawing Number

D1820/A3

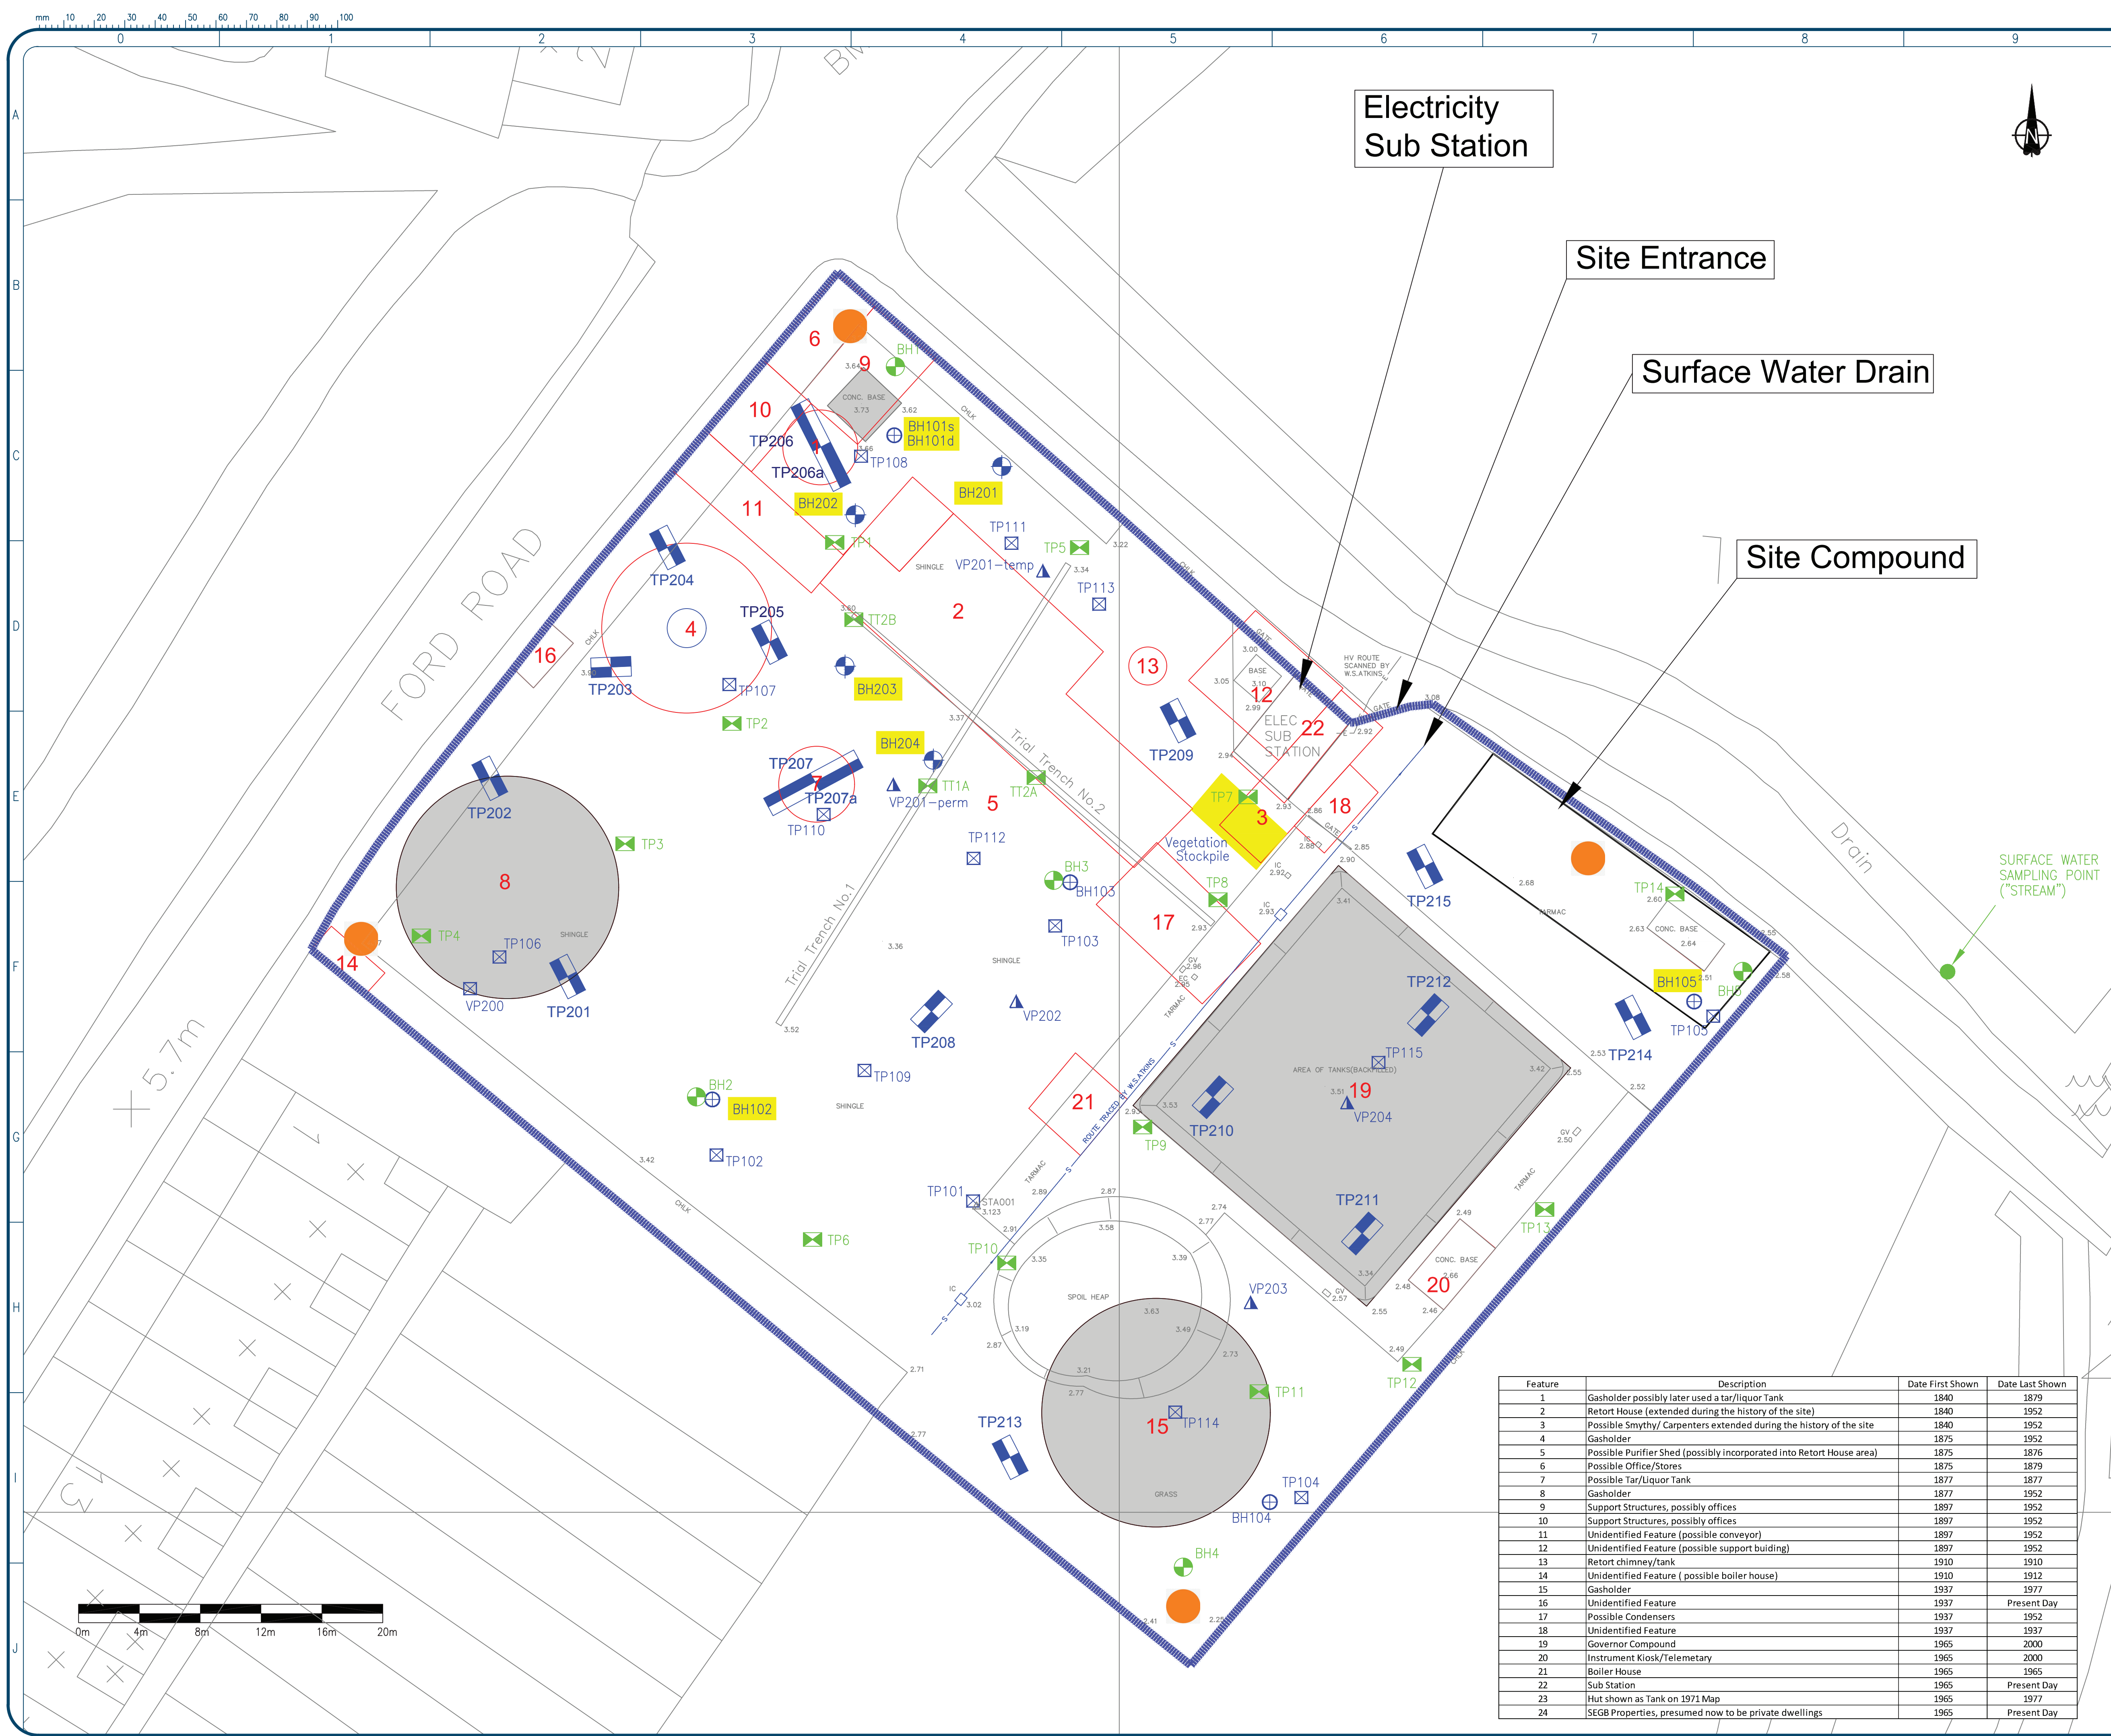

Legend

- National Grid Property Holdings Site Boundary
- Celtic Proposed Trial Pits
- Celtic Proposed Borehole Locations
- 2000 Atkins Borehole Location
- 2000 Atkins Trial Pit Location
- 2000 Trial Trench Location
- 2011 Atkins Borehole Location
- 2011 Atkins Trial Pit Location
- 2011 Vapour Well
- Historical Features
- Proposed Celtic Compound
- Current features on site which require on going protecting
- Environmental Monitoring Point

1	Current features on site that need on going protection	02/12/20
0	First Issue	26/10/20
REV	COMMENT	DATE



Columbus House
Village Way
Cardiff
CF15 7NE
029 2036 8636

enquiries@celtic-ltd.com
www.celtic-ltd.com

Client
nationalgrid


Project
Arundel Gas Works
Ford Road, Arundel

Title
Additional Site Investigation
Locations

Drawn by	Checked	Date	Authorised	Date
GEP	SG	26/10/20	MH	30/10/20
Original Scale	Date	Rev	Paper	
1:200	26/10/20	1	A1	

Drawing Number
D1820/A4

Feature	Description	Date First Shown	Date Last Shown
1	Gasholder possibly later used a tar/liquor Tank	1840	1879
2	Retort House (extended during the history of the site)	1840	1952
3	Possible Smythy/ Carpenters extended during the history of the site	1840	1952
4	Gasholder	1875	1952
5	Possible Purifier Shed (possibly incorporated into Retort House area)	1875	1876
6	Possible Office/Stores	1875	1879
7	Possible Tar/Liquor Tank	1877	1877
8	Gasholder	1877	1952
9	Support Structures, possibly offices	1897	1952
10	Support Structures, possibly offices	1897	1952
11	Unidentified Feature (possible conveyor)	1897	1952
12	Unidentified Feature (possible support building)	1897	1952
13	Retort chimney/tank	1910	1910
14	Unidentified Feature (possible boiler house)	1910	1912
15	Gasholder	1937	1977
16	Unidentified Feature	1937	Present Day
17	Possible Condensers	1937	1952
18	Unidentified Feature	1937	1937
19	Governor Compound	1965	2000
20	Instrument Kiosk/Telemetry	1965	2000
21	Boiler House	1965	1965
22	Sub Station	1965	Present Day
23	Hut shown as Tank on 1971 Map	1965	1977
24	SEGB Properties, presumed now to be private dwellings	1965	Present Day

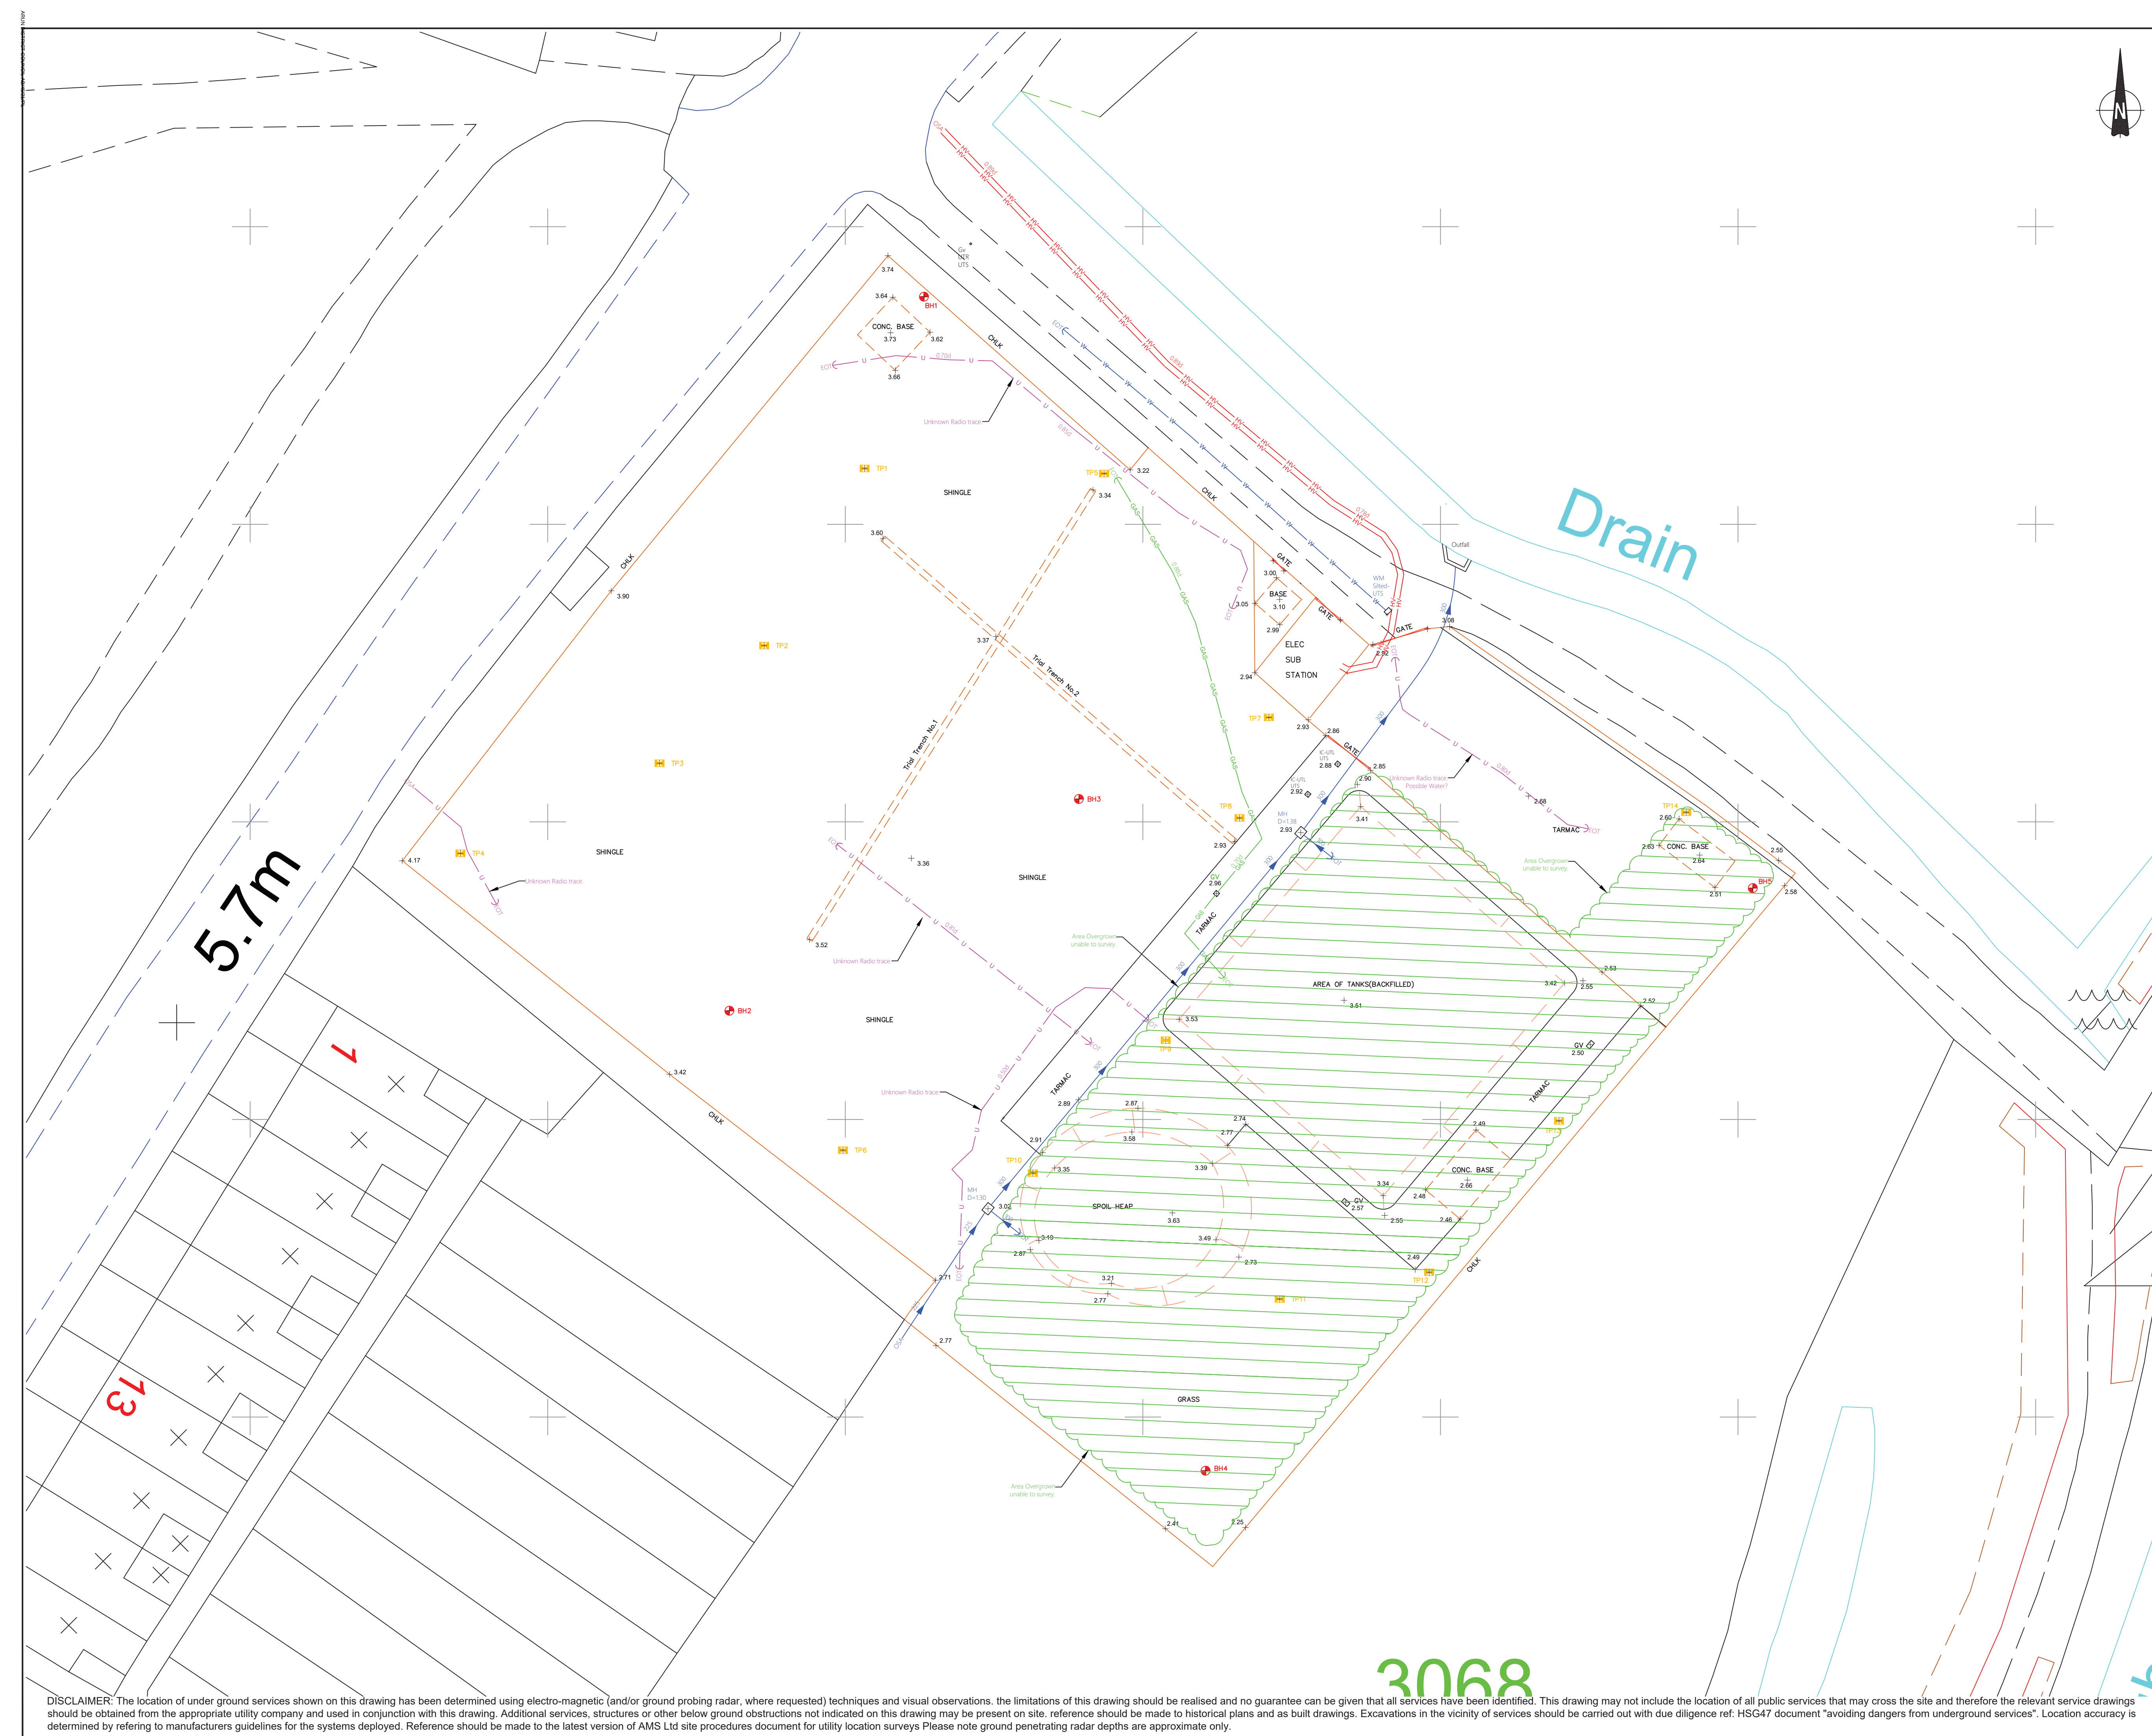

LEGEND

	Foul Drainage
	Surface Drainage
	Combined Drainage
	Electricity
	Electricity High Voltage
	Electricity Low Voltage
	Gas
	Cable Probing Radar
	Water
	Cable Television
	Close Circuit Television
	Communication
	British Telecom
	Compressed Air
	Offset Fill-Line
	Oil Pipe
	Pipe
	Ventilation
	Fuel Line
	Vapour Recovery
	Gauge Line
	Telemetry
	Fibre Optics
	Unknown
	Fence
	Edge of Canopy
	Gully Run
	End Of Trace
	Do Not Drill / Banded Pipes
	Borehole
	Trial Pit Location
	Excavated Area
	Window Sample
	Soil Vapour Sample

T TANK* - W= Water U=Unknown
F=Foam P=Product C=Concrete

ABBREVIATIONS

AR	Assumed Route	MW	Monitoring Well
BO	Bollard	NPV	No Pipes Visible
BOILL	Illuminated Bollard	OH	Overhead Service
BH	Borehole	OSA	Off Survey Area
BT	British Telecom Box	OSM	Ordnance Survey Bench Mark
BTIC	British Telecom Cover	PR	Pipe Riser
C/BOX	Cable Control Box	P	Post
C/B Fence	Closeboard Fence	P&R Fence	Spot & Rail Fence
CR	Cable Riser	RET WALL	Retaining Wall
CATV	Cable TV	RWP	Rain Water Pipe
CP	Catch Pit	RS	Road Sign
Co	Concrete	RE	Redding Eye
CON	Conifer	S/A	Soakaway
CL	Cover Level	S/BIRCH	Silver Birch
d	Depth (in metres)	SAP	Sapling
D/CHAN	Drainage Channel	SEC/FENCE	Security Fence
DP	Down Pipe	SL	Spot Light
ER	Earth Road	SP	Soil Pipe
EIC	Electricity IC	ST	Stop Tap
EP	Electricity Pole	SV	Sluice Valve
EOC	Edge of Canopy	SVP	Soft Vent Pipe
EOT	End of Trace	SVS	Soft Vapour Sample
F/BED	Flower Bed	TBM	Temporary Bench Marks
FI	Fire Hydrant	TRF	Taken From Records
FS	Fire Switch	TL	Traffic Light
GV	Gas Valve	TP	Telephone Pole
G	Gully	TS	Traffic Sensor
GPR	Ground Probing Radar	U/L	Unable to Locate
GRUN	Gully Run	UTL	Unable to Trace
HT	Height	UTS	Unable to Survey
H/CHESTNUT	Horse Chestnut	UTT	Unable to Trace
H/THORN	Hawthorn	VP	Vapour Recovery
IC	Inspection Cover	VM	Vent Pipe
IL	Invert Level	WM	Water Meter
INT	Interceptor	WFC	Water Filled Chamber
KO	Kno Outlet	WP	Waste Pipe
LP	Lamp Post	WR	Water Riser
LC	Lighting Column	WS	Window Sample
LH	Lamp Hole	U/S	Underside
MH	Manhole Cover	Ø	Pipe Diameter

General Notes:

Part of site overgrown at time of survey. UTS this area.

No Water or drainage guides available at time of survey.

Possible buried IC's on site.

Possibility of former infrastructure still underground



32 Doncaster Road, Barnsley, South Yorkshire, S70 1TL.
Tel: 01226 292 377 Mobile: 07969 360287
E-Mail: scott@avoynmaasurveys.com & info@avoynmaasurveys.com
Website: www.avoynmaasurveys.com

Client


CELTIC

Site Location

Gas Works
Ford Road
Arundel, BN18 9DX

Surveyed by AC	Drawn by AC	Approved by _
Drawing No. 1120/Celtic/8244		Revision -
Scale 1:200@ A1	Date 10/11/2020	Sheet No. 1 of 1

DISCLAIMER: The location of underground services shown on this drawing has been determined using electro-magnetic (and/or ground probing radar, where requested) techniques and visual observations. The limitations of this drawing should be realised and no guarantee can be given that all services have been identified. This drawing may not include the location of all public services that may cross the site and therefore the relevant service drawings should be obtained from the appropriate utility company and used in conjunction with this drawing. Additional services, structures or other below ground obstructions not indicated on this drawing may be present on site. reference should be made to historical plans and as built drawings. Excavations in the vicinity of services should be carried out with due diligence ref: HSG47 document "avoiding dangers from underground services". Location accuracy is determined by referring to manufacturers guidelines for the systems deployed. Reference should be made to the latest version of AMS Ltd site procedures document for utility location surveys Please note ground penetrating radar depths are approximate only.

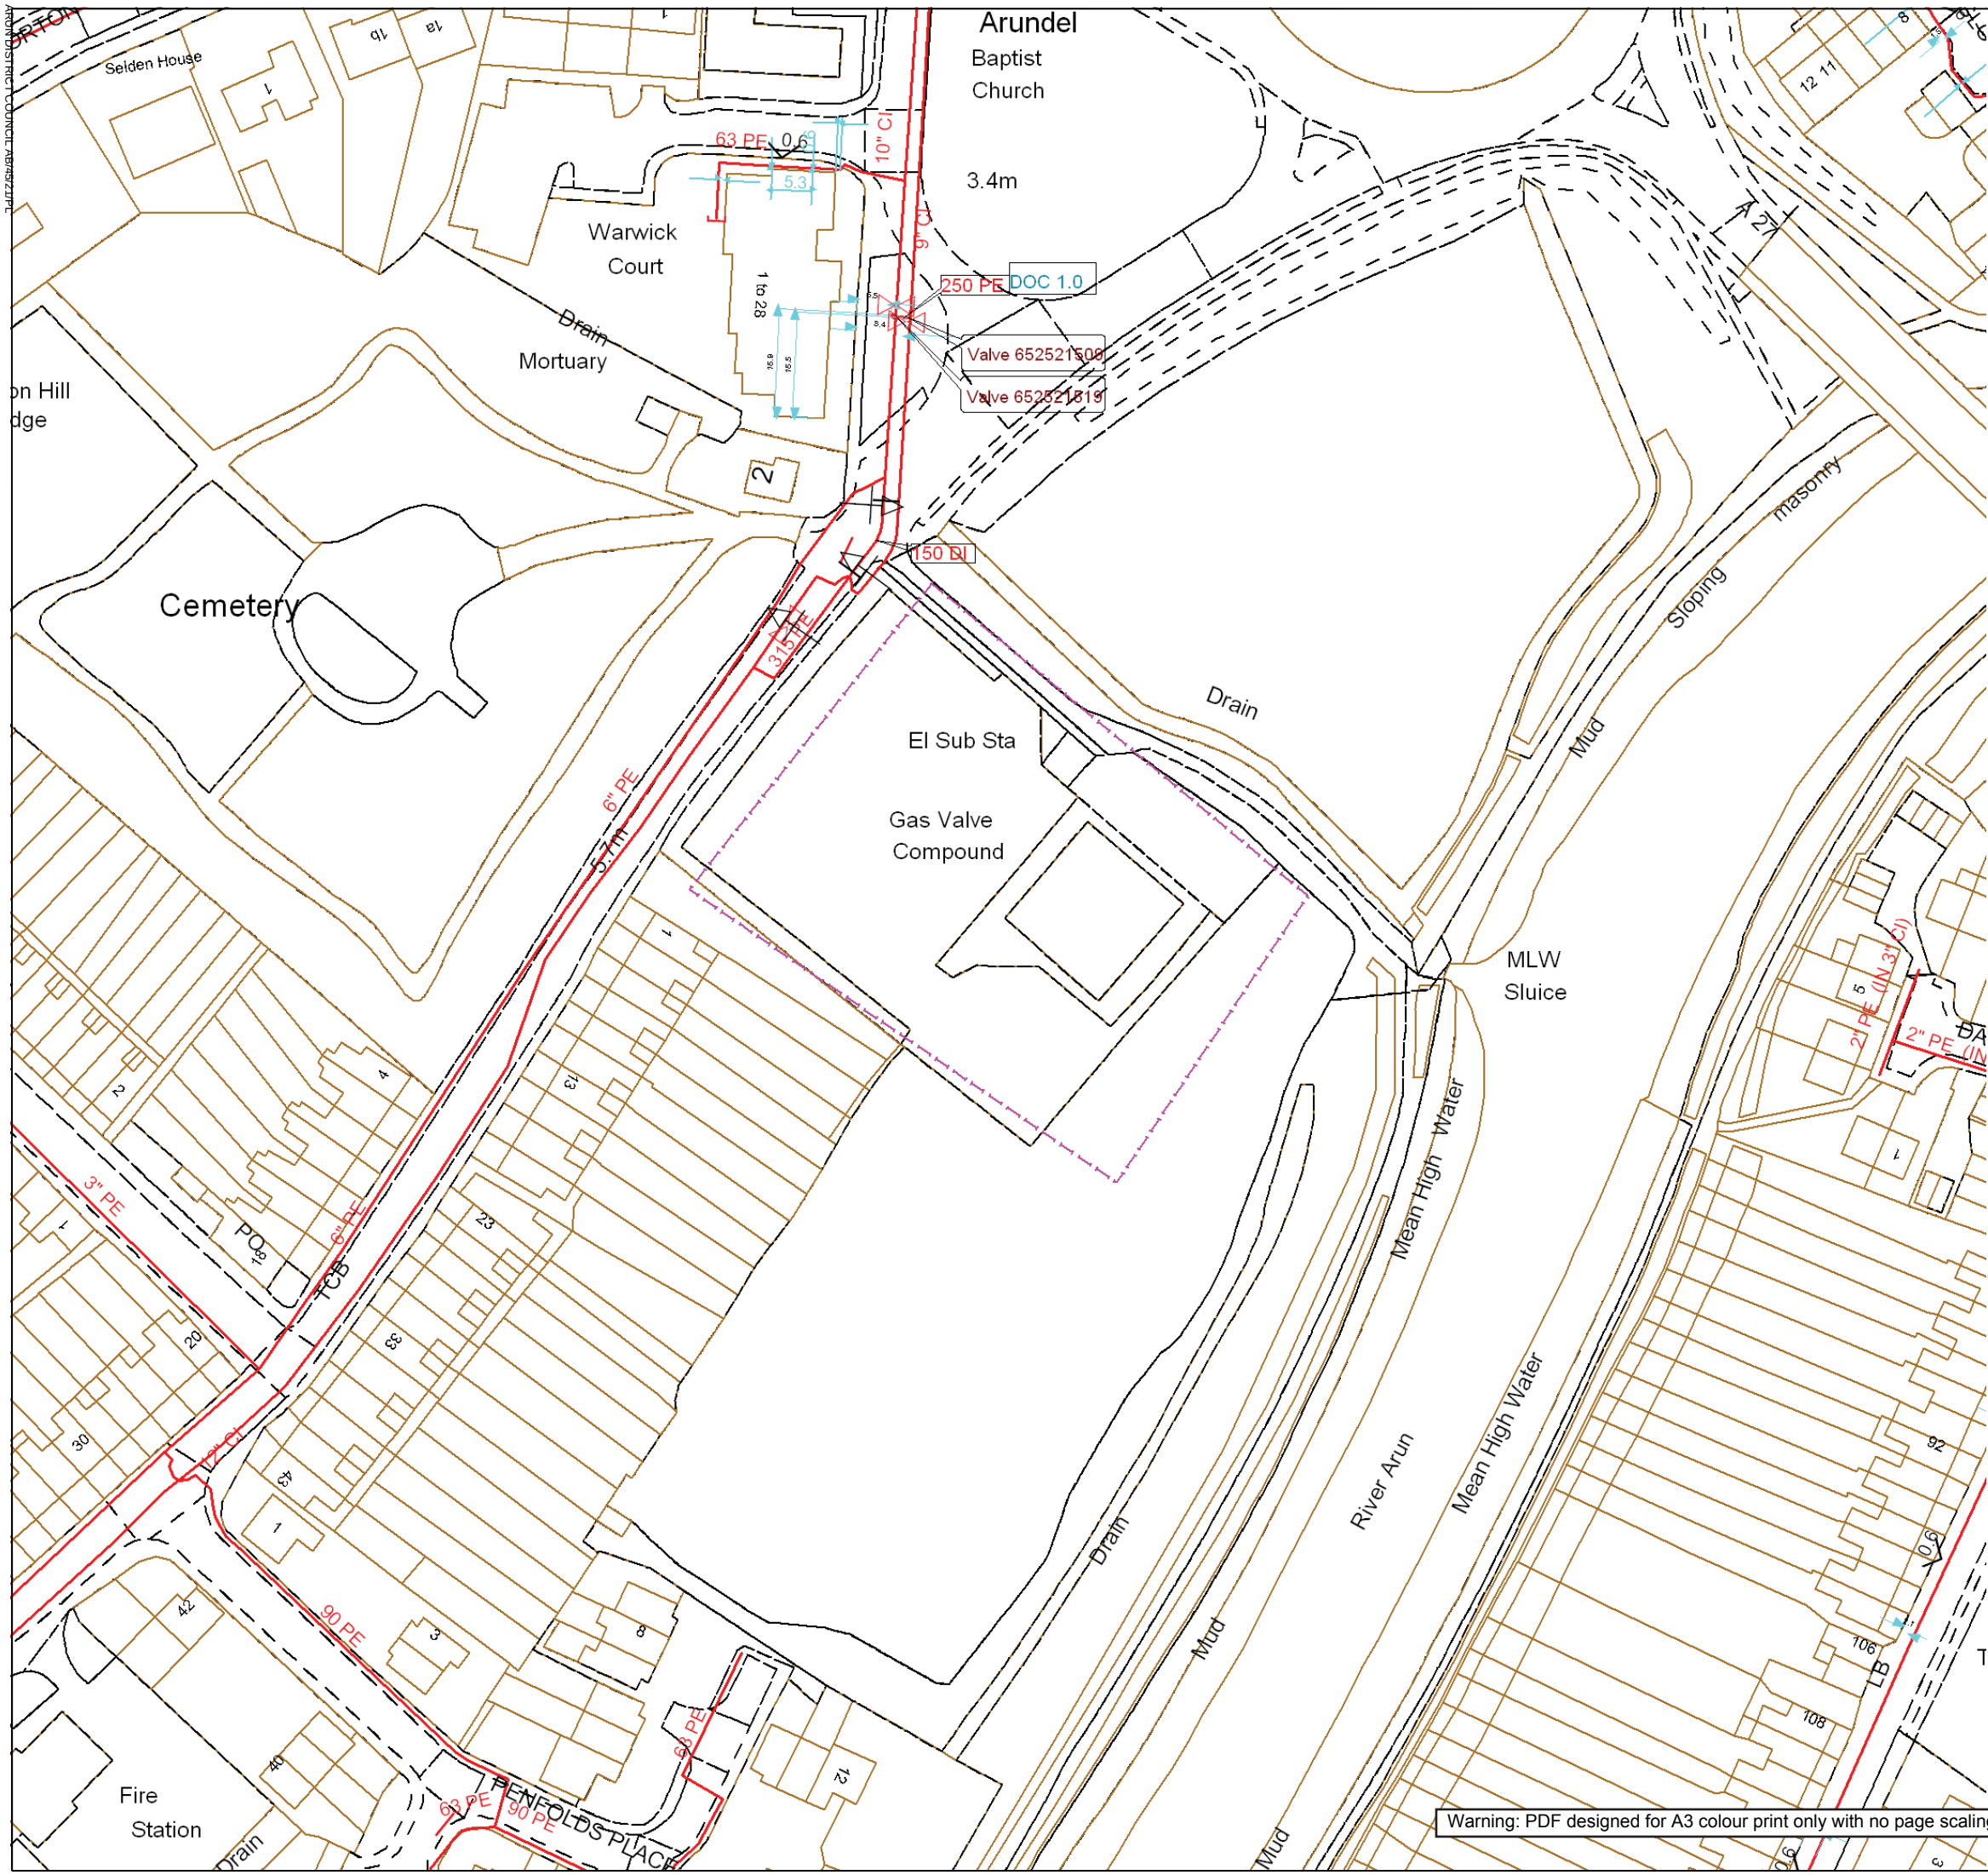

Contact Us
Mapping Enquiries:
All areas

General Enquiries:
All areas

Date Requested: 26/10/2020
Job Reference: 20319776
Site Location: 501300 106732
Requested by:
Mr Steven Gronow
Your Scheme/Reference:
C1820
Exact Scales:
1:1000 Area or Circle dig site
1:1000 Line dig site

This plan shows the location of those pipes owned by Scotia Gas Networks (SGN) by virtue of being a licensed Gas Transporter (GT). Gas pipes owned by other GTs or third parties may also be present in this area but are not shown on this plan. Information with regard to such pipes should be obtained from the relevant owners. No warranties are given with regard to the accuracy of the information shown on this plan. Service pipes, valves, siphons, sub-connections etc. are not shown but their presence should be anticipated. You should be aware that a small percentage of our pipes/assets may be undergoing review and will temporarily be highlighted in yellow. If your proposed works are close to one of these pipes, you should contact the SGN Safety Admin Team on 0800 912 1722 for advice. No liability of any kind whatsoever is accepted by SGN or its agents, servants or sub-contractors for any error or omission contained herein. Safe digging practices, in accordance with HS (G)47, must be used to verify and establish the actual position of mains, pipes, services and other apparatus on site before any mechanical plant is used. It is your responsibility to ensure that plant location information is provided to all persons (whether direct labour or sub-contractors) working for you on or near gas apparatus. Information included on this plan should not be referred to beyond a period of 28 days from the date of issue.

Report damage immediately – KEEP EVERYONE AWAY FROM THE AREA
0800 111 999

Low Pressure Mains

Medium Pressure Mains

Intermediate Pressure Mains

High Pressure Mains

LAs

GTs

Some Examples Of Plant Items

Valve

Syphon

Depth of Cover

Diameter Change

Material Change

Digsite: Line: Area:



This plan is reproduced from or based on the OS map by Scotia Gas Networks plc, with the sanction of the controller of HM Stationery Office. Crown Copyright Reserved. Southern Gas – 100044373 and Scotland Gas – 100044366.

Overview map of worksite

Warning: PDF designed for A3 colour print only with no page scaling

Dig Sites Area:  Line: 

Date Requested: 26/10/2020
Job Reference: 20319776
Site Location: 501301 106731
Requested by:
Mr Steven Gronow
Your Scheme/Reference:
C1820

Scale: 1:1025 (When plotted at A3)

WARNING

There may have been subsequent alteration to the surface levels. Trial holes must be undertaken to determine position and depths of cables. HS (G) 47 Booklet from the Health and Safety Executive – Avoiding Danger from Buried Cables – should be consulted before commencing excavation work.

WHEN WORKING IN THE VICINITY OF OVERHEAD LINES THE HEALTH AND SAFETY GUIDANCE NOTES GS6 SHOULD BE CONSULTED (AVAILABLE FROM THE HSE WEBSITE)

Voltages (V)	
LV (Low Voltage) and Services	Up to 1,000V
HV (High Voltage)	Over 1,000V to 11,000V
EHV (Extra High Voltage)	22,000V to 132,000V
Transmission	275,000V and 400,000V

NORMAL DEPTH TO THE TOP OF THE CABLE WHEN LAID

	Services	LV	HV	EHV
Footpath/Unmade	0.45m	0.45m	0.6m	0.8m
Road Crossing	0.6m	0.6m	0.75m	0.9m
Agricultural	1m	1m	1m	1.1m

Legend	
	Service Cable
	LV Mains
	2 – 3.3kV
	6.6kV
	11kV
	22kV
	33kV
	66kV
	132kV
	275kV
	400kV
	Fibre Optic
	Pilot Cable


Distribution Structures (Electric)	
	Pole, Existing Location
	Pole Structure, Existing Location - Single
	Pole Structure, Existing Location - H
	Duct Route
	Cross Section Route



Scottish and Southern Energy Power Distribution Ltd.
Registered Office: Inverlorn House,
200 Dunkeld Road, Perth, PH1 3AQ
Registered in Scotland No. SC213459

If you're unsure & need to seek advice before commencing excavations please contact:
General Enquiries: 0800 048 3516

Subject to revision – Master held by SSEN Asset Data Team:
Asset.Data@sse.com
01256 337 294

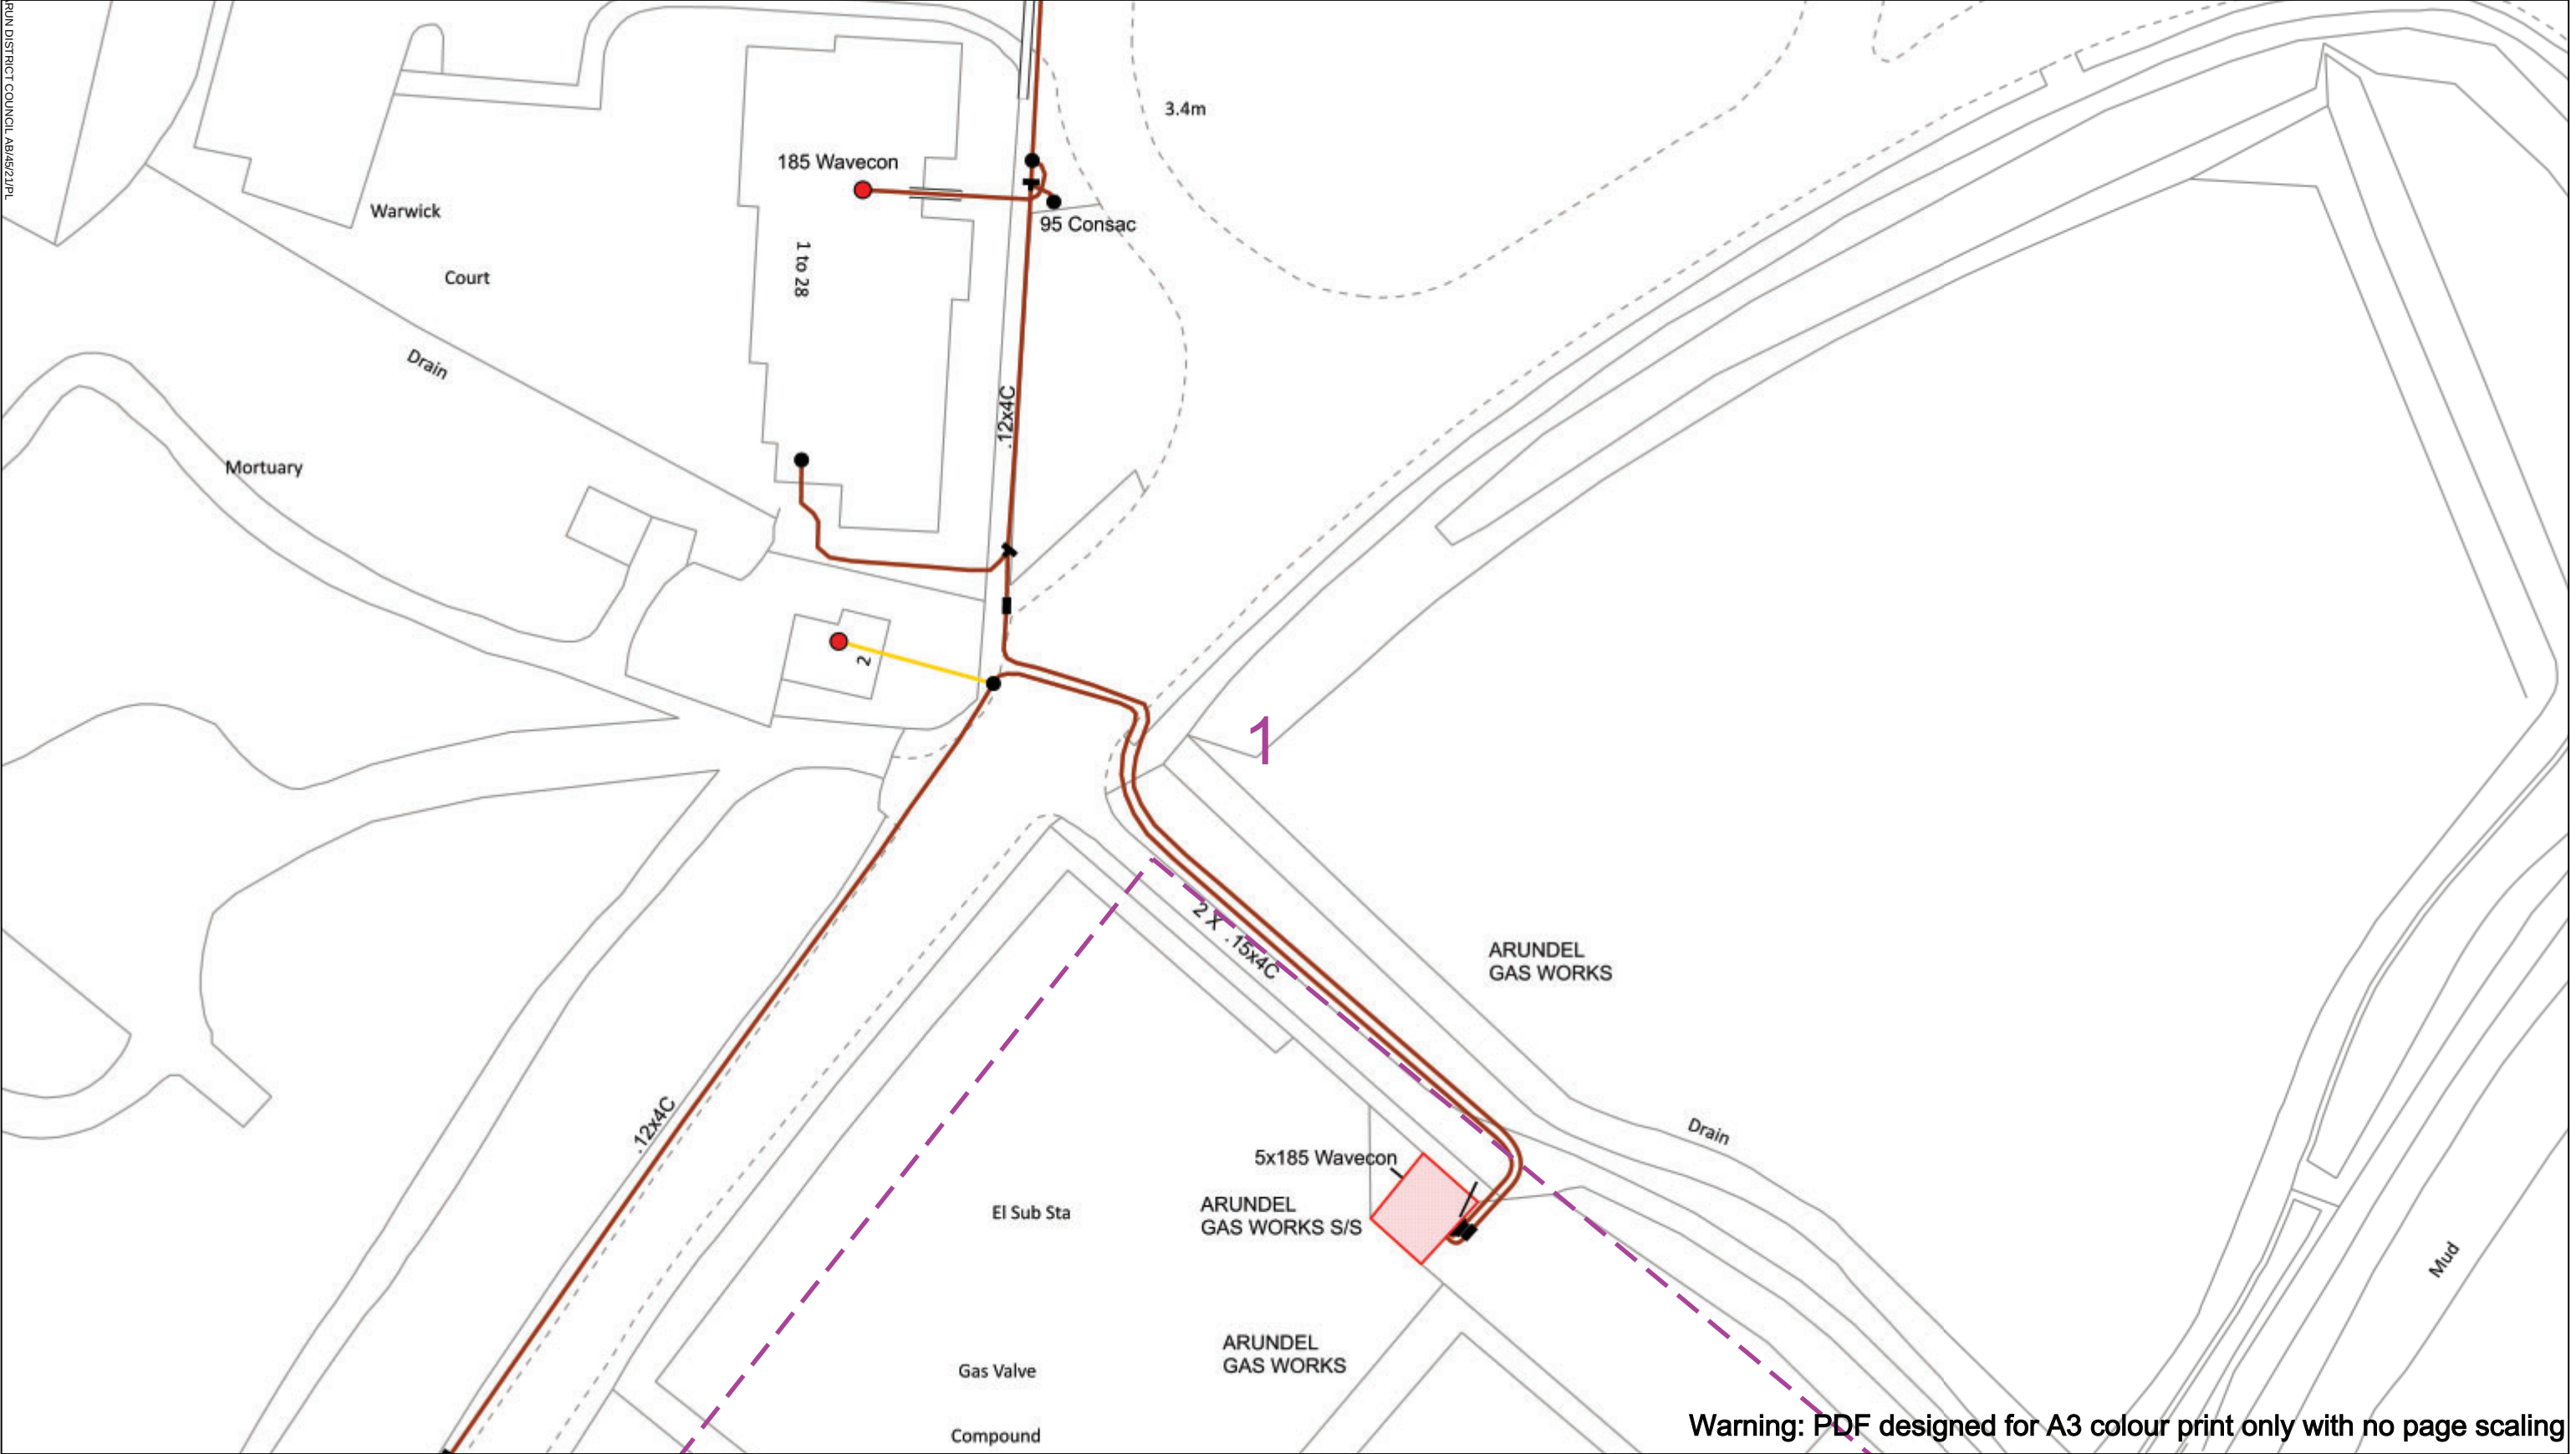

Warning: PDF designed for A3 colour print only with no page scaling

050m

Dig Sites

Area:

Line:

Date Requested: 26/10/2020

Job Reference: 20319776

Site Location: 501301 106731

Requested by: Mr Steven Gronow

Your Scheme/Reference: C1820

WARNING

There may have been subsequent alteration to the surface levels. Trial holes must be undertaken to determine position and depths of cables. HS (G) 47 Booklet from the Health and Safety Executive – Avoiding Danger from Buried Cables – should be consulted before commencing excavation work.

WHEN WORKING IN THE VICINITY OF OVERHEAD LINES THE HEALTH AND SAFETY GUIDANCE NOTES GS6 SHOULD BE CONSULTED (AVAILABLE FROM THE HSE WEBSITE)

Voltages (V)				
LV (Low Voltage) and Services	Up to 1,000V			
HV (High Voltage)	Over 1,000V to 11,000V			
EHV (Extra High Voltage)	22,000V to 132,000V			
Transmission	275,000V and 400,000V			

NORMAL DEPTH TO THE TOP OF THE CABLE WHEN LAID				
	Services	LV	HV	EHV
Footpath/Unmade	0.45m	0.45m	0.6m	0.8m
Road Crossing	0.6m	0.6m	0.75m	0.9m
Agricultural	1m	1m	1m	1.1m

Legend

Service Cable

LV Mains

2 – 3.3kV

6.6kV

11kV

22kV

33kV

66kV

Distribution Structures (Electric)

Pole, Existing Location

Pole Structure, Existing Location - Single

Pole Structure, Existing Location - H

Duct RouteCross Section Route

Scottish & Southern

Electricity Networks

Scottish and Southern Energy Power Distribution Ltd.

Registered Office: Inverlmond House,

200 Dunkeld Road, Perth, PH1 3AQ

Registered in Scotland No.SC213459

If you're unsure & need to seek advice before commencing excavations please contact:

General Enquiries: 0800 048 3516

Subject to revision – Master held by SSEN Asset Data Team:


Asset.Data@sse.com

01256 337 294

Scale: 1:500 (When plotted at A3)

BASED UPON THE ORDNANCE SURVEY MAP WITH THE SANCTION OF THE CONTROLLER OF H.M STATIONERY OFFICE CROWN COPYRIGHT RESERVED.

This copy has been made by or with the authority of Scottish and Southern Energy Power Distribution Ltd. Pursuant to section 47 of the Copyright, Designs and Patents Act 1988 ('The Act'). Unless the Act provides a relevant exception to copyright the copy must not be copied without prior permission of the copyright owner. Plans generated by DigSAFE Pro™ software provided by LinesearchbeforeUdig.

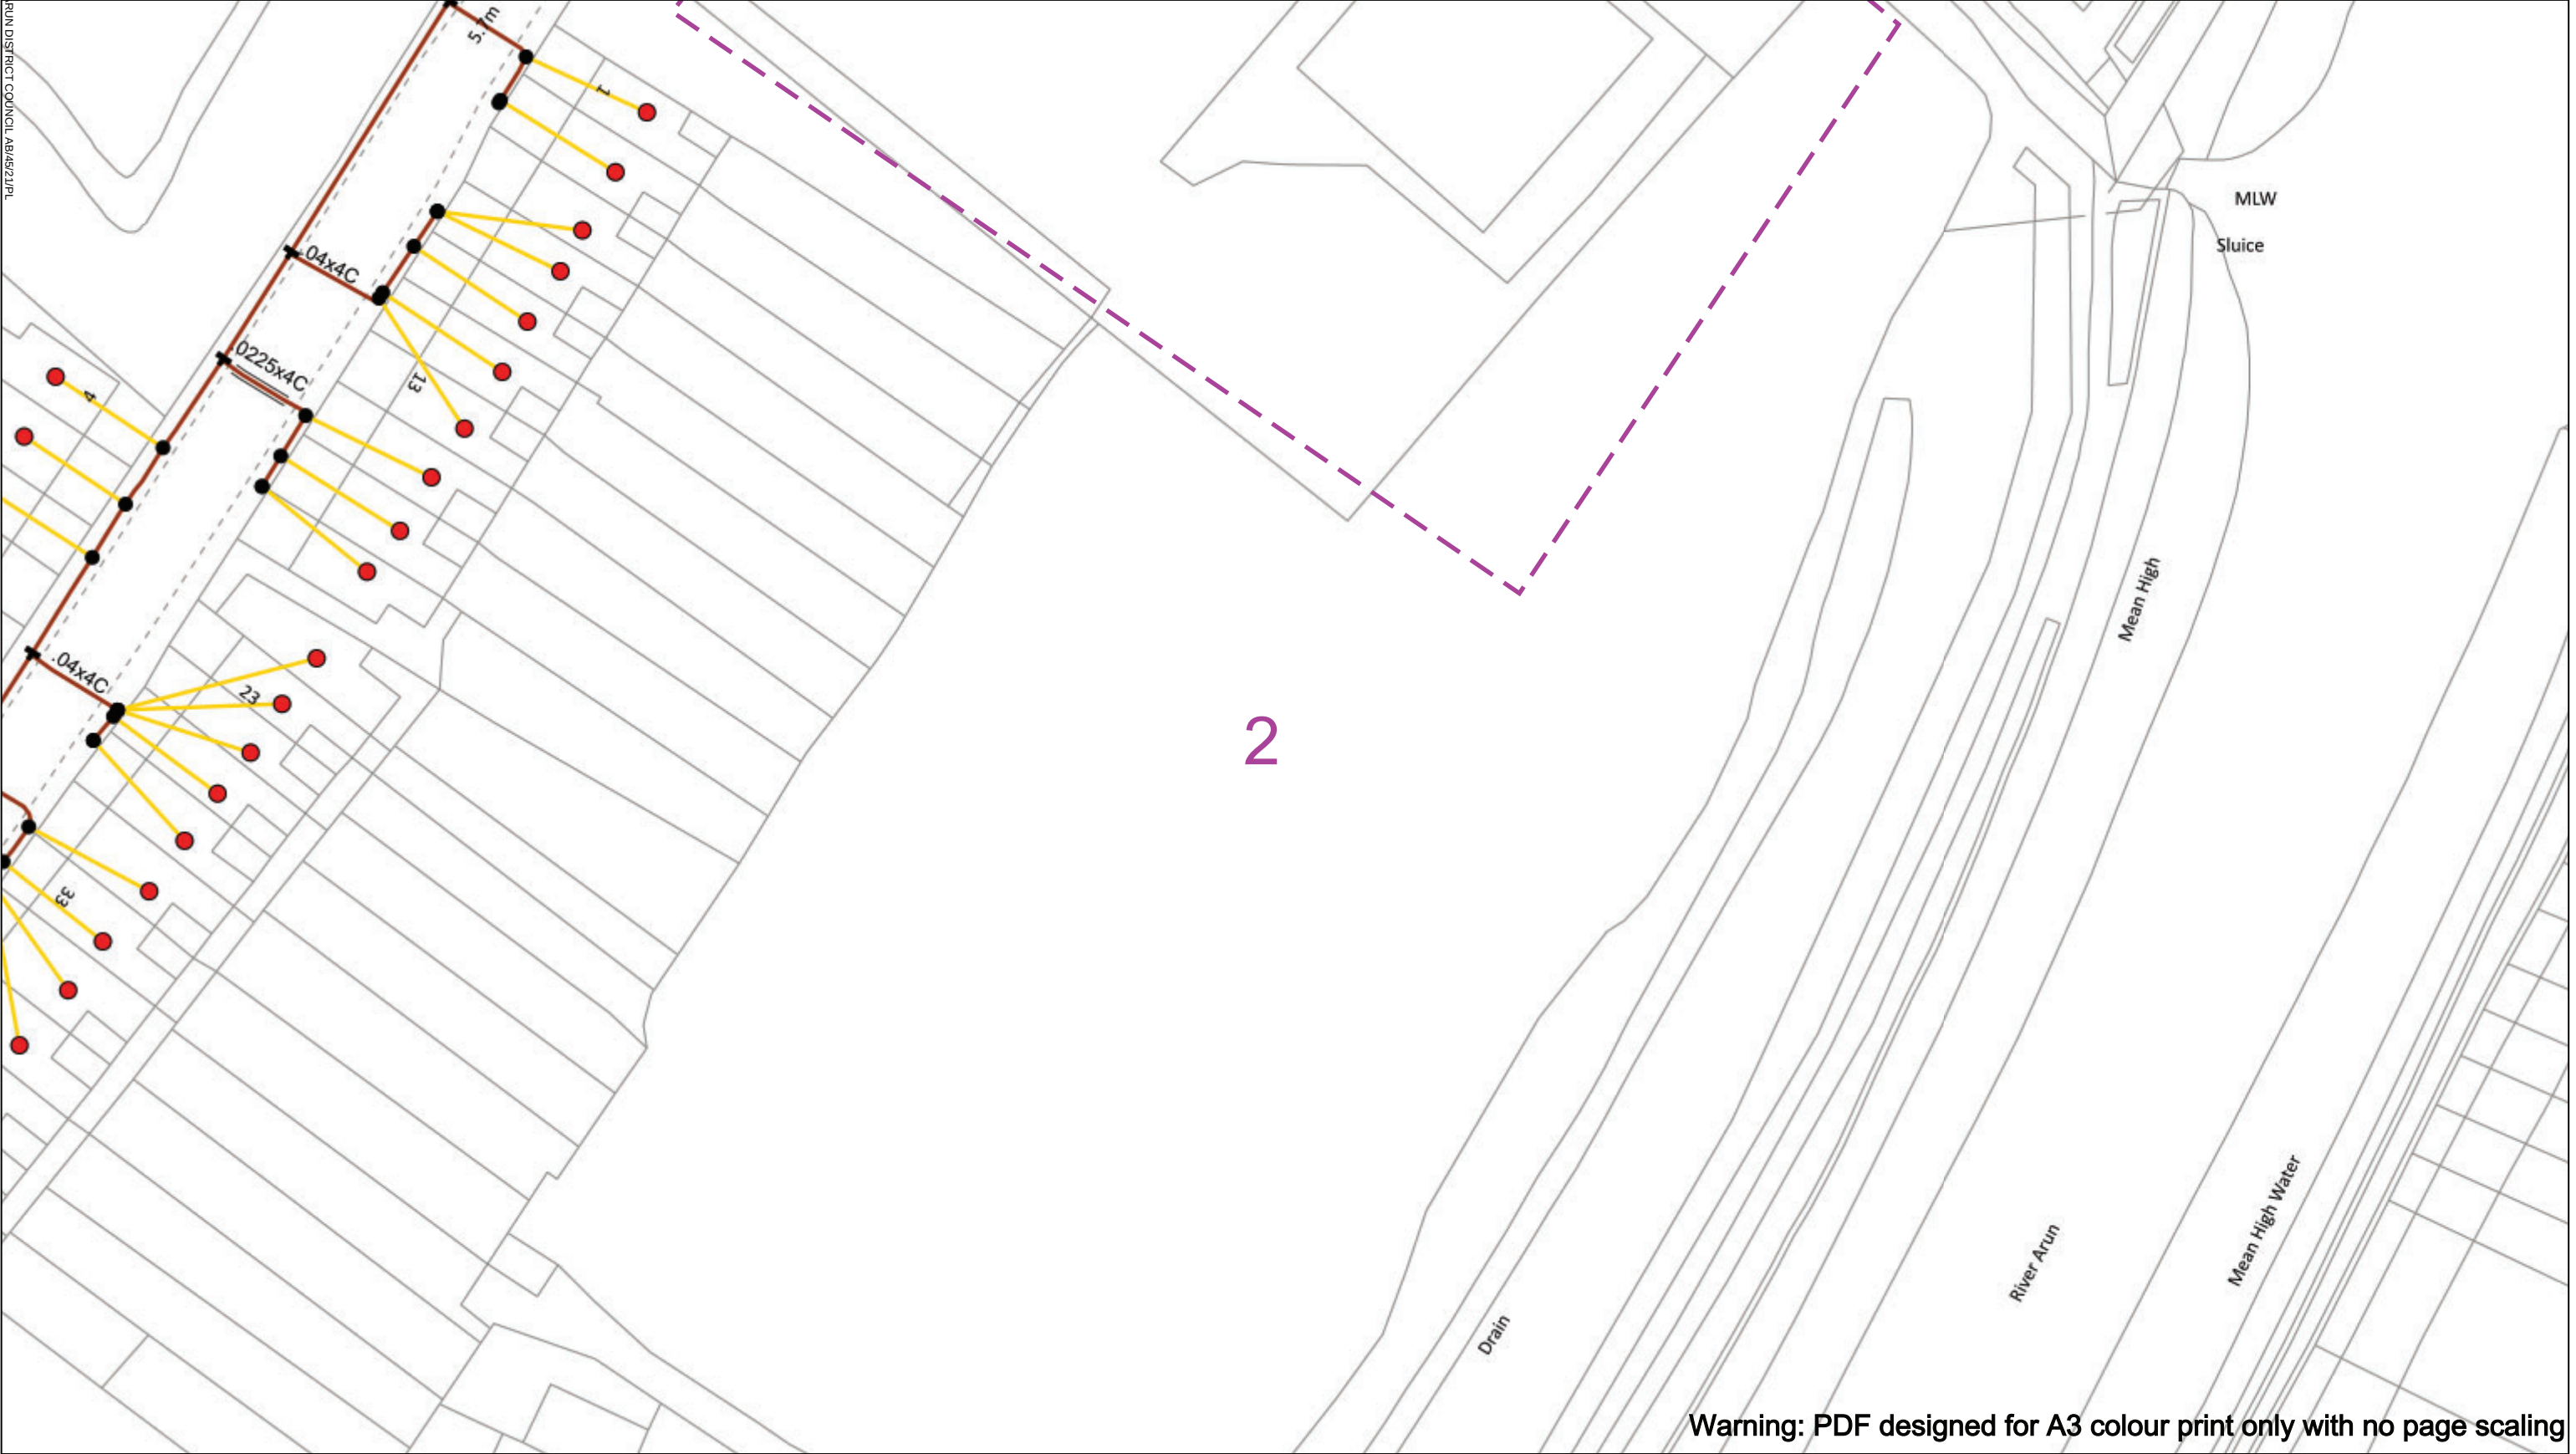

Warning: PDF designed for A3 colour print only with no page scaling

0
50m

Dig Sites
Area:
Line:

WARNING

There may have been subsequent alteration to the surface levels. Trial holes must be undertaken to determine position and depths of cables. HS (G) 47 Booklet from the Health and Safety Executive – Avoiding Danger from Buried Cables – should be consulted before commencing excavation work.

WHEN WORKING IN THE VICINITY OF OVERHEAD LINES THE HEALTH AND SAFETY GUIDANCE NOTES GS6 SHOULD BE CONSULTED (AVAILABLE FROM THE HSE WEBSITE)

Voltages (V)

LV (Low Voltage) and Services	Up to 1,000V
HV (High Voltage)	Over 1,000V to 11,000V
EHV (Extra High Voltage)	22,000V to 132,000V
Transmission	275,000V and 400,000V

NORMAL DEPTH TO THE TOP OF THE CABLE WHEN LAID

	Services	LV	HV	EHV
Footpath/Unmade	0.45m	0.45m	0.6m	0.8m
Road Crossing	0.6m	0.6m	0.75m	0.9m
Agricultural	1m	1m	1m	1.1m

Legend

- Service Cable
- LV Mains
- 2 – 3.3kV
- 6.6kV
- 11kV
- 22kV
- 33kV
- 66kV
- 132kV
- 275kV
- 400kV
- Fibre Optic
- Pilot Cable

Distribution Structures (Electric)

- Pole, Existing Location
- Pole Structure, Existing Location - Single
- Pole Structure, Existing Location - H
- Duct Route
- Cross Section Route

Scottish and Southern Electricity Networks

Scottish and Southern Energy Power Distribution Ltd.
Registered Office: Inverlorn House,
200 Dunkeld Road, Perth, PH1 3AQ
Registered in Scotland No.SC213459

If you're unsure & need to seek advice before commencing excavations please contact:
General Enquiries: 0800 048 3516


Subject to revision – Master held by SSEN Asset Data Team:
Asset.Data@sse.com
01256 337 294

Scale: 1:500 (When plotted at A3)

DATE REQUESTED: 26/10/2020
JOB REFERENCE: 20319776
SITE LOCATION: 501301 106731
REQUESTED BY:
Mr Steven Gronow
YOUR SCHEME/REFERENCE: C1820

THIS COPY HAS BEEN MADE BY OR WITH THE AUTHORITY OF SCOTTISH AND SOUTHERN ENERGY POWER DISTRIBUTION LTD. PURSUANT TO SECTION 47 OF THE COPYRIGHT, DESIGNS AND PATENTS ACT 1988 ('THE ACT'). UNLESS THE ACT PROVIDES A RELEVANT EXCEPTION TO COPYRIGHT THE COPY MUST NOT BE COPIED WITHOUT PRIOR PERMISSION OF THE COPYRIGHT OWNER. PLANS GENERATED BY DIGSAFE PRO™ SOFTWARE PROVIDED BY LINESEARCHBEFOREUDIG.

Dig Sites Area: Line:																																																														
Date Requested: 26/10/2020 Job Reference: 20319776 Site Location: 501301 106731 Requested by: Mr Steven Gronow Your Scheme/Reference: C1820	WARNING There may have been subsequent alteration to the surface levels. Trial holes must be undertaken to determine position and depths of cables. HS (G) 47 Booklet from the Health and Safety Executive – Avoiding Danger from Buried Cables – should be consulted before commencing excavation work. WHEN WORKING IN THE VICINITY OF OVERHEAD LINES THE HEALTH AND SAFETY GUIDANCE NOTES GS6 SHOULD BE CONSULTED (AVAILABLE FROM THE HSE WEBSITE) <td> Voltages (V) <table> <tr> <td>LV (Low Voltage) and Services</td><td>Up to 1,000V</td></tr> <tr> <td>HV (High Voltage)</td><td>Over 1,000V to 11,000V</td></tr> <tr> <td>EHV (Extra High Voltage)</td><td>22,000V to 132,000V</td></tr> <tr> <td>Transmission</td><td>275,000V and 400,000V</td></tr> </table> NORMAL DEPTH TO THE TOP OF THE CABLE WHEN LAID <table> <tr> <td>Services</td><td>LV</td><td>HV</td><td>EHV</td></tr> <tr> <td>Footpath/Unmade</td><td>0.45m</td><td>0.45m</td><td>0.6m</td></tr> <tr> <td>Road Crossing</td><td>0.6m</td><td>0.6m</td><td>0.75m</td></tr> <tr> <td>Agricultural</td><td>1m</td><td>1m</td><td>1.1m</td></tr> </table> </td> <td> Legend <table> <tr><td></td><td>Service Cable</td></tr> <tr><td></td><td>LV Mains</td></tr> <tr><td></td><td>6.6kV</td></tr> <tr><td></td><td>11kV</td></tr> <tr><td></td><td>22kV</td></tr> <tr><td></td><td>33kV</td></tr> <tr><td></td><td>66kV</td></tr> <tr><td></td><td>132kV</td></tr> <tr><td></td><td>275kV</td></tr> <tr><td></td><td>400kV</td></tr> <tr><td></td><td>Fibre Optic</td></tr> <tr><td></td><td>Pilot Cable</td></tr> </table> Distribution Structures (Electric) <table> <tr><td></td><td>Pole, Existing Location</td></tr> <tr><td></td><td>Pole Structure, Existing Location - Single</td></tr> <tr><td></td><td>Pole Structure, Existing Location - H</td></tr> <tr><td></td><td>Duct Route</td></tr> <tr><td></td><td>Cross Section Route</td></tr> </table> </td> <td> Scottish and Southern Energy Power Distribution Ltd. Registered Office: Inverlorn Road, Perth, PH1 3AQ Registered in Scotland No.SC213459 If you're unsure & need to seek advice before commencing excavations please contact: General Enquiries: 0800 048 3516 Subject to revision – Master held by SSEN Asset Data Team: Asset_Data@sse.com 01256 337 294 </td>	Voltages (V) <table> <tr> <td>LV (Low Voltage) and Services</td><td>Up to 1,000V</td></tr> <tr> <td>HV (High Voltage)</td><td>Over 1,000V to 11,000V</td></tr> <tr> <td>EHV (Extra High Voltage)</td><td>22,000V to 132,000V</td></tr> <tr> <td>Transmission</td><td>275,000V and 400,000V</td></tr> </table> NORMAL DEPTH TO THE TOP OF THE CABLE WHEN LAID <table> <tr> <td>Services</td><td>LV</td><td>HV</td><td>EHV</td></tr> <tr> <td>Footpath/Unmade</td><td>0.45m</td><td>0.45m</td><td>0.6m</td></tr> <tr> <td>Road Crossing</td><td>0.6m</td><td>0.6m</td><td>0.75m</td></tr> <tr> <td>Agricultural</td><td>1m</td><td>1m</td><td>1.1m</td></tr> </table>	LV (Low Voltage) and Services	Up to 1,000V	HV (High Voltage)	Over 1,000V to 11,000V	EHV (Extra High Voltage)	22,000V to 132,000V	Transmission	275,000V and 400,000V	Services	LV	HV	EHV	Footpath/Unmade	0.45m	0.45m	0.6m	Road Crossing	0.6m	0.6m	0.75m	Agricultural	1m	1m	1.1m	Legend <table> <tr><td></td><td>Service Cable</td></tr> <tr><td></td><td>LV Mains</td></tr> <tr><td></td><td>6.6kV</td></tr> <tr><td></td><td>11kV</td></tr> <tr><td></td><td>22kV</td></tr> <tr><td></td><td>33kV</td></tr> <tr><td></td><td>66kV</td></tr> <tr><td></td><td>132kV</td></tr> <tr><td></td><td>275kV</td></tr> <tr><td></td><td>400kV</td></tr> <tr><td></td><td>Fibre Optic</td></tr> <tr><td></td><td>Pilot Cable</td></tr> </table> Distribution Structures (Electric) <table> <tr><td></td><td>Pole, Existing Location</td></tr> <tr><td></td><td>Pole Structure, Existing Location - Single</td></tr> <tr><td></td><td>Pole Structure, Existing Location - H</td></tr> <tr><td></td><td>Duct Route</td></tr> <tr><td></td><td>Cross Section Route</td></tr> </table>		Service Cable		LV Mains		6.6kV		11kV		22kV		33kV		66kV		132kV		275kV		400kV		Fibre Optic		Pilot Cable		Pole, Existing Location		Pole Structure, Existing Location - Single		Pole Structure, Existing Location - H		Duct Route		Cross Section Route	Scottish and Southern Energy Power Distribution Ltd. Registered Office: Inverlorn Road, Perth, PH1 3AQ Registered in Scotland No.SC213459 If you're unsure & need to seek advice before commencing excavations please contact: General Enquiries: 0800 048 3516 Subject to revision – Master held by SSEN Asset Data Team: Asset_Data@sse.com 01256 337 294
LV (Low Voltage) and Services	Up to 1,000V																																																													
HV (High Voltage)	Over 1,000V to 11,000V																																																													
EHV (Extra High Voltage)	22,000V to 132,000V																																																													
Transmission	275,000V and 400,000V																																																													
Services	LV	HV	EHV																																																											
Footpath/Unmade	0.45m	0.45m	0.6m																																																											
Road Crossing	0.6m	0.6m	0.75m																																																											
Agricultural	1m	1m	1.1m																																																											
	Service Cable																																																													
	LV Mains																																																													
	6.6kV																																																													
	11kV																																																													
	22kV																																																													
	33kV																																																													
	66kV																																																													
	132kV																																																													
	275kV																																																													
	400kV																																																													
	Fibre Optic																																																													
	Pilot Cable																																																													
	Pole, Existing Location																																																													
	Pole Structure, Existing Location - Single																																																													
	Pole Structure, Existing Location - H																																																													
	Duct Route																																																													
	Cross Section Route																																																													
Scale: 1:1025 (When plotted at A3)																																																														

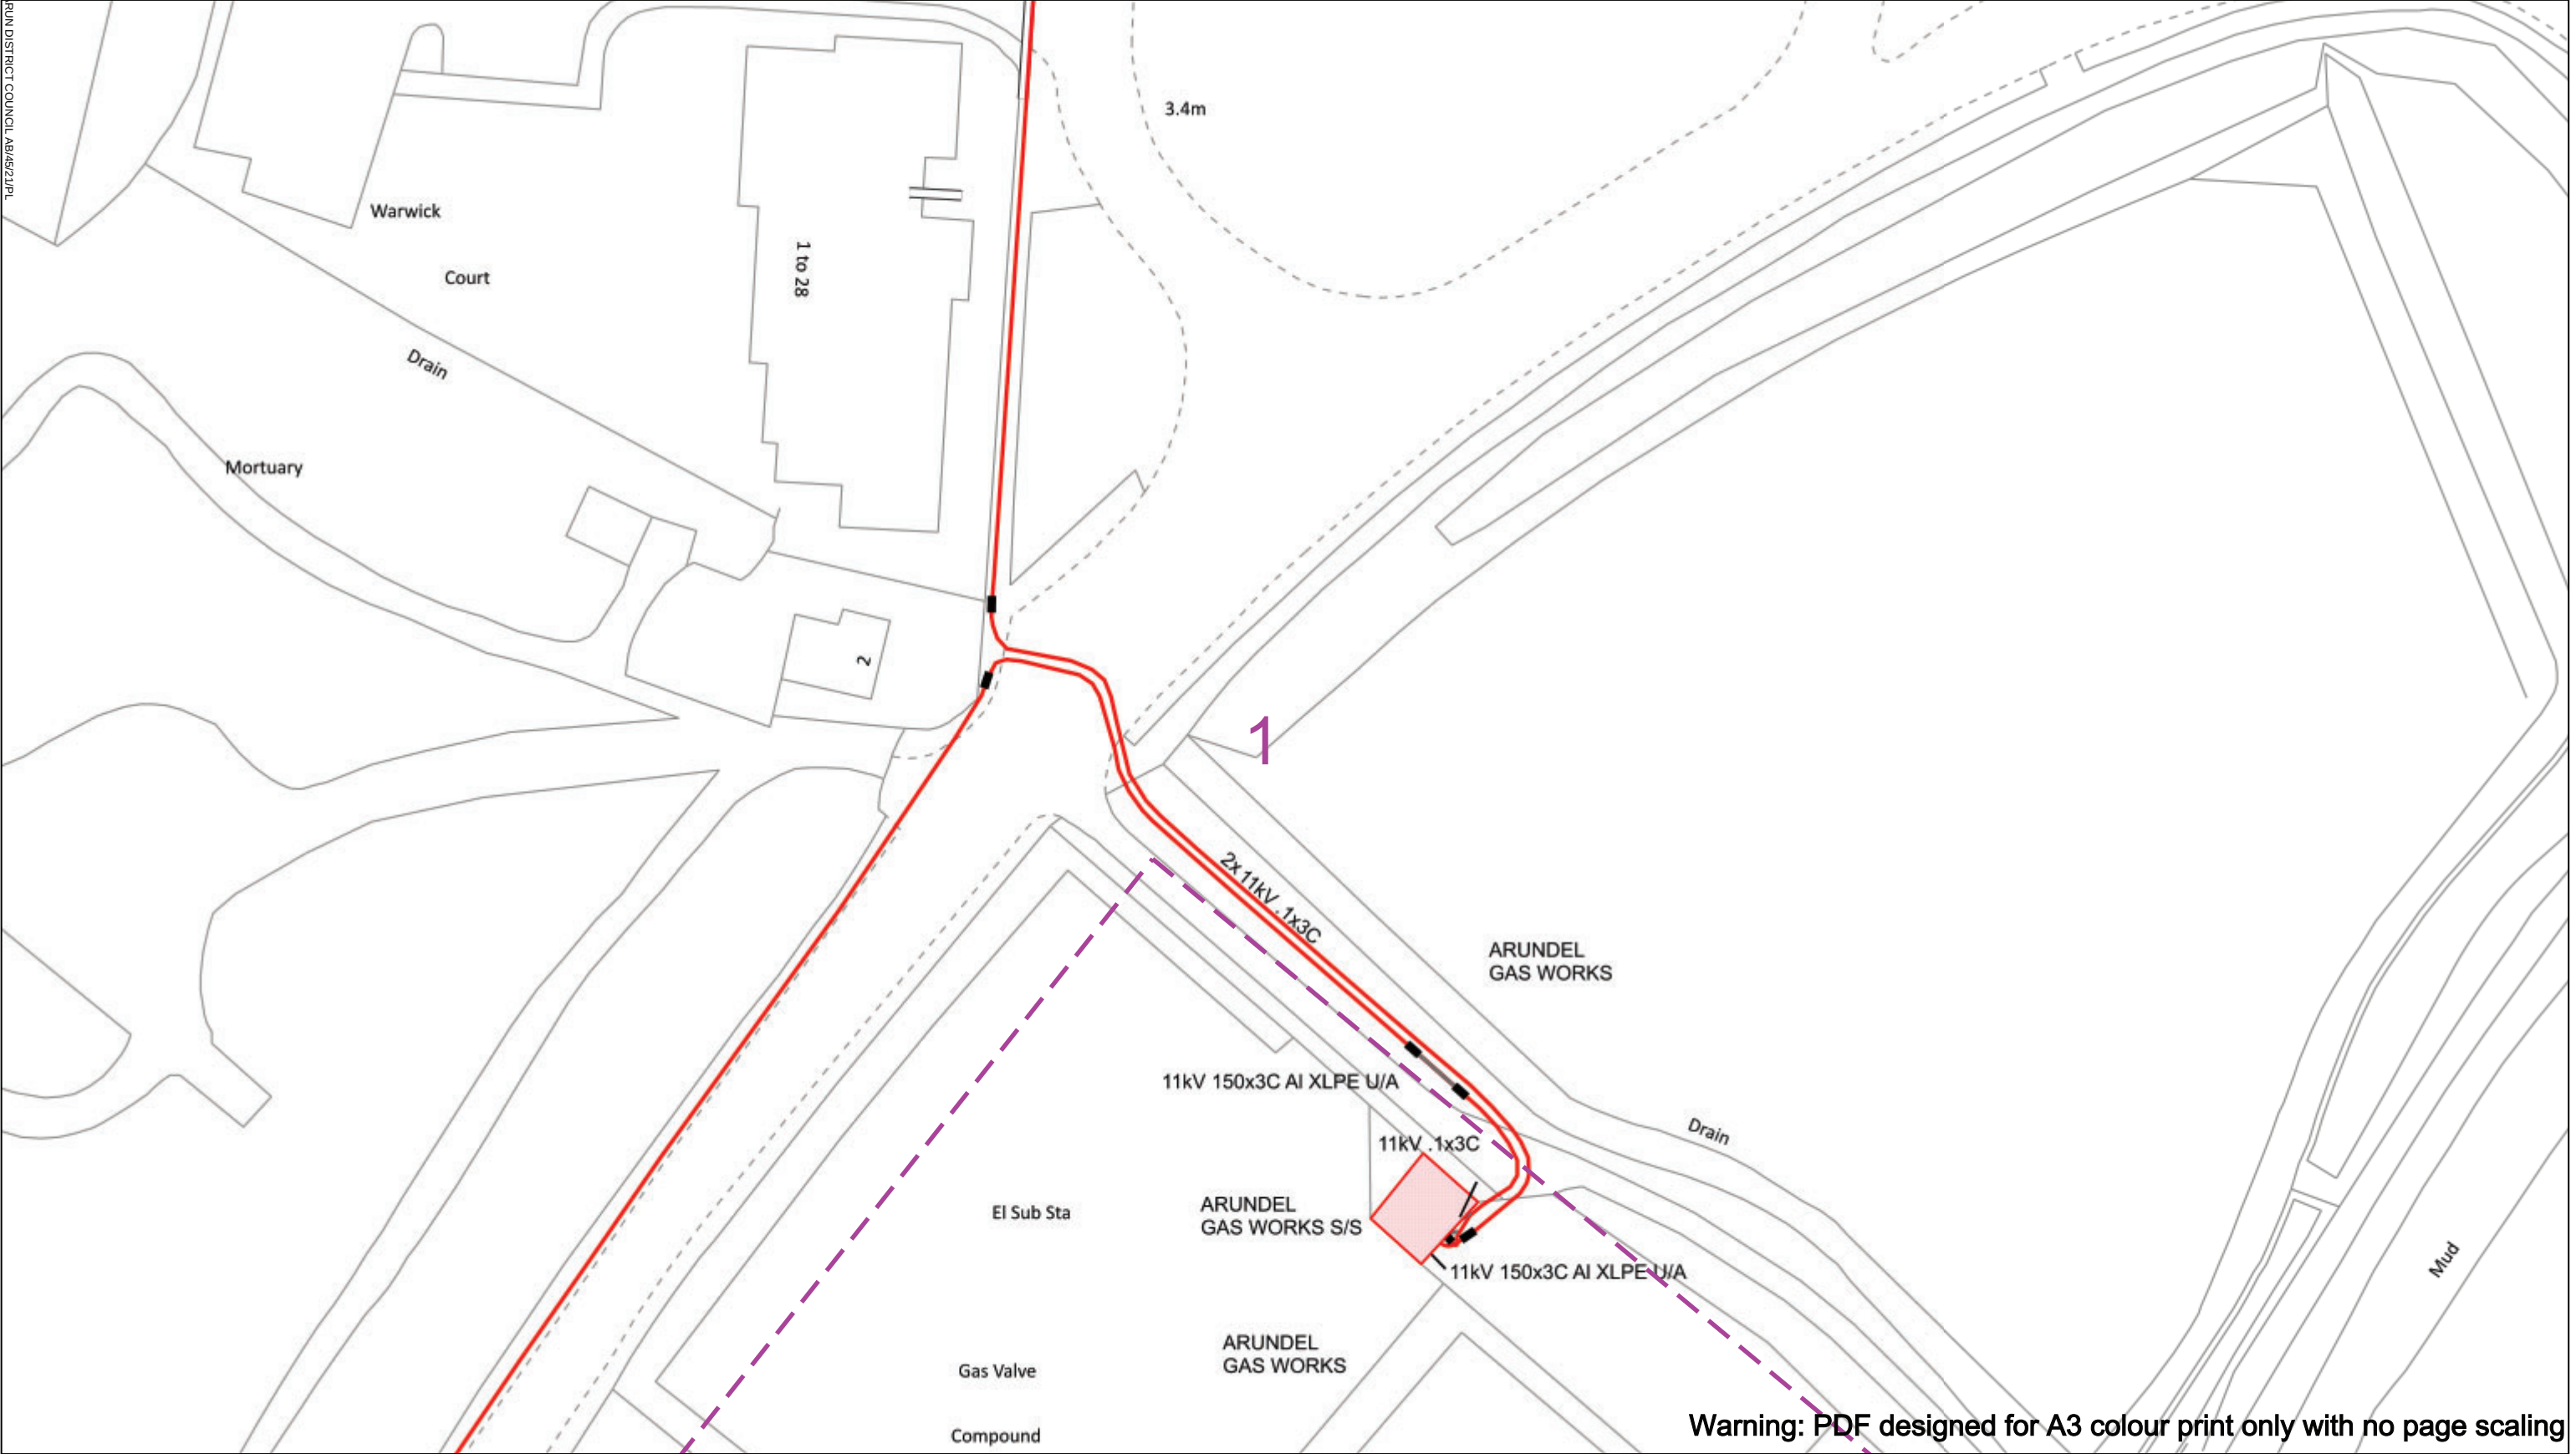

Warning: PDF designed for A3 colour print only with no page scaling

0

50m

Dig Sites
Area:
Line:

Date Requested: 26/10/2020

Job Reference: 20319776

Site Location: 501301 106731

Requested by: Mr Steven Gronow

Your Scheme/Reference: C1820

WARNING

There may have been subsequent alteration to the surface levels. Trial holes must be undertaken to determine position and depths of cables. HS (G) 47 Booklet from the Health and Safety Executive – Avoiding Danger from Buried Cables – should be consulted before commencing excavation work.

WHEN WORKING IN THE VICINITY OF OVERHEAD LINES THE HEALTH AND SAFETY GUIDANCE NOTES GS6 SHOULD BE CONSULTED (AVAILABLE FROM THE HSE WEBSITE)

Scale: 1:500 (When plotted at A3)

Voltages (V)				
LV (Low Voltage) and Services	Up to 1,000V			
HV (High Voltage)	Over 1,000V to 11,000V			
EHV (Extra High Voltage)	22,000V to 132,000V			
Transmission	275,000V and 400,000V			

NORMAL DEPTH TO THE TOP OF THE CABLE WHEN LAID				
	Services	LV	HV	EHV
Footpath/Unmade	0.45m	0.45m	0.6m	0.8m
Road Crossing	0.6m	0.6m	0.75m	0.9m
Agricultural	1m	1m	1m	1.1m

Legend

- Service Cable
- LV Mains
- 2 – 3.3kV
- 6.6kV
- 11kV
- 22kV
- 33kV
- 66kV
- 132kV
- 275kV
- 400kV
- Fibre Optic
- Pilot Cable

Distribution Structures (Electric)

- Pole, Existing Location
- Pole Structure, Existing Location - Single
- Pole Structure, Existing Location - H
- Duct Route
- Cross Section Route

Scottish and Southern Energy Power Distribution Ltd.

Registered Office: Inverlmond House,
200 Dunkeld Road, Perth, PH1 3AQ
Registered in Scotland No.SC213459

If you're unsure & need to seek advice before commencing excavations please contact:
General Enquiries: 0800 048 3516

Subject to revision – Master held by SSEN Asset Data Team:
Asset.Data@sse.com
01256 337 294

BASED UPON THE ORDNANCE SURVEY MAP WITH THE SANCTION OF THE CONTROLLER OF H.M STATIONERY OFFICE CROWN COPYRIGHT RESERVED.

This copy has been made by or with the authority of Scottish and Southern Energy Power Distribution Ltd. Pursuant to section 47 of the Copyright, Designs and Patents Act 1988 ('The Act'). Unless the Act provides a relevant exception to copyright the copy must not be copied without prior permission of the copyright owner. Plans generated by DigSAFE Pro™ software provided by LinesearchbeforeUdig.

