

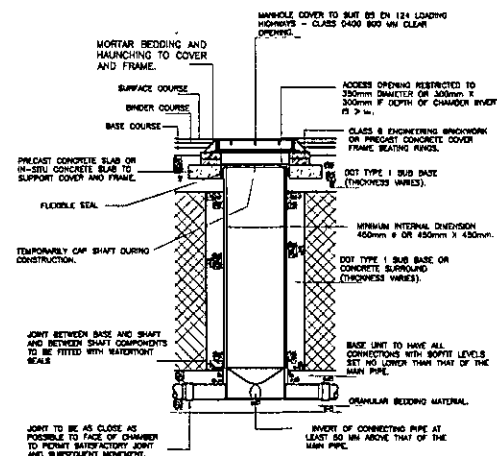
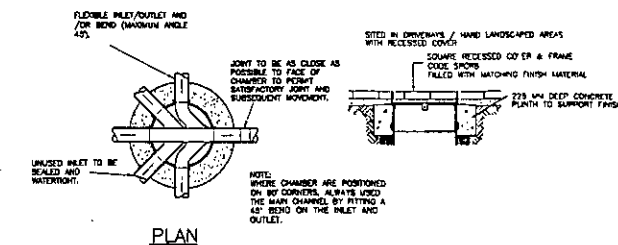
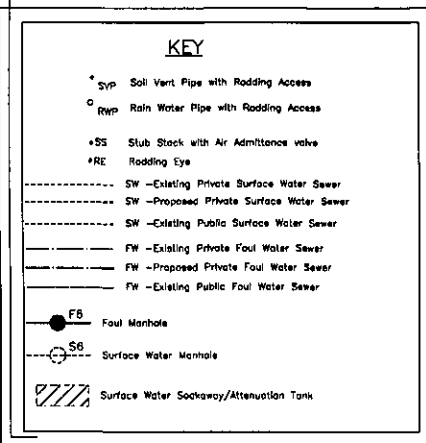


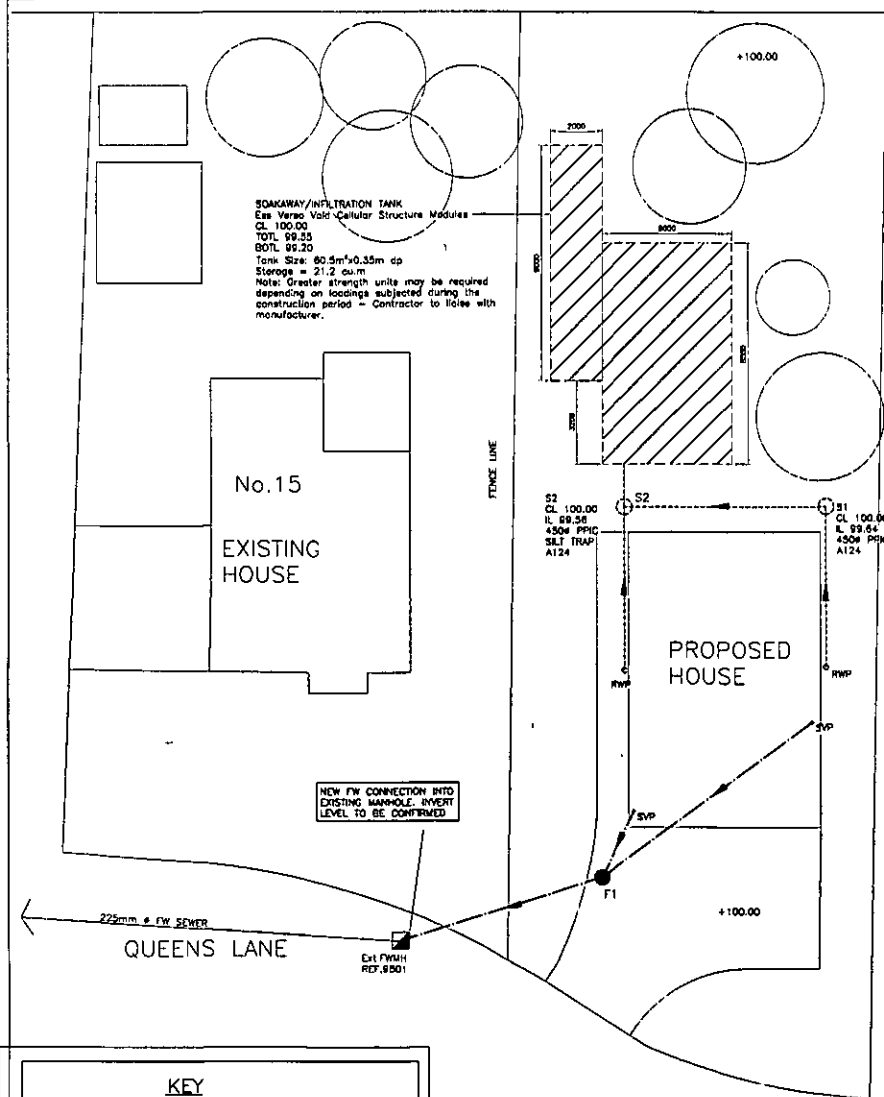

TYPE 3 - 450P POLYPROPYLENE INSPECTION CHAMBER (MAX. DEPTH 3.0M TO PIPE SOFFIT).
 SCALE 1:20

NOTE: PLASTIC CHAMBERS AND RING SHALL COMPLY WITH BS EN 13598-1 AND BS EN 13598-2 OR HAVE EQUIVALENT INDEPENDENT APPROVAL.

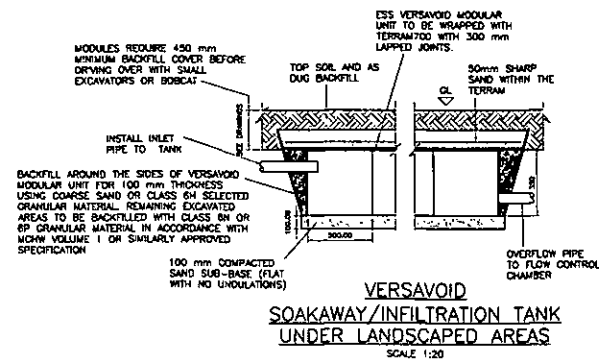

In addition to these notes, reference shall be made to the specification of works and the relevant Architect's and Structural drawings and specifications. The Contractor is responsible for verifying all site dimensions before commencing work.

All dimensions are in millimetres unless noted otherwise.

This drawing has been produced electronically and may have been photo reduced or enlarged from original or scanned. Dimensions on this drawing shall not be scaled. Refer only to dimensioned drawings. Any dimensioned drawings shall be in accordance with the original drawings.

Levels are in metres unless noted otherwise in dimensioned drawings.

The Contractor is responsible for the stability of the building whilst the works are in progress.

- NOTES**
- THIS DRAWING IS BASED ON DRAWING NO. 2015 /000/BRB REV E BY 3D ARCHITECTURE LIMITED.
 - CONTRACTOR IS TO TAKE NECESSARY PRECAUTIONS TO ENSURE THAT TRENCHES ARE KEPT CLEAR OF GROUND WATER DURING CONSTRUCTION.
 - ALL DRAINAGE WORKS TO BE CARRIED OUT IN ACCORDANCE WITH "SEWERS FOR ADOPTION" 7TH EDITION.
 - ALL PIPEWORK TO BE 110Ø UPVC UNLESS NOTED OTHERWISE.
 - ALL PIPEWORK THROUGH WALLS TO BE IN ACCORDANCE WITH THE BUILDING REGULATIONS.
 - ALL PIPEWORK UNDER ROADS WITH LESS THAN 800mm COVER TO HAVE 150mm CONCRETE SURROUND.
 - MINIMUM GRADIENT TO DRAINS TO BE 1:80 FOR 110Ø OR 1:100 FW AND 1:100 FOR 150Ø SW.
 - POSITIONS OF MANHOLES SHOWN ON THIS DRAWING ARE INDICATIVE ONLY. ACTUAL LOCATIONS TO BE FINALIZED ON SITE.
 - PROVIDE CONCRETE LINTLS OVER OPENINGS WHERE PIPES PASS THROUGH WALLS. ALLOW FOR 150mm CLEARANCE ALL ROUND PIPE.

ALL DIMENSIONS AND LEVELS TO BE CHECKED AND CONFIRMED BY THE ARCHITECT PRIOR TO CONSTRUCTION.

REV	DESCRIPTION	DATE	BY
0	ORIGINAL ISSUE	27/03/17	JS

DIXON
 CONSULTING CIVIL & STRUCTURAL ENGINEERS

HEVERSHAM HOUSE, 10-12 BOUNDARY ROAD, HOVE, BN3 4ET
 T: (01273) 431444 F: (01273) 420000 E: hove@dixon.co.uk
 www.dixon.co.uk

Registered in England No. 5428758 - Registered Office 1 Freshwater Terrace, Brighton BN1 1AL

CONTRACT			
15 QUEENS LANE ARUNDEL, WEST SUSSEX			
DRAWING			
DRAINAGE LAYOUT AND DETAILS			
DRAWING No.		REV	CHECKED
51493 / 10		0	
SCALE	DATE	DRAWN	APPROVED
1:100, 1:200 A1	MAR 17	JS	
AutoCAD Ref: 01493-10.dwg			
This drawing is provided solely for the Client's use. It is not to be used for any other purpose without the written consent of Dixon.			