

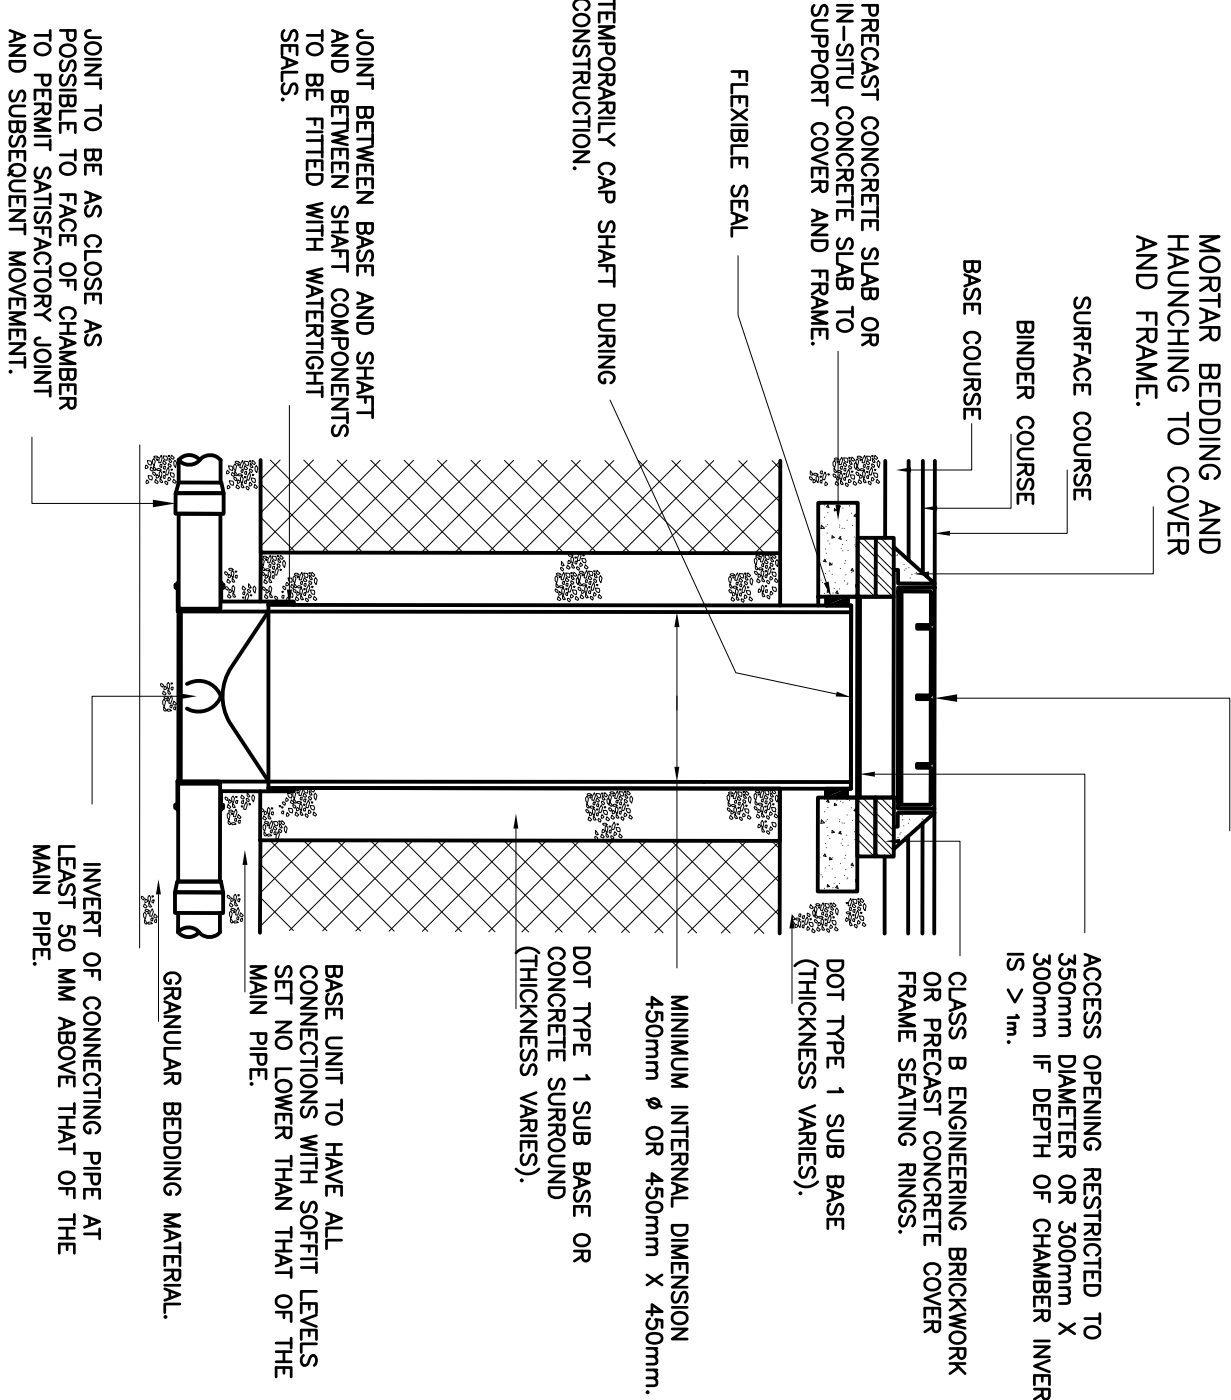
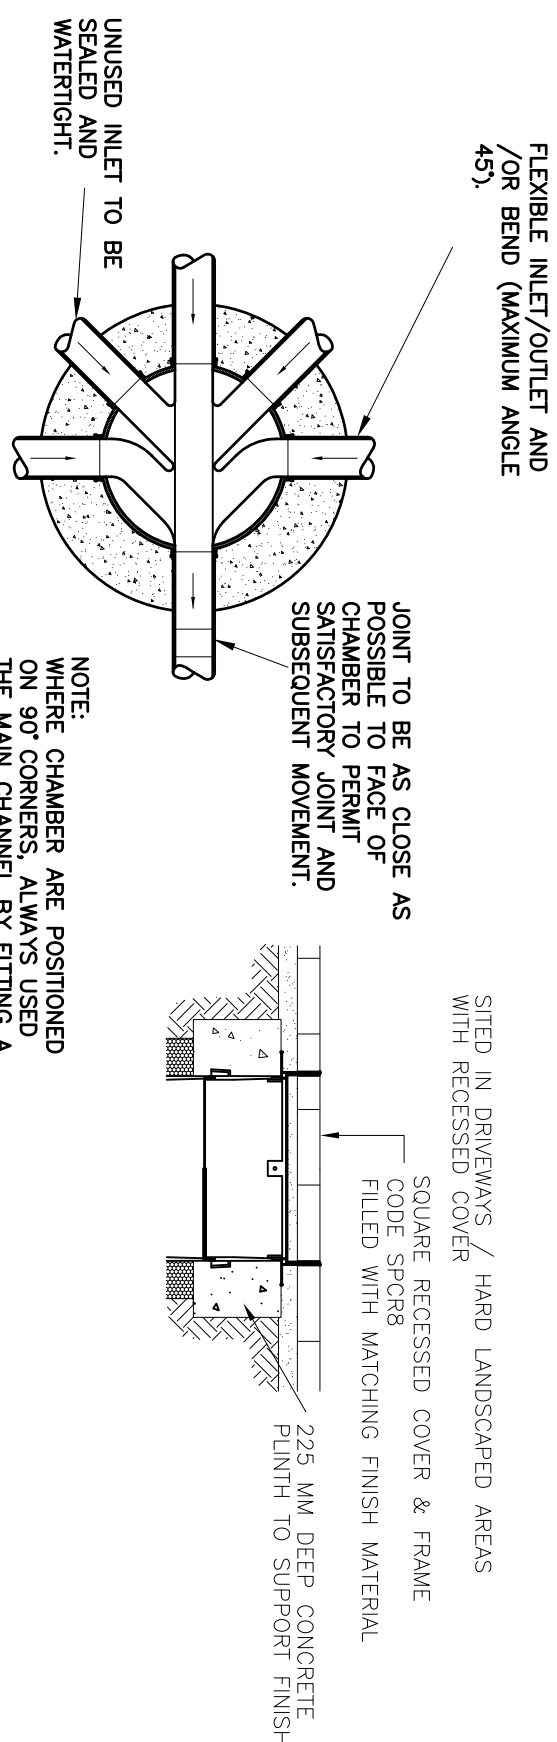


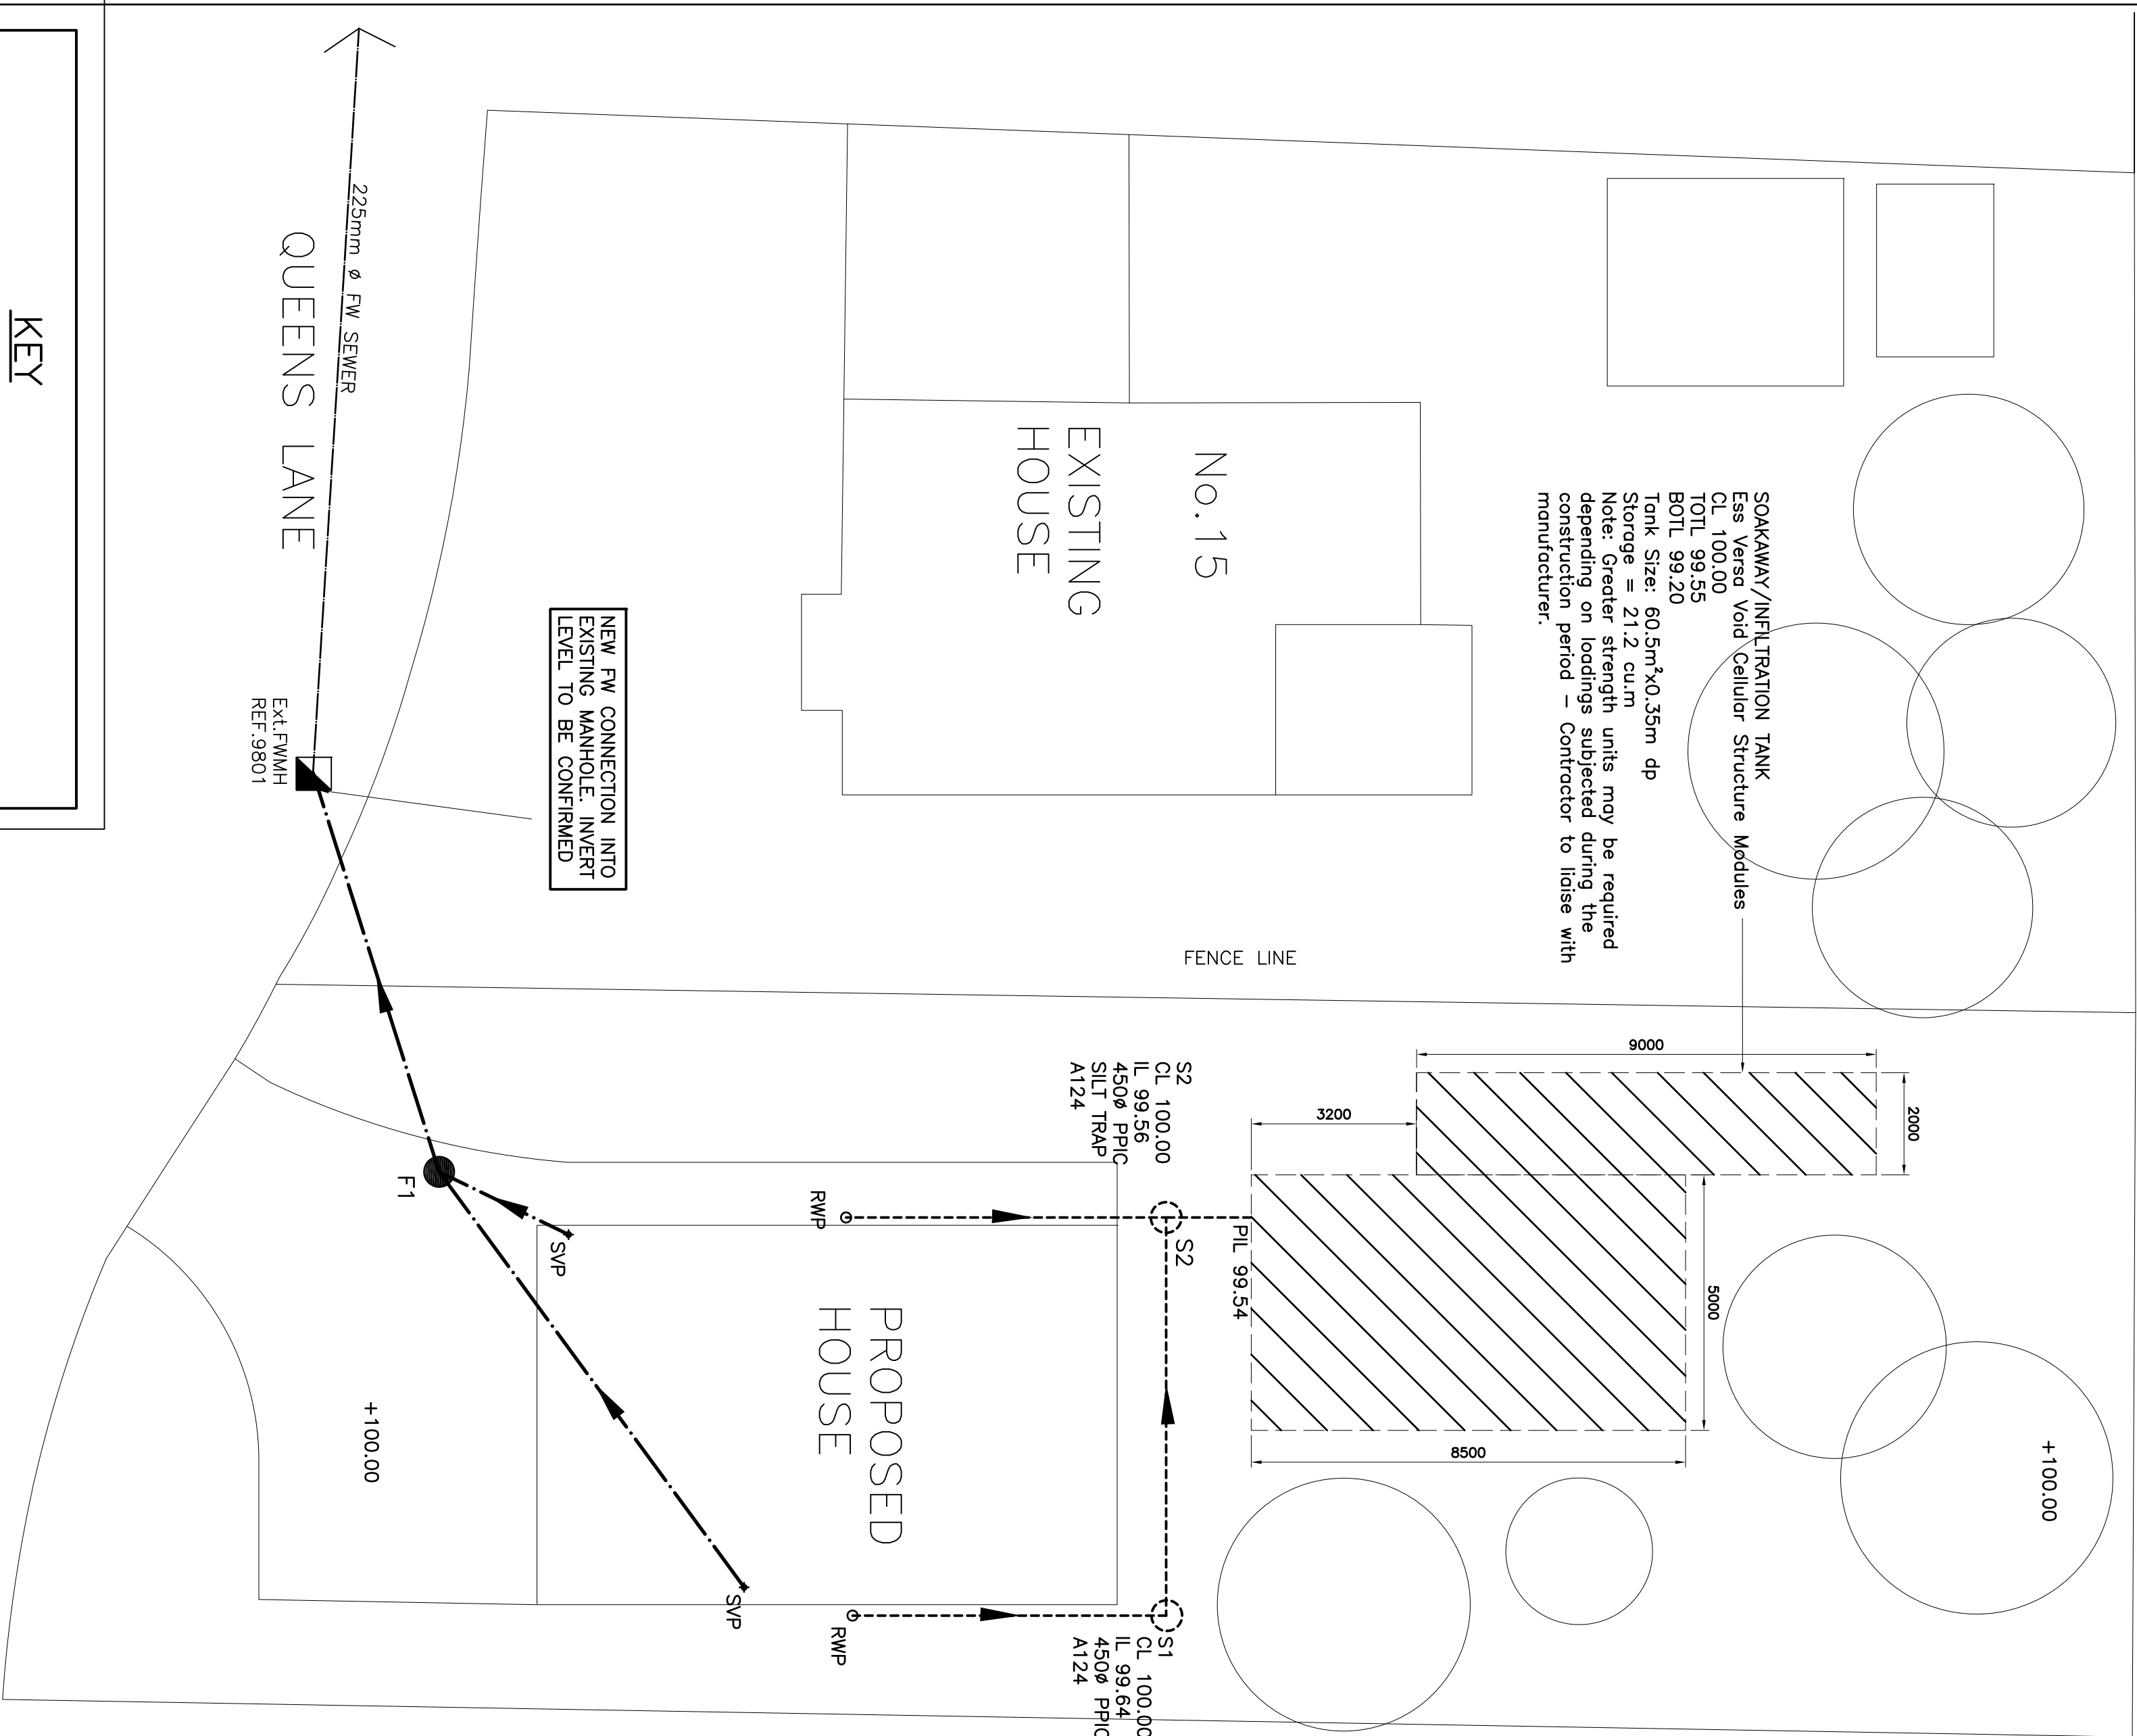

TYPE 3 – 450P POLYPROPYLENE
INSPECTION CHAMBER (MAX. DEPTH 3.0M
TO PIPE SOFFIT).
SCALE 1:20

NOTE: PLASTIC CHAMBERS AND RING
SHALL COMPLY WITH BS EN 13598-1
AND BS EN 13598-2 OR HAVE
EQUIVALENT INDEPENDENT APPROVAL.

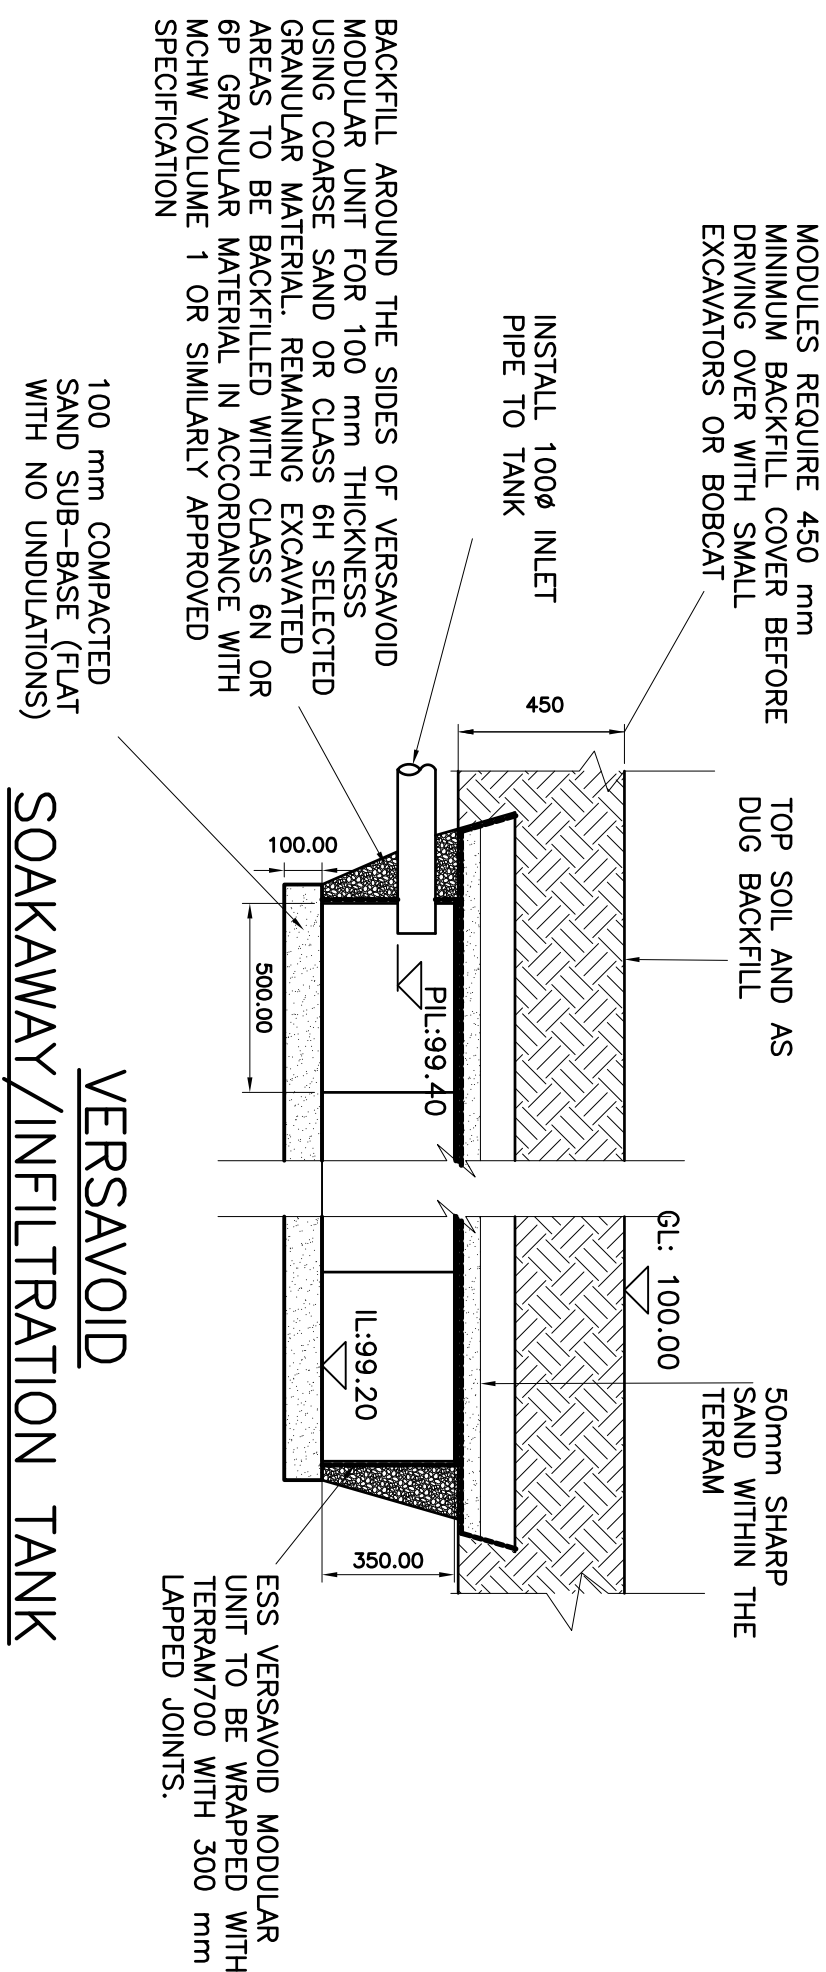

VERSAROID
SOAKAWAY/INFILTRATION TANK
UNDER LANDSCAPED AREAS
SCALE 1:20

1. THIS DRAWING IS BASED ON DRAWING NO. 2015 /090/BR8 REV E BY 3D ARCHITECTURE LIMITED.
2. CONTRACTOR IS TO TAKE NECESSARY PRECAUTIONS TO ENSURE THAT TRENCES ARE KEPT CLEAR OF GROUND WATER DURING CONSTRUCTION.
3. ALL DRAINAGE WORKS TO BE CARRIED OUT IN ACCORDANCE WITH "SEWERS FOR ADOPTION" 7TH EDITION.
4. ALL PIPEWORK TO BE 110Ø UPVC UNLESS NOTED OTHERWISE.
5. ALL PIPEWORK THROUGH WALLS TO BE IN ACCORDANCE WITH THE BUILDING REGULATIONS.
6. ALL PIPEWORK UNDER ROADS WITH LESS THAN 900MM COVER TO HAVE 150MM CONCRETE SURROUND.
7. MINIMUM GRADIENT TO DRAINS TO BE 1:80 FOR 110Ø OR 110Ø FW AND 1:100 FOR 110Ø SW.
8. POSITIONS OF MANHOLES SHOWN ON THIS DRAWING ARE INDICATIVE ONLY. ACTUAL LOCATIONS TO BE FINALIZED ON SITE.
9. PROVIDE CONCRETE LINTELS OVER OPENINGS WHERE PIPES PASS THROUGH WALLS. ALLOW FOR 150MM CLEARANCE ALL ROUND PIPE.

ALL DIMENSIONS AND LEVELS
TO BE CHECKED AND
CONFIRMED BY THE ARCHITECT
PRIOR TO CONSTRUCTION.

DIXON HURST
CONSULTING CIVIL & STRUCTURAL ENGINEERS

HERGENSHAM HOUSE, 18-22 BOUNDARY ROAD, HONE, BN13 4EF
T: (01273) 421444 F: (01273) 420008 E: hove@dih.co.uk
www.dih.co.uk

Registered in England No. 2438720 – Registered Office at Frederick Terrace, Brighton BN1 1XK

CONTRACT

15 QUEENS LANE
ARUNDEL, WEST SUSSEX

DRAINAGE LAYOUT
AND DETAILS

DRAWING No.	REV	CHECKED
51493	/ 10	A
SCALE	DATE	DRAWN
1:100; 1:20 @ A1	MAR 17	JS
AutoCAD Ref: 51493-10.dwg		