


- ABBREVIATIONS (WHERE APPLICABLE)
- AH ARCH HEIGHT
 - BGP BREAK GLASS POINT
 - BH BEAM HEIGHT
 - C WINDOW CILL HEIGHT
 - CH CILL TO HEAD HEIGHT
 - C/B CUPBOARD
 - CL COVER LEVEL
 - COL COLUMN
 - CSU CEILING SLOPING UP
 - DF DRINKING FOUNTAIN
 - DP DOWN PIPE
 - FP FIRE PLACE
 - G GULLEY
 - HB HAND BASIN
 - HT HEIGHT
 - MH MANHOLE
 - O/H OVERHEAD
 - RAD RADIATOR
 - RSJ ROLLED STEEL JOIST
 - RWP RAIN WATER PIPE
 - S SINK
 - SL SKYLIGHT
 - SP ARCH SPRINGER HEIGHT
 - T & B TOP AND BOTTOM HEIGHTS
 - UR URINAL
 - UTL UNABLE TO LIFT
 - VP VENT PIPE
 - WC WATER CLOSET
 - Ø DIAMETER
 - 3.28 FLOOR TO CEILING HEIGHT
 - 4.28 FALSE CEILING
 - ⬆ LIGHT SWITCH
 - ⊙ LIGHT POINT

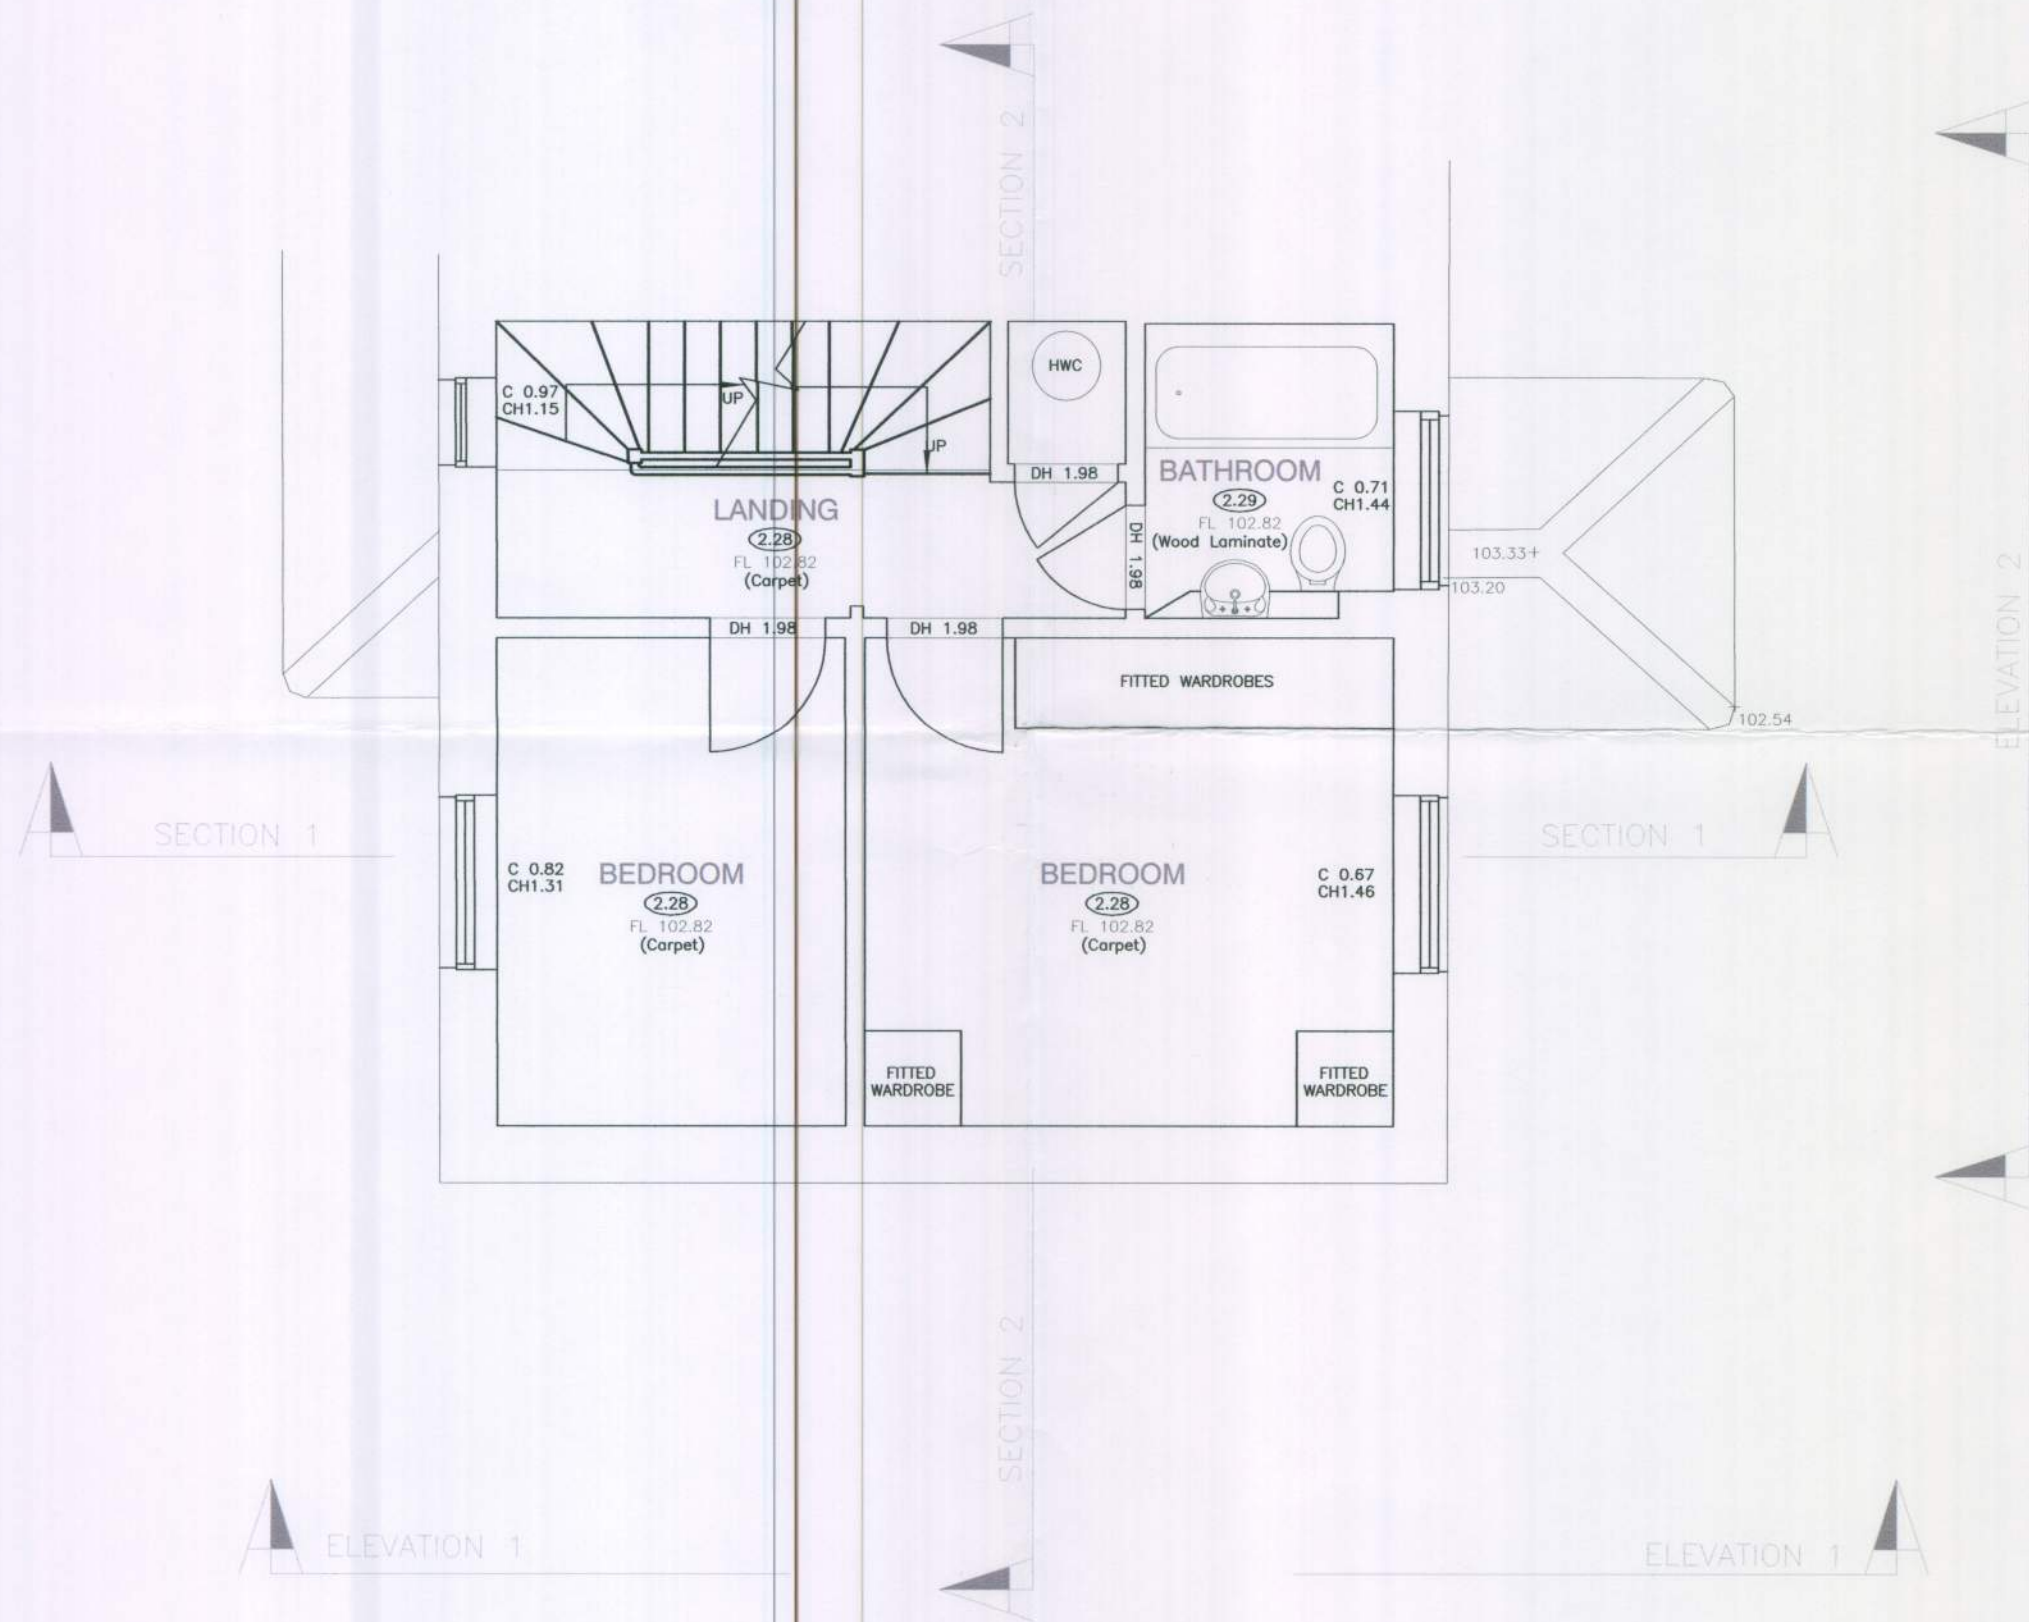

Scale 1 to 50
Plotted on A2 Sheet
10 metres

REV	DATE	DESCRIPTION	BY
REVISIONS			
e-mail: mail@Harrissurveys.co.uk			
		CHEQUERS WINCHESTER ROAD WALTHAM CHASE SOUTHAMPTON HAMPSHIRE SO32 2LG TEL: 01489 894394 FAX: 01489 894394	
HARRIS SURVEYS LTD			
Project Title: 5 Surrey Wharf Arundel West Sussex			
Drawing Title: First Floor Plan			
Client	Neil Holland Architects		
Dwg.No:	11806_1	Scale	1:50
Drawn	RC	Date	June 2011
Level Note All levels based on arbitrary datum.			