



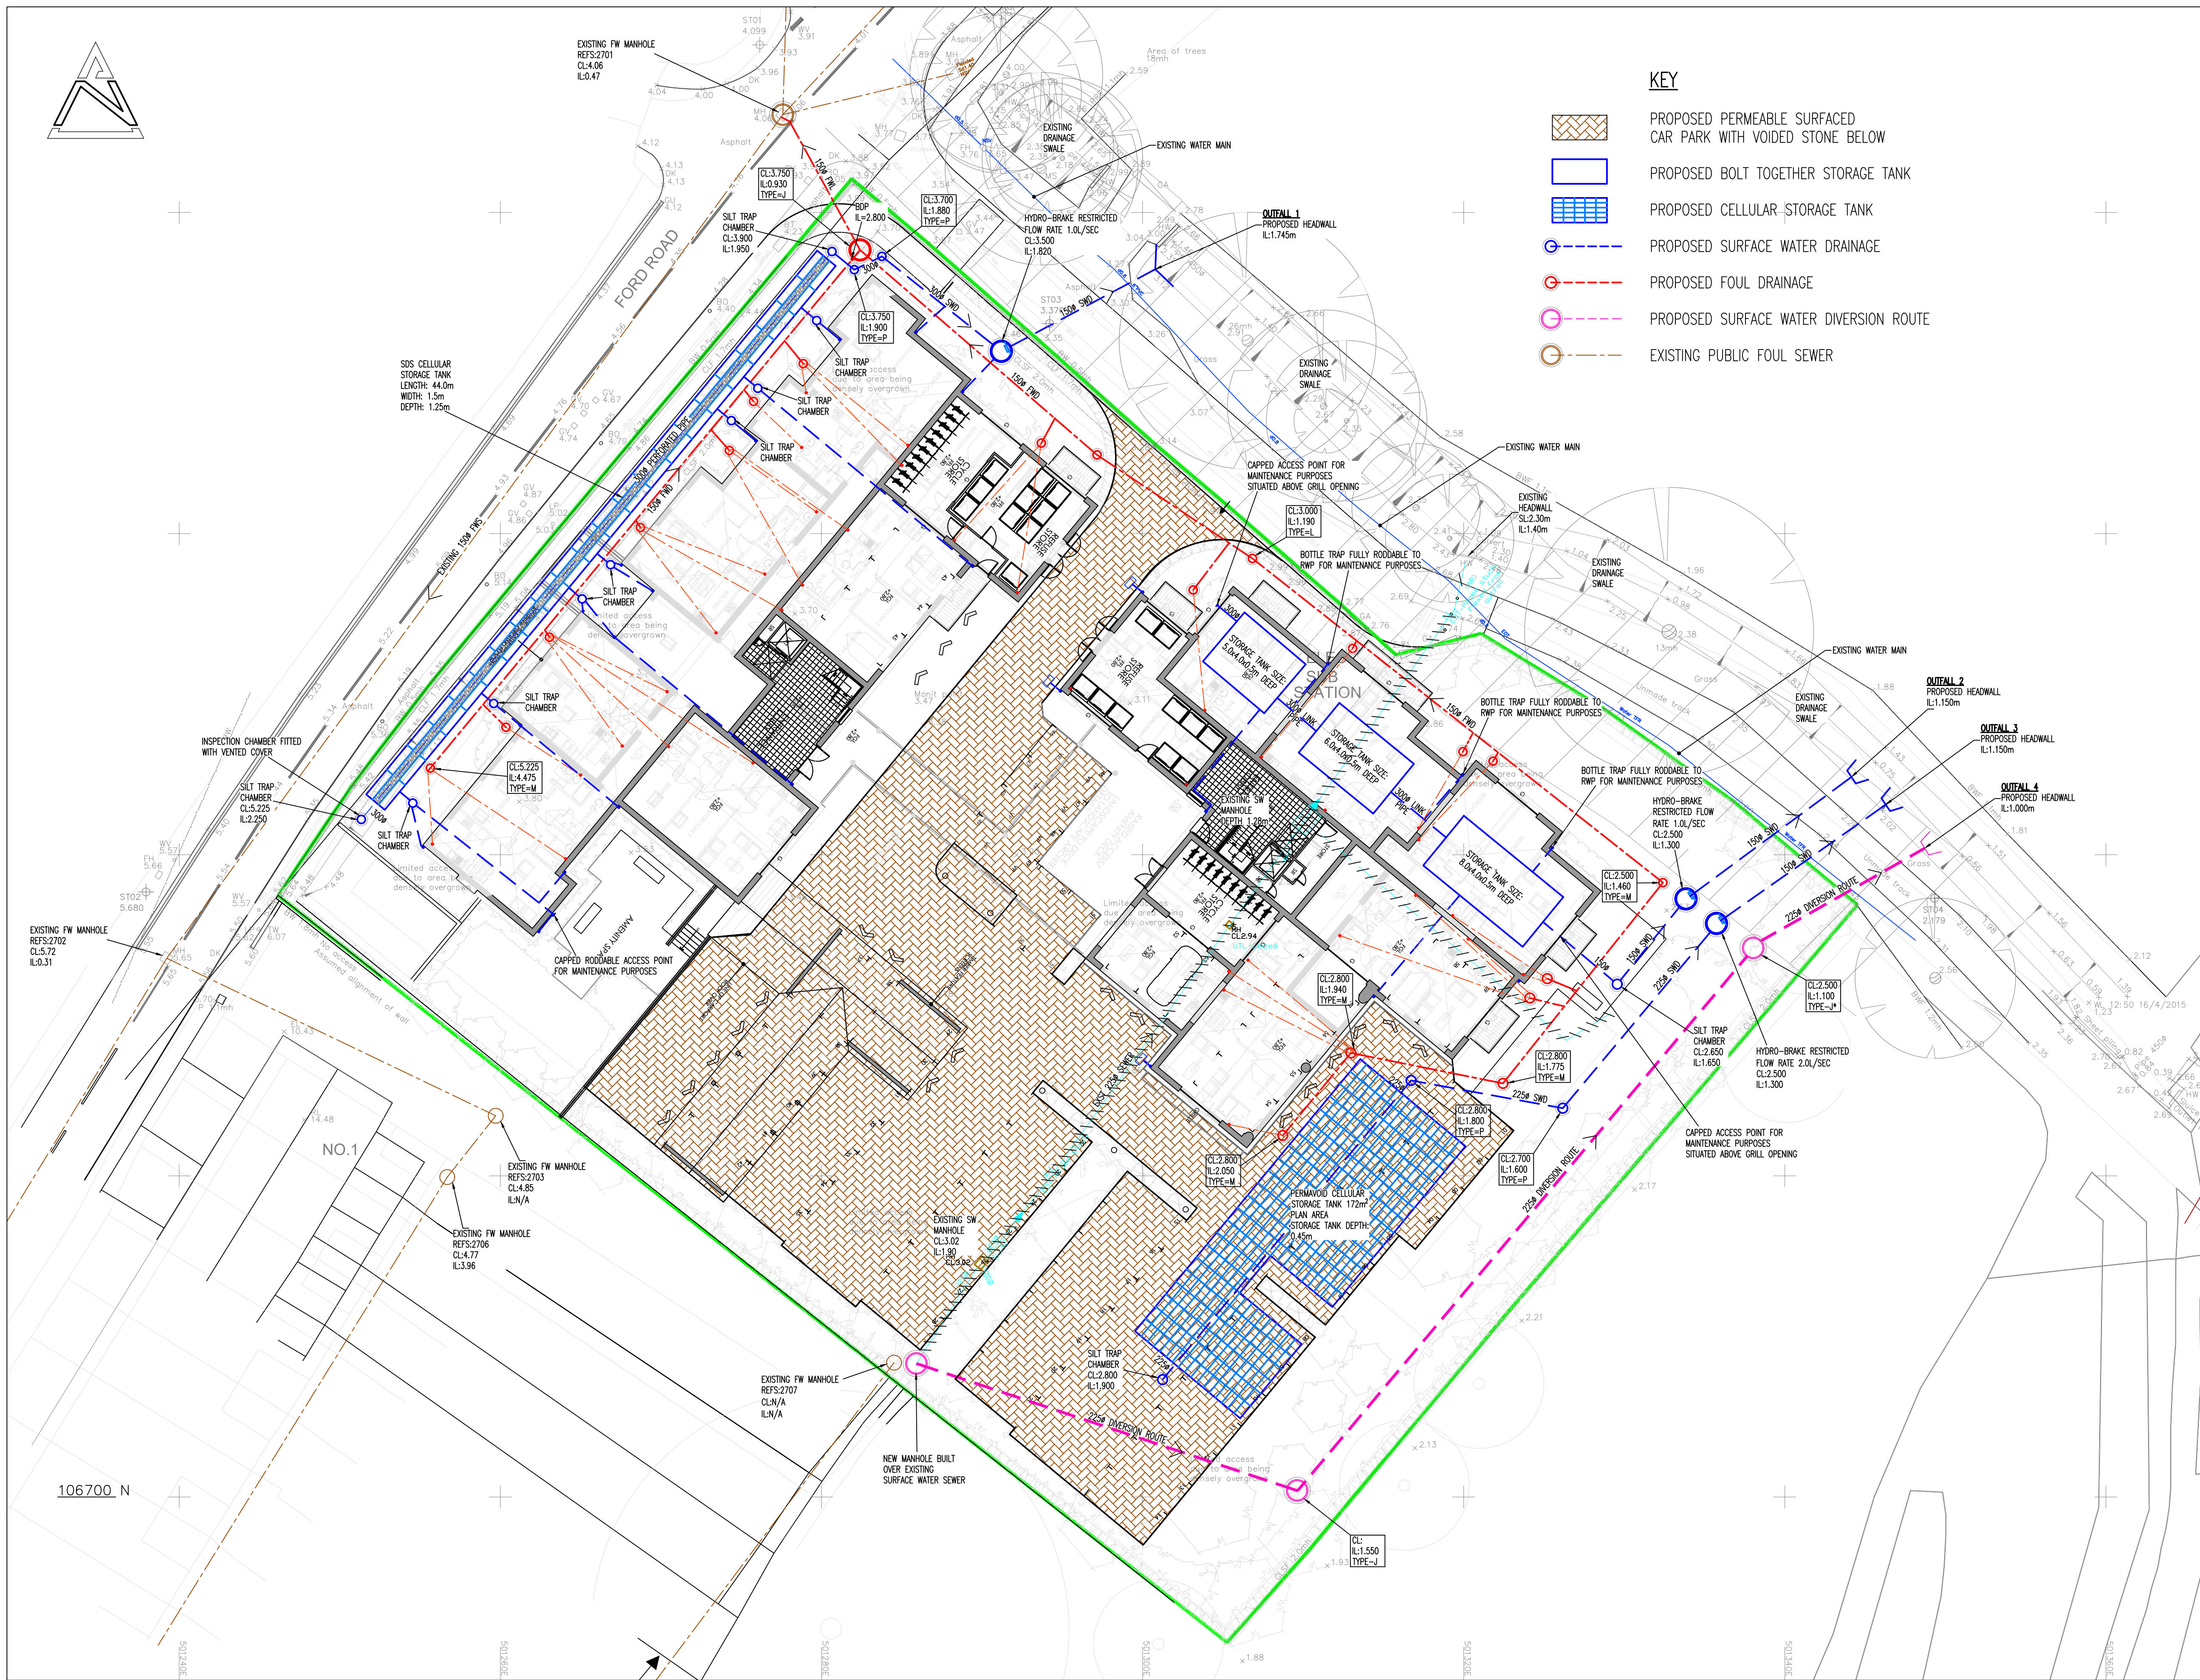



SITE DRAINAGE PLAN
SCALE 1:200

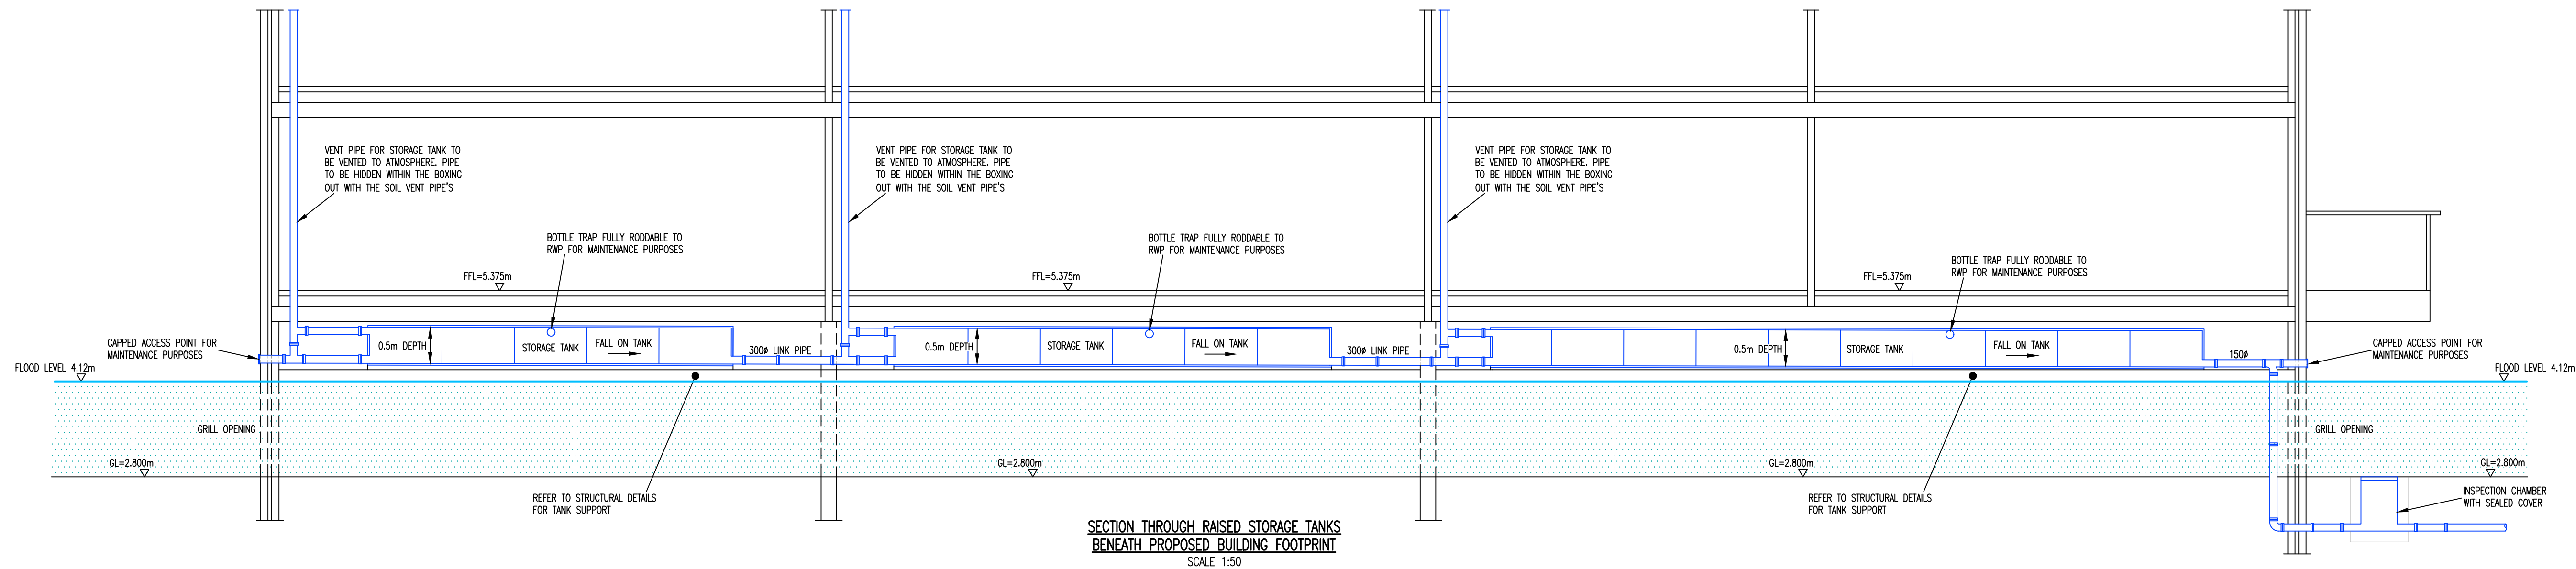

SECTION THROUGH RAISED STORAGE TANKS
BENEATH PROPOSED BUILDING FOOTPRINT
SCALE 1:50

ALL PROPOSED INSPECTION CHAMBERS & MANHOLES THAT HAVE A COVER LEVEL LOWER THAN THAT OF THE FLOOD LEVEL OF 4.12m TO BE FITTED WITH A SEALED COVER.


AN ADDITIONAL STORAGE VOLUME OF 164m³ IS PROVIDED WITHIN THE PERMEABLE PAVING SUB-BASE STORAGE STONE (30% VOID RATIO) BASED ON A DEPTH OF 400mm. THIS WILL HELP COMPENSATE FOR THE FLUVIAL FLOOD WATER

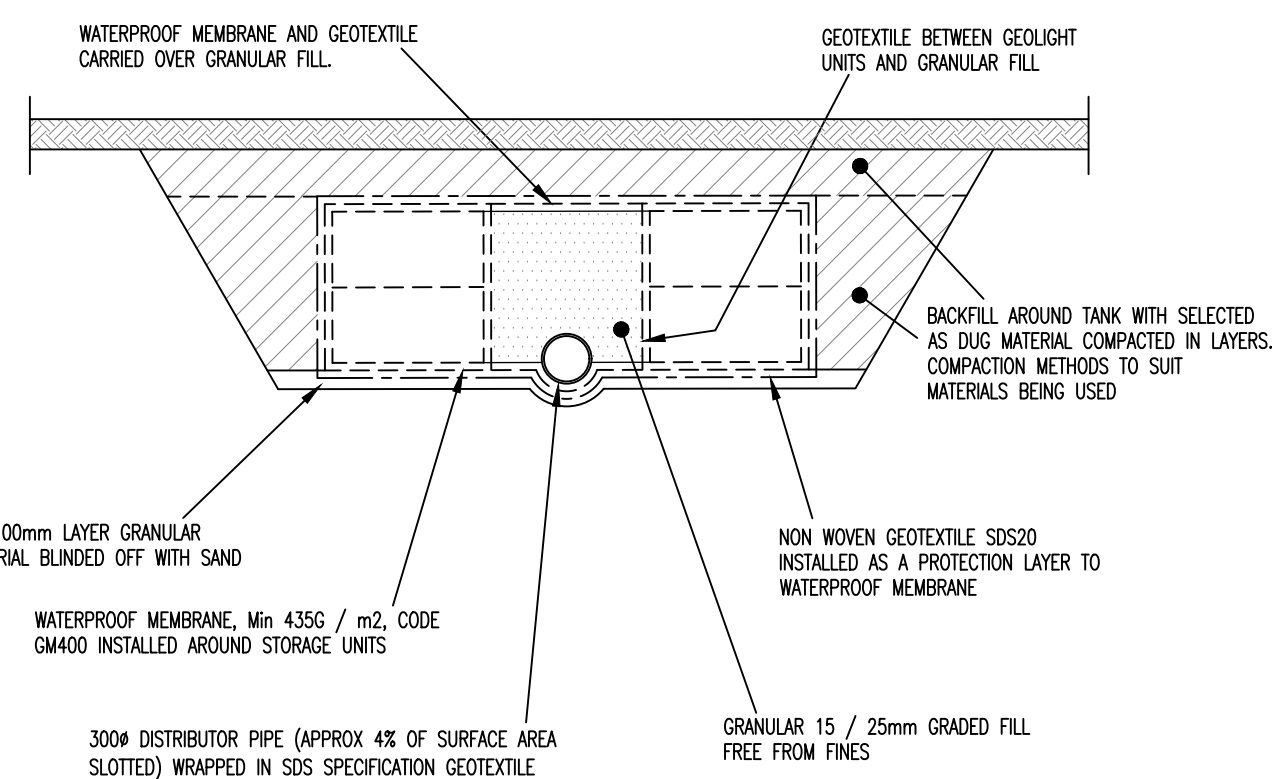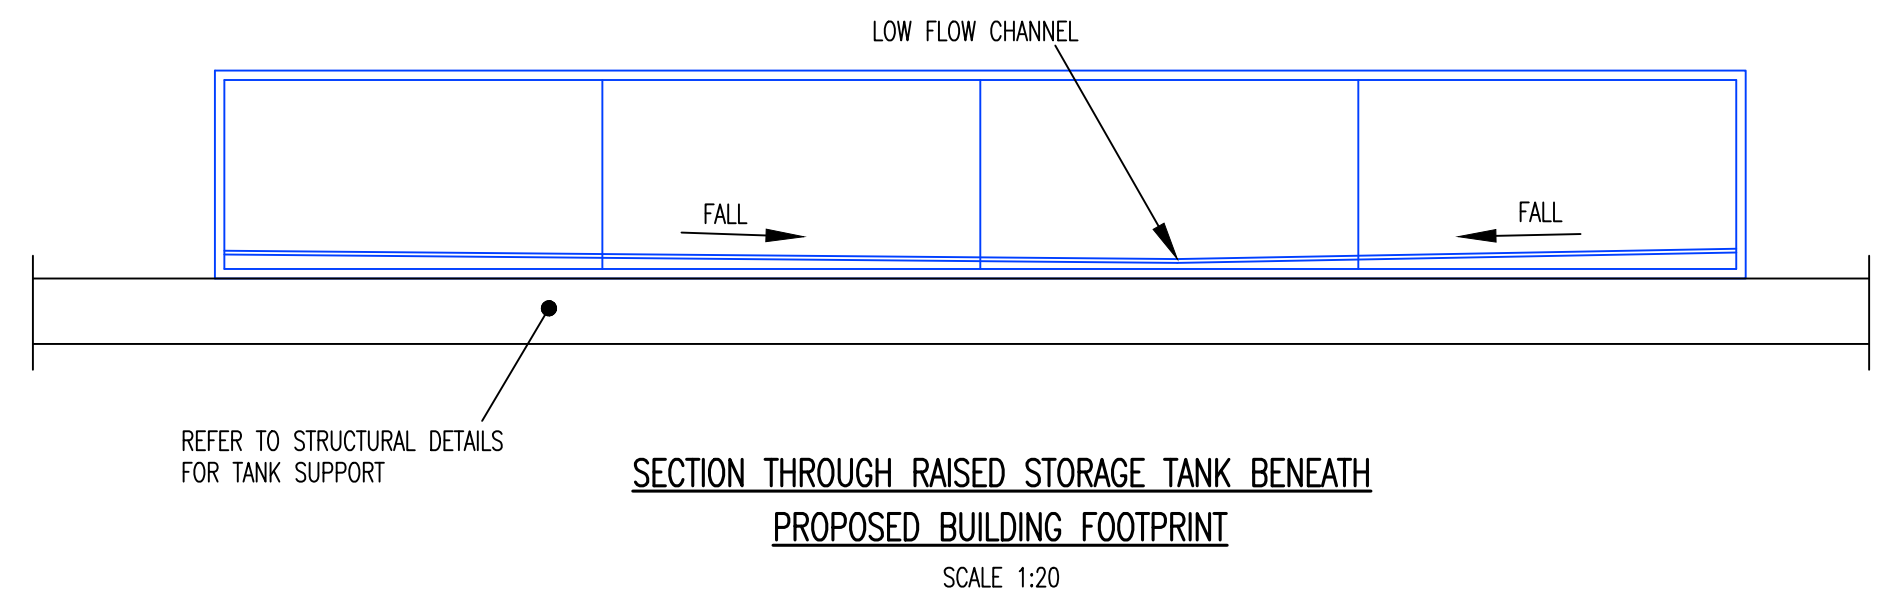

SDS GEOLIGHT - SURFACE WATER STORAGE FACILITY INSTALLATION DETAIL
SCALE = 1:50

NOTE:
IF GROUND CONDITIONS AT FORMATION LEVEL ARE NOT AS ANTICIPATED DOWNGRADEMENT OF SUB BASE BLINDING LAYER MAY BE REQUIRED. ENGINEER TO BE CONSULTED BEFORE LAYING OF ANY UNITS.
THIS DETAIL HAS BEEN BASED ON TYPICAL INSTALLATION DIAGRAM. IT IS THE CONTRACTORS RESPONSIBILITY TO ENSURE SDS GEOLIGHT UNITS ARE INSTALLED STRICTLY IN ACCORDANCE WITH MANUFACTURERS INSTRUCTIONS.

NOTES
1. THIS DRAWING SHALL BE READ IN CONJUNCTION WITH ALL RELEVANT ENGINEER'S DRAWINGS. ANY DISCREPANCIES FOUND BETWEEN INFORMATION SHOWN ON THIS OR ANY OTHER DRAWING SHALL BE REPORTED TO THE ENGINEER IMMEDIATELY AND PRIOR TO ANY WORKS COMMENCING ON SITE.

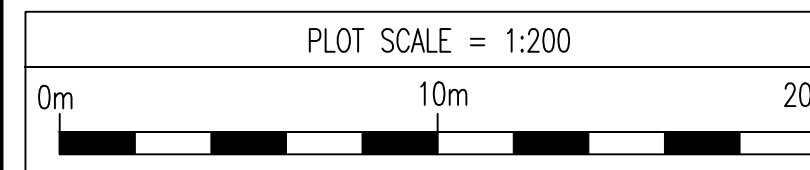

B	APR 20	DRAINAGE PROPOSAL REVISED TO SUIT COMMENTS RECEIVED BY EMAIL DATED 22/04/20	NJ
A	APR 20	DRAINAGE PROPOSAL REVISED TO SUIT COMMENTS RECEIVED BY EMAIL DATED 02/04/20	NJ
REV	DATE	DESCRIPTION	BY

PLANNING

This drawing is the property and copyright of the Consulting Engineer and shall not without written consent be reproduced in a third party.

OAKFORD HOMES

FORD ROAD, ARUNDEL

Strategy Site Drainage Plan
& Drainage Construction Details

SDP CONSULTING ENGINEERS
Head Office, Suite 3, Solar House, Camptford Road, St Albans, Hertfordshire, AL1 1JY
Tel: 01727 844606 Fax: 01727 830771 Email: mail@sdpc.co.uk
Southern Office, 21a Bargates, Chichester, Dorset, BH23 1QD
Tel: 01727 844606 Fax: 01202 494601 Email: sdpsouth@sdpc.co.uk

SCALE	DATE	DATE
1:200	NJ	Feb 20
DESIGNED	NG	REVISED
DRAWING NO.	E19-003-1000	REV
		B