
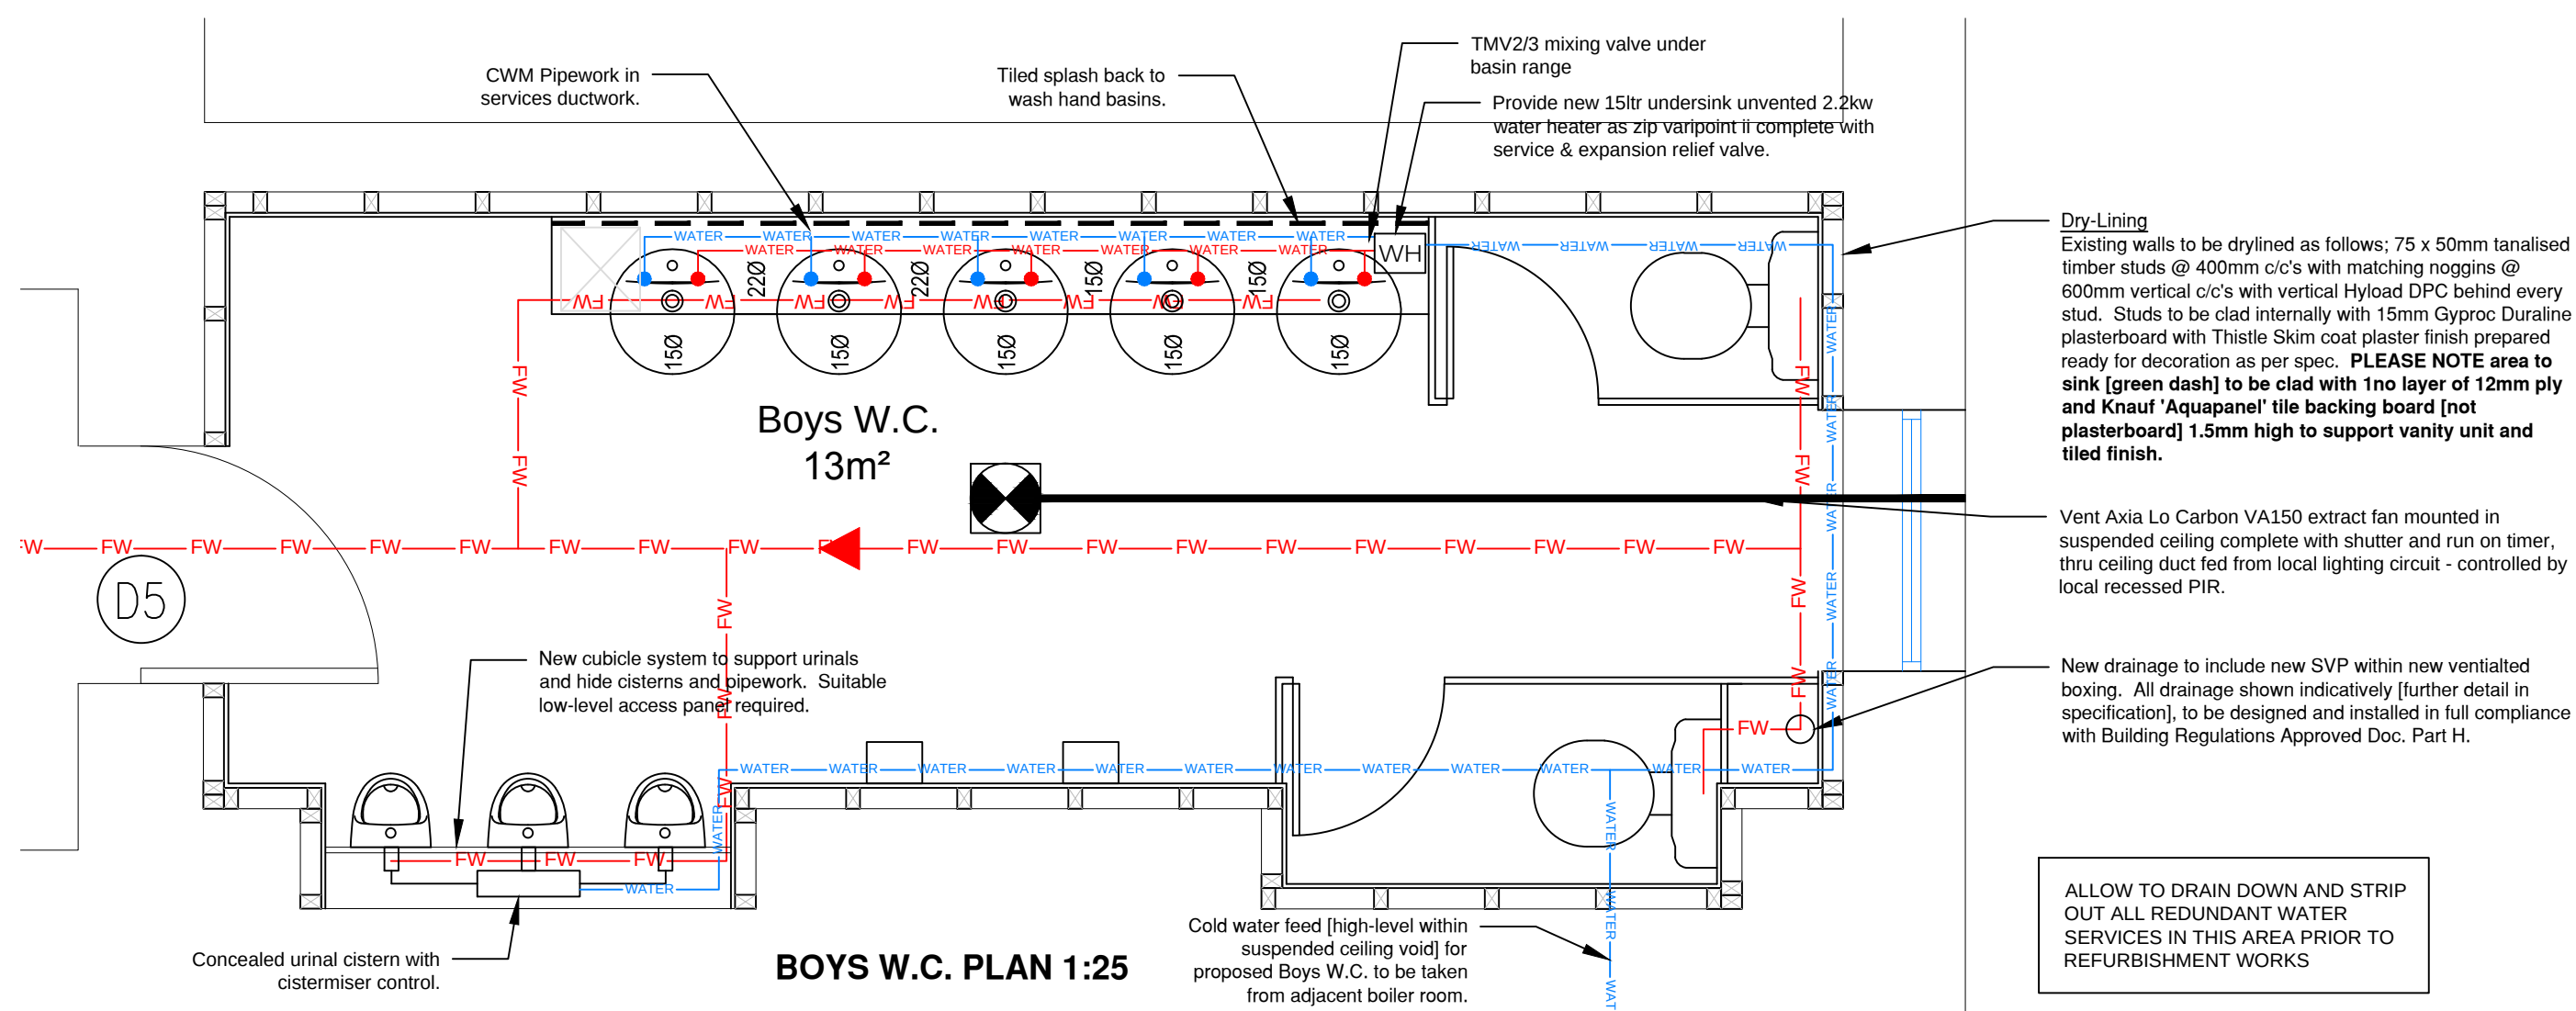
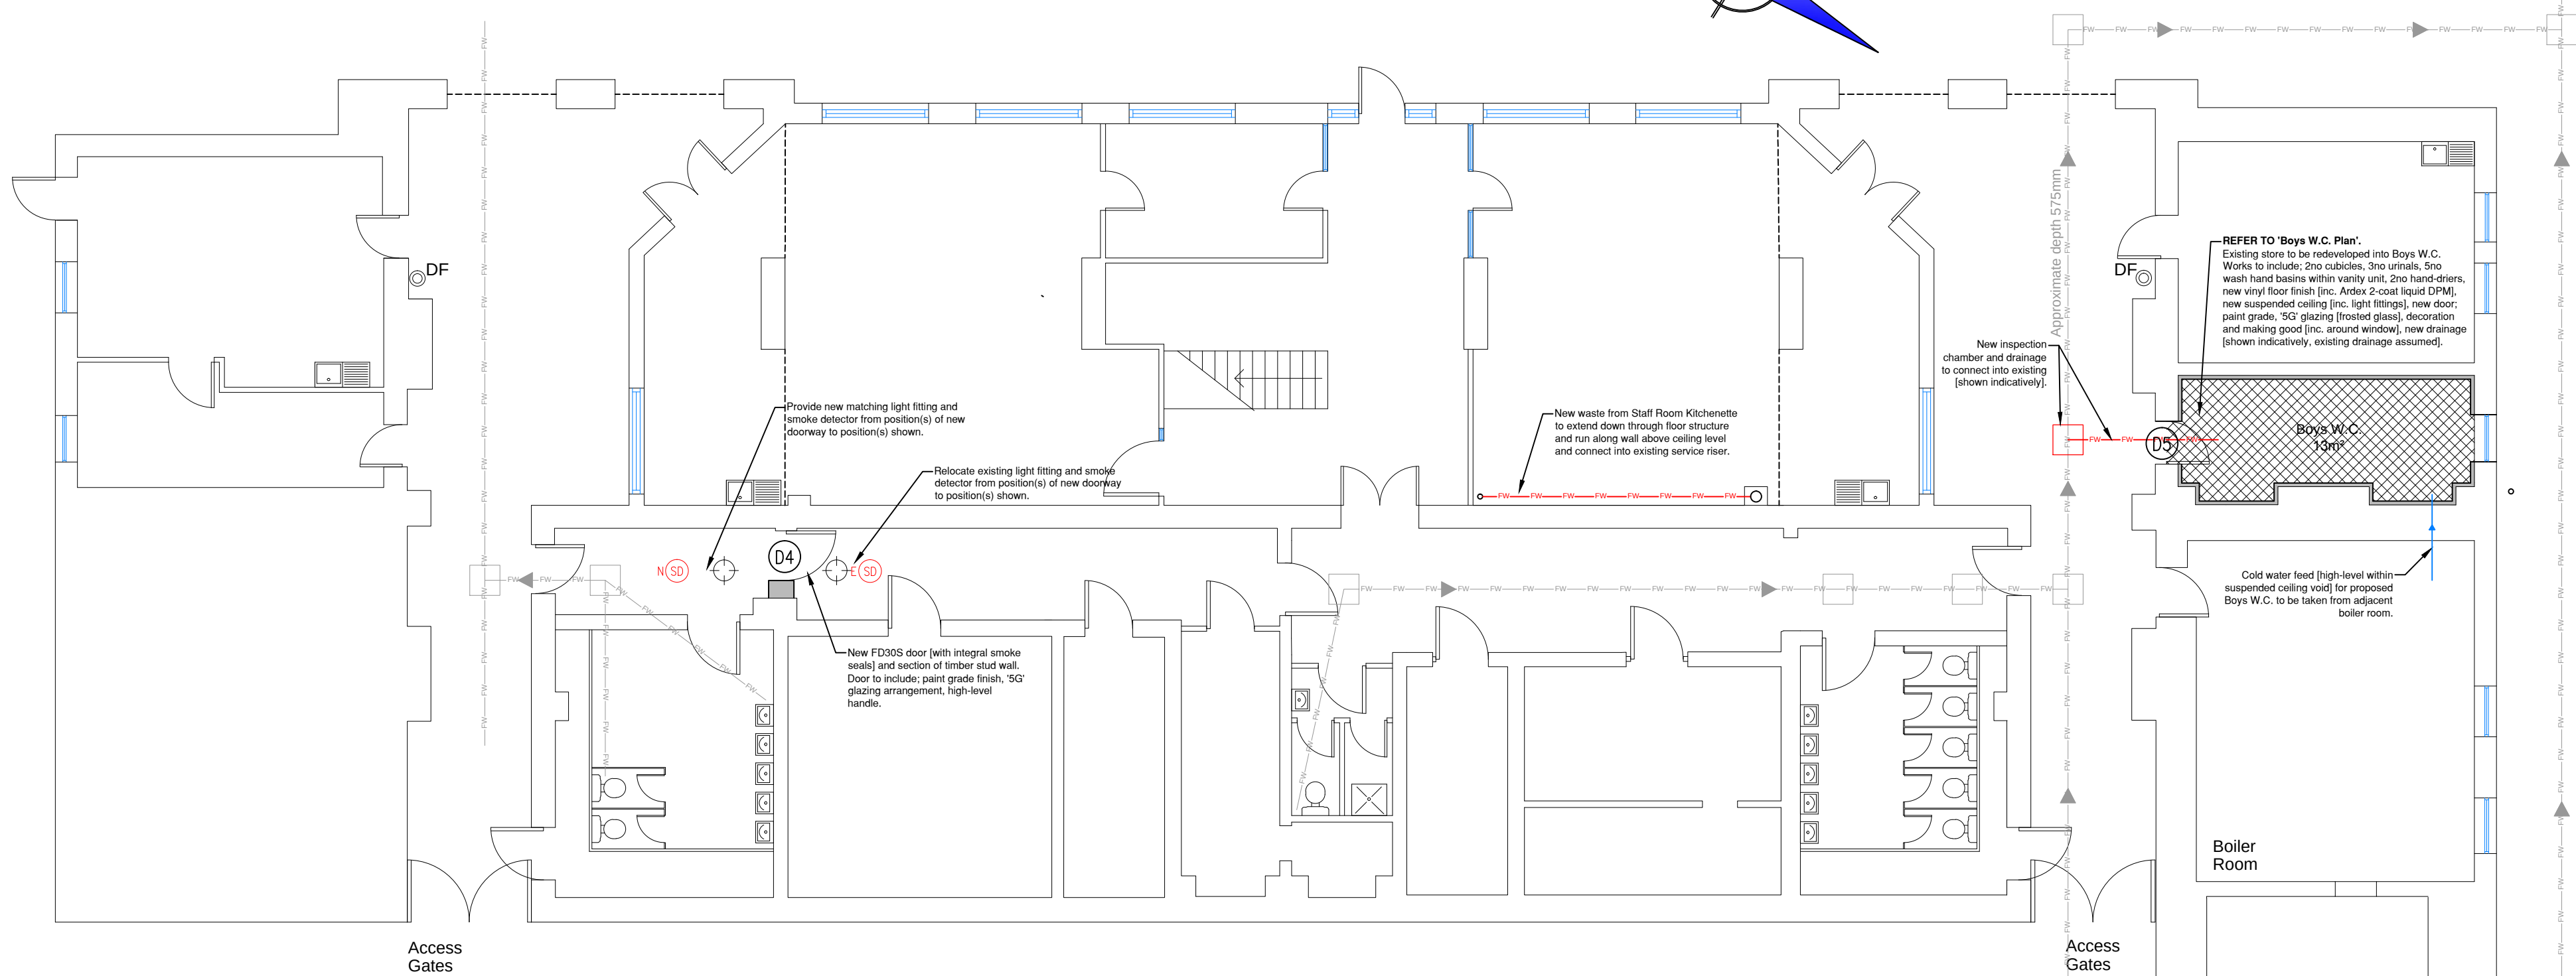
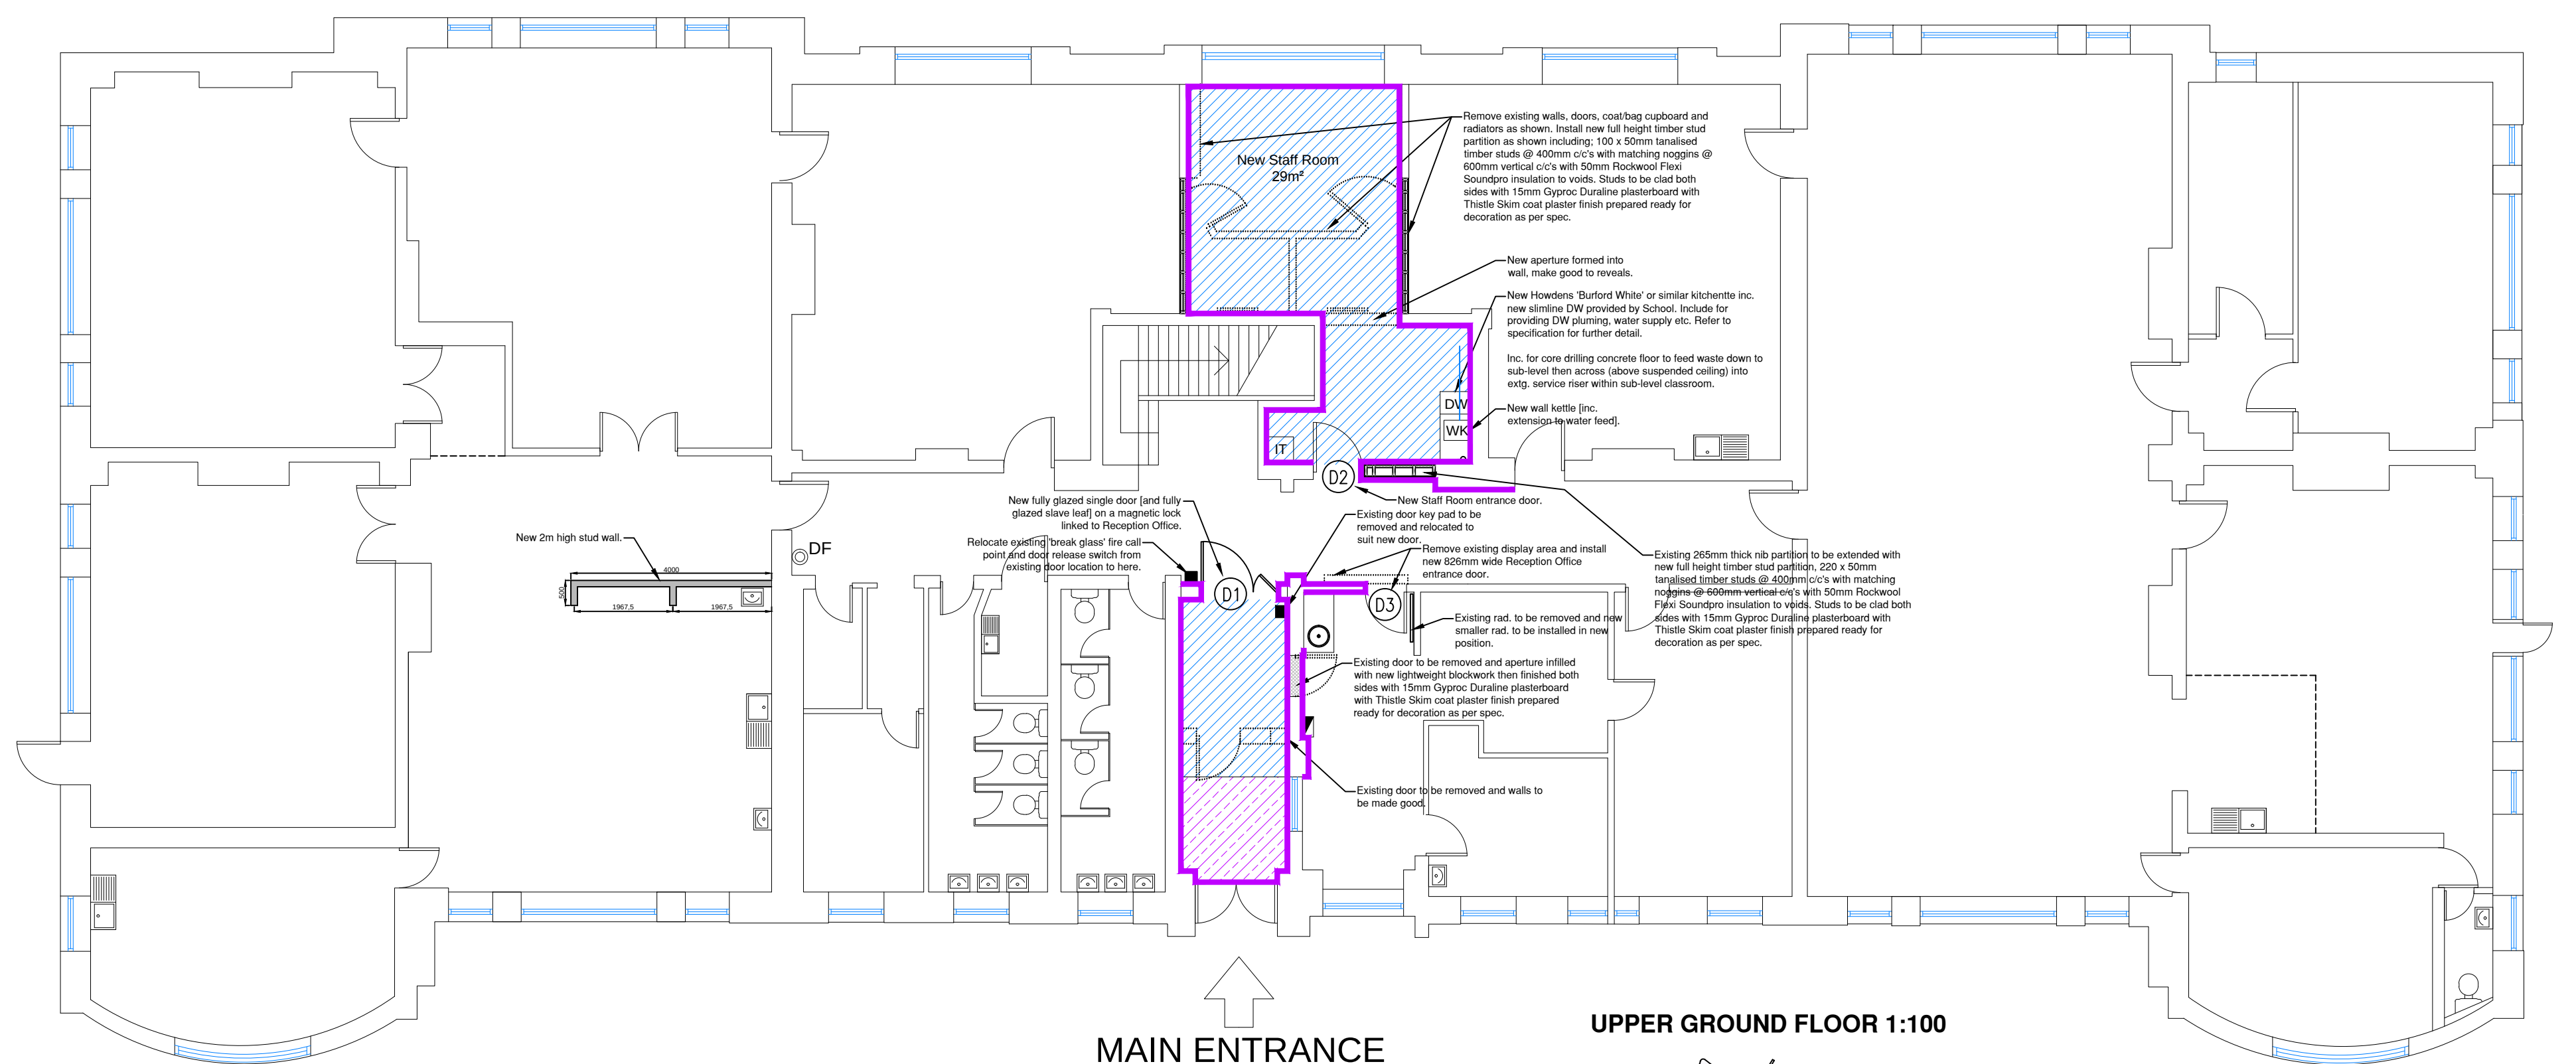
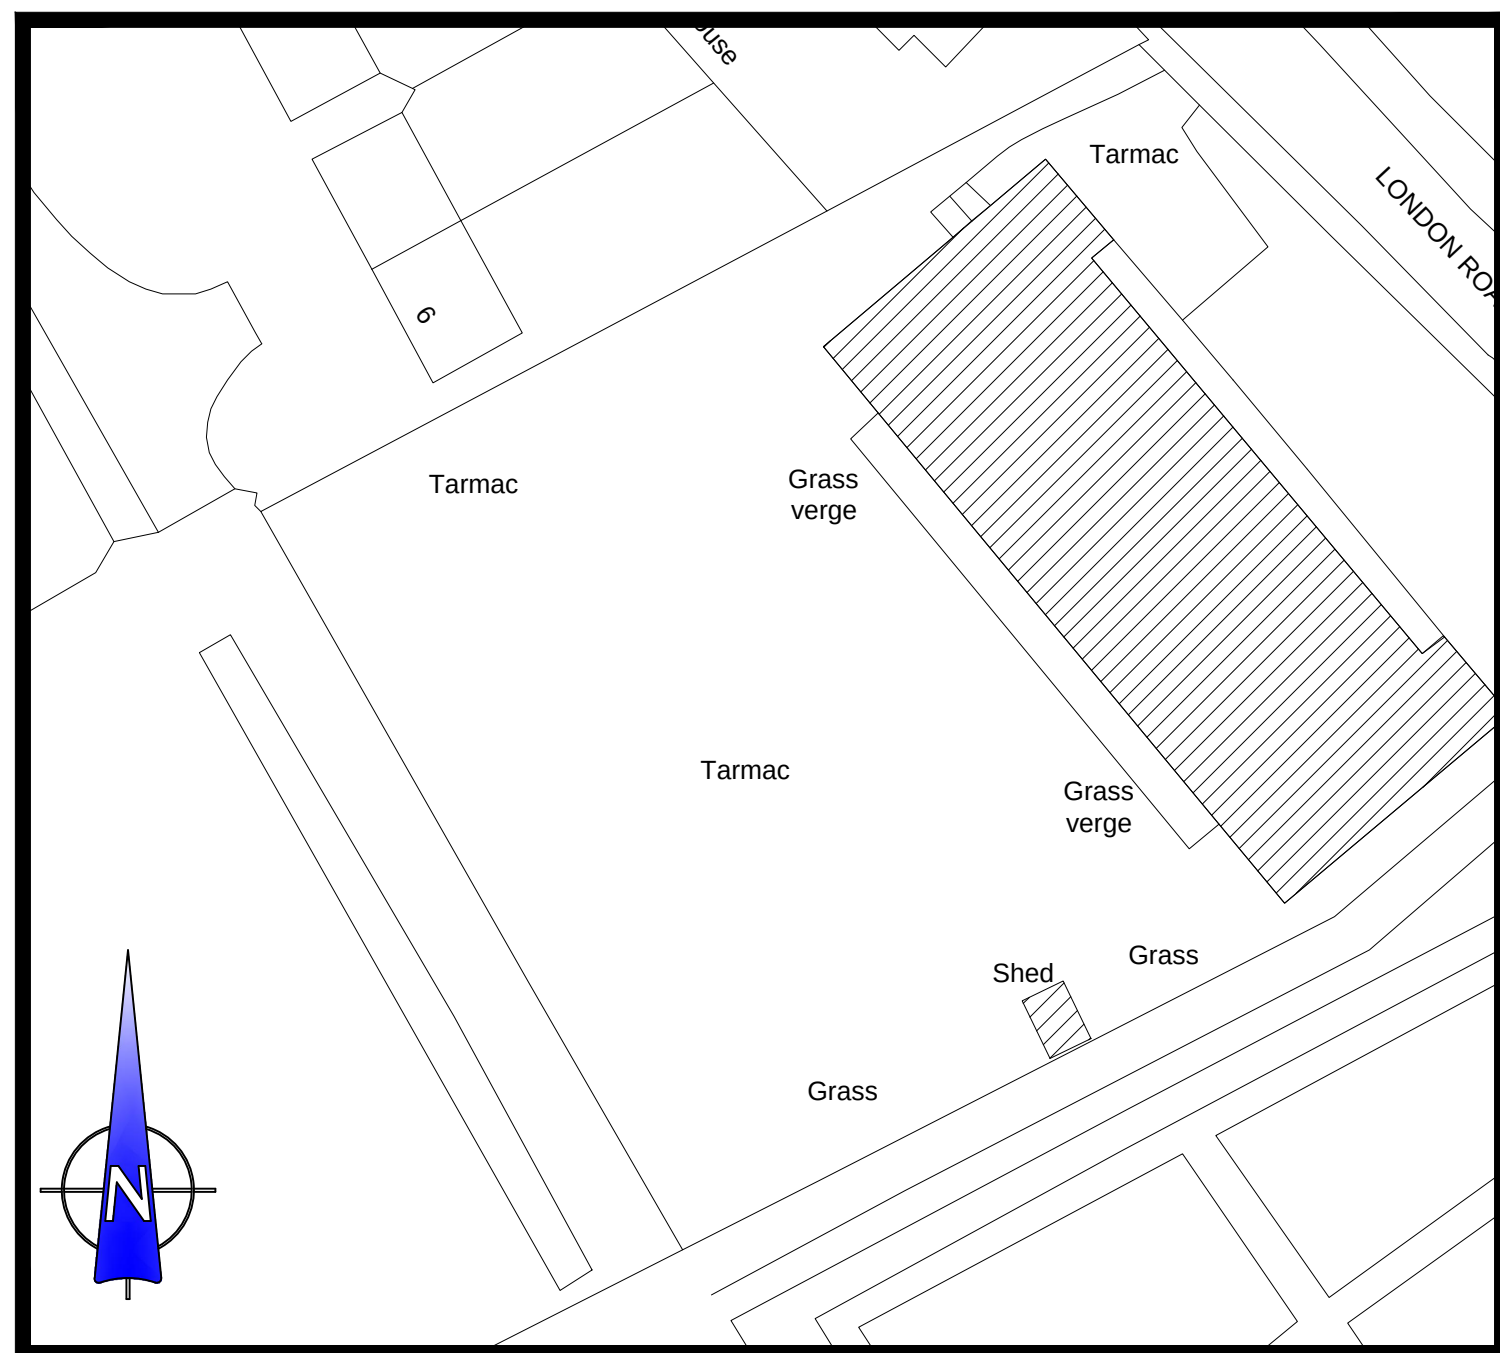


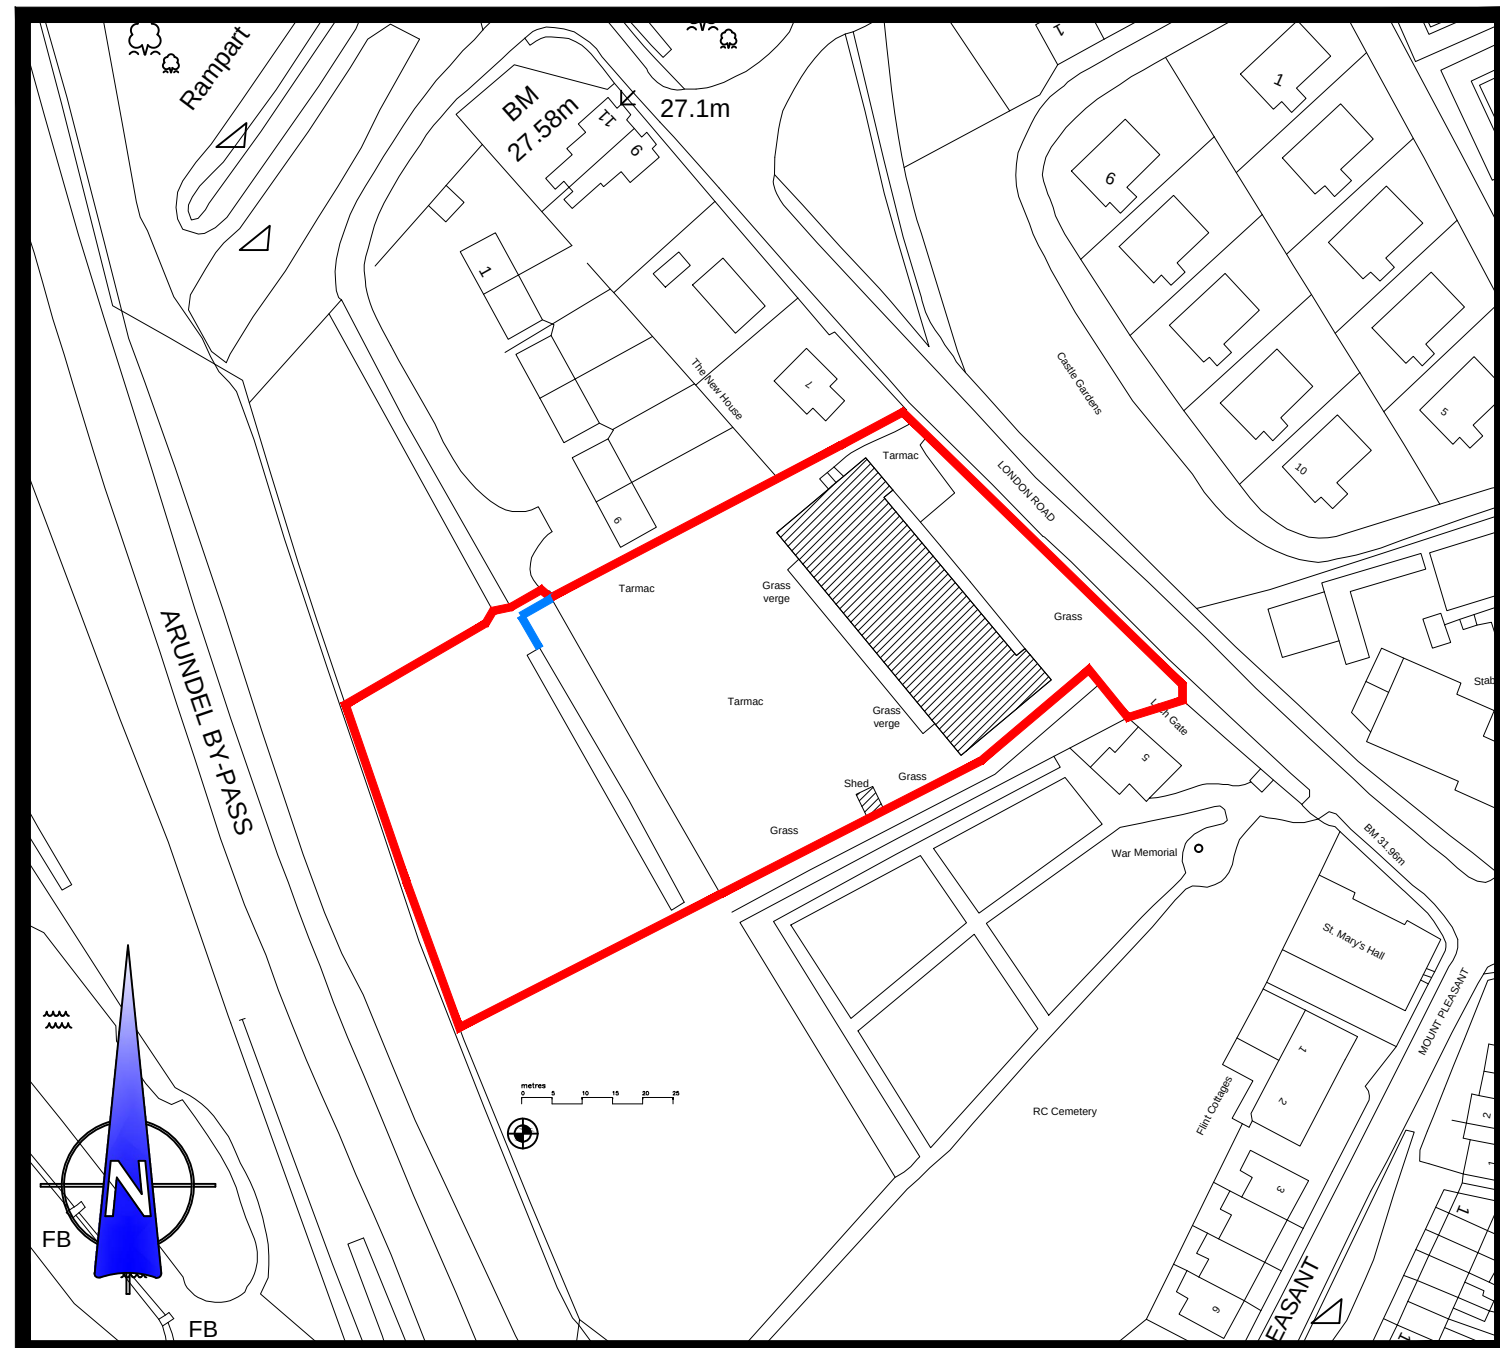

All details are indicative only. All dimensions to be checked on contractor prior to commencement of works. Any discrepancy drawings to be reported to Philips Surveyors LLP.

FINISHES LEGEND	
	New Rawson 'Felkirk' carpet tiles
	New Rawson 'Trackmaster' barrier ma
	New Altro 'Suprema I' slip resistant vin
	Existing walls to be decorated and/or redecorated.

—WATER— New cold water feed [taken from existing].

—WATER— New hot water feed [via water heater - as shown on drawing].

— FW — Existing foul drainage - shown indicatively

—FW— Proposed foul drainage - shown indicativ
All new drainage to be designed and insta
in full accordance with manufactu
instructions and Building Regulati
Approved Doc. Part H.

	<i>New wall-mounted kettle.</i>
	<i>Existing IT/Data panel.</i>
	<i>Existing Distribution Board</i>
	<i>Existing [relocated] Ceiling Light Point</i>
	<i>Existing [relocated] Fire Alarm Smoke Detector</i>
	<i>New Fire Alarm Smoke Detector</i>

Rev.	Amendments	Date

PS PHILIPS SURVEYORS
BUILDING SURVEYORS, DESIGNERS & CONS

PHILIPS SURVEYORS LLP, THE OLD COACH HOUSE, 78 LOWE STREET, PULBROUGH, WEST SUSSEX, RH20 2AA
TEL 01798 873222 FAX 01798 873444
EMAIL INFO@PHILIPS-SURVEYORS.CO.UK
WWW.PHILIPSHARTEREDSURVEYORS.CO.UK



CLIENT:
St. Philips Catholic Primary School
London Road, Arundel, West
Sussex. BN18 9BA

PROJECT:
St. Philips Catholic Primary School
London Road, Arundel, West
Sussex. BN18 9BA

Internal Alterations

DRAWING TITLE:

Works Identification Plan; Propo:
Floor Plans; Notes.

DRAWN: MAB	JOB NO: 1985/15	SCALE: @A1
CHECKED: WRC	DRAWING NO: T01	REV: A
DATE: Jun 2015		

© Philips Surveyors LLP.