


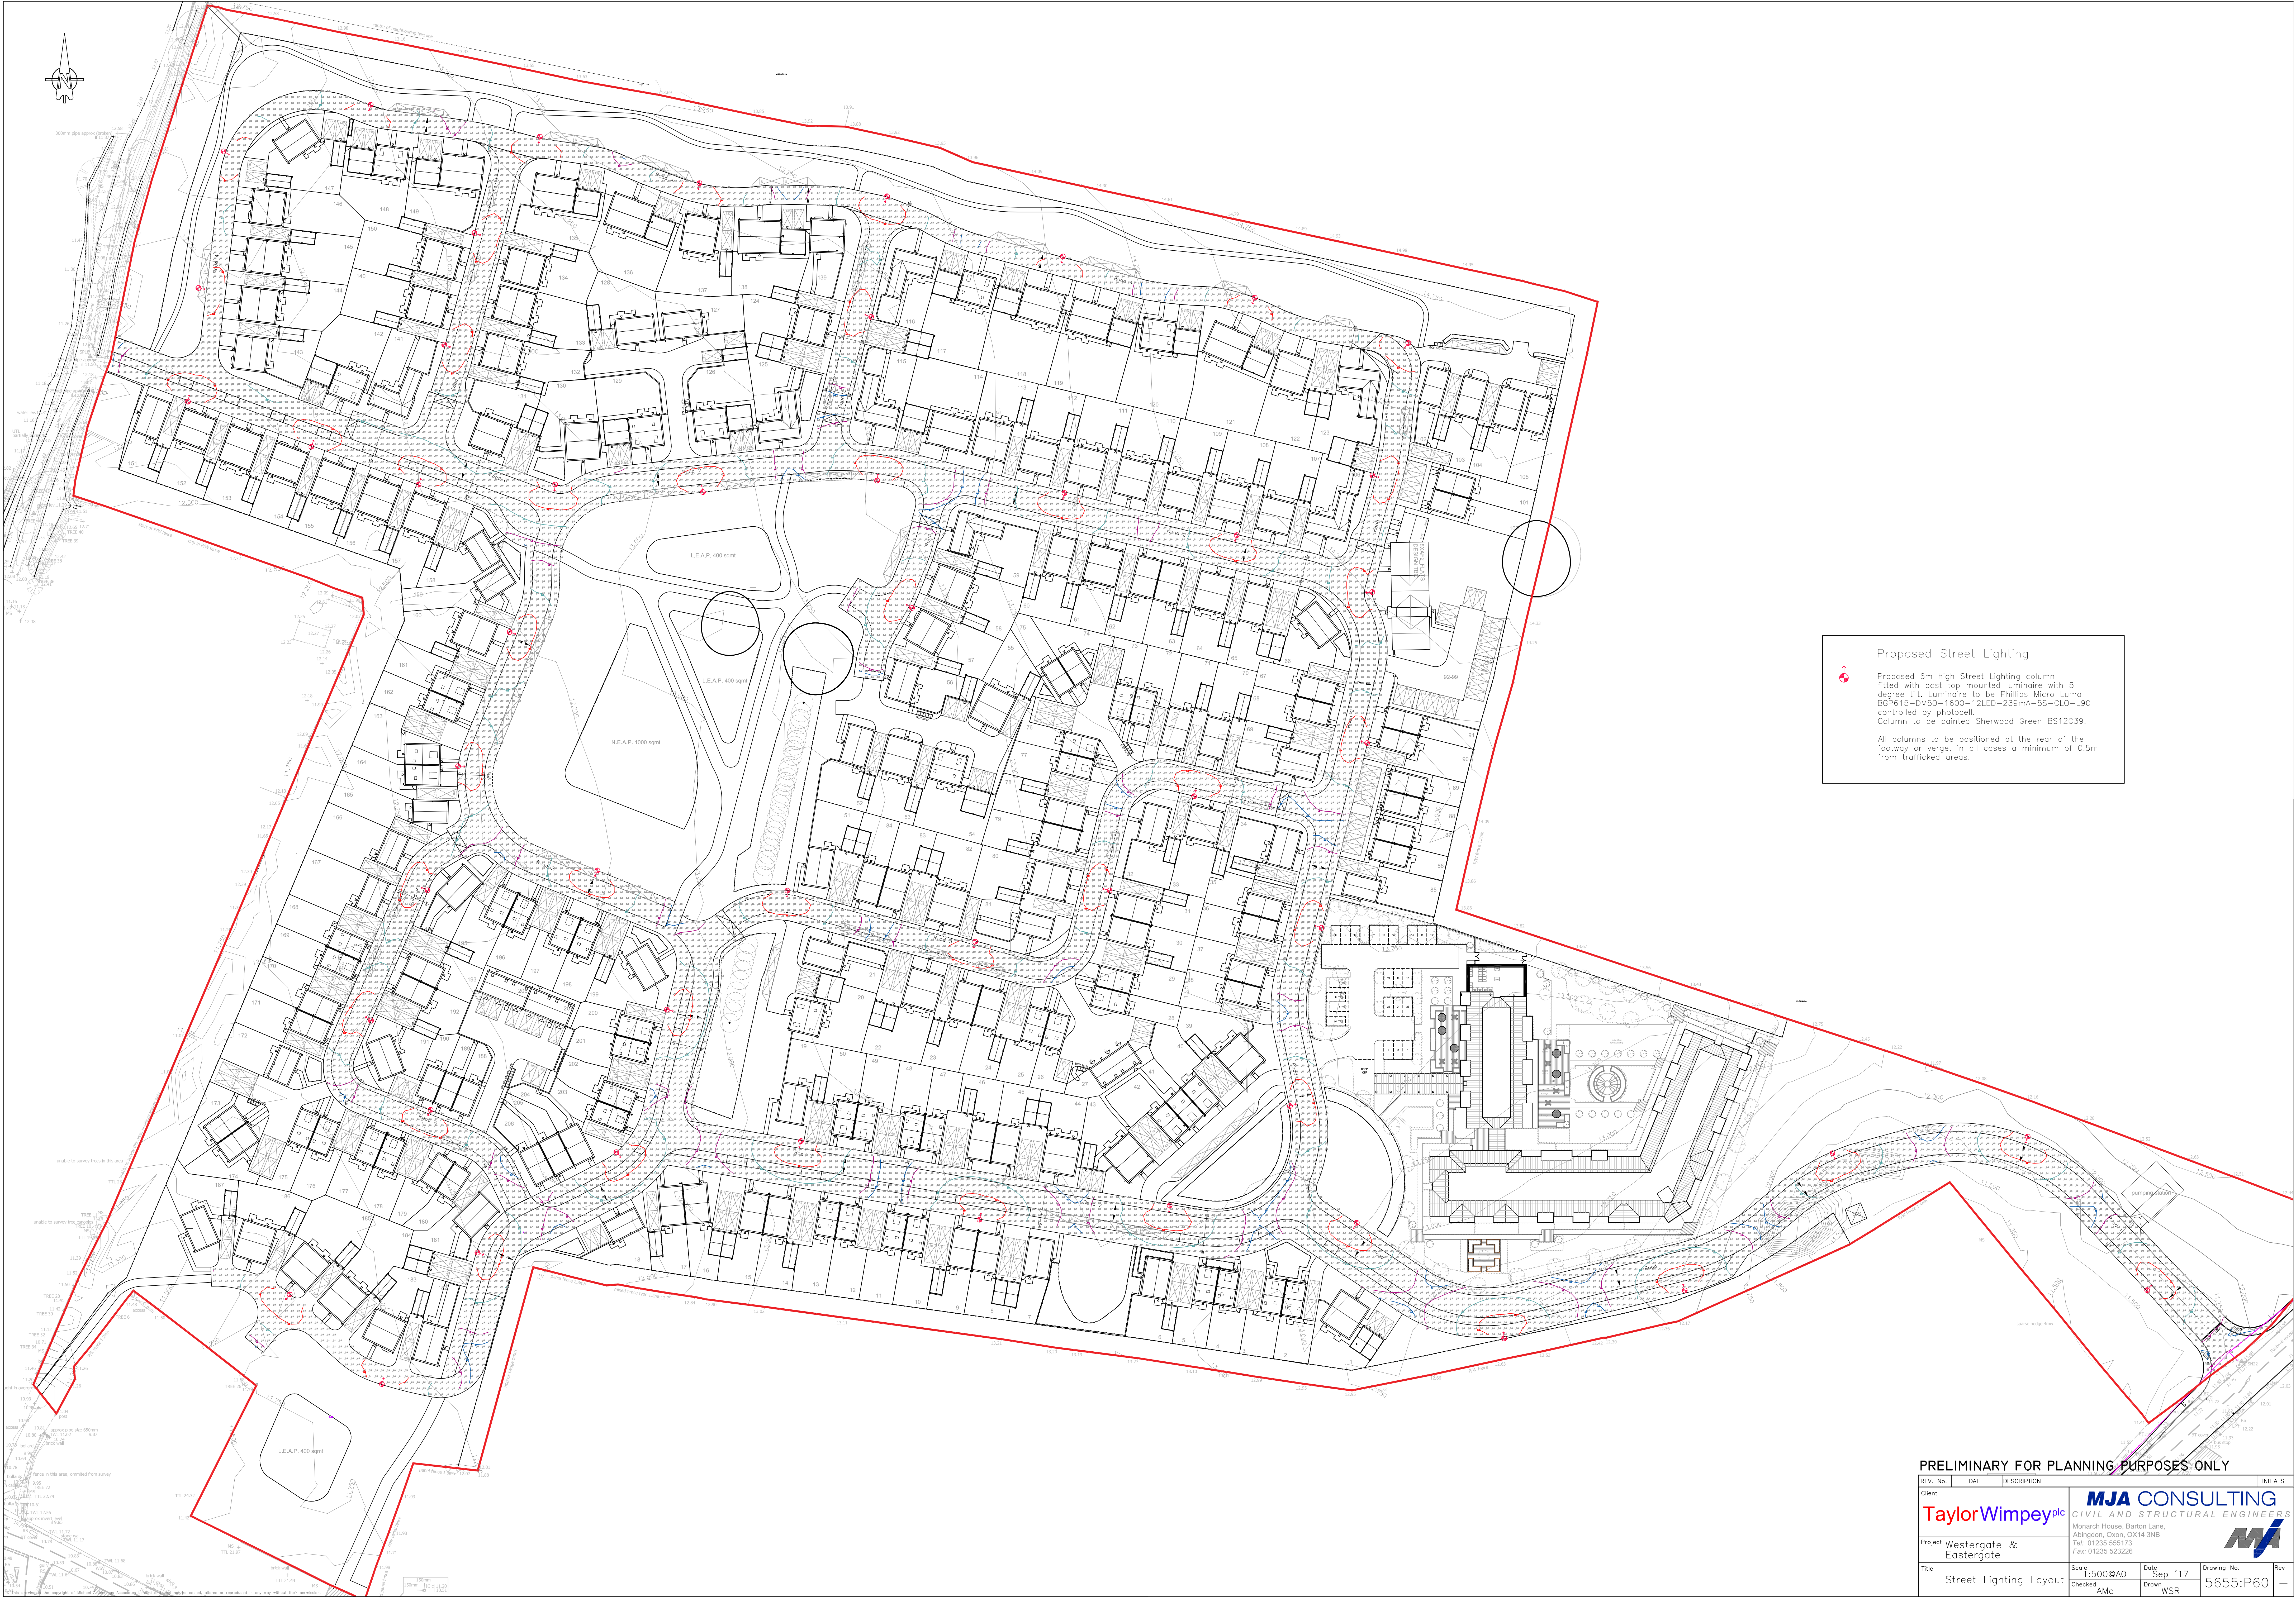

Proposed Street Lighting

Proposed 6m high Street Lighting column fitted with post top mounted luminaire with 5 degree tilt. Luminaire to be Phillips Micro Luma BGP615-DW50-1600-12LED-239mA-5S-CLO-L90 controlled by photocell.
Column to be painted Sherwood Green BS12C39.

All columns to be positioned at the rear of the footway or verge, in all cases a minimum of 0.5m from trafficked areas.

PRELIMINARY FOR PLANNING PURPOSES ONLY				
REV. No.	DATE	DESCRIPTION	INITIALS	
Client			MJA CONSULTING CIVIL AND STRUCTURAL ENGINEERS Monarch House, Barton Lane, Abingdon, Oxon, OX14 3NB Tel: 01235 555173 Fax: 01235 523226 	
Project			Westergate & Eastergate	
Title	Street Lighting Layout		Scale 1:500@A0 Checked AMC	Date Sep '17 Drawn WSR
			Drawing No.	Rev
			5655:P60	—