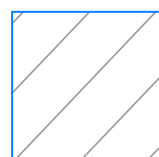
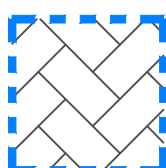
 
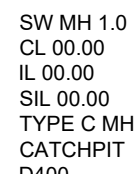




DESIGN SUBJECT TO THE APPROVAL OF:
PLANNING AUTHORITY
BUILDING CONTROL
SOUTHERN WATER

EXISTING FEATURES

- 

PROPOSED FEATURES

- | | |
|---|--|
|  | STORM WATER SEWER/DRAIN |
|  | RAINWATER PIPE |
|  | STORM WATER 300Ø INSPECTION CHAMBER |
|  | STORM WATER INSPECTION CHAMBER 460Ø PPIC |
|  | STORM WATER GEOCELLULAR SOAKAWAY USING POLYPIPE POLYSTORM OR SIMILAR APPROVED
CL = COVER LEVEL
TOSL = TOP OF SOAKAWAY LEVEL
BOSL = BOTTOM OF SOAKAWAY LEVEL |
|  | INFILTRATING POROUS PAVING |
|  | FOUL WATER SEWER/DRAIN |
|  | SOIL STACK (TYPE TBC BY ARCHITECT/M/E ENGINEER) |
|  | FOUL WATER 300Ø INSPECTION CHAMBER |
|  | FOUL WATER INSPECTION CHAMBER 460Ø PPIC |
|  | PIPE DETAIL: Ø, LENGTH, GRADIENT,
BEDDING TYPE |
|  | MANHOLE REFERENCE:
COVER LEVEL,
INVERT LEVEL,
SUMP INVERT LEVEL,
MH TYPE,
CATCHPIT MANHOLE (IF REQUIRED),
COVER GRADE |

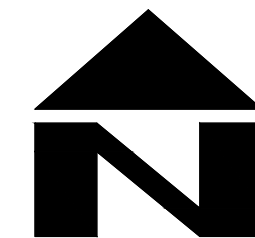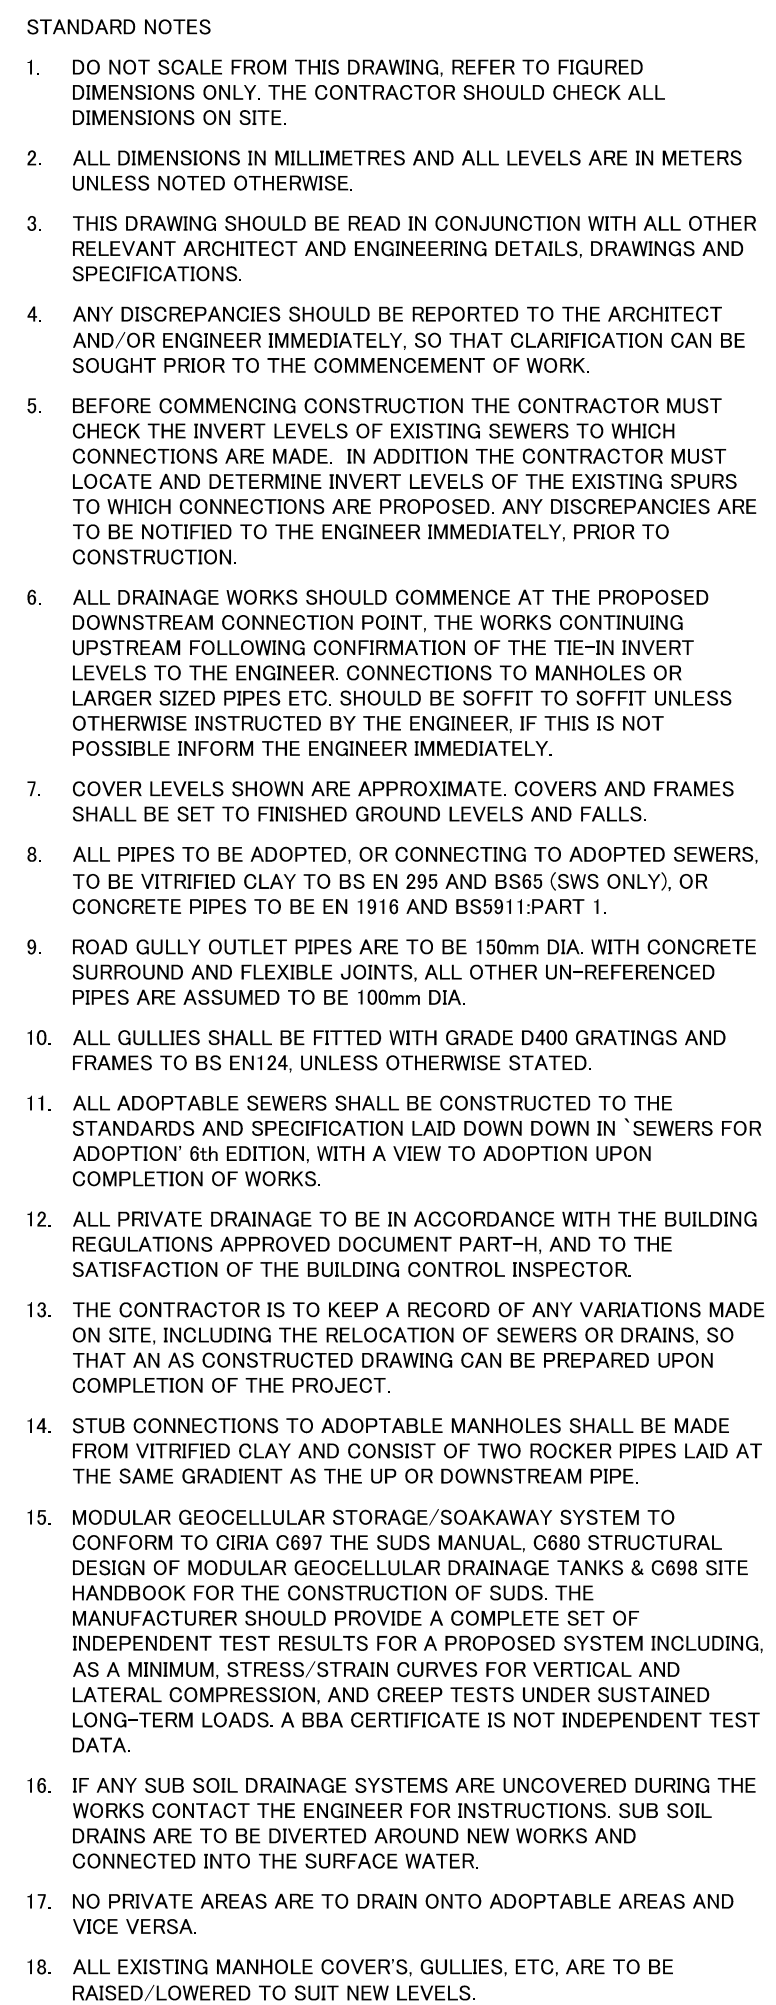

P.	14.09.18	PRELIMINARY ISSUE FOR COMMENT	C.S.	C.S.	-
REV	DATE	DESCRIPTION	BY	CHK	APP
					
CLIENT					
MR AND MRS LE CHEMINANT					
ARCHITECT					
RE-FORMAT					
JOB TITLE					
L'APACHE WESTERGATE STREET WESTERGATE					
DRAWING TITLE					
DRAINAGE LAYOUT					
DRAWN		ENGINEER		CHECKED	
C.S.		C. SLADE		C.S.	
DATE		SCALE @ A1		APPROVED	
SEP 2018		1:100		C.S.	
JOB No.		STATUS		DRAWING No.	
C1094		P		100	
				REV.	
				P-	

PRELIMINARY