




TREE SCHEDULE				
Number	Girth(m)	Spread(m)	Height(m)	Note
1.1	0.7	6	6	
1.2	0.7	6	6	
1.3	0.7	6	6	
1.4	0.7	6	6	
1.5	0.7	6	6	
1.6	0.7	6	6	
1.7	0.7	6	6	
1.8	0.7	6	6	
1.9	0.7	6	6	
1.10	0.7	6	6	
1.11	0.7	6	6	
1.12	0.7	6	6	
3.00	0.7	6	6	

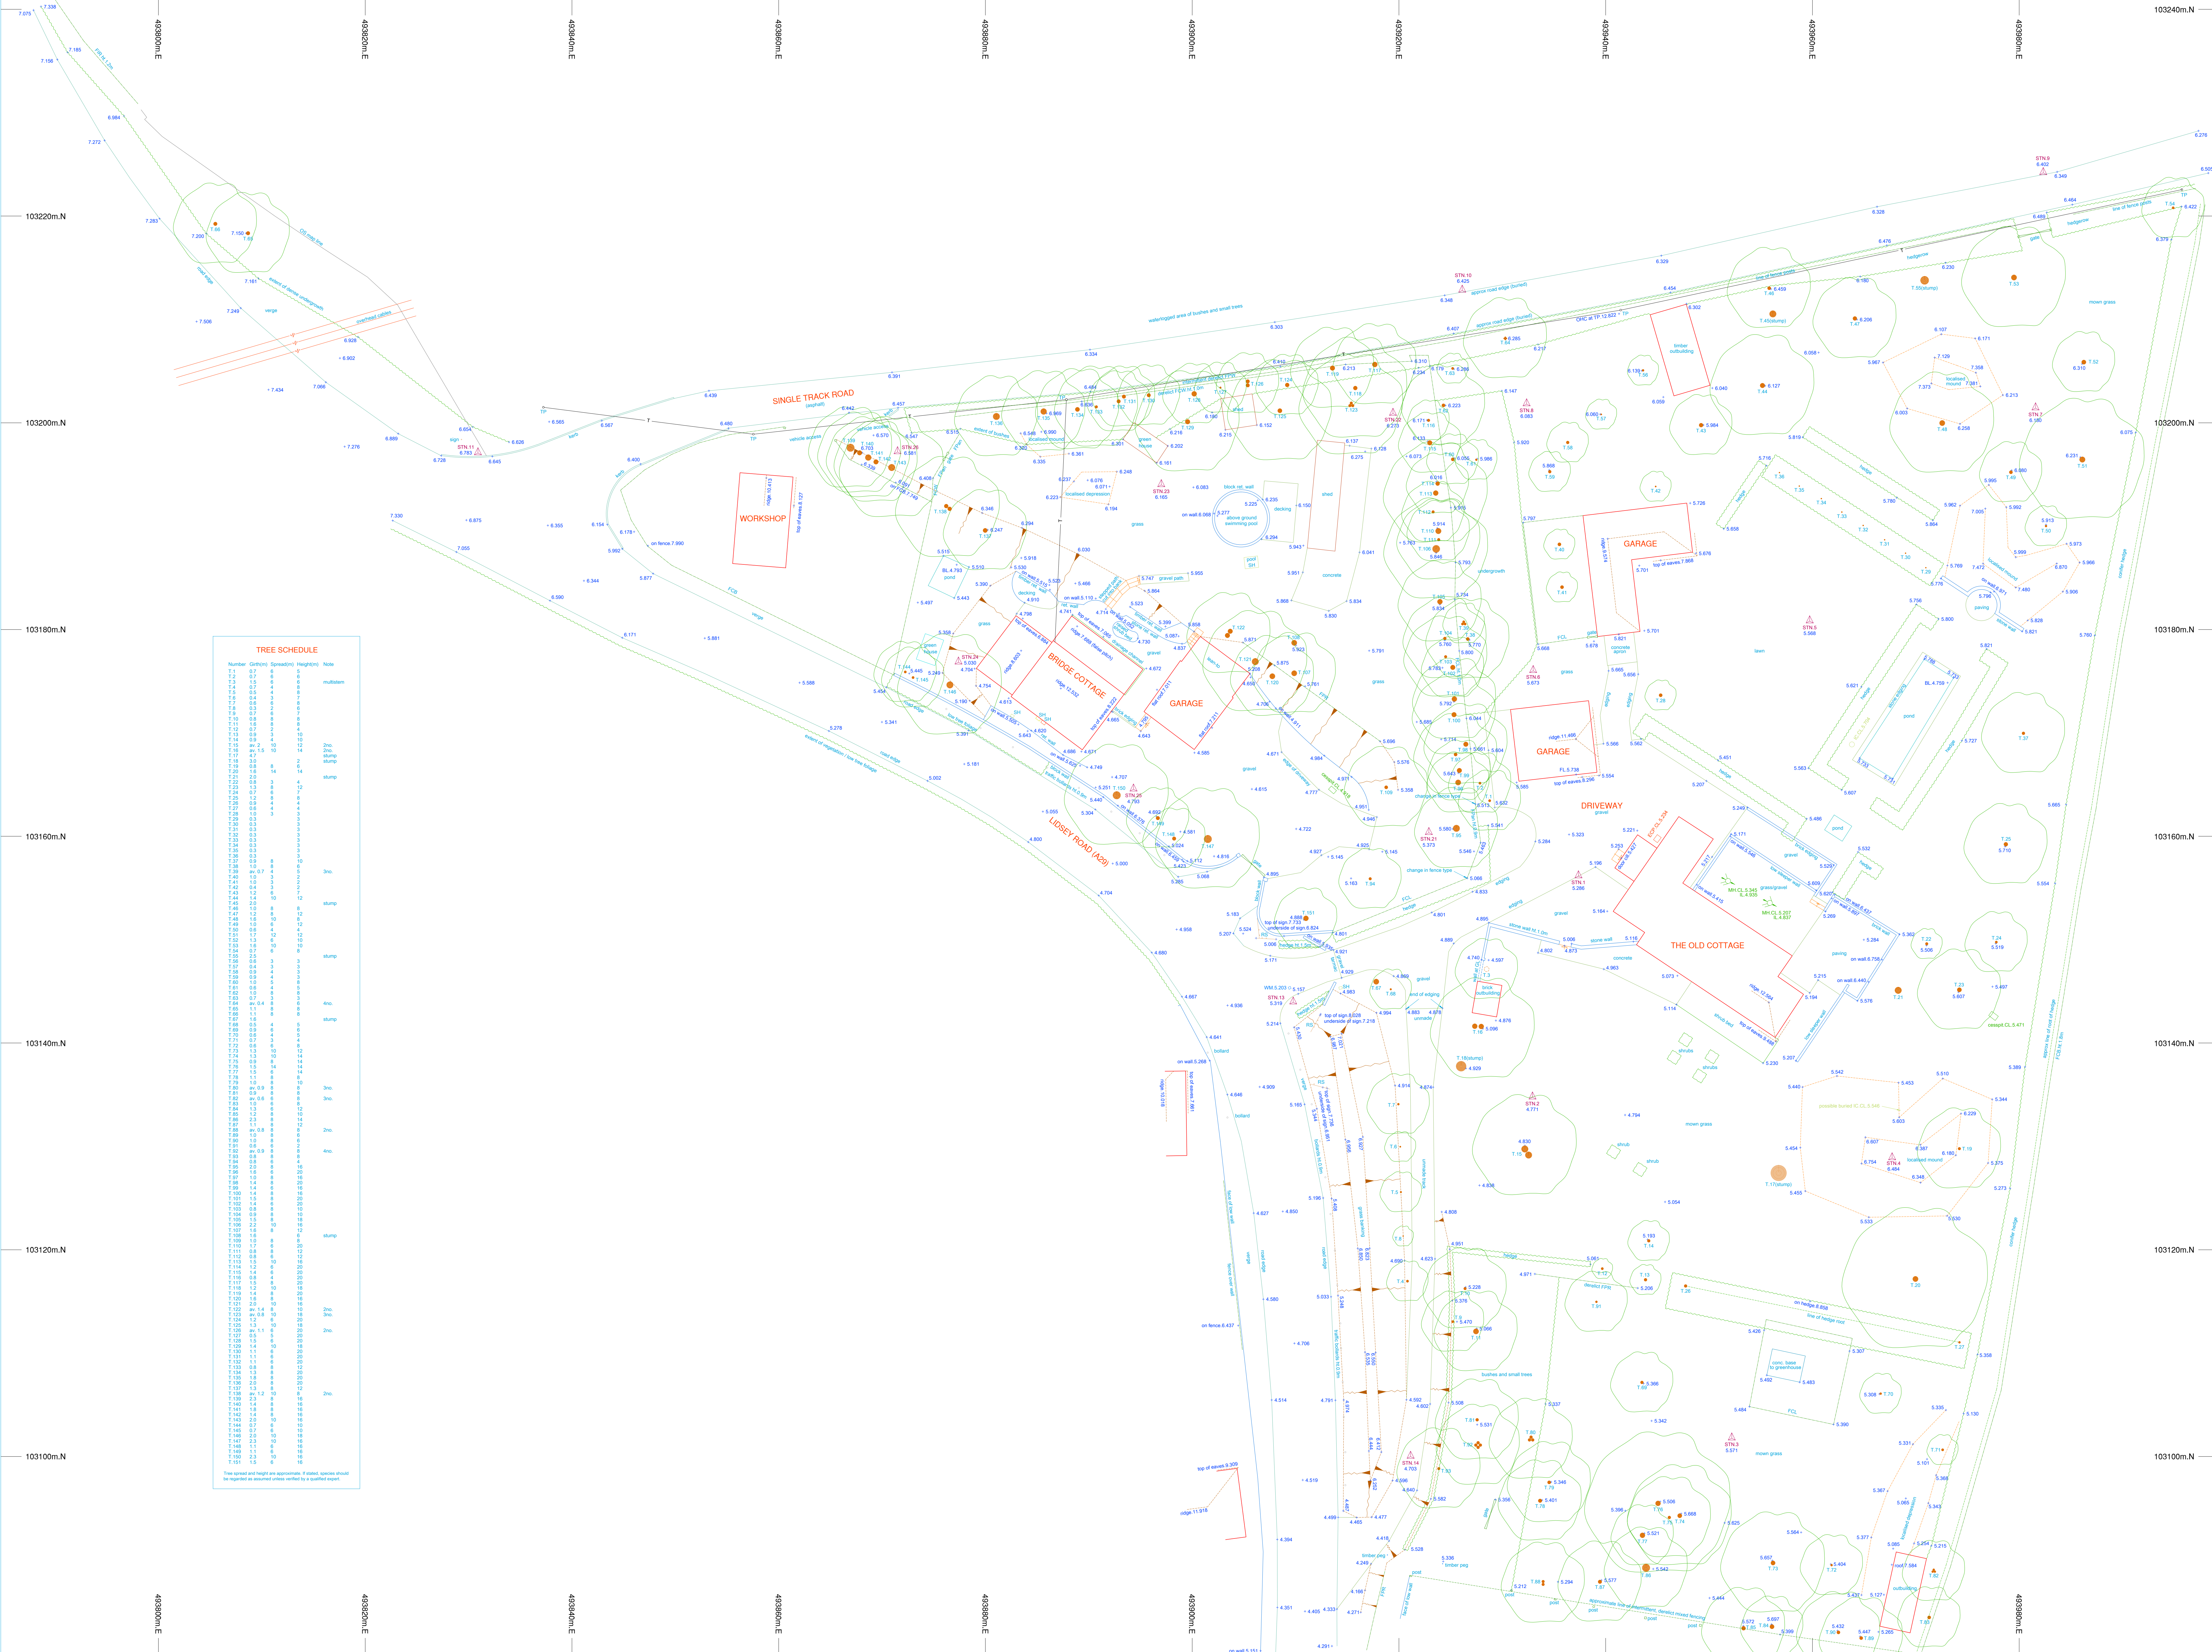

Chartered Surveyors
Copyright © 2017

Offington Land Surveys Ltd
29 Offington Drive
Worthing
West Sussex, BN14 9PW

Telfax 01903 267883
surveyors@offington.com

THE OLD COTTAGE & BRIDGE COTTAGE
LIDSEY ROAD
BOGNOR REGIS
PO22 9PQ

Drawing No. 15731117 Site Plan

Version 2.0

Client Design Directive

Plot Scale: 1:200

Sheet Size: A3 Landscape

Survey Dates: 19/10/2017, 11/11/2017 (Original Survey)
04/10/2018, 08/10/2018 (Bridge Cottage)

Survey: JLV

Drawn by: JLV

Checked by: ST

STANDARD REFERENCE

Datum Used: Newlyn

Survey referenced to ODN & GOSGR(16) by non-located best fit to GOSGR RTK of controls (GOSGR accuracy ~ 50mm rms).

Survey Station Shown Thus:

- Field Water Drainage
- Storm Water Drainage
- Water Main
- Gas Mains
- Electricity Cable
- British Telecom Cable

True north direction shown is indicative only.

The details shown herein relating to all underground services are as obtained by normal geophysical surveys and other data and methods and are intended only for reference to available utility records. Although all reasonable efforts have been made no guarantee can be given for the completeness or accuracy of this information.

ABBREVIATIONS

BL	Best Level	IC	Inspection Chamber
BT	British Telecom IC	L	Level
CATV	Cable Television Cable	LP	Lamp Post
CB	Concrete Block	M	Manhole
CE	Chimney Eye	CMC	Overhead Cable
CL	Contour Level	ODS	Outstanding Survey
CM	Cable Marker	RD	Road
CP	Cable Pipe	RS	Road Sign
CR	Cable	RWP	Road Water Pipe
ECP	Electricity Cable	SC	Stop Clock
EP	Electricity Pole	SP	Service Manhole
ER	Earth Road	SV	Stop Valve
FL	First Floor	SWP	Sub & Vent Pipe
FP	Footpath	W	Wall
GL	Ground Level	WM	Water Meter
		WV	Water Vent Out

STATION SCHEDULE

Station	Easting(m)	Northing(m)	Level(m)
1	493910.889	103184.751	5.086
2	493910.892	103184.751	4.771
3	493910.197	103185.755	5.071
4	493907.712	103186.872	6.484
5	493905.282	103186.885	5.068
6	493905.282	103186.885	5.068
7	493905.282	103186.885	5.068
8	493905.282	103186.885	5.068
9	493905.282	103186.885	5.068
10	493905.282	103186.885	5.068
11	493905.282	103186.885	5.068
12	493905.282	103186.885	5.068
13	493905.282	103186.885	5.068
14	493905.282	103186.885	5.068
15	493905.282	103186.885	5.068
16	493905.282	103186.885	5.068
17	493905.282	103186.885	5.068
18	493905.282	103186.885	5.068
19	493905.282	103186.885	5.068
20	493905.282	103186.885	5.068
21	493905.282	103186.885	5.068
22	493905.282	103186.885	5.068
23	493905.282	103186.885	5.068
24	493905.282	103186.885	5.068
25	493905.282	103186.885	5.068

VERSION HISTORY

Version	Date	Description
1.0	28/10/2017	Original Version
2.0	08/10/2018	Bridge Cottage added

NOTES



0m 10m

