




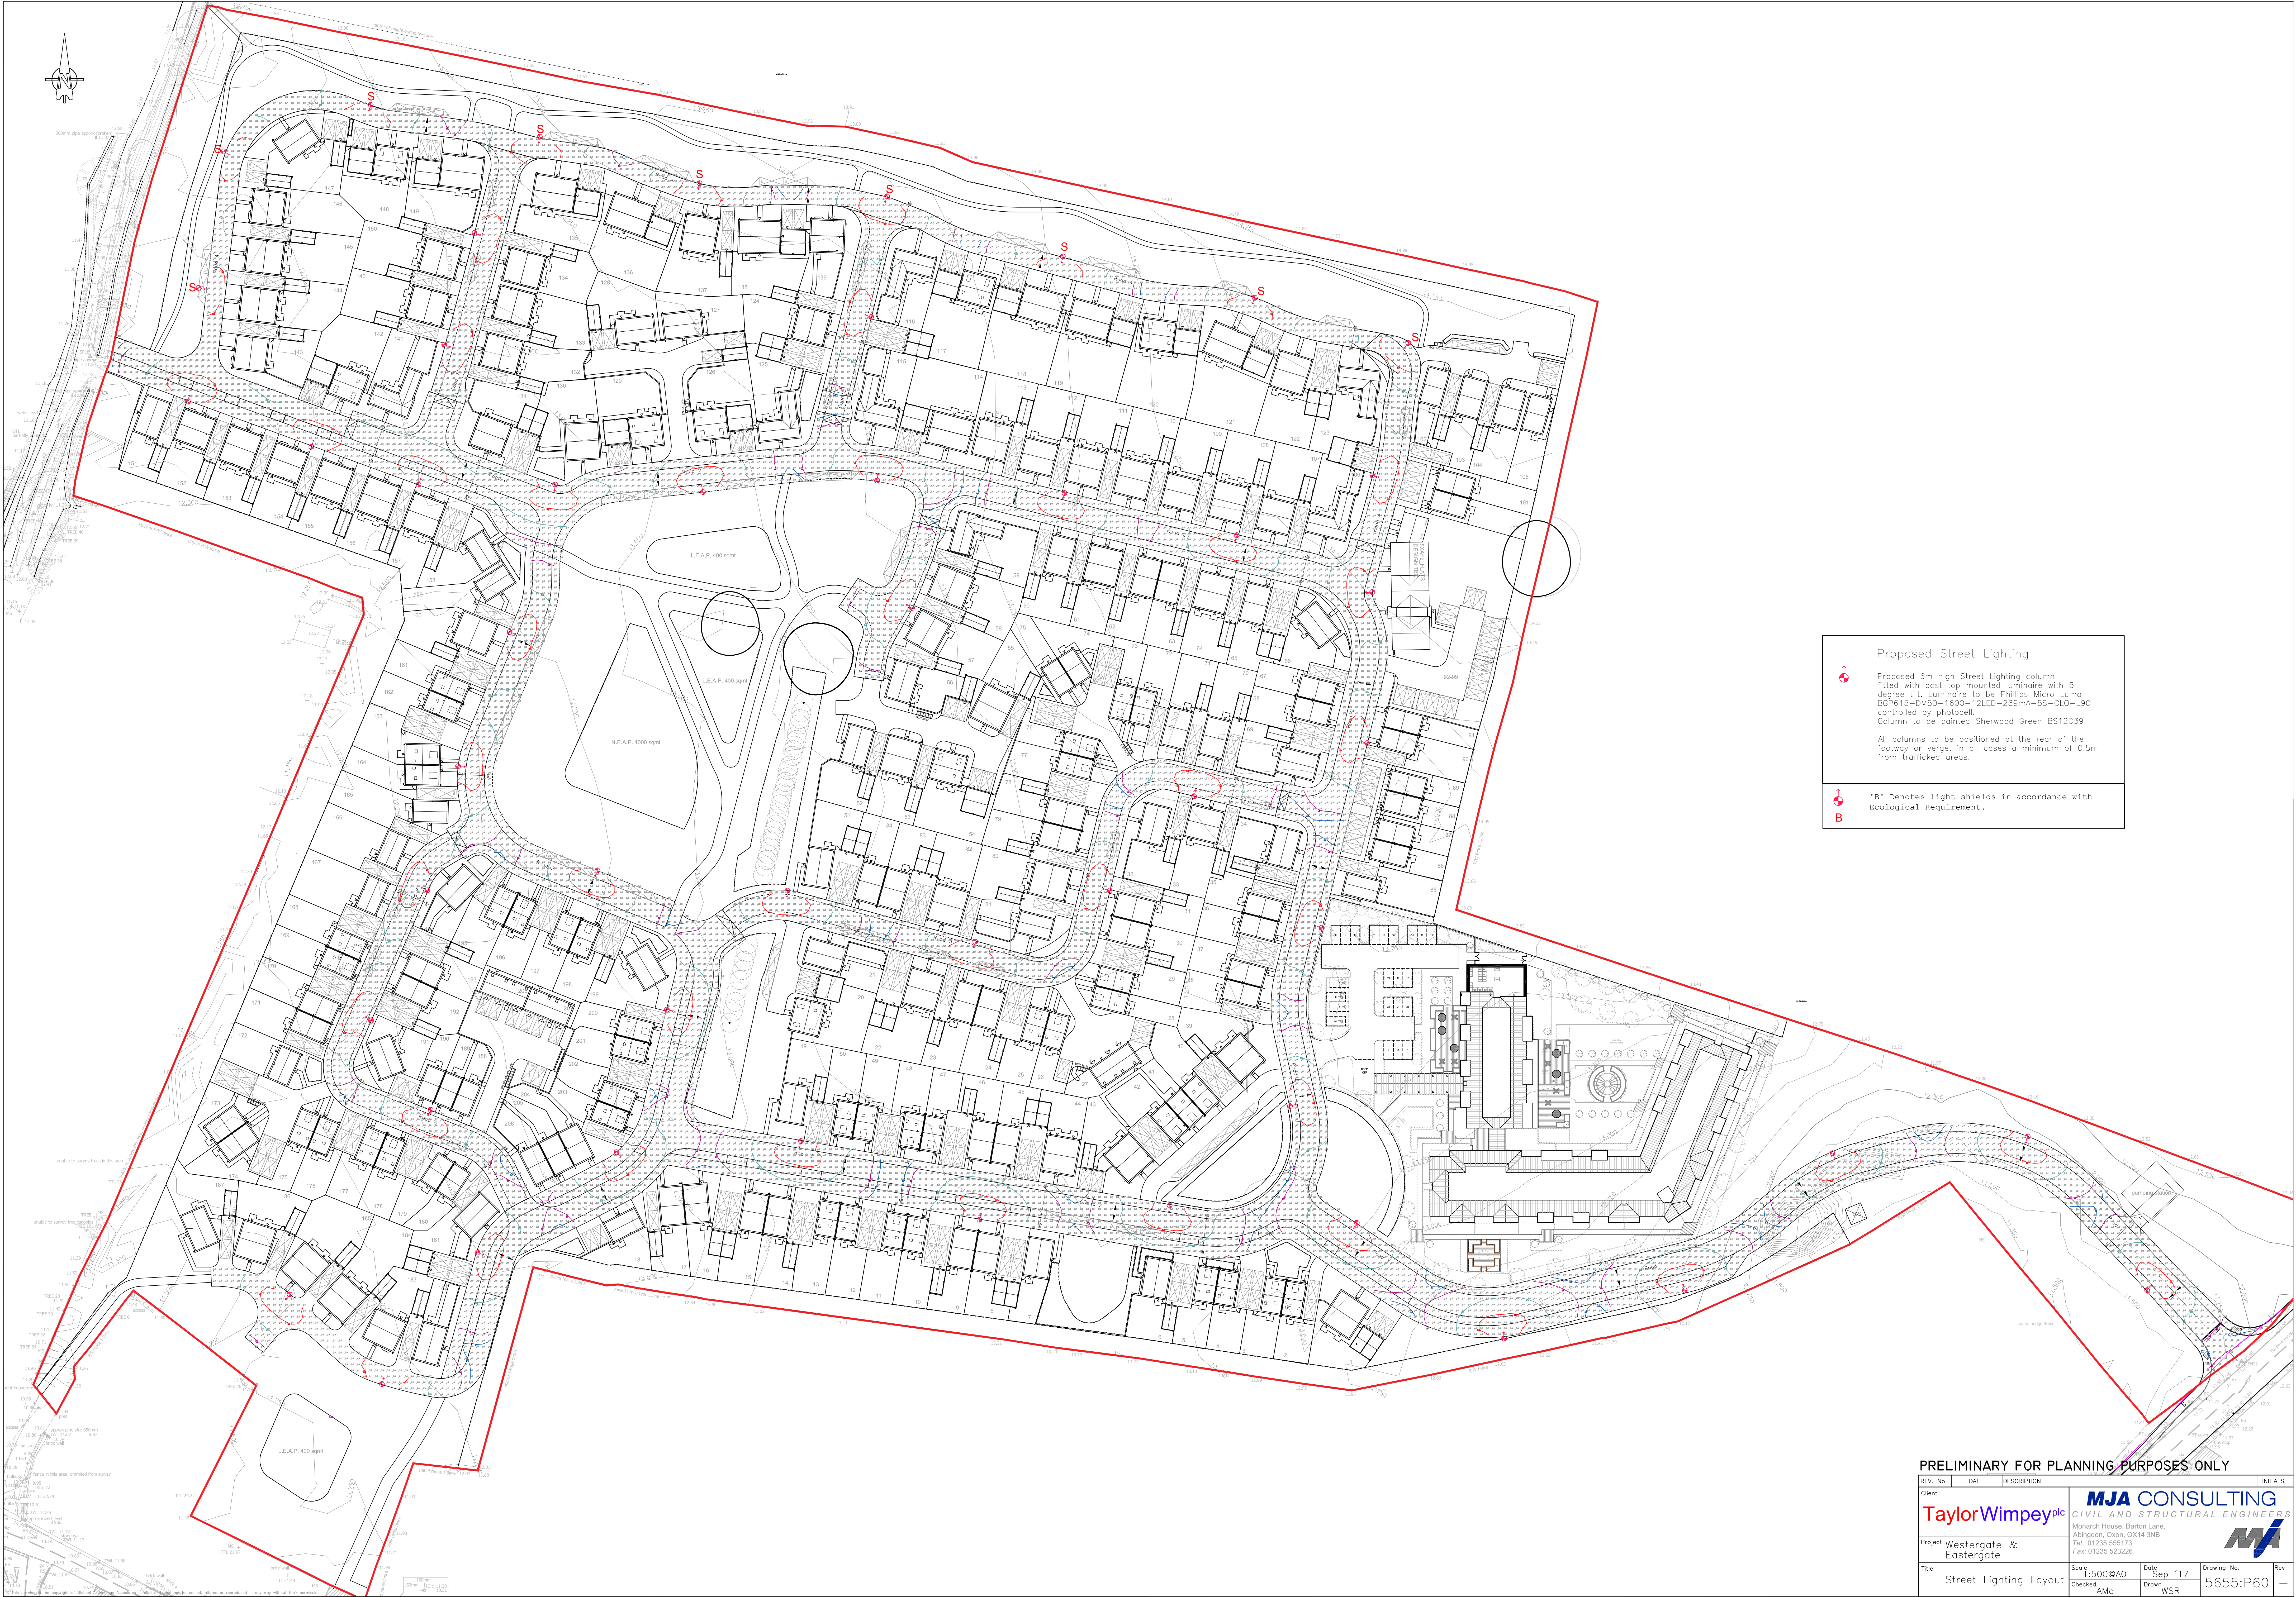

Proposed Street Lighting

Proposed 6m high Street Lighting column fitted with post top mounted luminaire with 5 degree tilt. Luminaire to be Phillips Micro Luma BGP615-DW50-1600-12LED-239mA-5S-CLO-L90 controlled by photocell.
Column to be painted Sherwood Green BS12C39.

All columns to be positioned at the rear of the footway or verge, in all cases a minimum of 0.5m from trafficked areas.



'B' Denotes light shields in accordance with Ecological Requirement.

PRELIMINARY FOR PLANNING PURPOSES ONLY						
REV. No.	DATE	DESCRIPTION	INITIALS			
Client			Taylor Wimpey plc MJA CONSULTING CIVIL AND STRUCTURAL ENGINEERS Monarch House, Barton Lane, Aldington, Oxen, OX11 3NB Tel: 01235 555173 Fax: 01235 502256			
Project			Westergate & Eastergate 			
Title	Street Lighting Layout		Scale 1:500@A0 Checked AMC	Date Sep '17 Drawn WSR	Drawing No 5655:P60	Rev -