


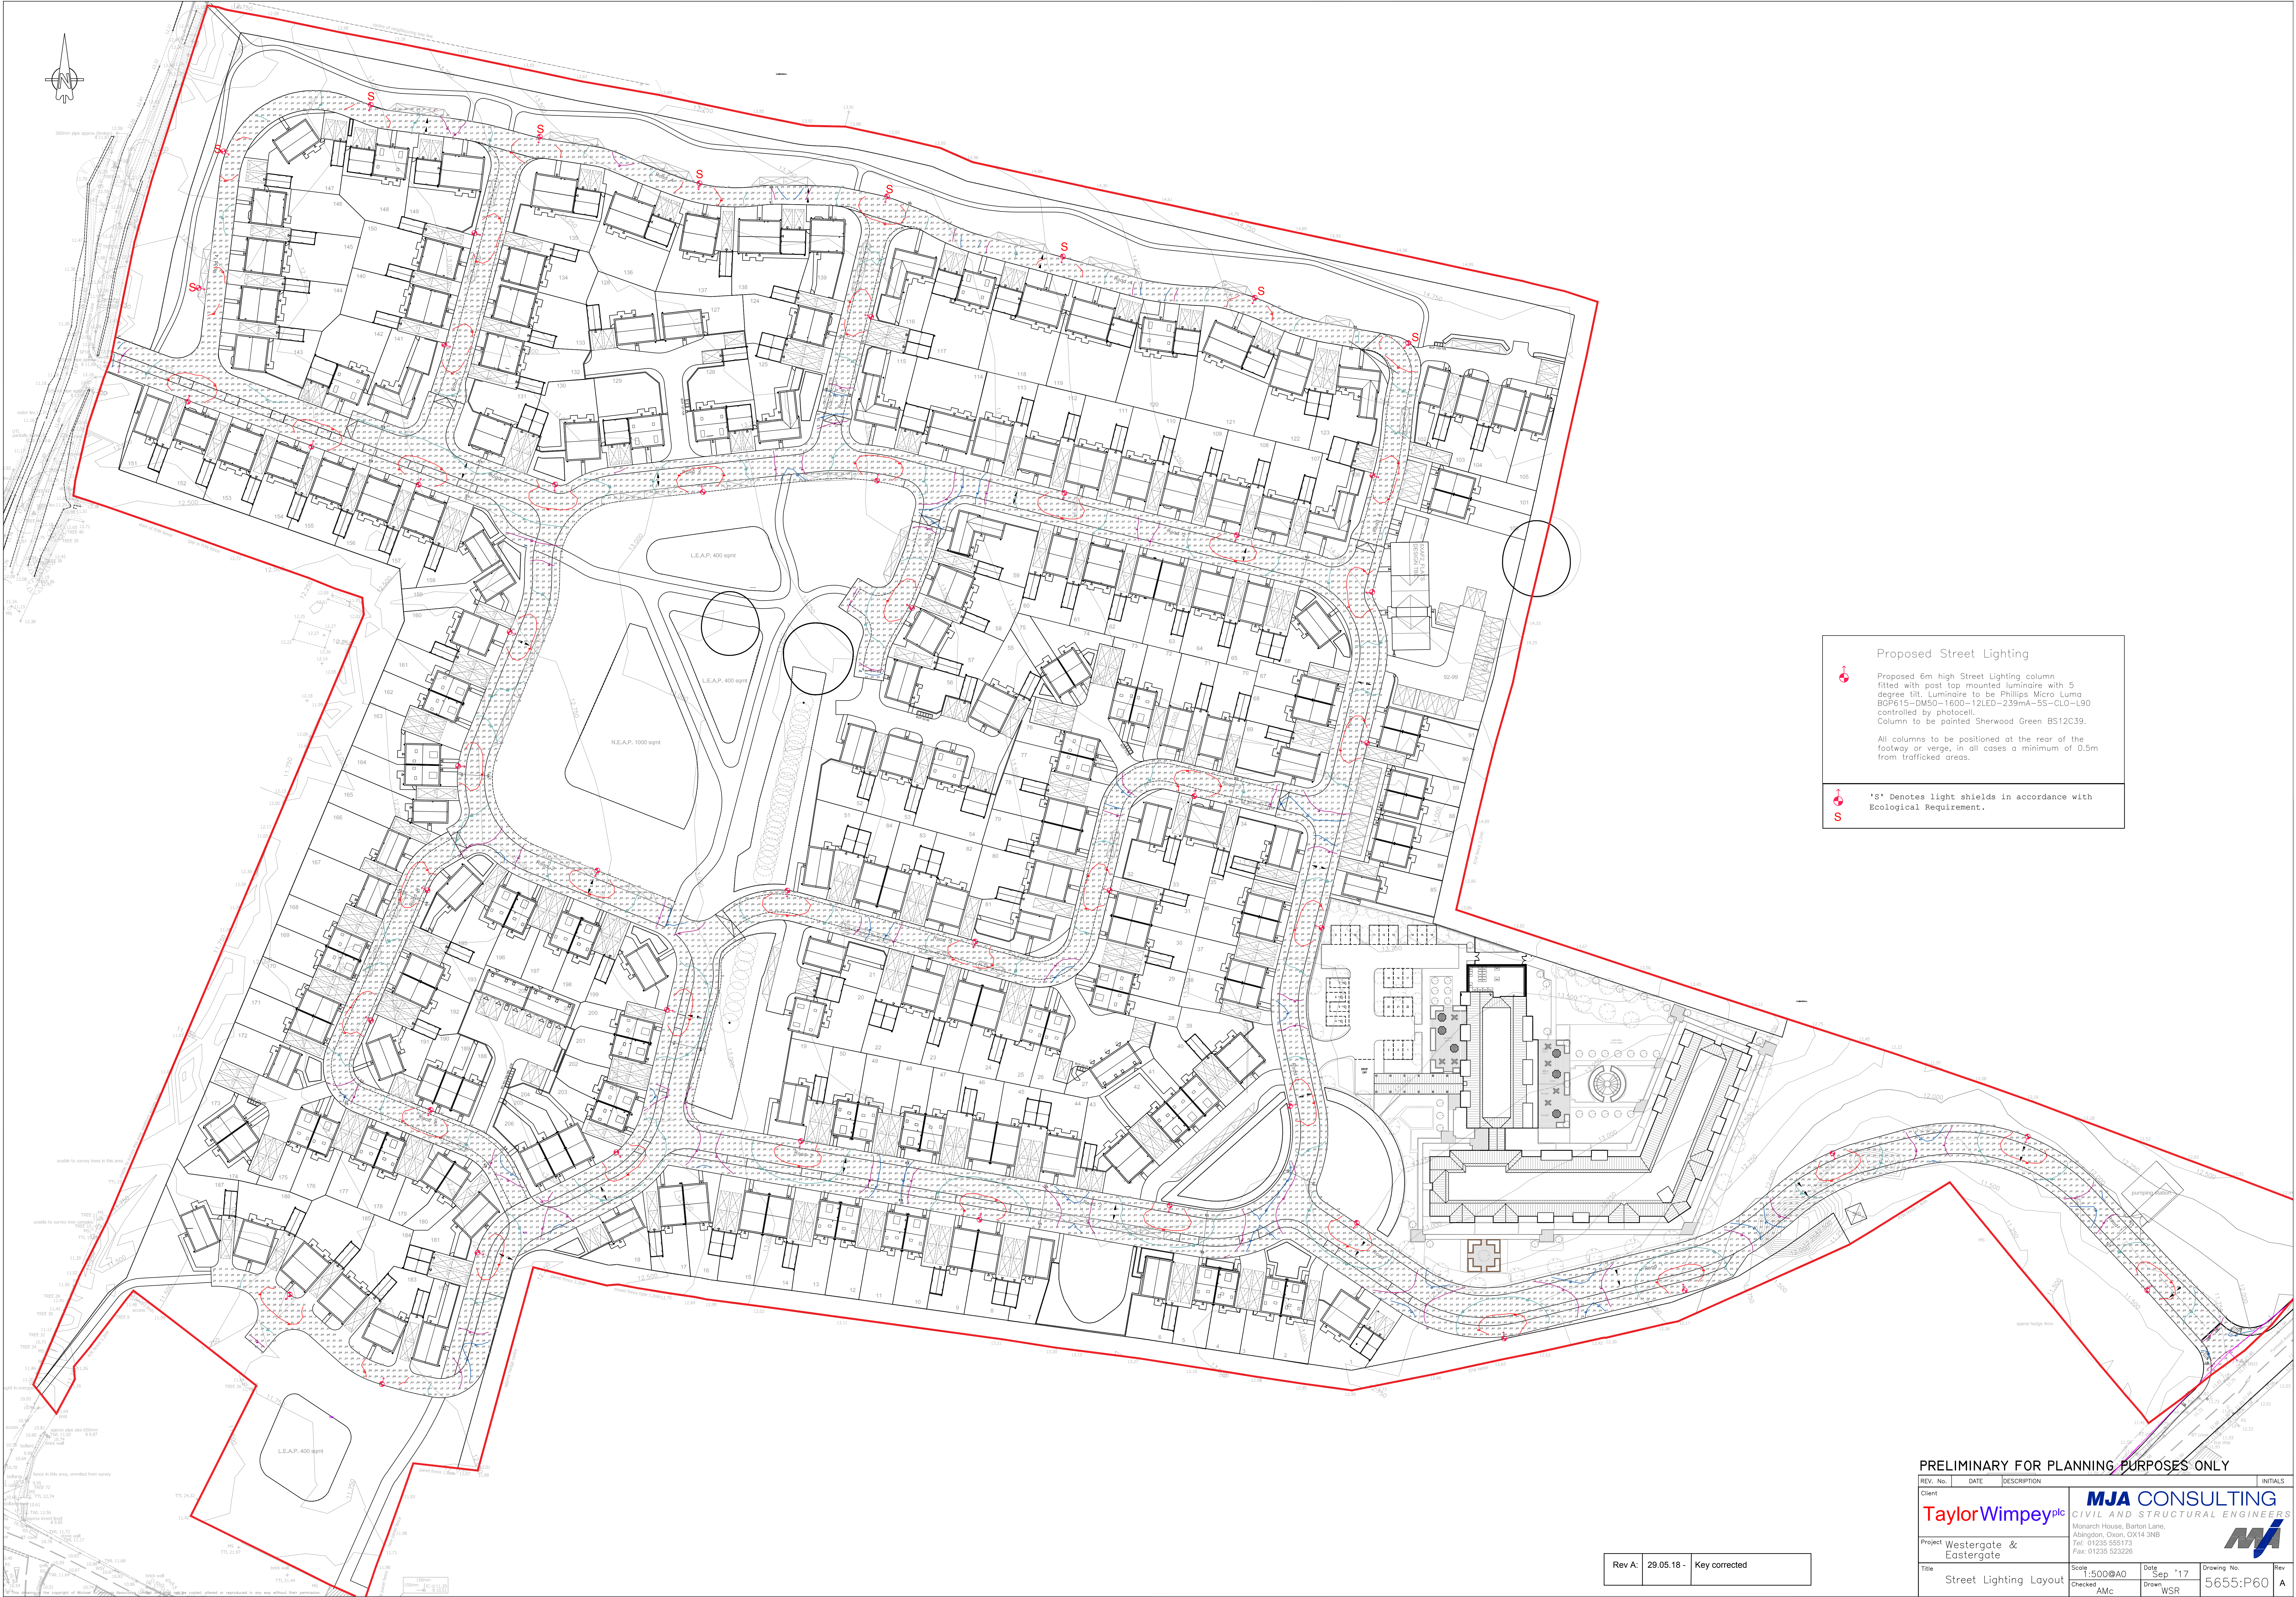

Proposed Street Lighting

Proposed 6m high Street Lighting column fitted with post top mounted luminaire with 5 degree tilt. Luminaire to be Phillips Micro Luma BGP615-DW50-1600-12LED-239mA-5S-CLO-L90 controlled by photocell. Column to be painted Sherwood Green BS12C39.

All columns to be positioned at the rear of the footway or verge, in all cases a minimum of 0.5m from trafficked areas.

'S' Denotes light shields in accordance with Ecological Requirement.

Rev A: 29.05.18 - Key corrected

PRELIMINARY FOR PLANNING PURPOSES ONLY				
REV. No.	DATE	DESCRIPTION	INITIALS	
Client			MJA CONSULTING CIVIL AND STRUCTURAL ENGINEERS Monarch House, Barton Lane, Abingdon, Oxon, OX14 3NB Tel: 01235 555173 Fax: 01235 523226 	
Project			Westergate & Eastergate	
Title			Scale: 1:500@A0 Checked: AMc	Date: Sep '17 Drawn: WSR
Street Lighting Layout			Drawing No. 5655:P60	Rev A