



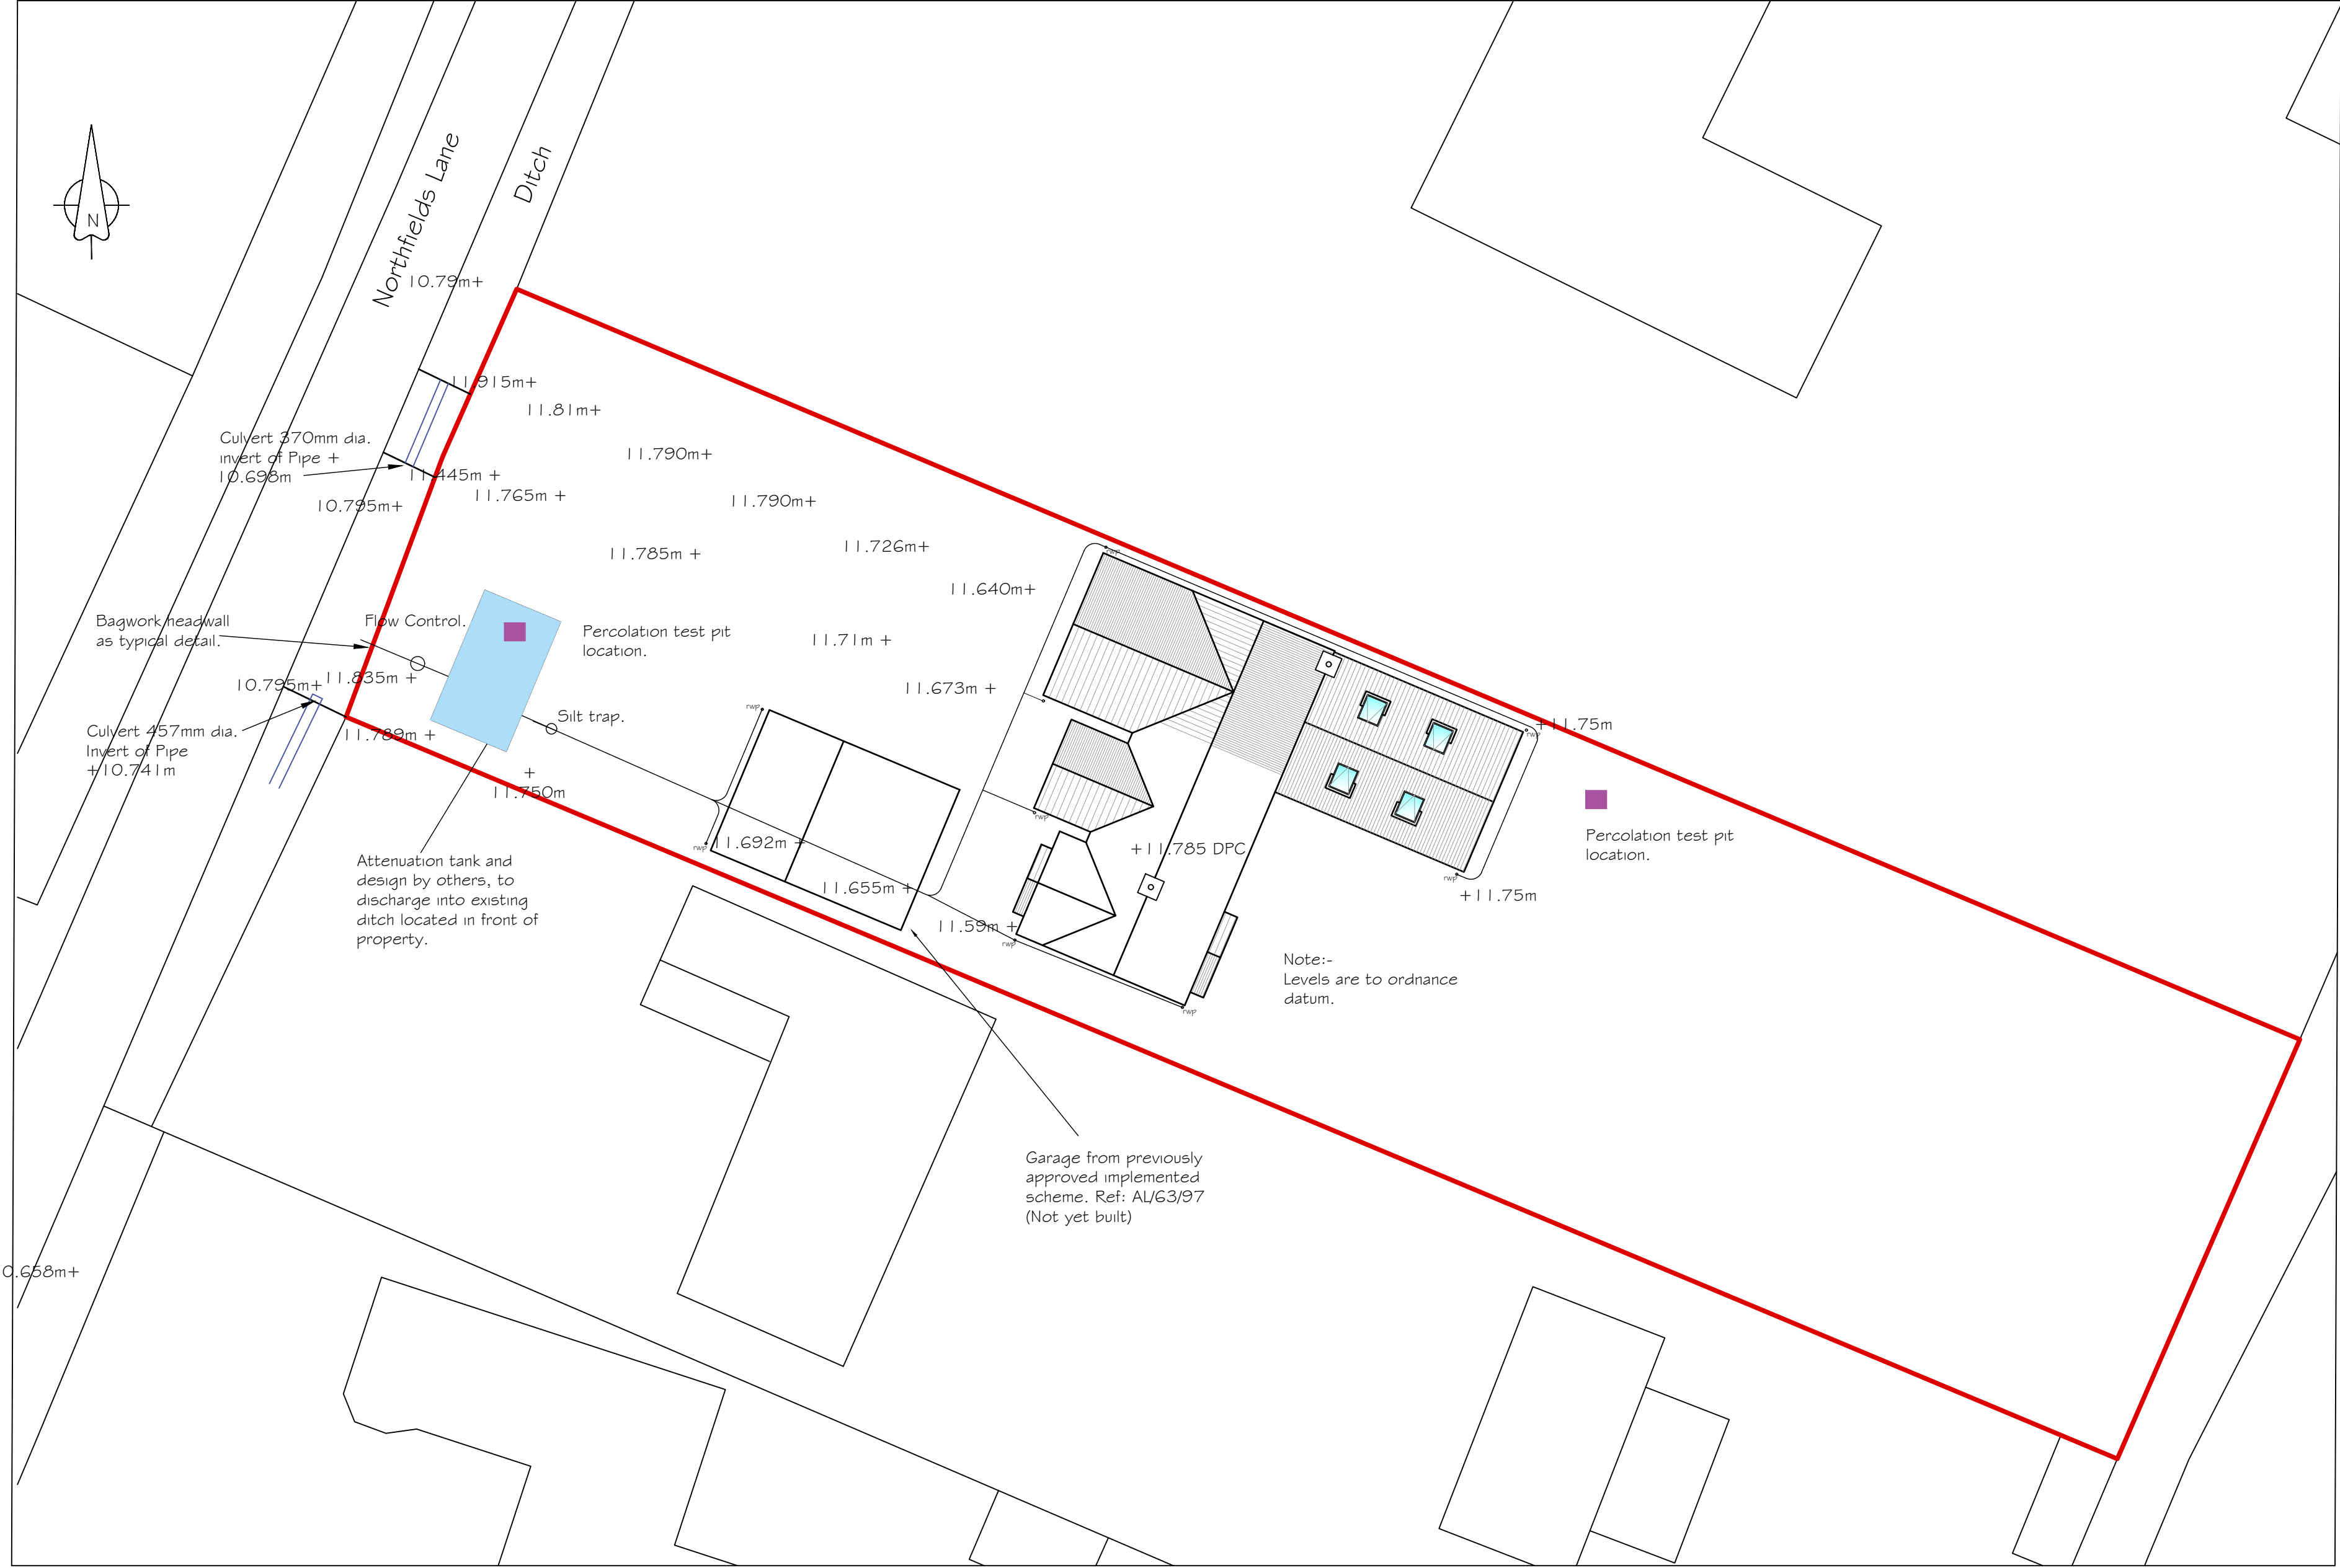

Site Plan with
OS Datum Levels and Tank Position
1:500

See Drainage Layout Drawing for further details

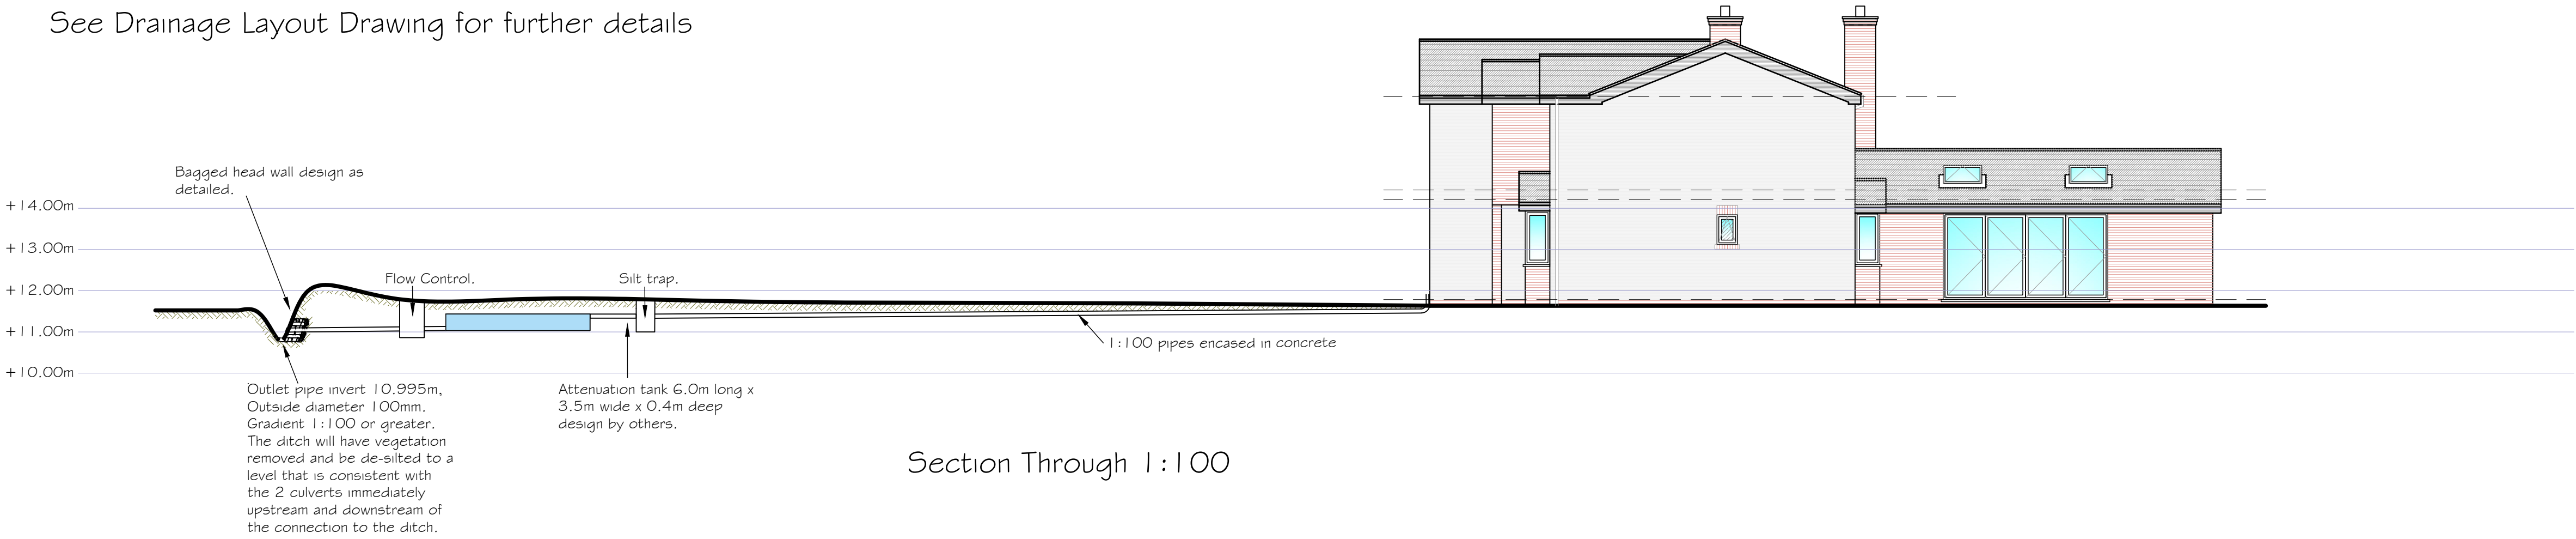

Section Through 1:100


Issued for Planning Conditions Discharge

Drawing Notes:


The copyright of this drawing belongs solely with BPS Design Consultants Ltd, it should not be copied or reproduced without their written consent.

Written dimensions to take precedent over scaling the drawing however all dimensions to be checked and verified on site prior to commencing works. The Contractor shall take all responsibility for setting out. Any discrepancies should be clarified prior to proceeding with work.

All workmanship and materials shall comply with BS 8000 Parts 1-15.

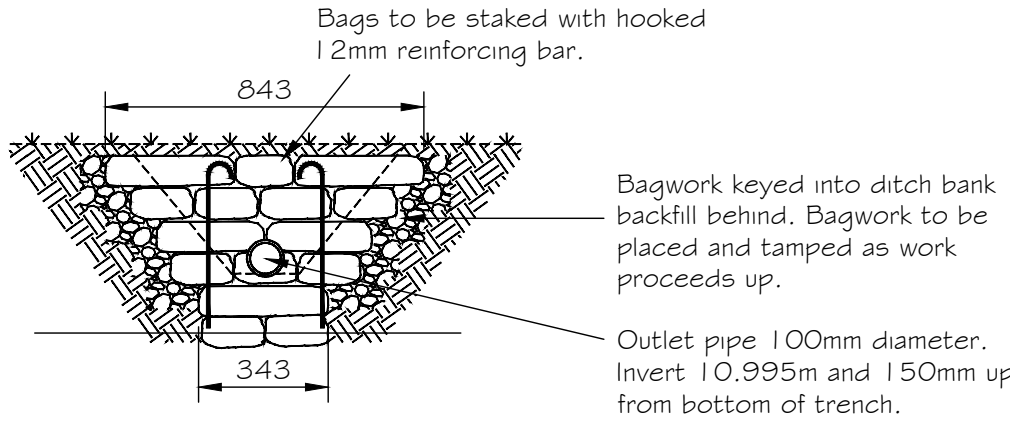

Typical Bagwork Headwall
Elevation 1:20

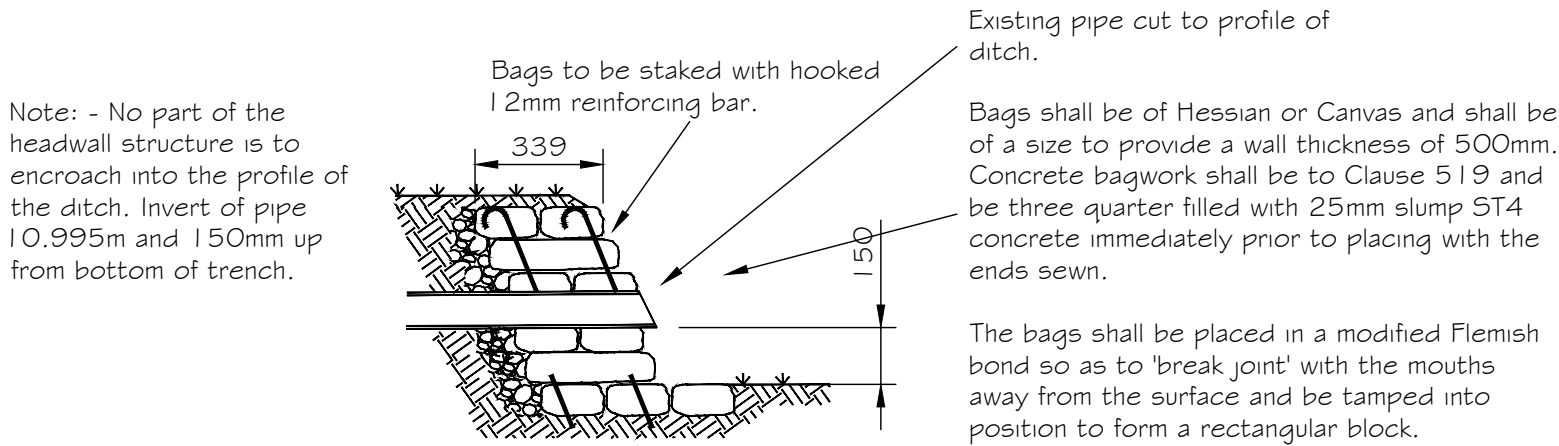

Typical Bagwork Headwall
Section 1:20

BPS Design Consultants Ltd
Architectural Services and Structural Engineers

Seafields, Dodwell lane, Bursledon, Southampton, SO31 1DJ

Tel: 023 8040 4017

robert@bpsdesign.co.uk colin@bpsdesign.co.uk
Mobile: 07915 604 293 Mobile: 07886 655 697

www.bpsdesign.co.uk

Project:	Stanwick Northfields Lane Westergate Chichester PO20 3UH		
Client:	Mr and Mrs Vos		
Dwg Title:	Rainwater Attenuation		
Dwg No:	PL/03	Revision:	D
Date:	May 2021	By:	rjn
		Scale:	As Shown
The Copyright of this drawing belongs solely to BPS Design Consultants Ltd. It should not be copied or reproduced without consent from BPS Design Consultants Ltd. Original drawing at A1 size.			

