


SOUTHERN WATER

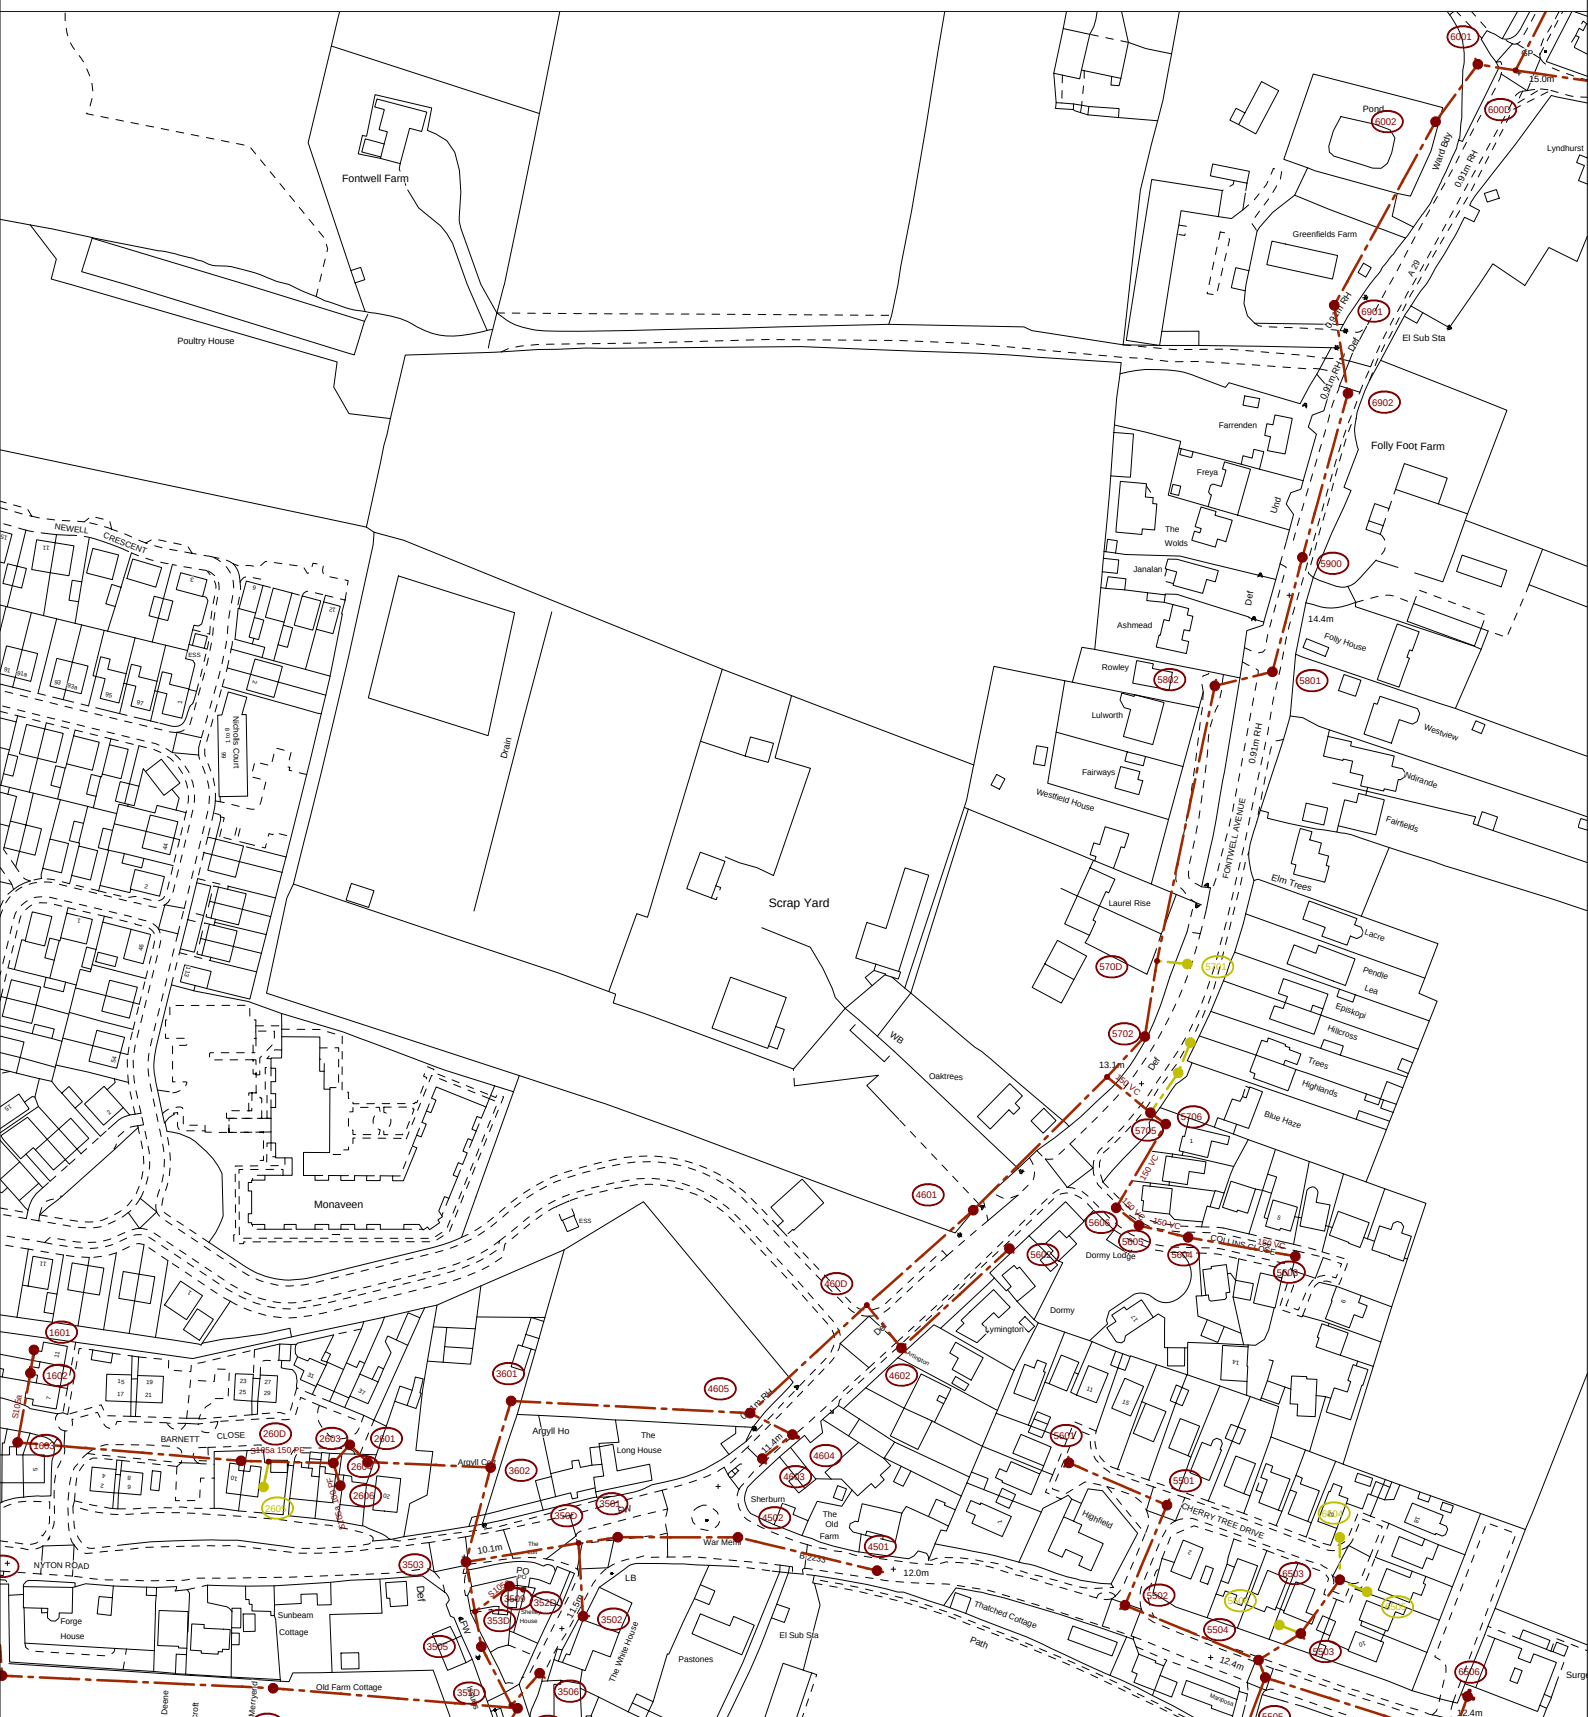

The positions of pipes shown on this plan are believed to be correct, but Southern Water Services Ltd accept no responsibility in the event of inaccuracy. The actual positions should be determined on site.

Based upon Ordnance Survey Digital Data with the permission of the controller of H.M.S.O. Crown Copyright Reserved Licence No. WU 298530

O.S. REF: SU9405NW

Scale: 1:2500

Sewer Plot

WARNING: BAC pipes are constructed of Bonded Asbestos Cement

WARNING: Unknown (UNK) materials may include Bonded Asbestos Cement

ARUN DISTRICT COUNCIL AL/49/22/PL



Printed By: Mercy

Date: 11-1-2022

Site Plan

Requested By: