



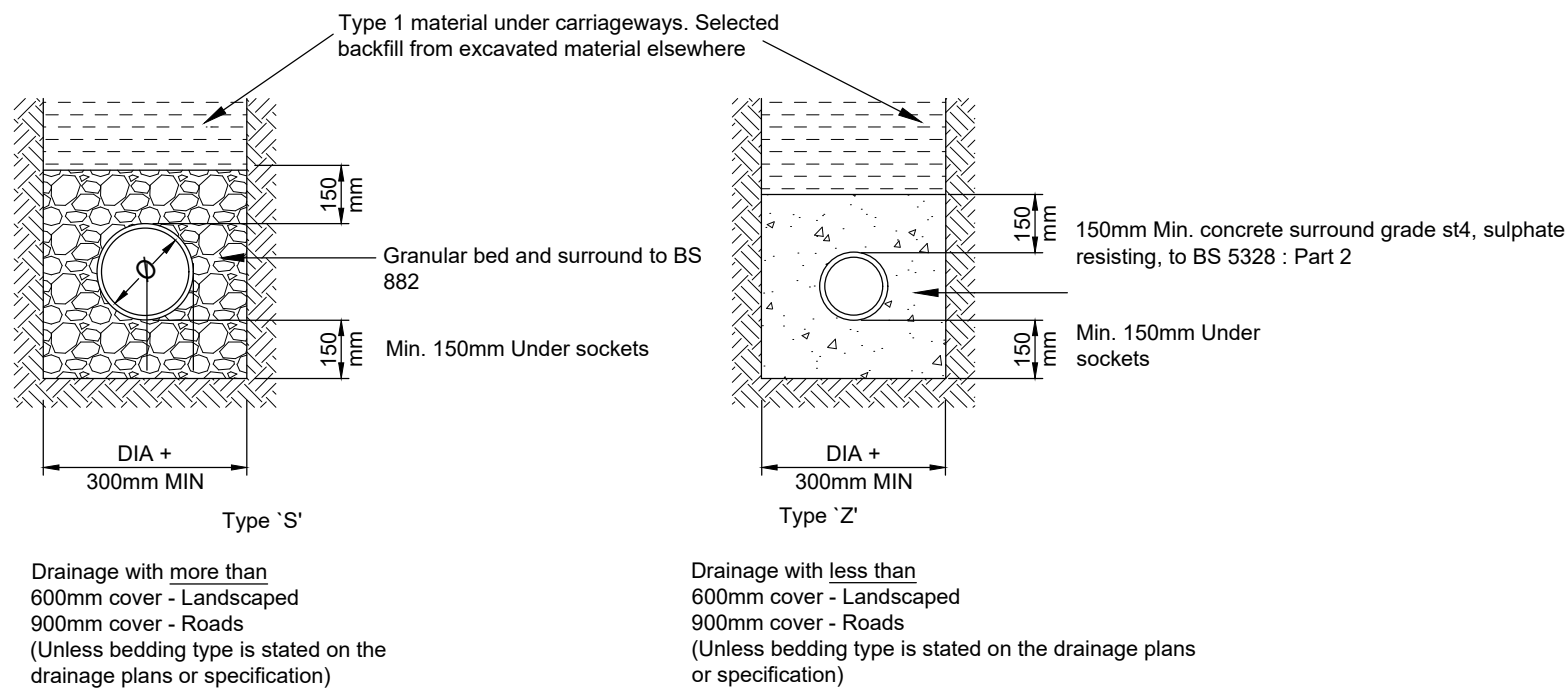


Pipe bedding details in private Areas

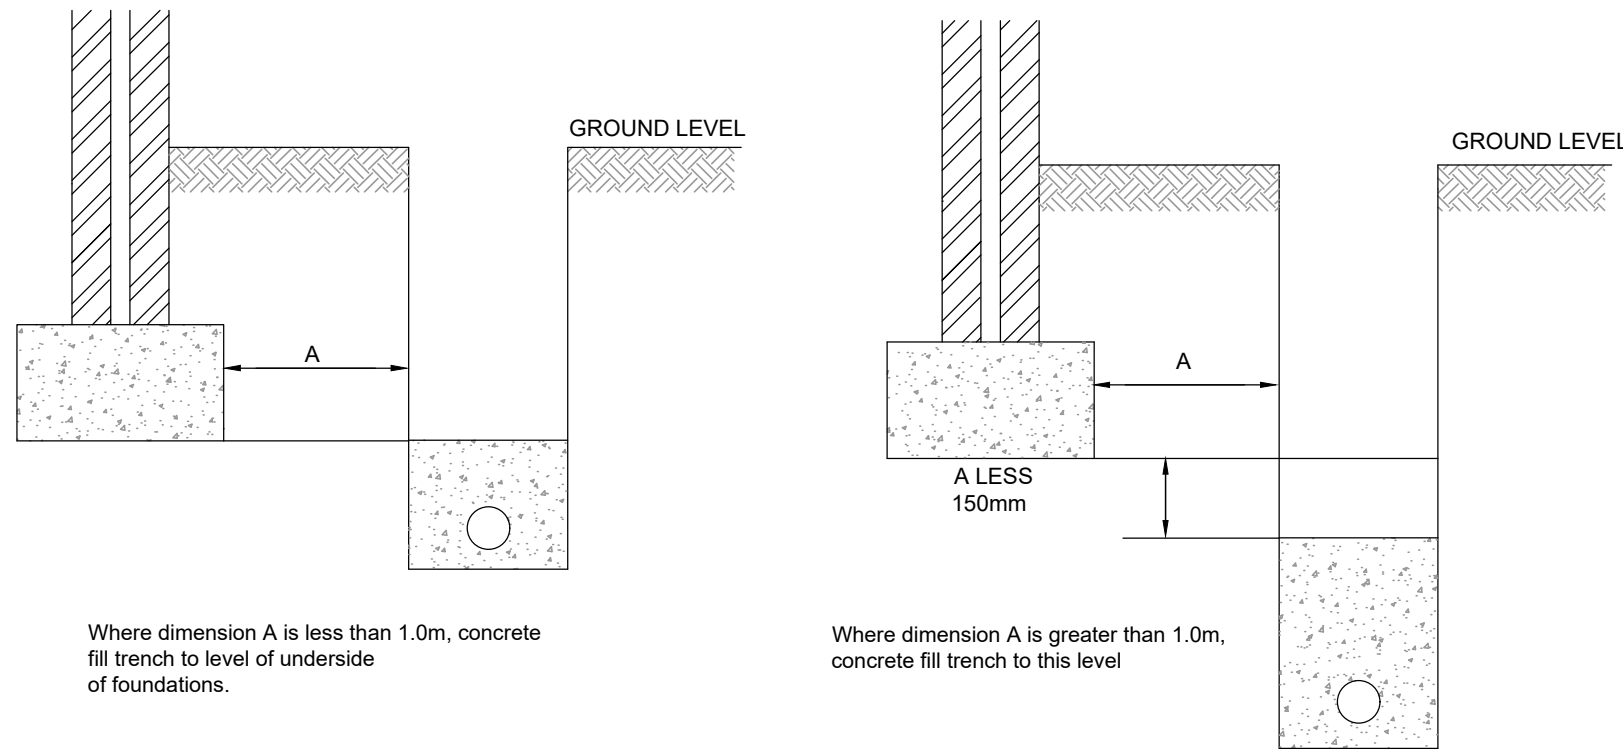


Pipes near buildings


Pipes near buildings

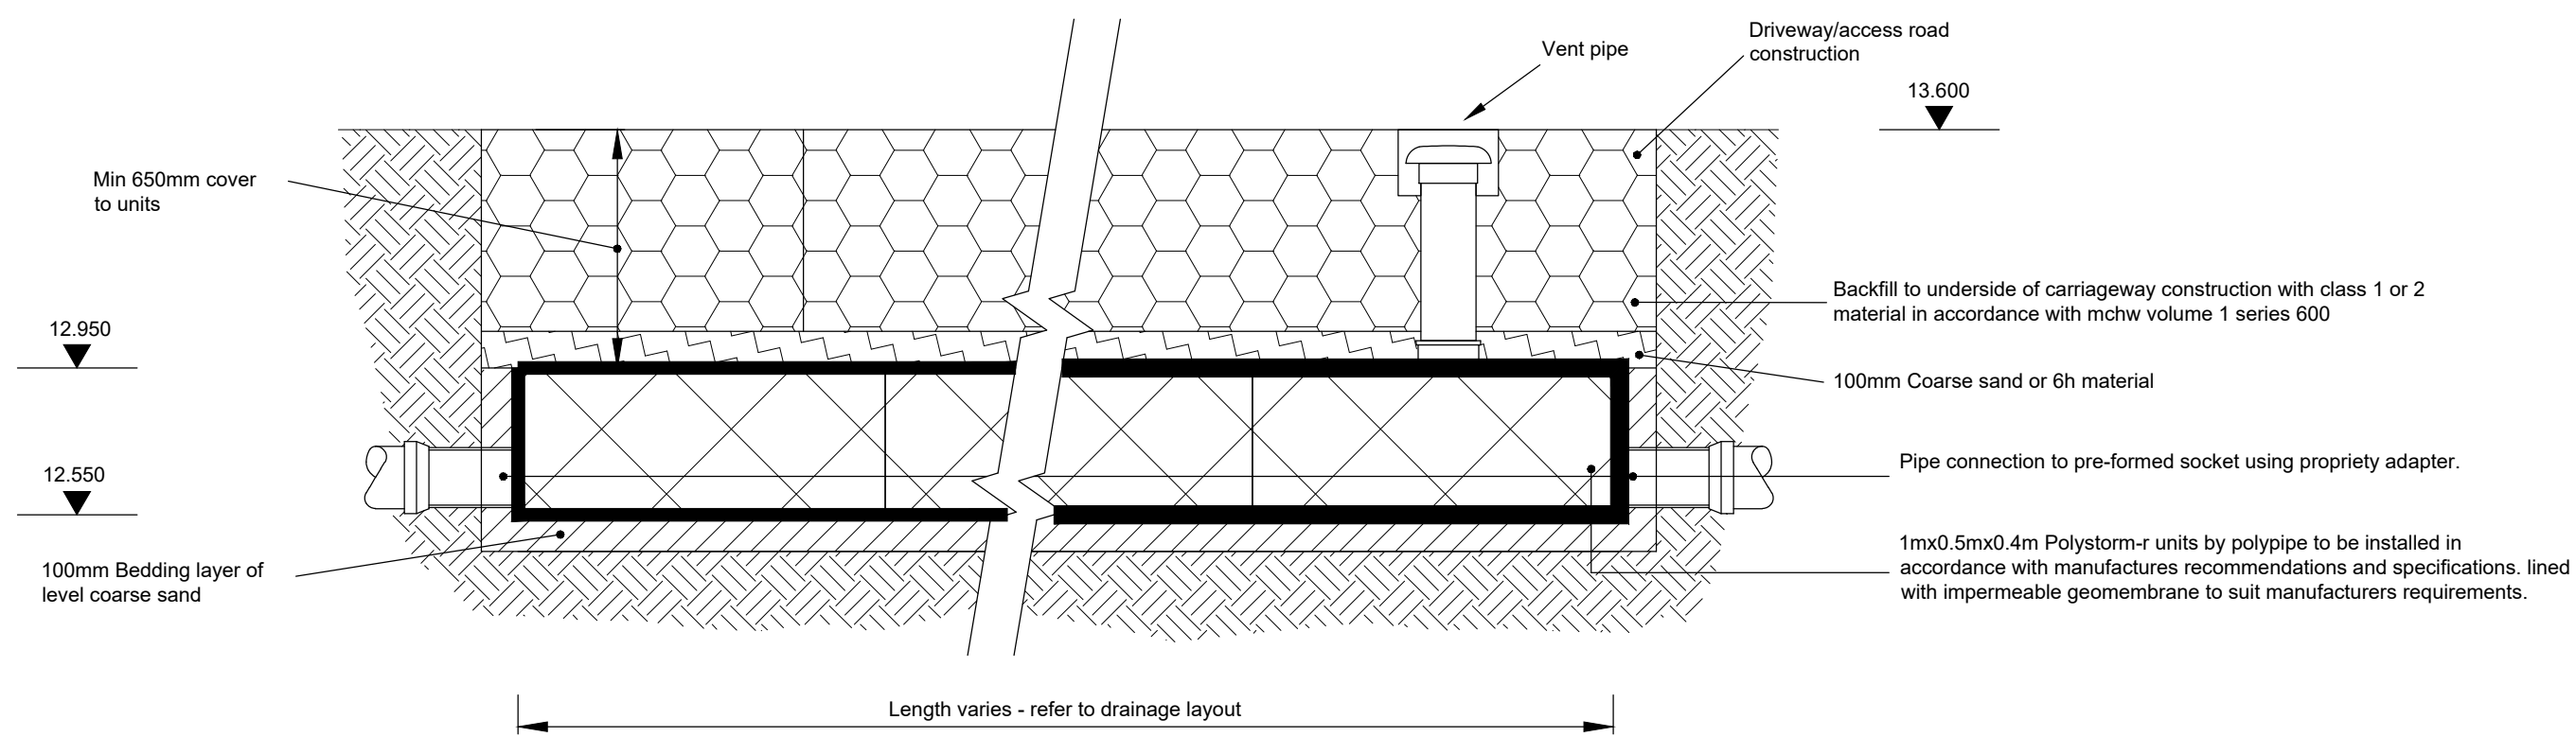

Attenuation tank using polystorm-r geomodular units trafficked areas

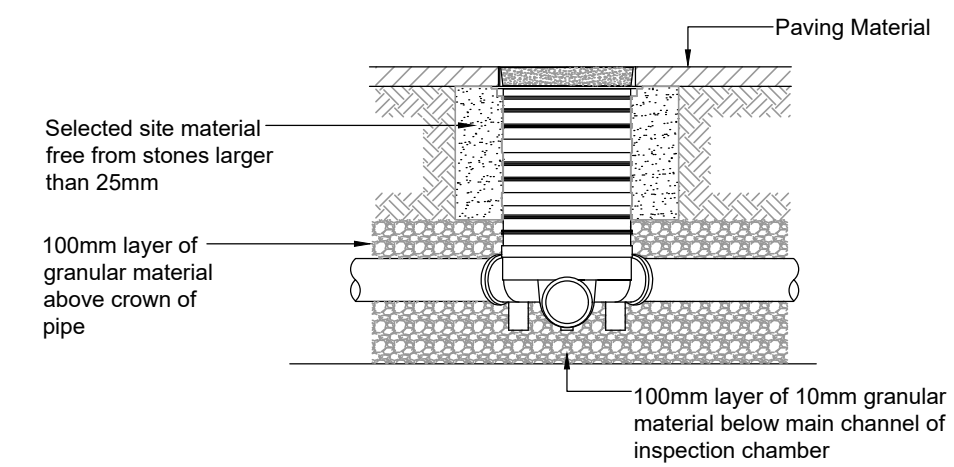


300mmØ SHALLOW INSPECTION CHAMBER DETAIL

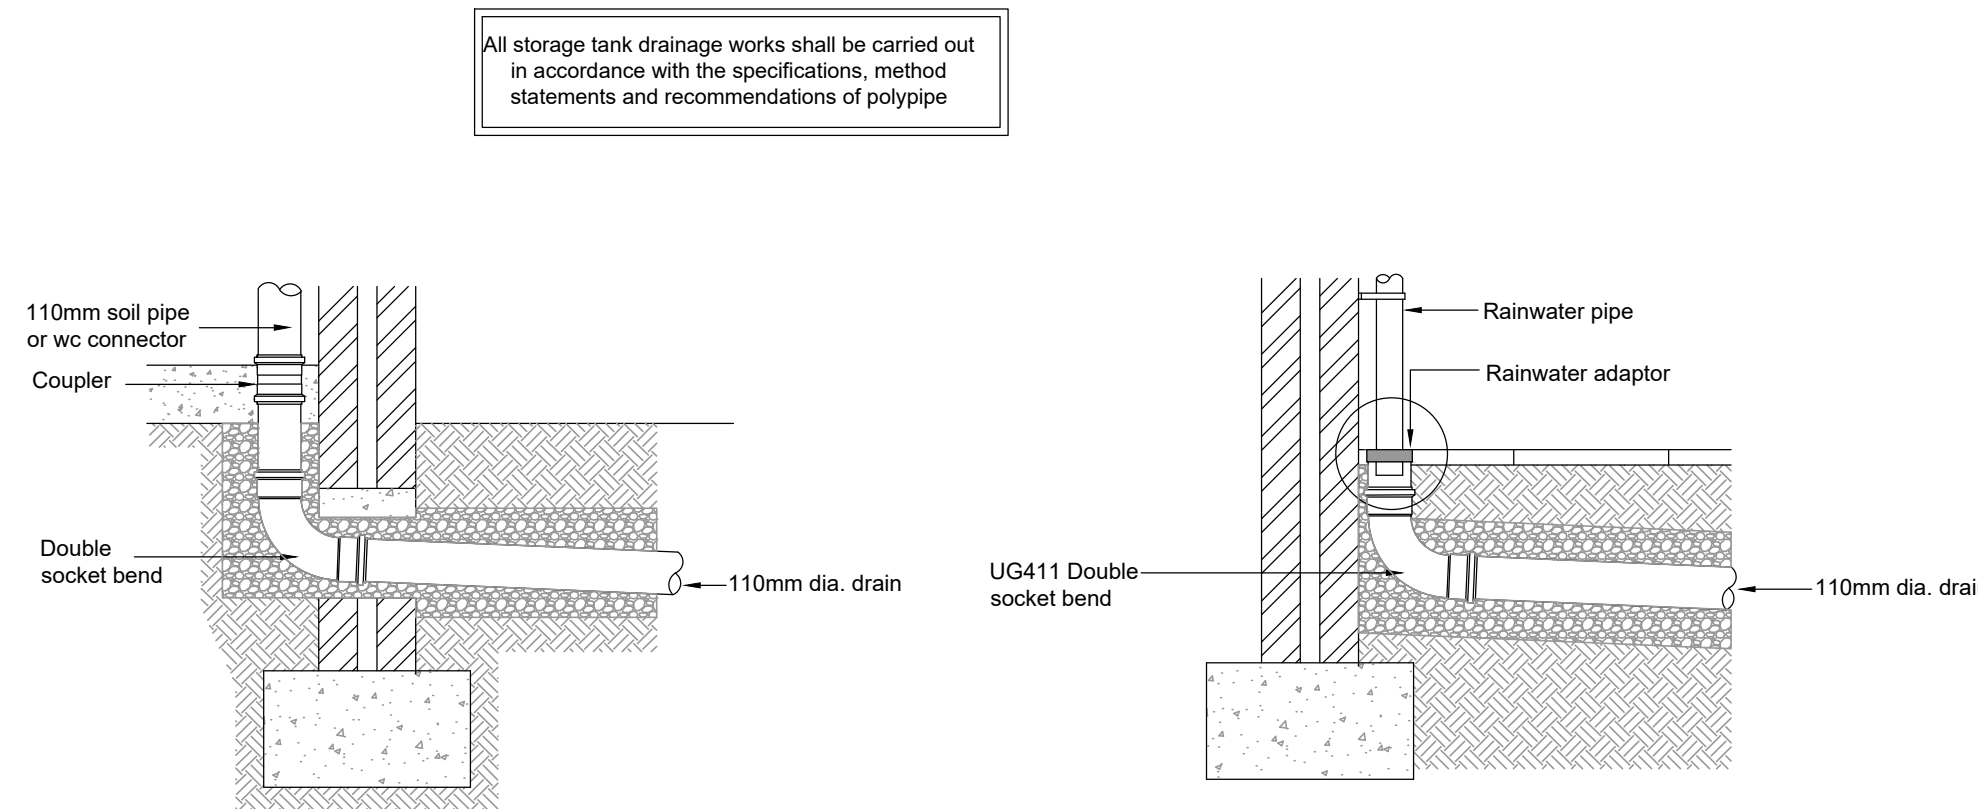


Soil pipe / wc connection


Rainwater pipe connection

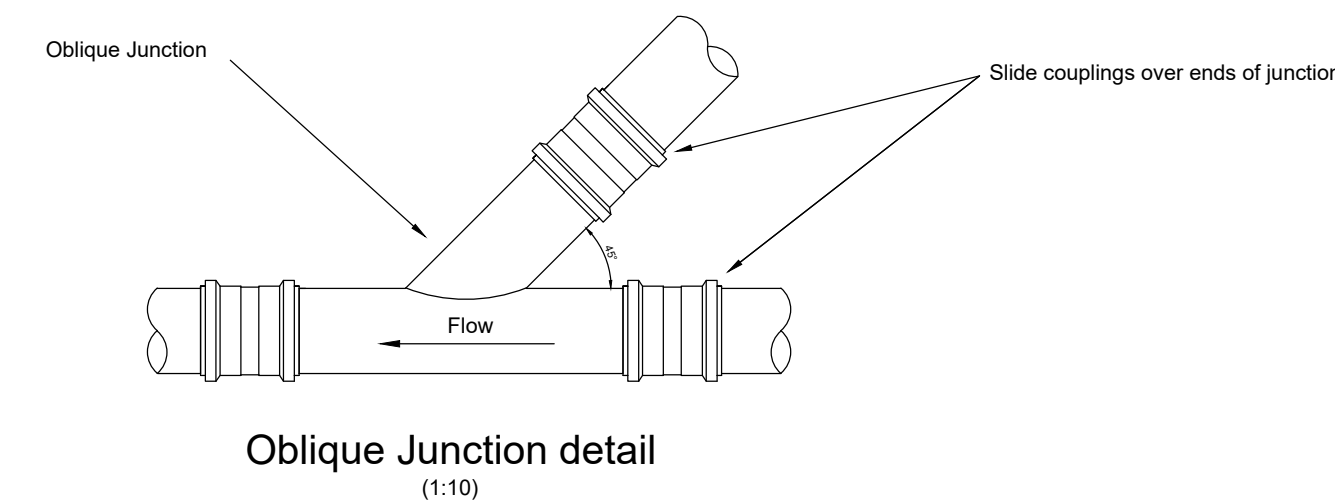


Oblique Junction detail (1:10)

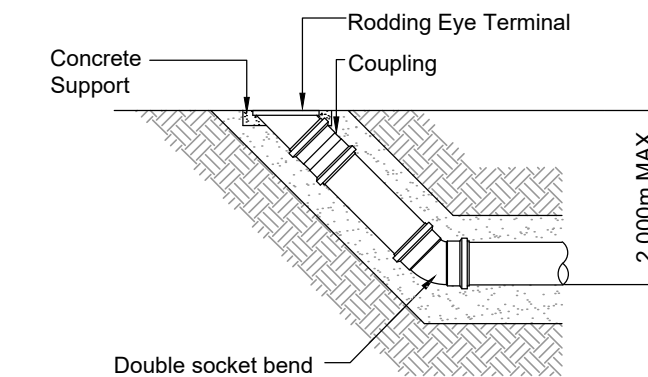



Roding eye detail

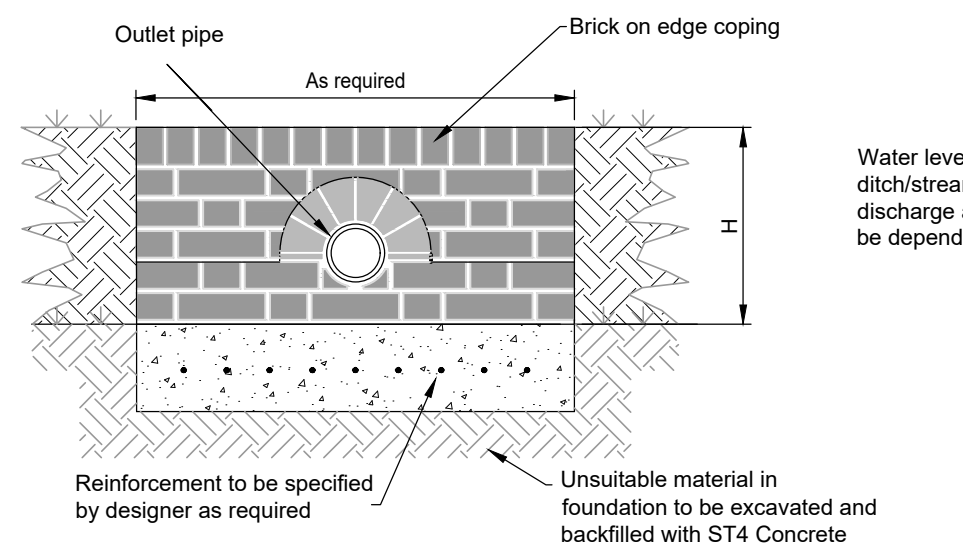


ELEVATION OF HEADWALL OUTFALL TO POND / SIDE OF DITCH

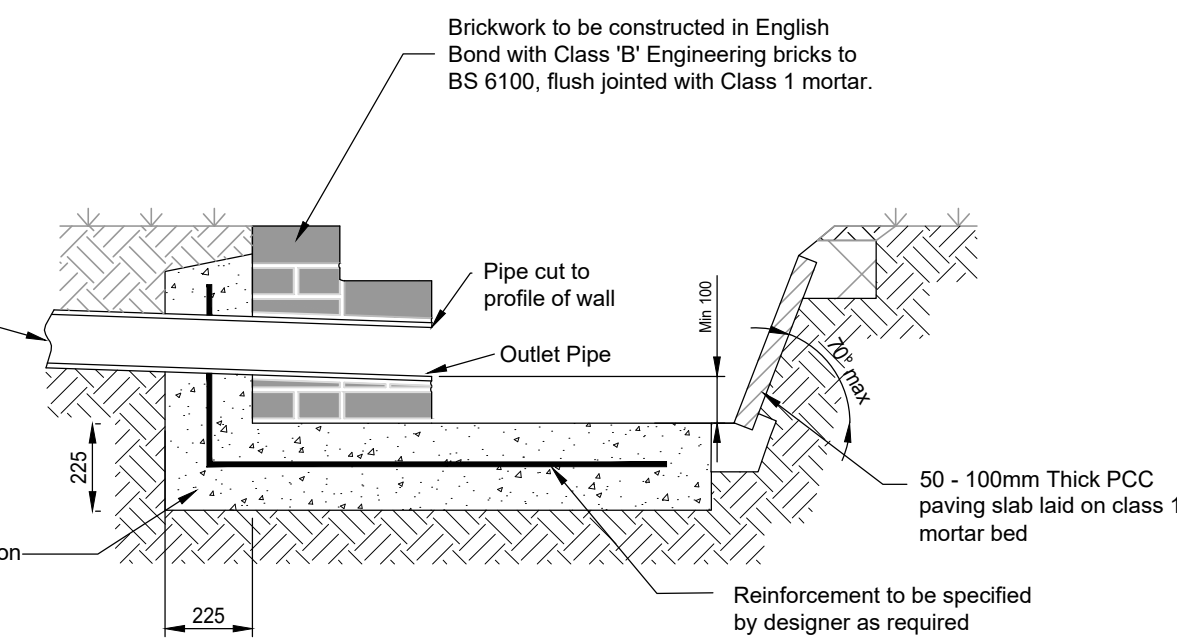


HEADWALL SECTION OUTFALL TO SIDE OF DITCH

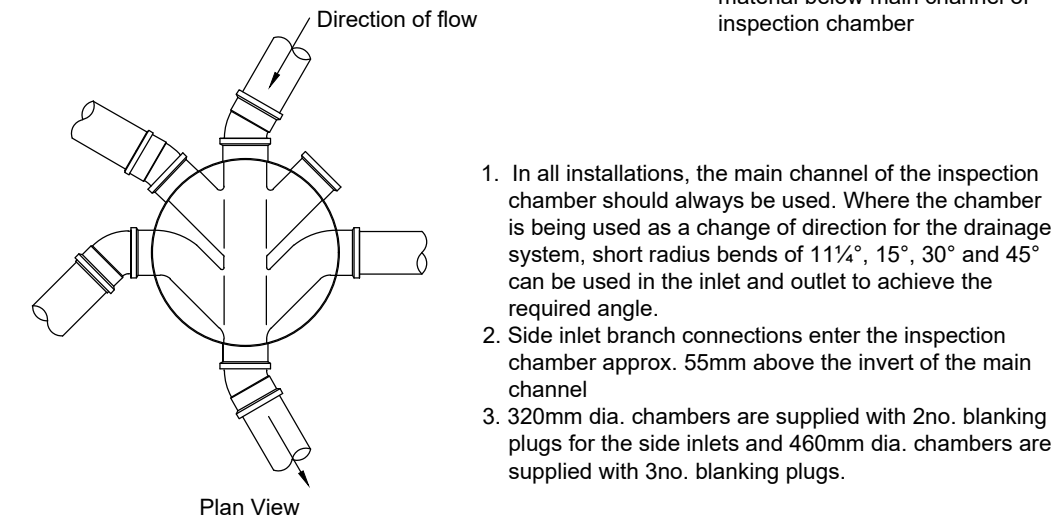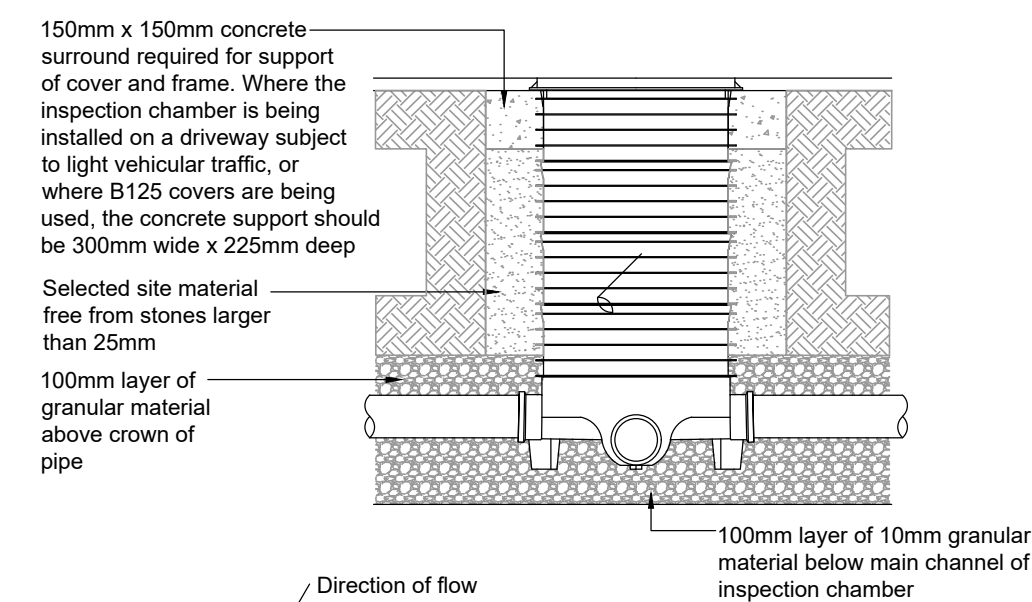

460mmØ INSPECTION CHAMBER DETAIL

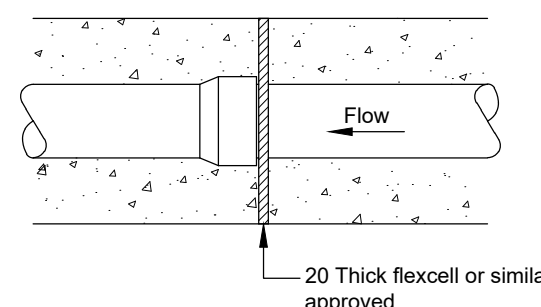

Flexible joint detail for socketed pipes Joints for concrete encased pipes

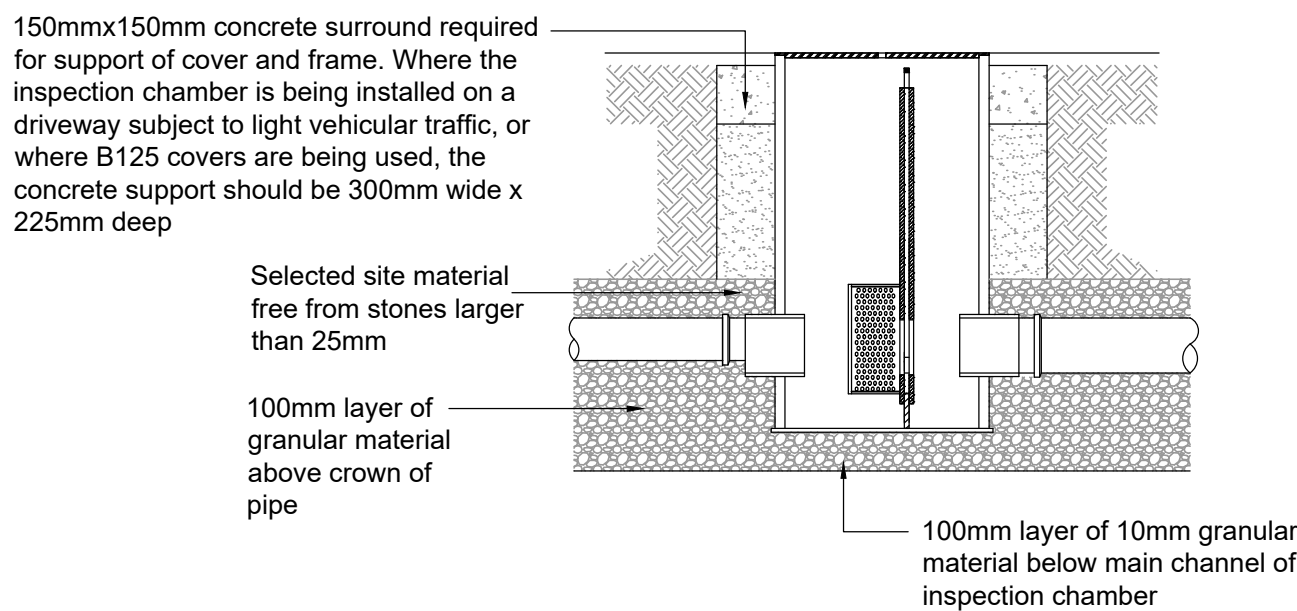

SEL CONTROFLOW 500 ORIFICE CHAMBER

SEL Environmental LTD
Phone: 01254 589987
Email: sales@selenvironmental.com

P1	21.07.20	UPDATED TO MATCH LAYOUT	LH	CS	CS
P-	25.03.20	PRELIMINARY ISSUE	LH	CS	CS
REV	DATE	DESCRIPTION	BY	CHK	APP

cgs
civils
Consulting Civil Engineers

CLIENT	KIERAN NAPHTHINE				
ARCHITECT	SMITH SIMMONS AND PARTNERS				
JOB TITLE	TYRONE HOUSE ALDINGBOURNE				
DRAWING TITLE	CONSTRUCTION DETAILS SHEET 1 OF 2				
DRAWN	LH	ENGINEER	CS	CHECKED	CS
DATE	MARCH 2020		SCALE @ A1 1:20		
JOB No.	C1340	STATUS	P	DRAWING No.	300
REV.	P1				

PRELIMINARY