

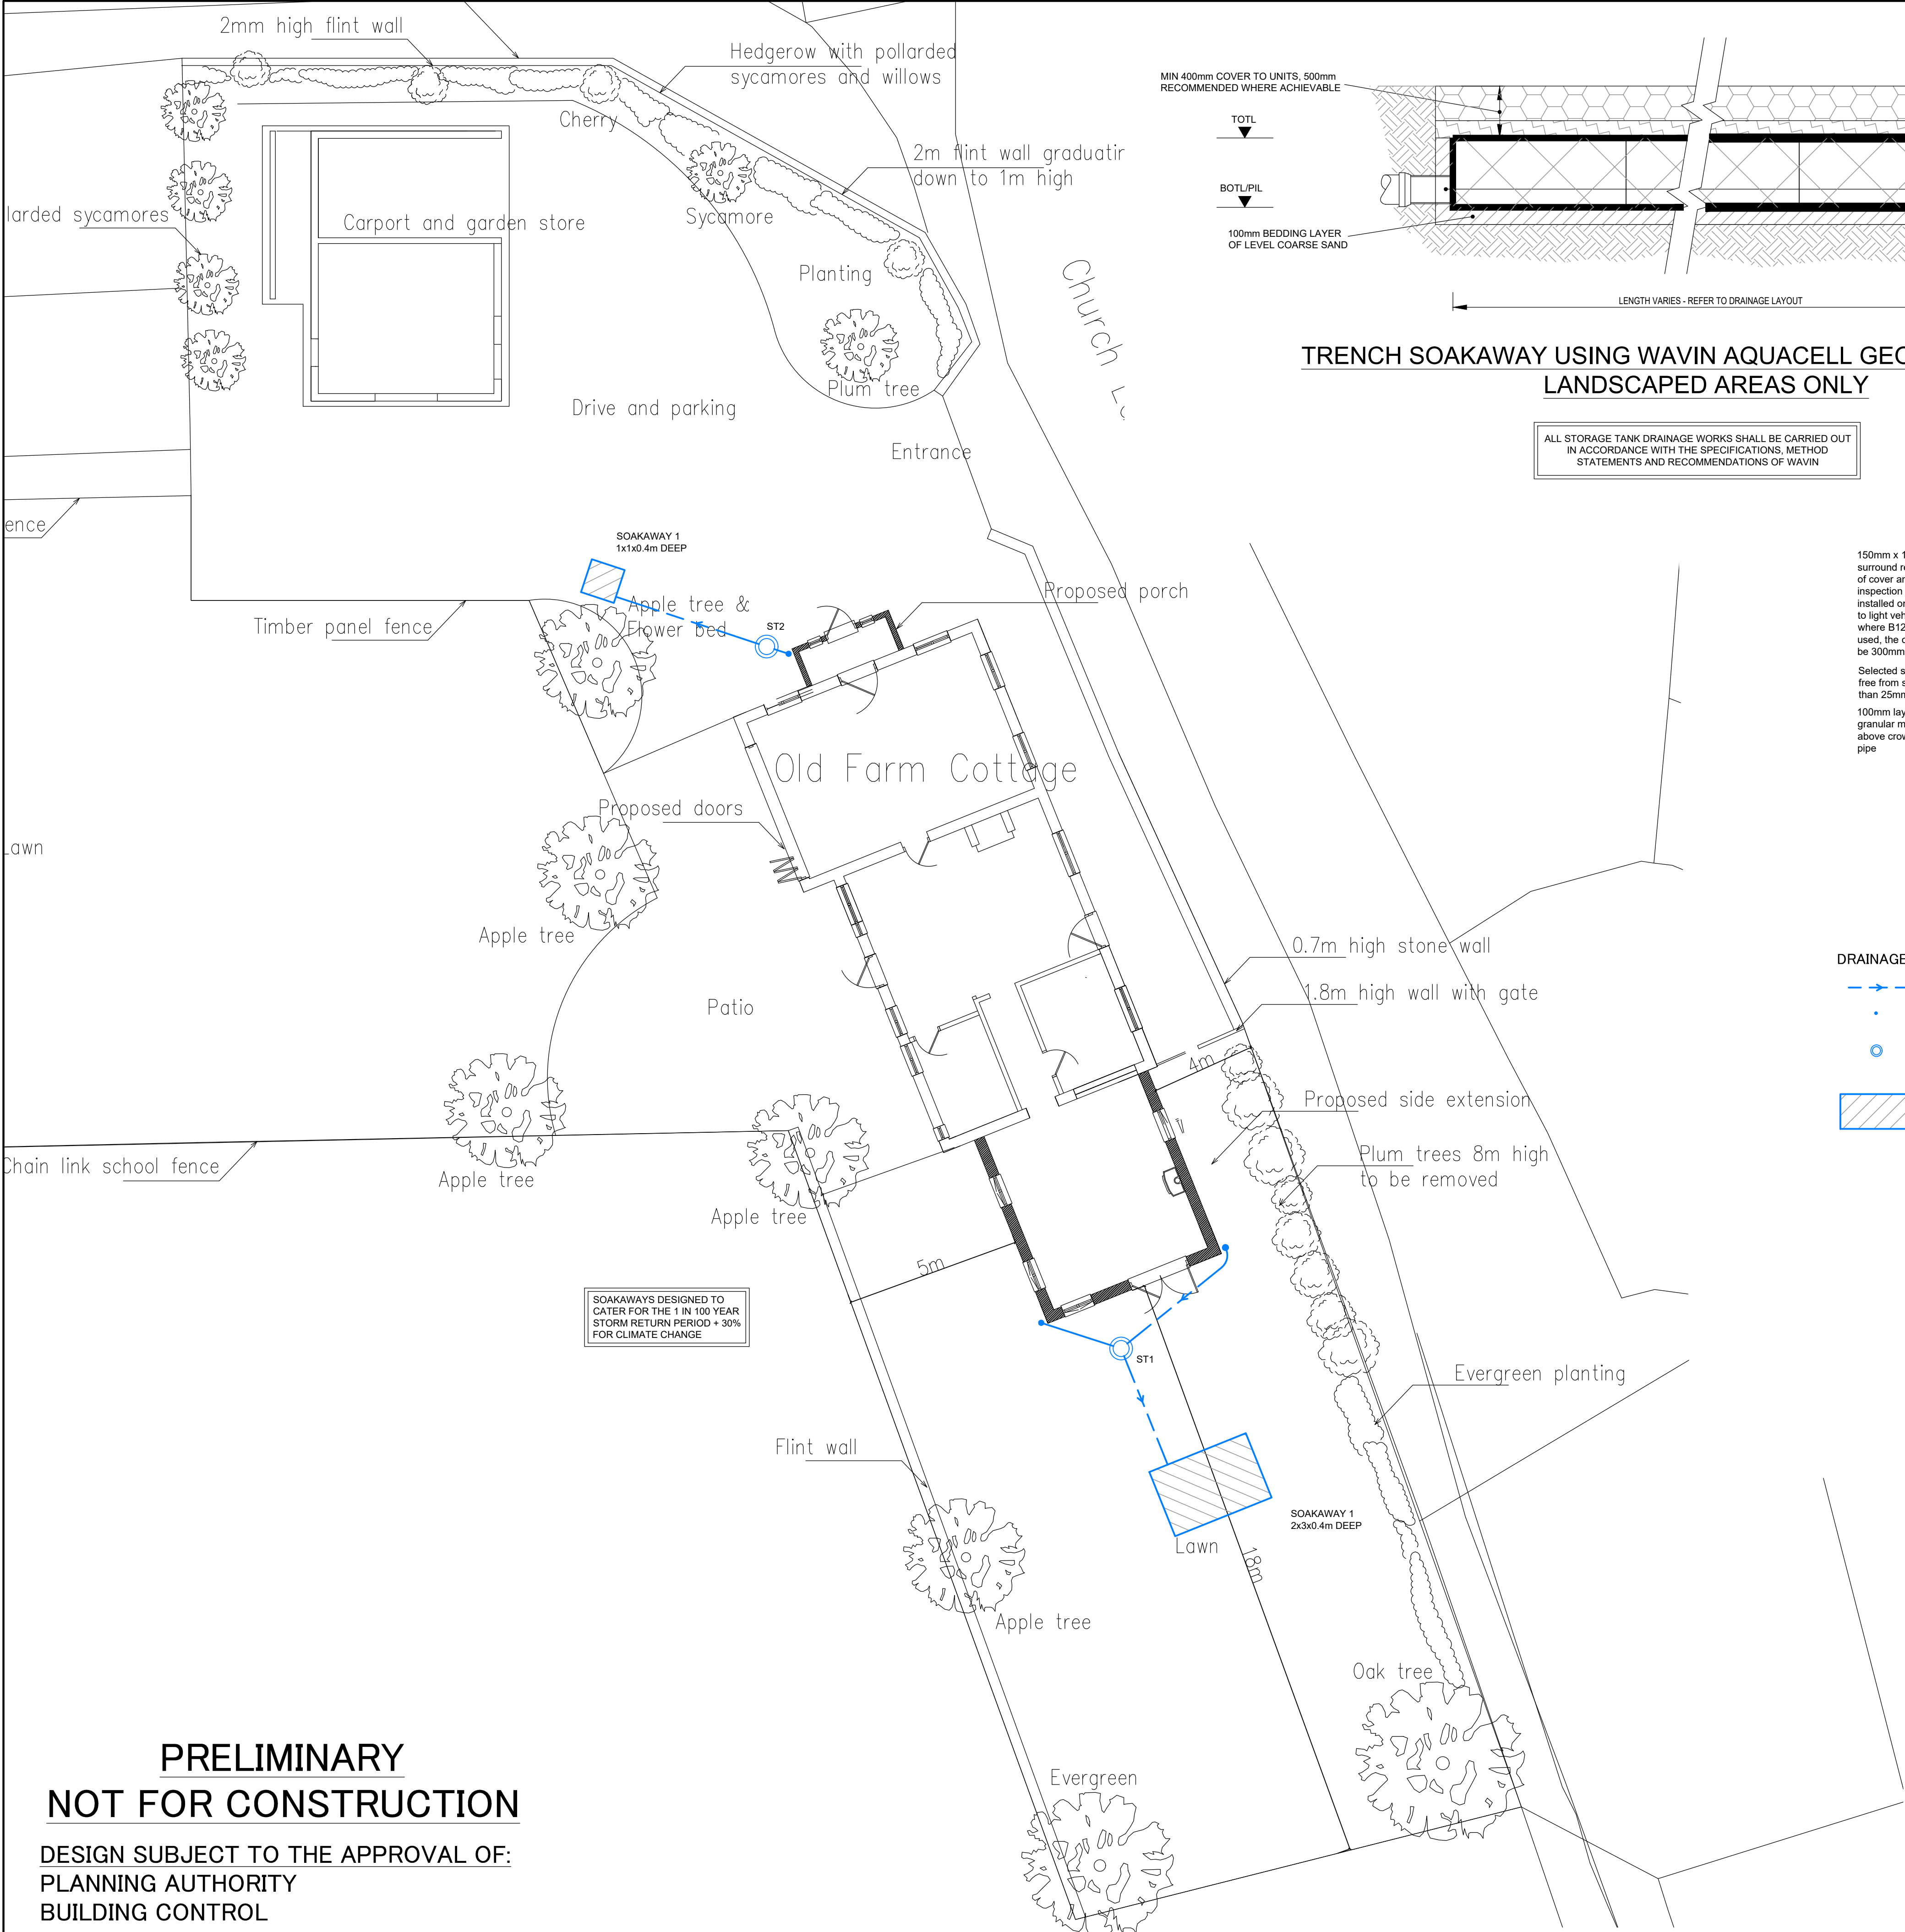


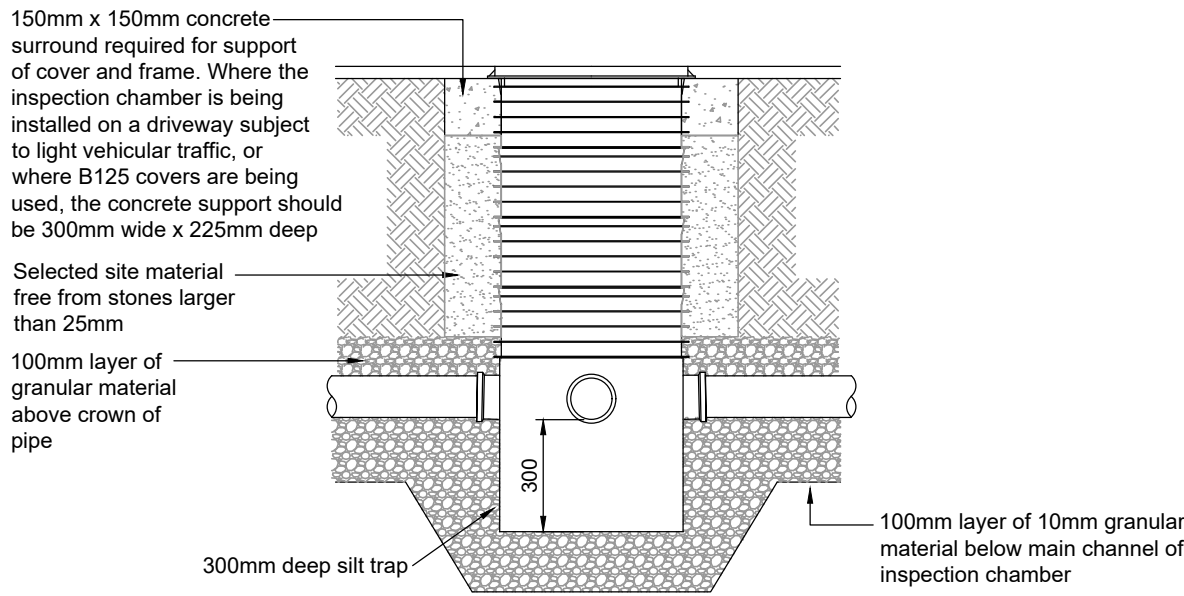


TRENCH SOAKAWAY USING WAVIN AQUACELL GEOMODULAR UNITS
LANDSCAPED AREAS ONLY

ALL STORAGE TANK DRAINAGE WORKS SHALL BE CARRIED OUT
IN ACCORDANCE WITH THE SPECIFICATIONS, METHOD
STATEMENTS AND RECOMMENDATIONS OF WAVIN

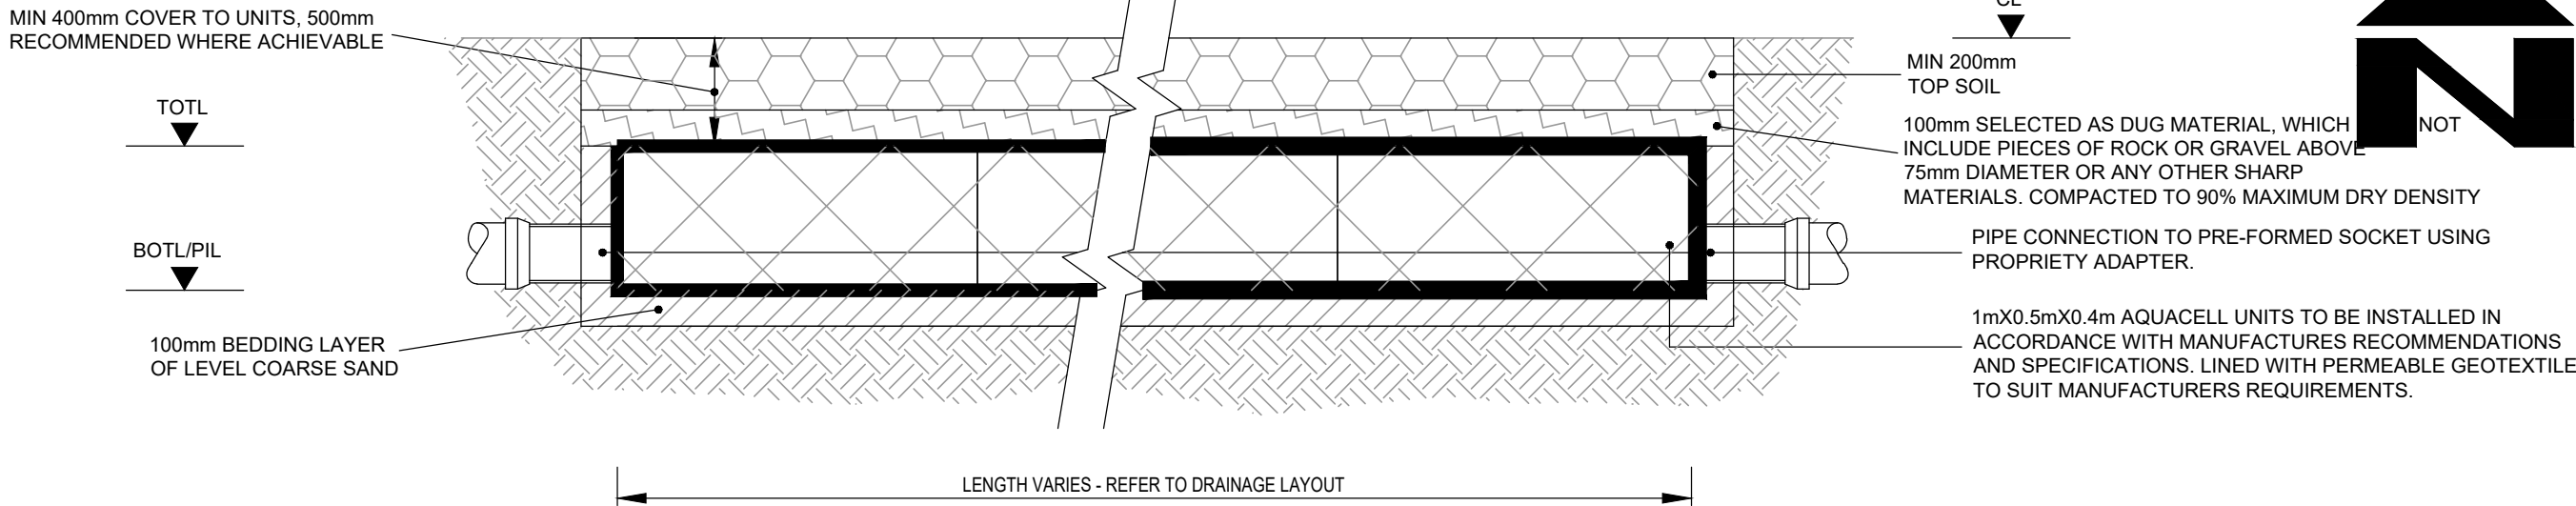

460mmØ POLYPIPE BASIC
SILT TRAP DETAIL

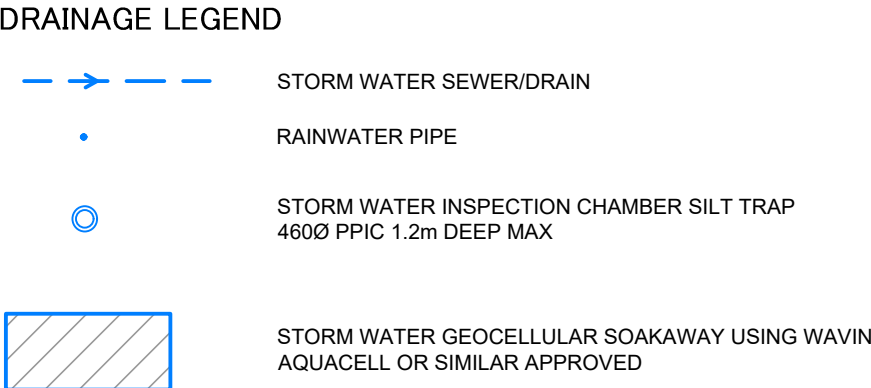

- STANDARD NOTES
- DO NOT SCALE FROM THIS DRAWING. REFER TO FIGURED DIMENSIONS ONLY. THE CONTRACTOR SHOULD CHECK ALL DIMENSIONS ON SITE.
 - ALL DIMENSIONS IN MILLIMETRES AND ALL LEVELS ARE IN METERS UNLESS NOTED OTHERWISE.
 - THIS DRAWING SHOULD BE READ IN CONJUNCTION WITH ALL OTHER RELEVANT ARCHITECT AND ENGINEERING DETAILS, DRAWINGS AND SPECIFICATIONS.
 - ANY DISCREPANCIES SHOULD BE REPORTED TO THE ARCHITECT AND/OR ENGINEER IMMEDIATELY, SO THAT CLARIFICATION CAN BE SOUGHT PRIOR TO THE COMMENCEMENT OF WORK.
 - BEFORE COMMENCING CONSTRUCTION THE CONTRACTOR MUST CHECK THE INVERT LEVELS OF EXISTING SEWERS TO WHICH CONNECTIONS ARE MADE. IN ADDITION THE CONTRACTOR MUST LOCATE AND DETERMINE INVERT LEVELS OF THE EXISTING SPURS TO WHICH CONNECTIONS ARE MADE. ANY DISCREPANCIES ARE TO BE NOTIFIED TO THE ENGINEER IMMEDIATELY, PRIOR TO CONSTRUCTION.
 - ALL DRAINAGE WORKS SHOULD COMMENCE AT THE PROPOSED DOWNSTREAM CONNECTION POINT. THE WORKS CONTINUING UPSTREAM FOLLOWING CONFIRMATION OF THE TIE-IN INVERT LEVELS TO THE ENGINEER. CONNECTIONS TO MANHOLES OR LARGER SIZED PIPES ETC. SHOULD BE SOFFIT TO SOFFIT UNLESS OTHERWISE INSTRUCTED BY THE ENGINEER. IF THIS IS NOT POSSIBLE INFORM THE ENGINEER IMMEDIATELY.
 - COVER LEVELS SHOWN ARE APPROXIMATE. COVERS AND FRAMES SHALL BE SET TO FINISHED GROUND LEVELS AND FALLS.
 - ALL PIPES TO BE ADOPTED, OR CONNECTING TO ADOPTED SEWERS, TO BE VITRIFIED CLAY TO BS EN 285 AND BS45 (SWS ONLY), OR CONCRETE PIPES TO BE EN 1916 AND BS5911 PART 1.
 - Y FW MIN GRADIENT - 1 IN 40 (100 DIA) NO WC'S CONNECTED
 - Y FW MIN GRADIENT - 1 IN 80 (100 DIA) MIN 1 WC CONNECTED
 - Y FW MIN GRADIENT - 1 IN 150 (150 DIA) MIN 5 WC'S CONNECTED
 - Y SW MIN GRADIENT - 1 IN 100 (100 DIA)
 - Y SW MIN GRADIENT - 1 IN 150 (150 DIA)
 - ROAD GULLY OUTLET PIPES ARE TO BE 150mm DIA. WITH CONCRETE SURROUND AND FLEXIBLE JOINTS. ALL OTHER UN-REFERENCED PIPES ARE ASSUMED TO BE 100mm DIA.
 - ALL GULLIES SHALL BE FITTED WITH GRADE D400 GRATINGS AND FRAMES TO BS EN124, UNLESS OTHERWISE STATED.
 - ALL ADOPTABLE SEWERS SHALL BE CONSTRUCTED TO THE STANDARDS AND SPECIFICATION LAID DOWN DOWN IN 'SEWERS FOR ADOPTION' 6th EDITION, WITH A VIEW TO ADOPTION UPON COMPLETION OF WORKS.
 - IN ORDER TO MAINTAIN THE SATISFACTORY FUNCTIONING OF SURFACE WATER SEWERS, ALL ROAD AND YARD GULLIES ARE TO BE 'TRAPPED'.
 - ANY WORKS ASSOCIATED WITH THE PUBLIC HIGHWAY INCLUDING HIGHWAY DRAINAGE, SHALL BE IN ACCORDANCE WITH THE HIGHWAYS AGENCY SPECIFICATION WORKS, UNLESS NOTED OTHERWISE OR HCC STANDARD SPECIFICATIONS OR DRAWINGS.
 - ALL ADOPTABLE SEWERS WITH LESS THAN 1.2m OF COVER WHEN LAID BENEATH THE ROADS, OR 0.9m OF COVER IN OTHER AREAS, SHALL HAVE TYPE Z BED.
 - ALL PRIVATE DRAINAGE TO BE IN ACCORDANCE WITH THE BUILDING REGULATIONS APPROVED DOCUMENT PART-H, AND TO THE SATISFACTION OF THE BUILDING CONTROL INSPECTOR.
 - WHERE DRAINS PASS THROUGH FOUNDATIONS OR CONNECT TO MANHOLES, A FLEXIBLE PIPE JOINT SHOULD BE PROVIDED TO FORM A ROCKER PIPE IN ACCORDANCE WITH THE STANDARD DETAIL PROVIDED.
 - WHERE DRAINAGE RUNS PASS CLOSE TO BUILDINGS OR THEIR INVERT LEVELS ARE BELOW FOUNDATION LEVEL, THEN THE TRENCHES ARE TO BE BACK FILL IN ACCORDANCE WITH THE STANDARD DETAIL PROVIDED.
 - THE CONTRACTOR IS TO KEEP A RECORD OF ANY VARIATIONS MADE ON SITE, INCLUDING THE RELOCATION OF SEWERS OR DRAINS, SO THAT AN AS CONSTRUCTED DRAWING CAN BE PREPARED UPON COMPLETION OF THE PROJECT.
 - STUB CONNECTIONS TO ADOPTABLE MANHOLES SHALL BE MADE FROM VITRIFIED CLAY AND CONSIST OF TWO ROCKER PIPES LAID AT THE SAME GRADIENT AS THE UP OR DOWNSTREAM PIPE.
 - ALL DOWNPIPES ARE TO BE SEALED AND CONNECTED DIRECTLY TO THE STORMWATER DRAIN. ACCESS POINTS ARE TO BE PROVIDED 1m ABOVE GROUND LEVEL FOR EXTERNAL RWP'S AND 1m ABOVE FFL FOR INTERNAL RWP'S. IF INTERNAL RWP'S ARE TO BECOME INACCESSIBLE THEN ACCESS CHAMBERS ARE TO BE PROVIDED EXTERNALLY TO ACCESS EACH RWP.
 - MODULAR GEOCELLULAR STORAGE/SOAKAWAY SYSTEM TO CONFORM TO CIRIA C697 THE SUDS MANUAL, C680 STRUCTURAL DESIGN OF MODULAR GEOCELLULAR DRAINAGE TANKS & C698 SITE HANDBOOK FOR THE CONSTRUCTION OF SUDS. THE MANUFACTURER SHOULD PROVIDE A COMPLETE SET OF INDEPENDENT TEST RESULTS FOR A PROPOSED SYSTEM INCLUDING, AS A MINIMUM, STRESS/STRAIN CURVES FOR VERTICAL AND LATERAL COMPRESSION, AND CREEP TESTS UNDER SUSTAINED LONG-TERM LOADS. A BBA CERTIFICATE IS NOT INDEPENDENT TEST DATA.
 - IF ANY SUB SOIL DRAINAGE SYSTEMS ARE UNCOVERED DURING THE WORKS CONTACT THE ENGINEER FOR INSTRUCTIONS. SUB SOIL DRAINS ARE TO BE DIVERTED AROUND NEW WORKS AND CONNECTED INTO THE SURFACE WATER.
 - NO PRIVATE AREAS ARE TO DRAIN ONTO ADOPTABLE AREAS AND VICE VERSA.
 - SOFT SPOTS IN FORMATION ARE TO BE REMOVED AND REPLACED WITH SUITABLE MATERIAL.
 - ALL EXISTING MANHOLE COVERS, GULLIES, ETC. ARE TO BE RAISED TO SUIT NEW LEVELS.

P=	16.07.18	DRAFT ISSUE FOR COMMENT	C.S.	C.S.	-
REV	DATE	DESCRIPTION	BY	CHK	APP
 Consulting Civil Engineers					
CLIENT	BVL DEVELOPMENTS LTD				
ARCHITECT	BVL DEVELOPMENTS LTD				
JOB TITLE	OLD FARM COTTAGE EASTERGATE				
DRAWING TITLE	DRAINAGE LAYOUT				
DRAWN	CS	ENGINEER	C.SLADDE	CHECKED	APPROVED
DATE	JULY 2018		SCALE @ A1 1:100		
JOB No.	C1090	STATUS	P	DRAWING No.	100
REV.	P-				

PRELIMINARY
NOT FOR CONSTRUCTION
DESIGN SUBJECT TO THE APPROVAL OF:
PLANNING AUTHORITY
BUILDING CONTROL