


Timber purlin support above
where partition wall is removed.



- m&e key:
- towel radiator
 - radiator (sized to suit)
 - Pendant light fitting
 - halogen spot
 - spots on wire track (spots min 50watt)
 - Flourescent light fitting
 - Wall light
 - manual external light (no sensor)
 - Exterior Light (with movement sensor)
 - D-TV
 - TV aerial point
 - double switched socket
 - double switched socket above work top
 - external double socket
 - mains smoke detector and sounder (linked)
 - mains heat detector (linked)
 - Light pull-switch
 - Light switch (2 way)
 - External Tap
 - Extract Fan
 - Telephone point
 - Broadband access point
 - Consumer unit
 - Meter

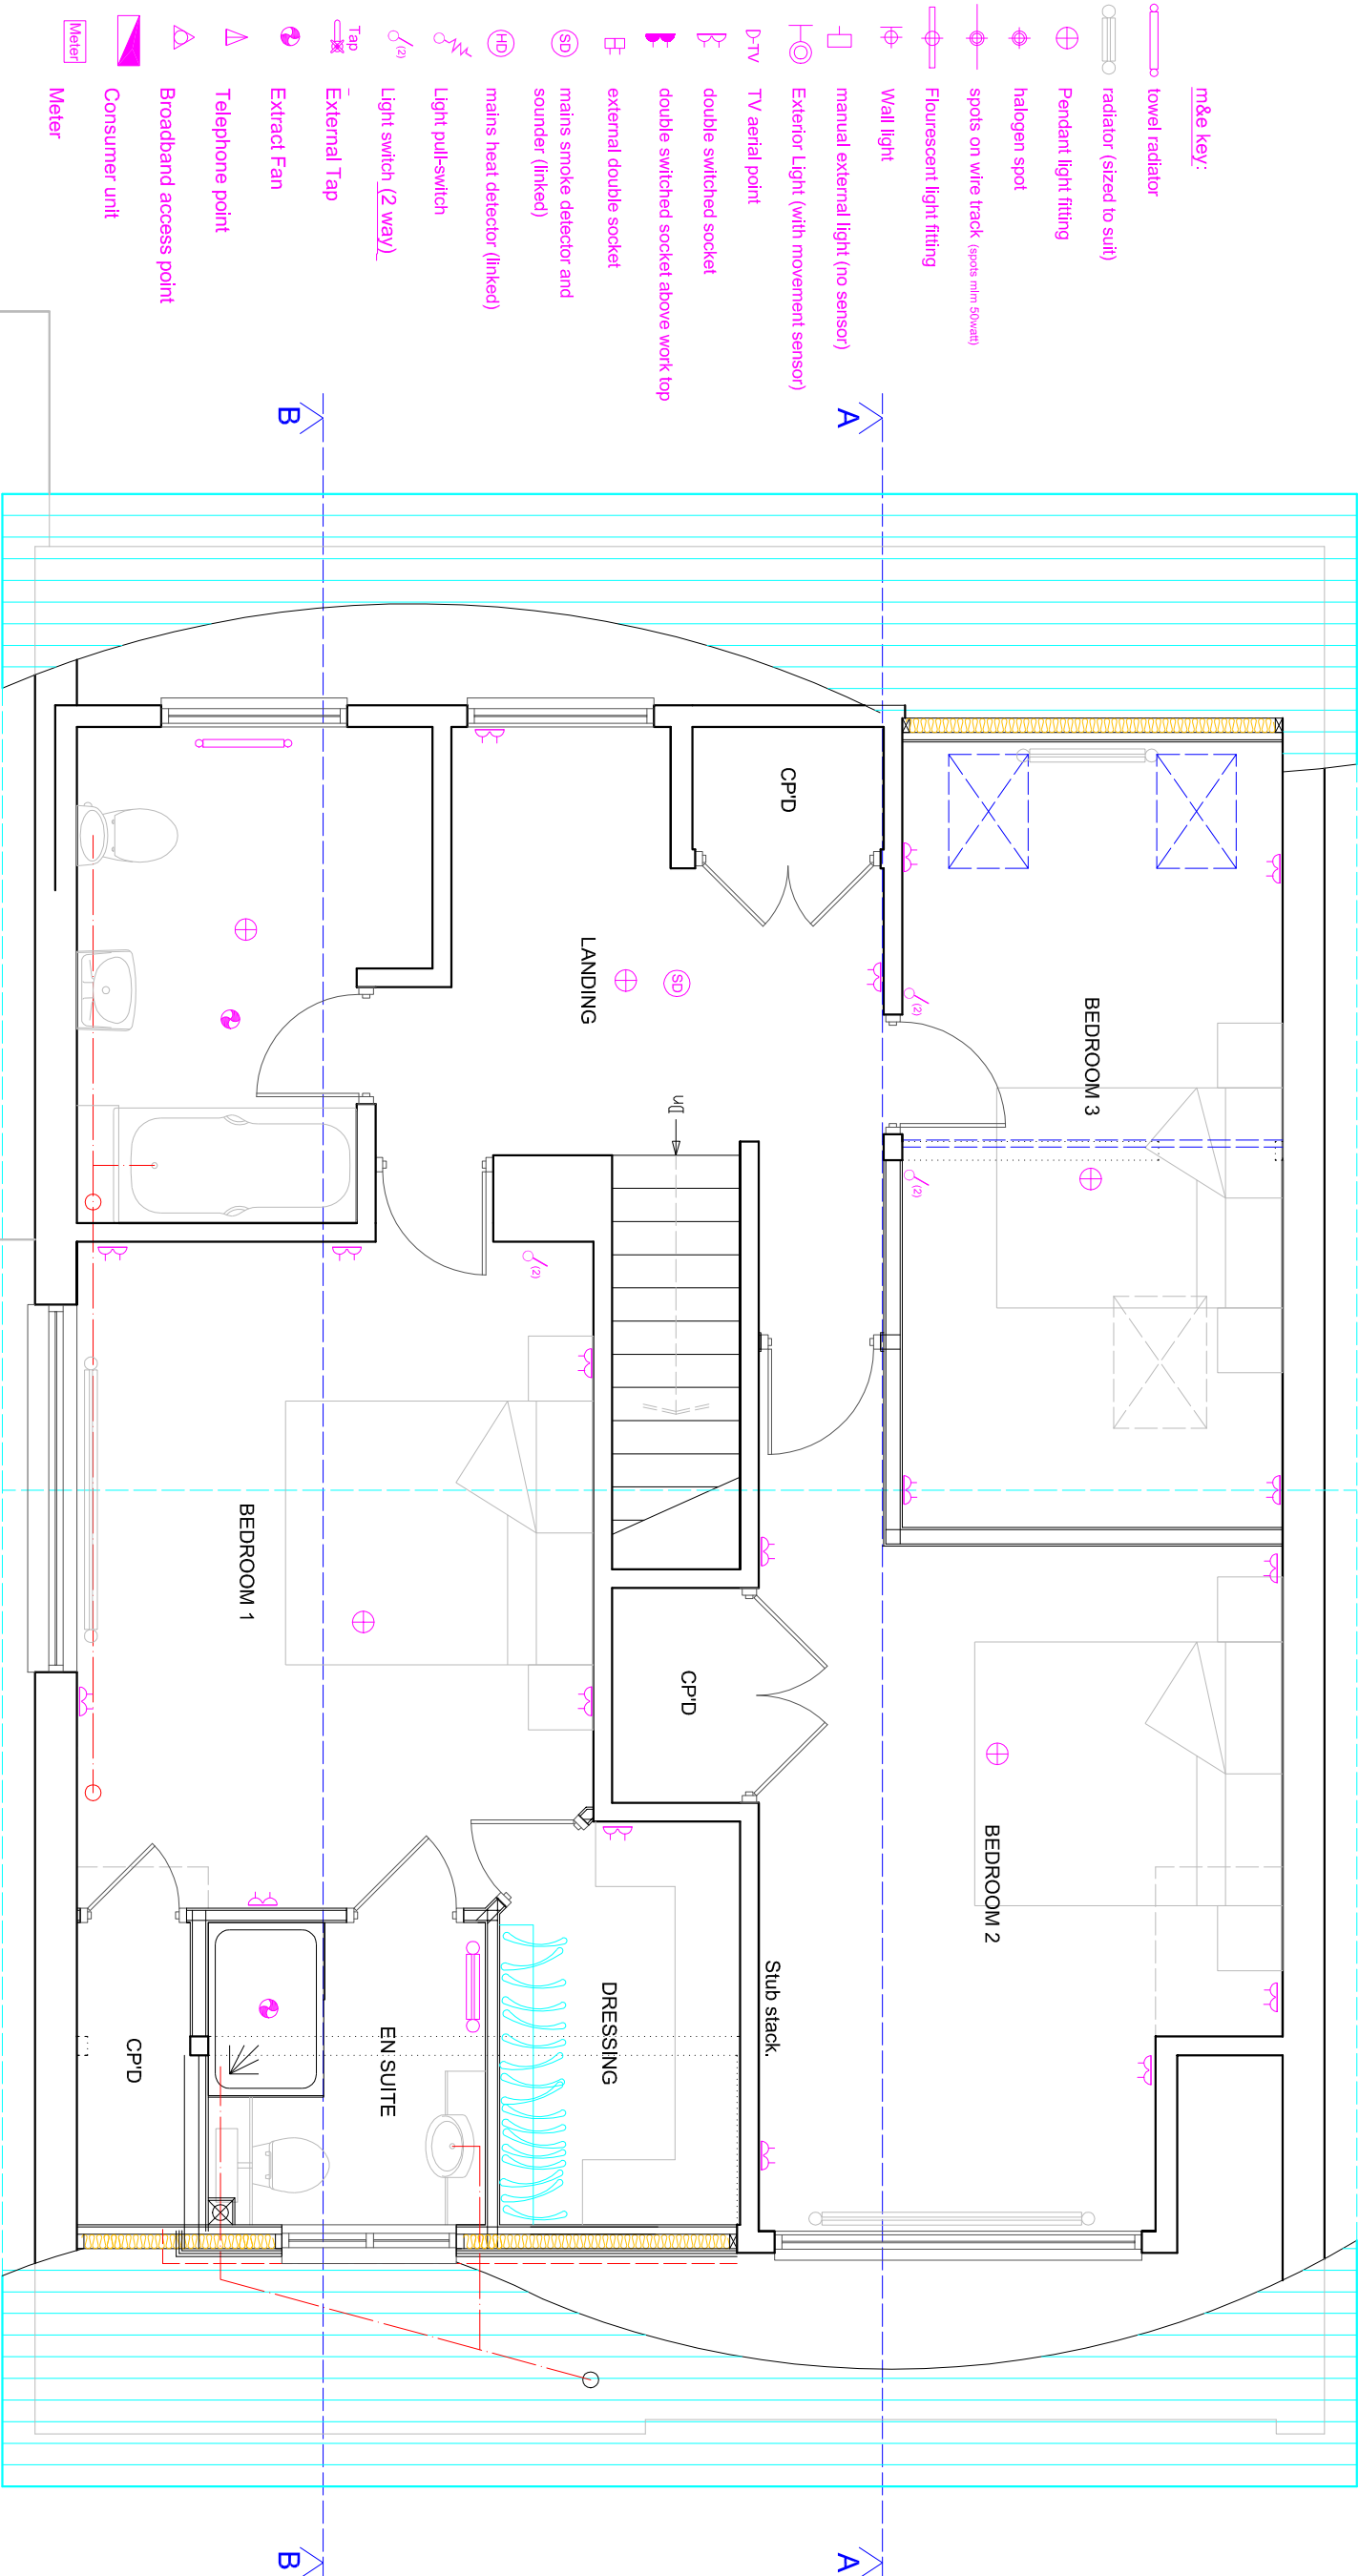

PROPOSED FIRST FLOOR PLAN

Scale 1:50 on A3

SUSSEX BUILDING CONSULTANCY LIMITED

4 REGIS AVENUE, ALDWICK,
BOGNOR REGIS, WEST SUSSEX.

SCALE - 1/50 REV - F DATE - 21/07/2026