


- m&e key:
- towel radiator
 - radiator (sized to suit)
 - Pendant light fitting
 - halogen spot
 - spots on wire track (spots min 50watt)
 - Flourescent light fitting
 - Wall light
 - manual external light (no sensor)
 - Exterior Light (with movement sensor)
 - D-TV TV aerial point
 - double switched socket
 - double switched socket above work top
 - external double socket
 - mains smoke detector and sounder (linked)
 - mains heat detector (linked)
 - Light pull-switch
 - Light switch (2 way)
 - External Tap
 - Extract Fan
 - Telephone point
 - Broadband access point
 - Consumer unit
 - Meter

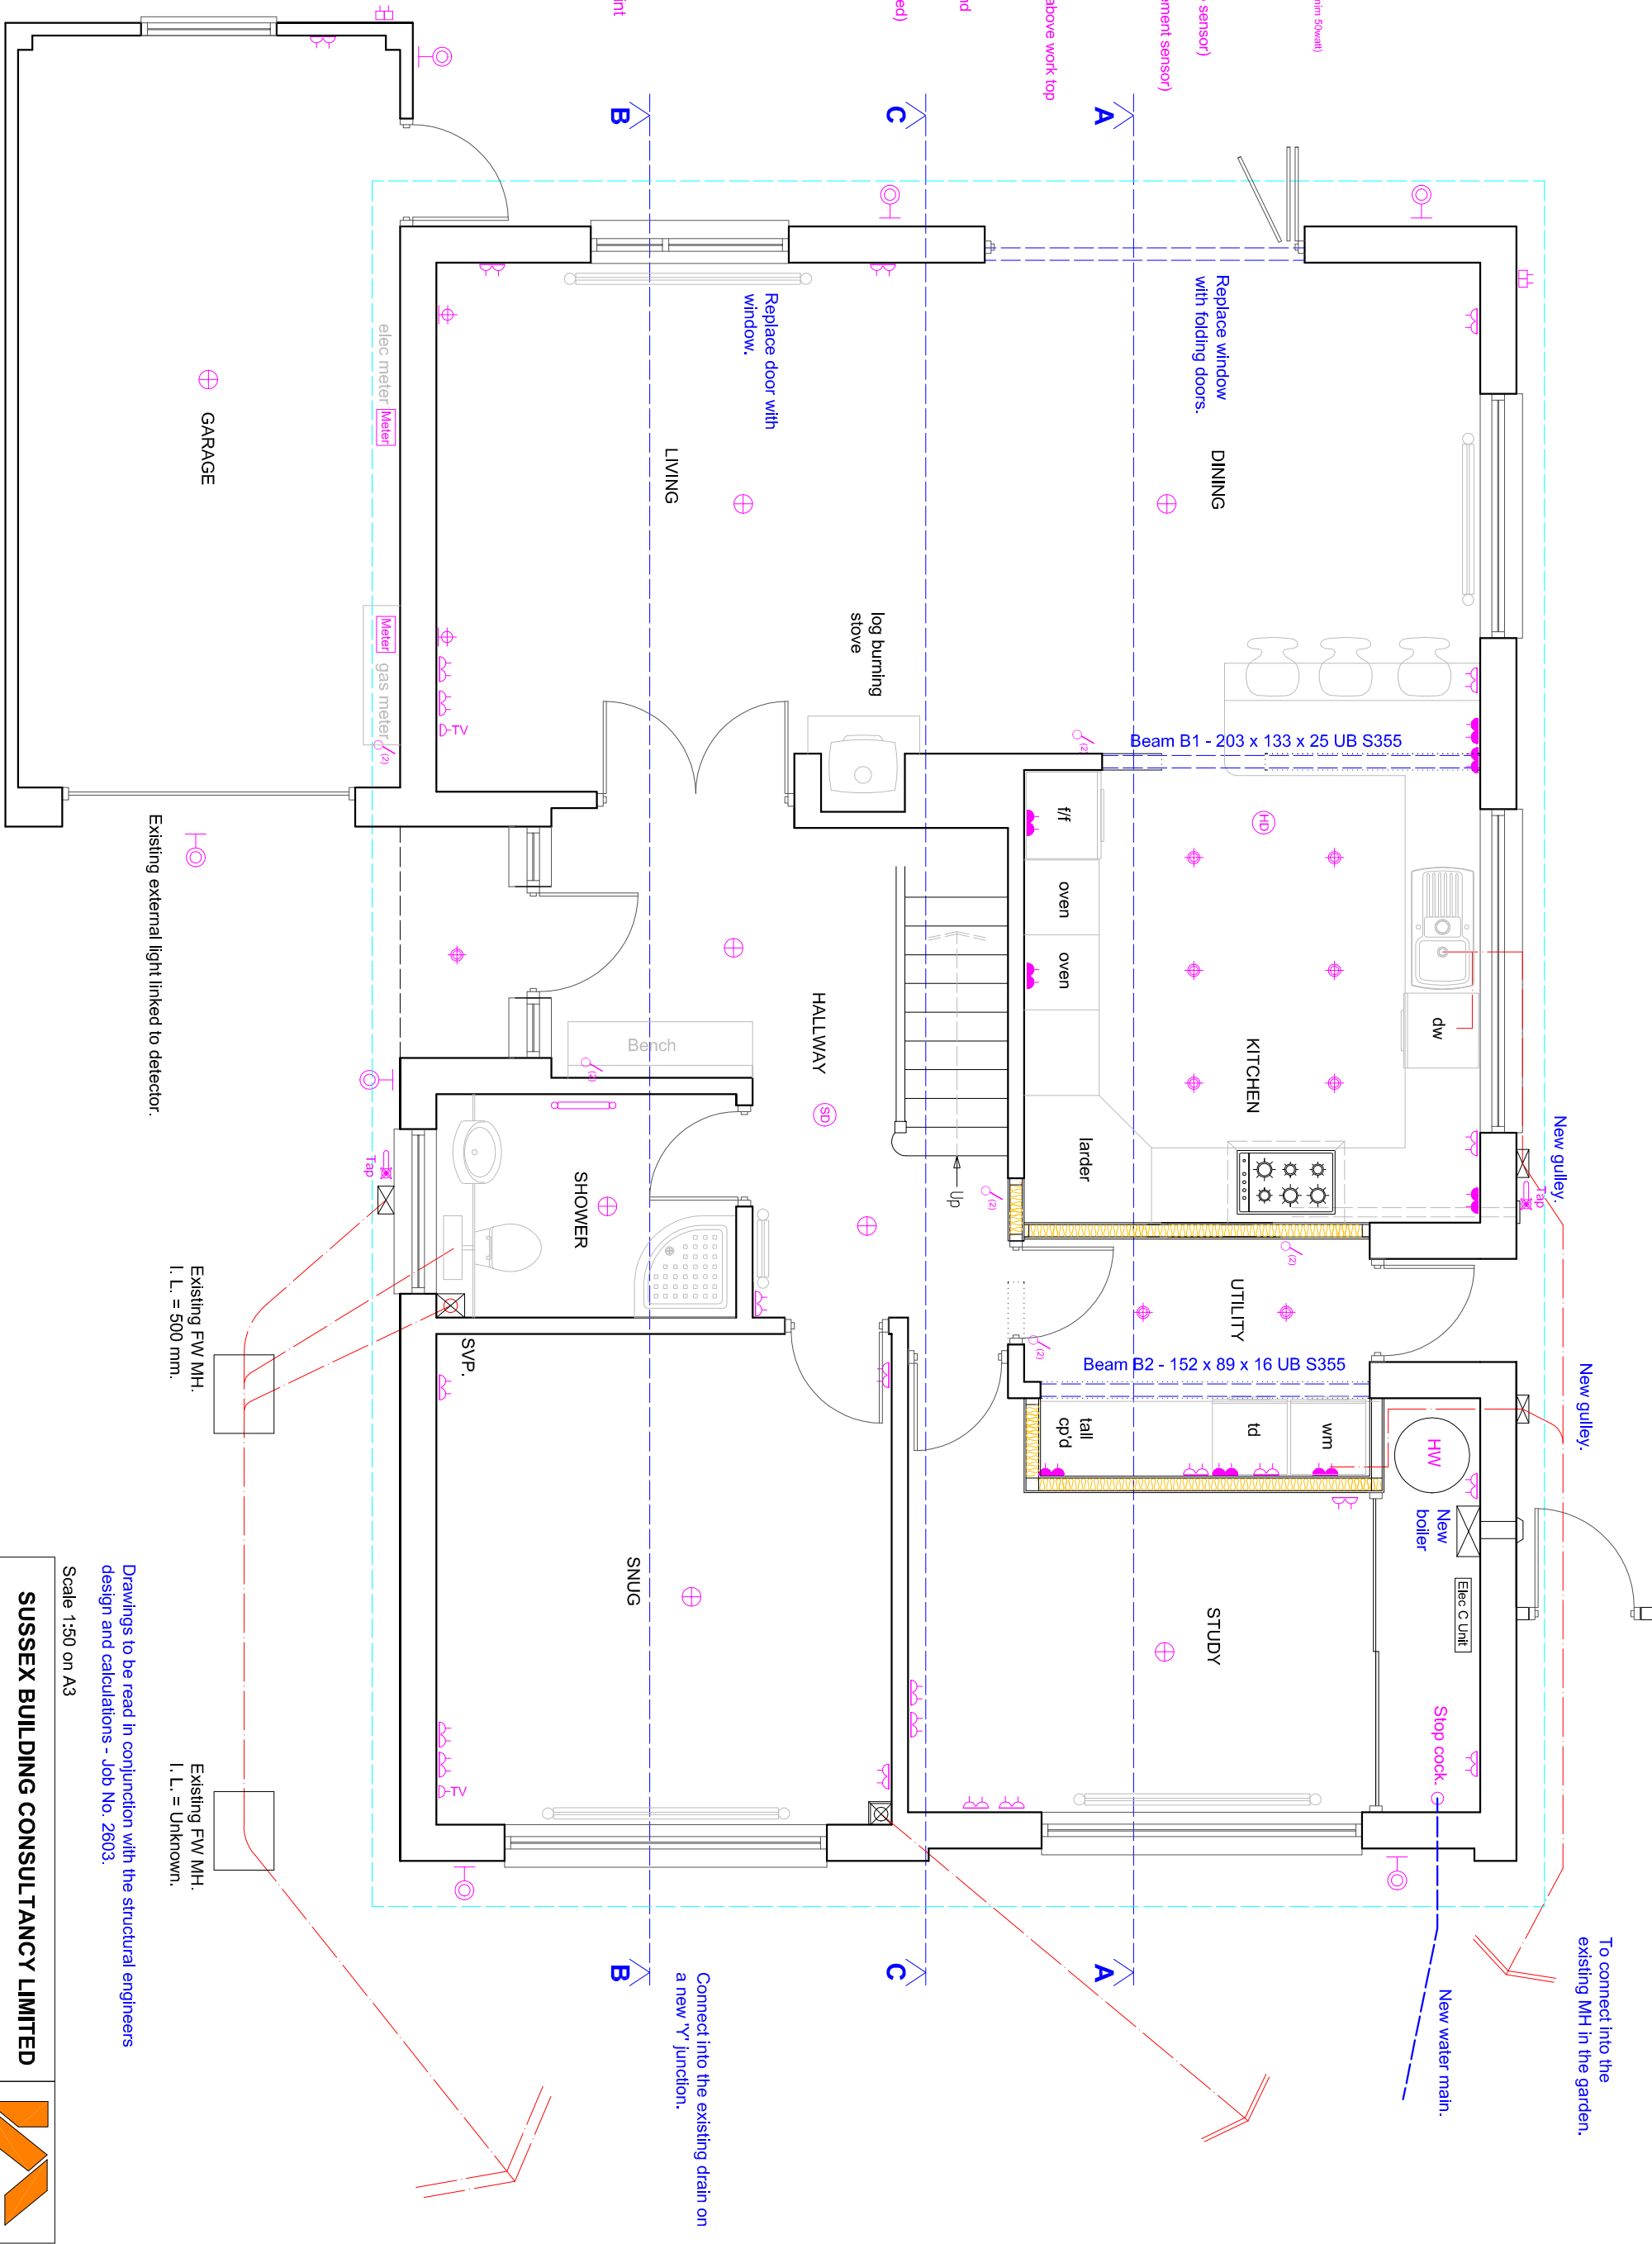

Drawings to be read in conjunction with the structural engineers design and calculations - Job No. 2603.

Scale 1:50 on A3

SUSSEX BUILDING CONSULTANCY LIMITED


4 REGIS AVENUE, ALDWICK,
BOGNOR REGIS, WEST SUSSEX.

SCALE - 1/50 REV - G DATE - 21/07/2026

partner

LABC

3 NORTHCOOTE ROAD
BOGNOR REGIS
PO21 5LZ
TEL/FAX - (01243) 861379

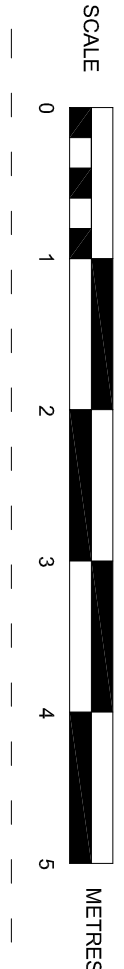

PROPOSED GROUND FLOOR PLAN