

PROPOSED GROUND FLOOR PLAN

SCALE
0 1 2 3 4 5 METRES


Scale 1:50 on A3

SUSSEX BUILDING CONSULTANCY LIMITED

7 MEADOW WAY, ALDWICK,
BOGNOR REGIS, WEST SUSSEX.

SCALE - 1/50 REV - B DATE - 11/11/2024

partner
LABC
3 NORTHCOTE ROAD
BOGNOR REGIS
PO21 5LZ
TELFAX - (01243) 861379

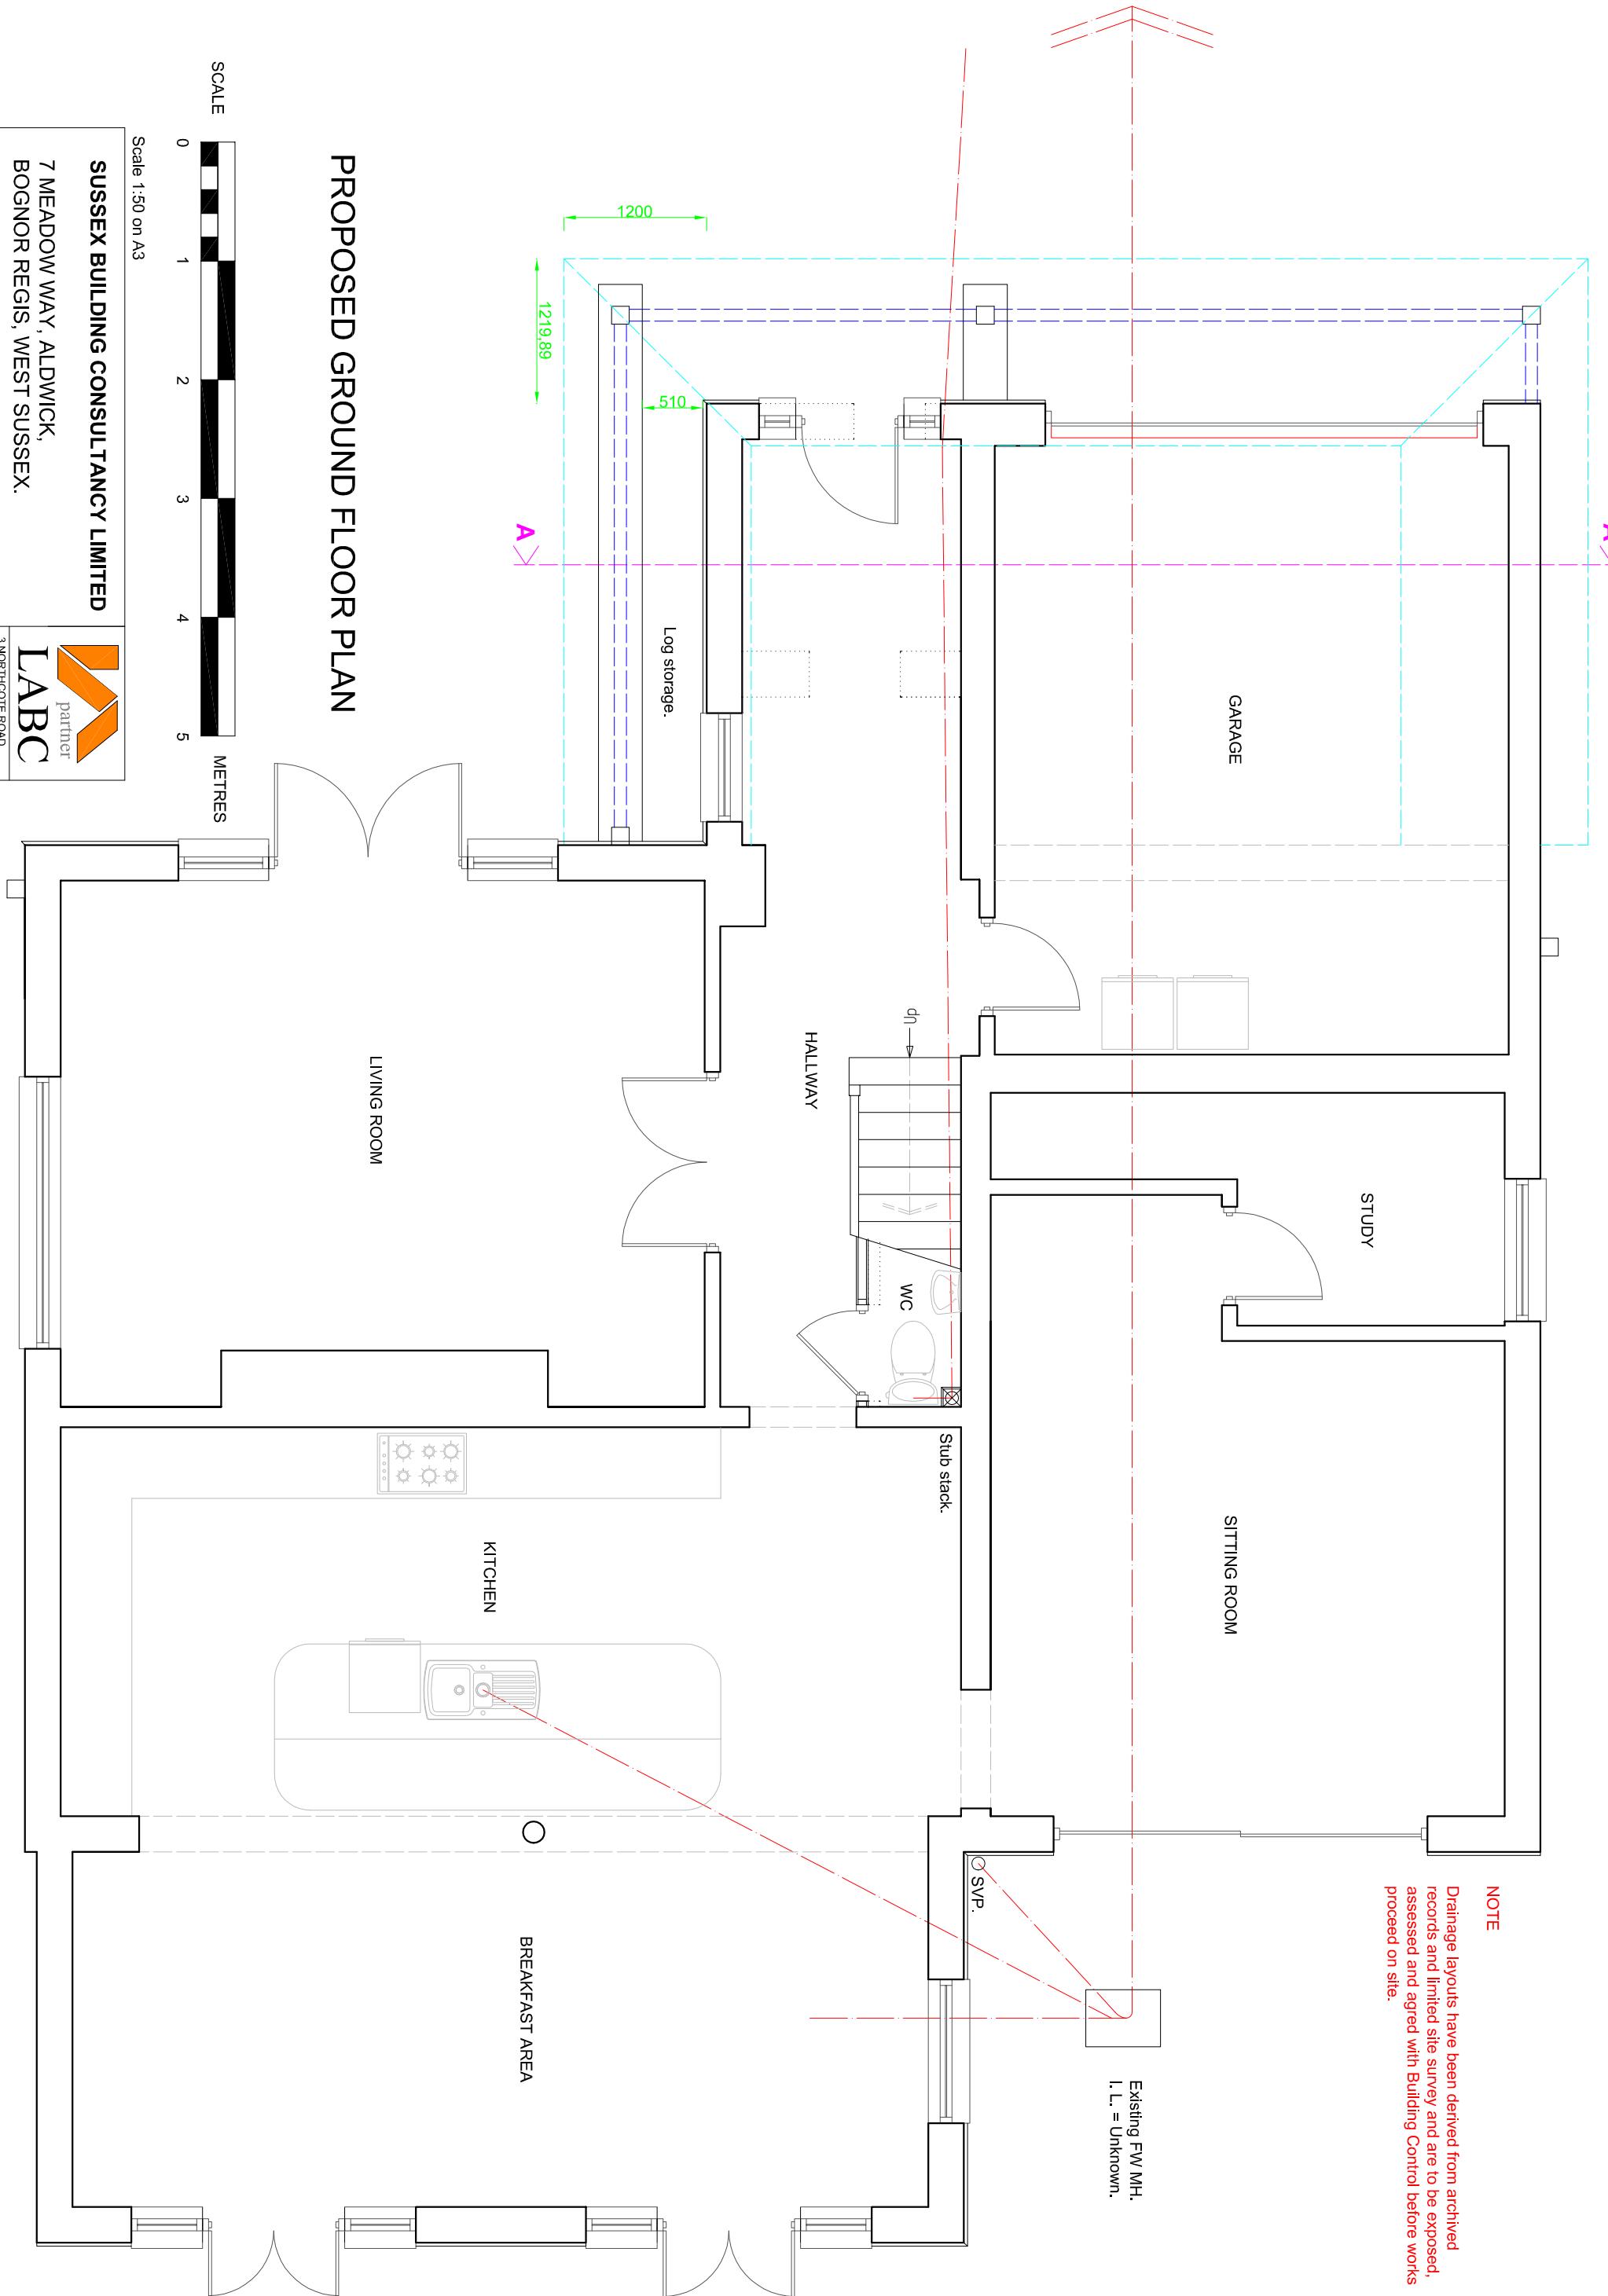

NOTE
Drainage layouts have been derived from archived records and limited site survey and are to be exposed, assessed and agreed with Building Control before works proceed on site.