



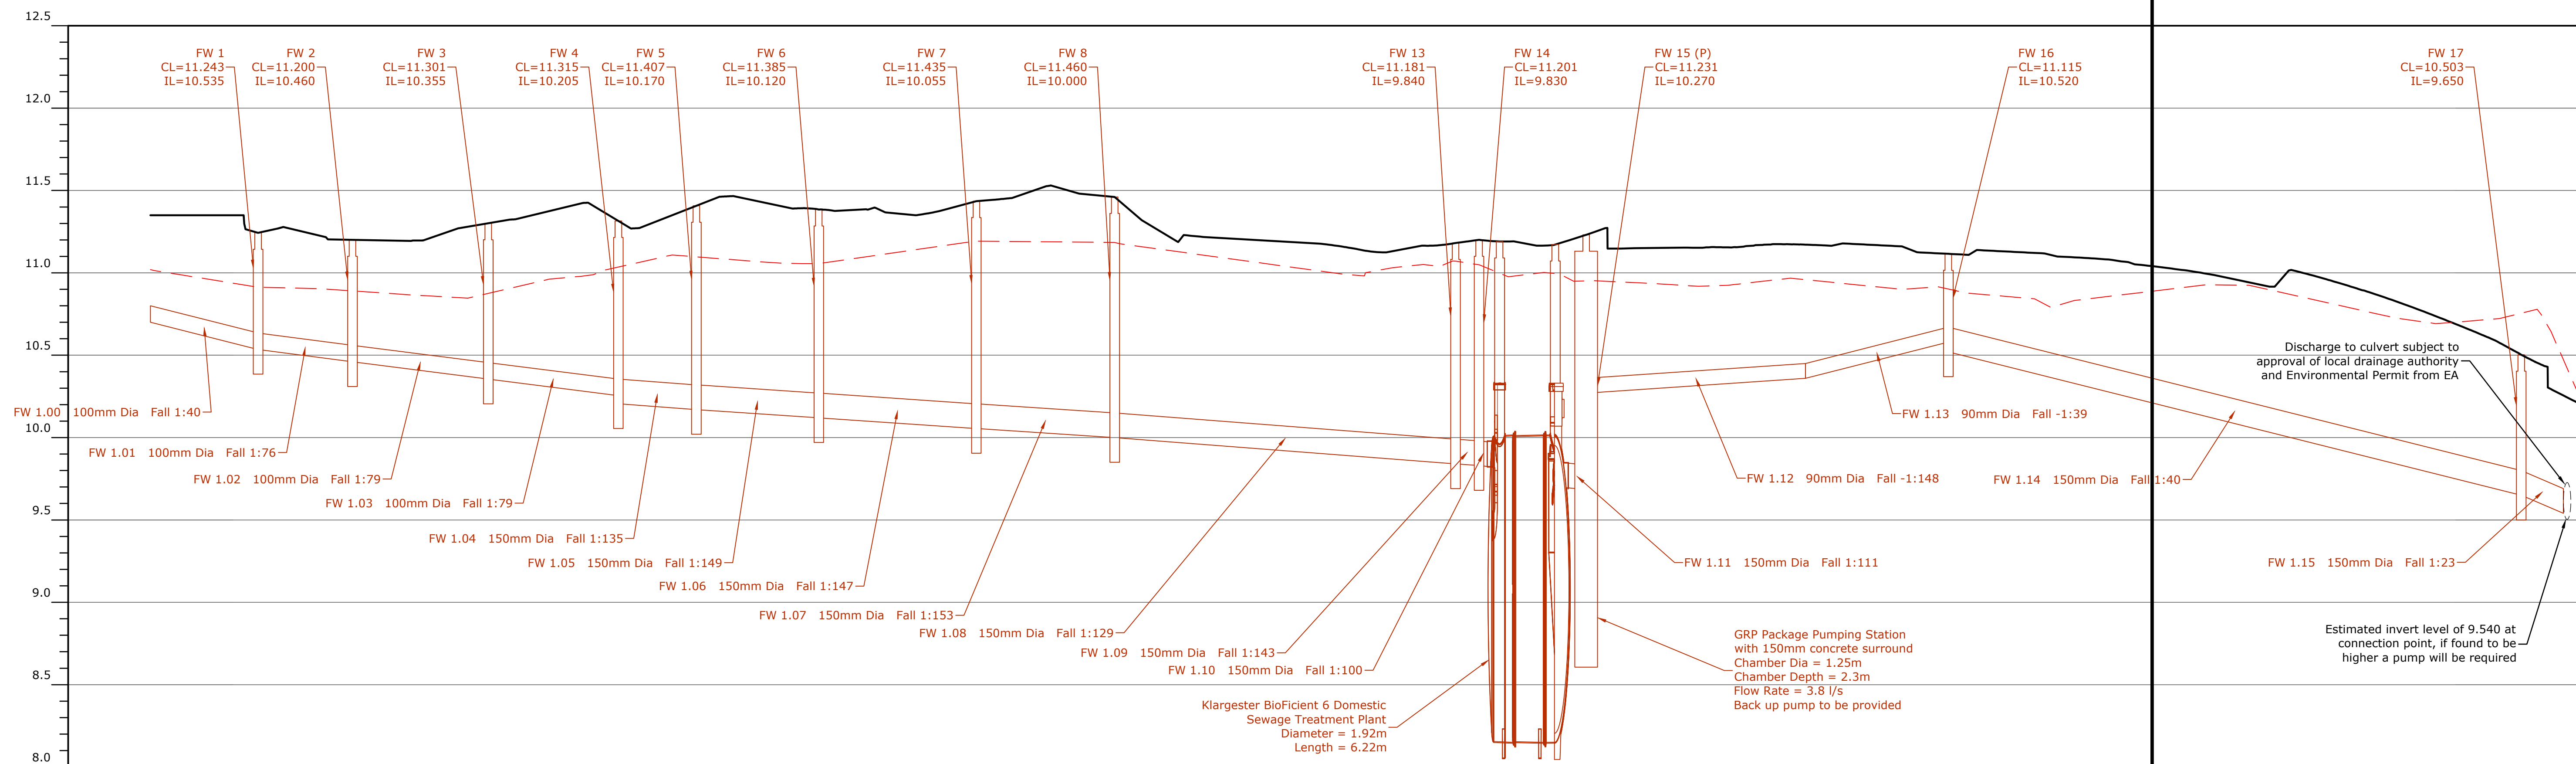

Foul Water Branch 9

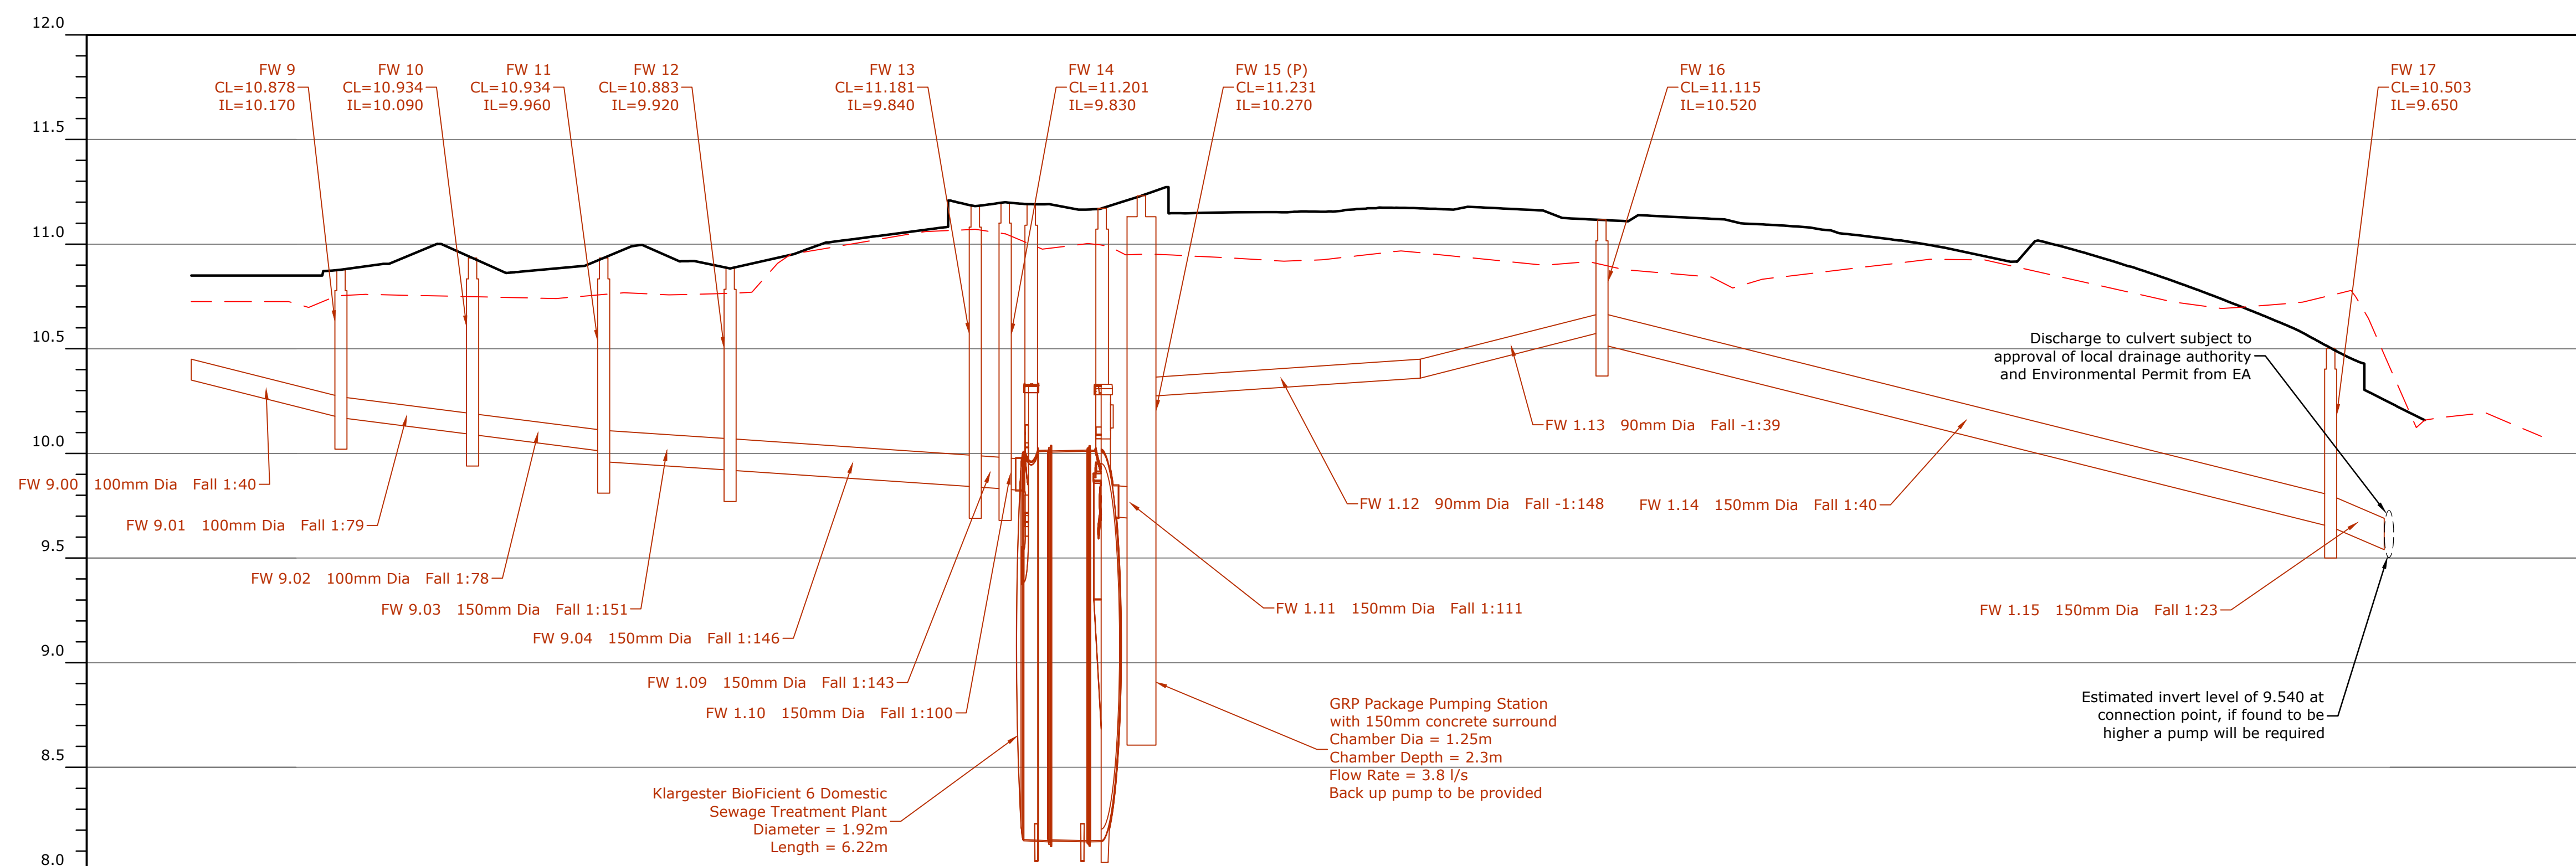

NOTES

FW 17
CL=10.503
IL=9.650

Discharge to culvert subject to approval of local drainage authority and Environmental Permit from EA

Fall 1:40

FW 1.15 150mm Dia Fall 1:23

Estimated invert level of 9.540 at connection point, if found to be higher a pump will be required

A	Revised to Client comments	RS	KBL	KBL	19/07/19
Rev	Amendment	Drawn	Checked	Approved	Date


LANMOR Consulting
 Civil Engineers & Transport Planning

Thorogood House, 34 Tolworth Close, Surbiton, Surrey, KT6 7EW
 Telephone: 0208 339 7899 Fax: 0208 339 7898
 e-mail: info@lanmor.co.uk
 www.lanmor.co.uk

Countyoak Homes Ltd

Dappers Lane Angmering

Drainage Layout Sewer Long Sections

Sheet 3 of 4

DRAWN	RS	CHECKED	KBL	APPROVED	KBL
DATE	Jul-19	DATE	Jul-19	DATE	Jul-19
SCALE	H 1:200 V 1:20	PRJ No.	191183	SIZE	REV
DWG No.	191183/520/01			A1	A