


DUAL UNRESTRICTED 24/7 ACCESS BRICK SUBSTATION


SUBSTATION CONSTRUCTION TO DRG NO - GTC-E-SS-0012

EARTHING ARRANGEMENT TO DRG NO
- 7963-EAR-01
- GTC-E-EA-0001
- GTC-E-EA-0003

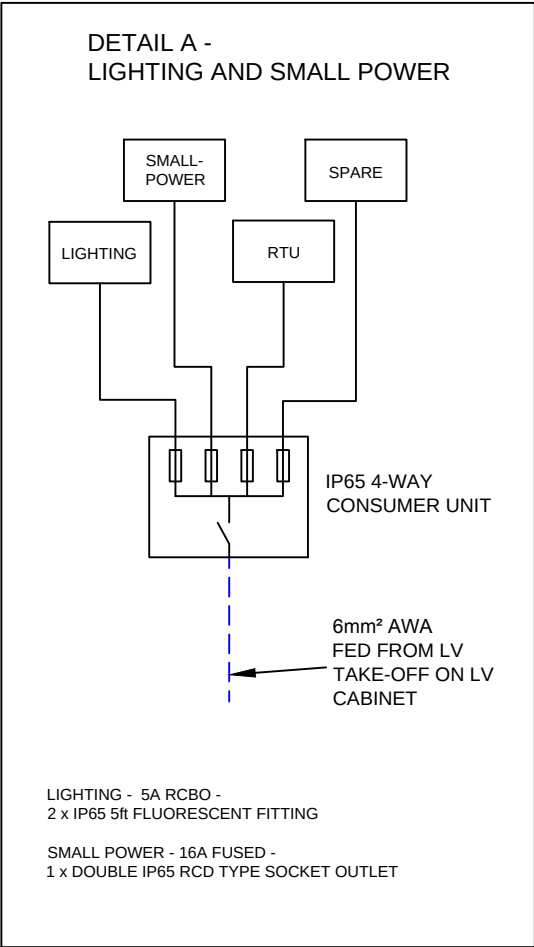

ADOPTED BY ENC

ADOPTED BY UKPN

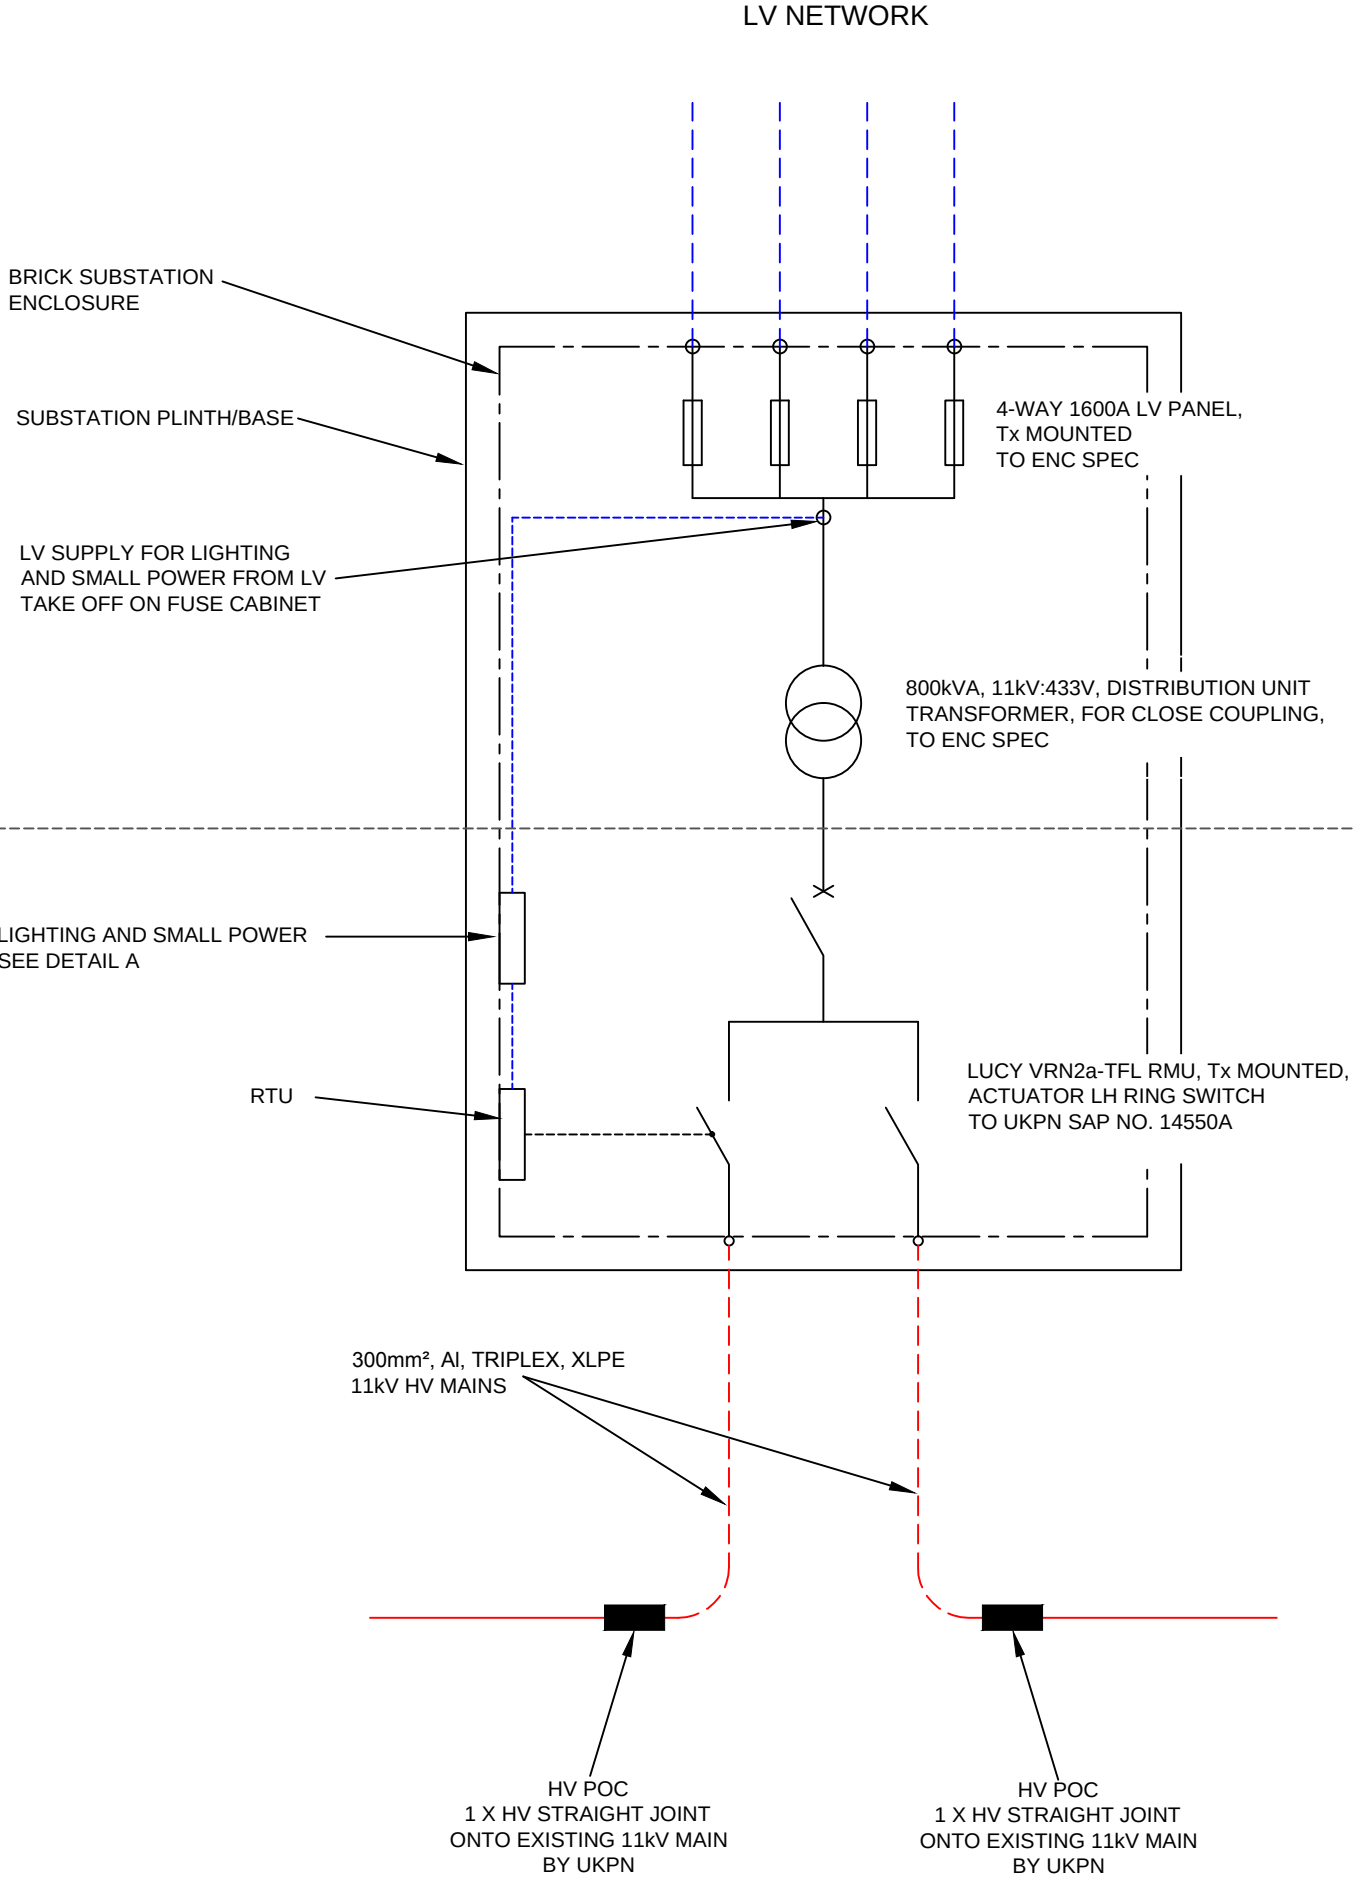

ADOPTED BY ENC

ADOPTED BY UKPN

A	FOR APPROVAL	20/10/2016	PA
REV	REVISION NOTES	DATE	ENG.
DESIGN APPROVED BY UK POWER NETWORKS 11-11-16 DESIGN APPROVED BY THE ELECTRICITY NETWORK CO 21-11-16			
Planning Drawing Only Obtain up-to-date utility records from asset owner before commencing work.			
The details supplied on this drawing are intended to be used for information only and are not representative of any binding or contractual agreement between R & D Network Design and any other parties involved. The positions of existing mains is given for guidance only and, as such, no liability can be accepted by R & D Network Design Ltd for any damage caused to, nor any injury sustained, as a result of interference with such apparatus. Before any onsite works commence an up to date copy of the relevant utilities records must be obtained.			
Design supplied for and on behalf of:			
TRICONNEX 4 Tamdown Way Braintree Essex CM7 2QL 01376 332680			
R&D networkdesign R & D Network Design Ltd Blue Pit Mill Queensway Rochdale OL11 2YW			
Client	TriConnex	Client Ref	X322
Site Address	WEST END NURSERY, ANGMERING, LITTLEHAMPTON		
Title	Single Line Diagram		
Drawn By	PA	Date	20/10/2016
Checked By	DS	Date	20/10/2016
Approved By		Date	
Scale	NTS @ A3		
Revision	A		
Drawing No	7963-SLD-01		