


DESIGN SUBJECT TO THE APPROVAL OF:
PLANNING AUTHORITY
BUILDING CONTROL
SOUTHERN WATER
WEST SUSSEX COUNTY COUNCIL

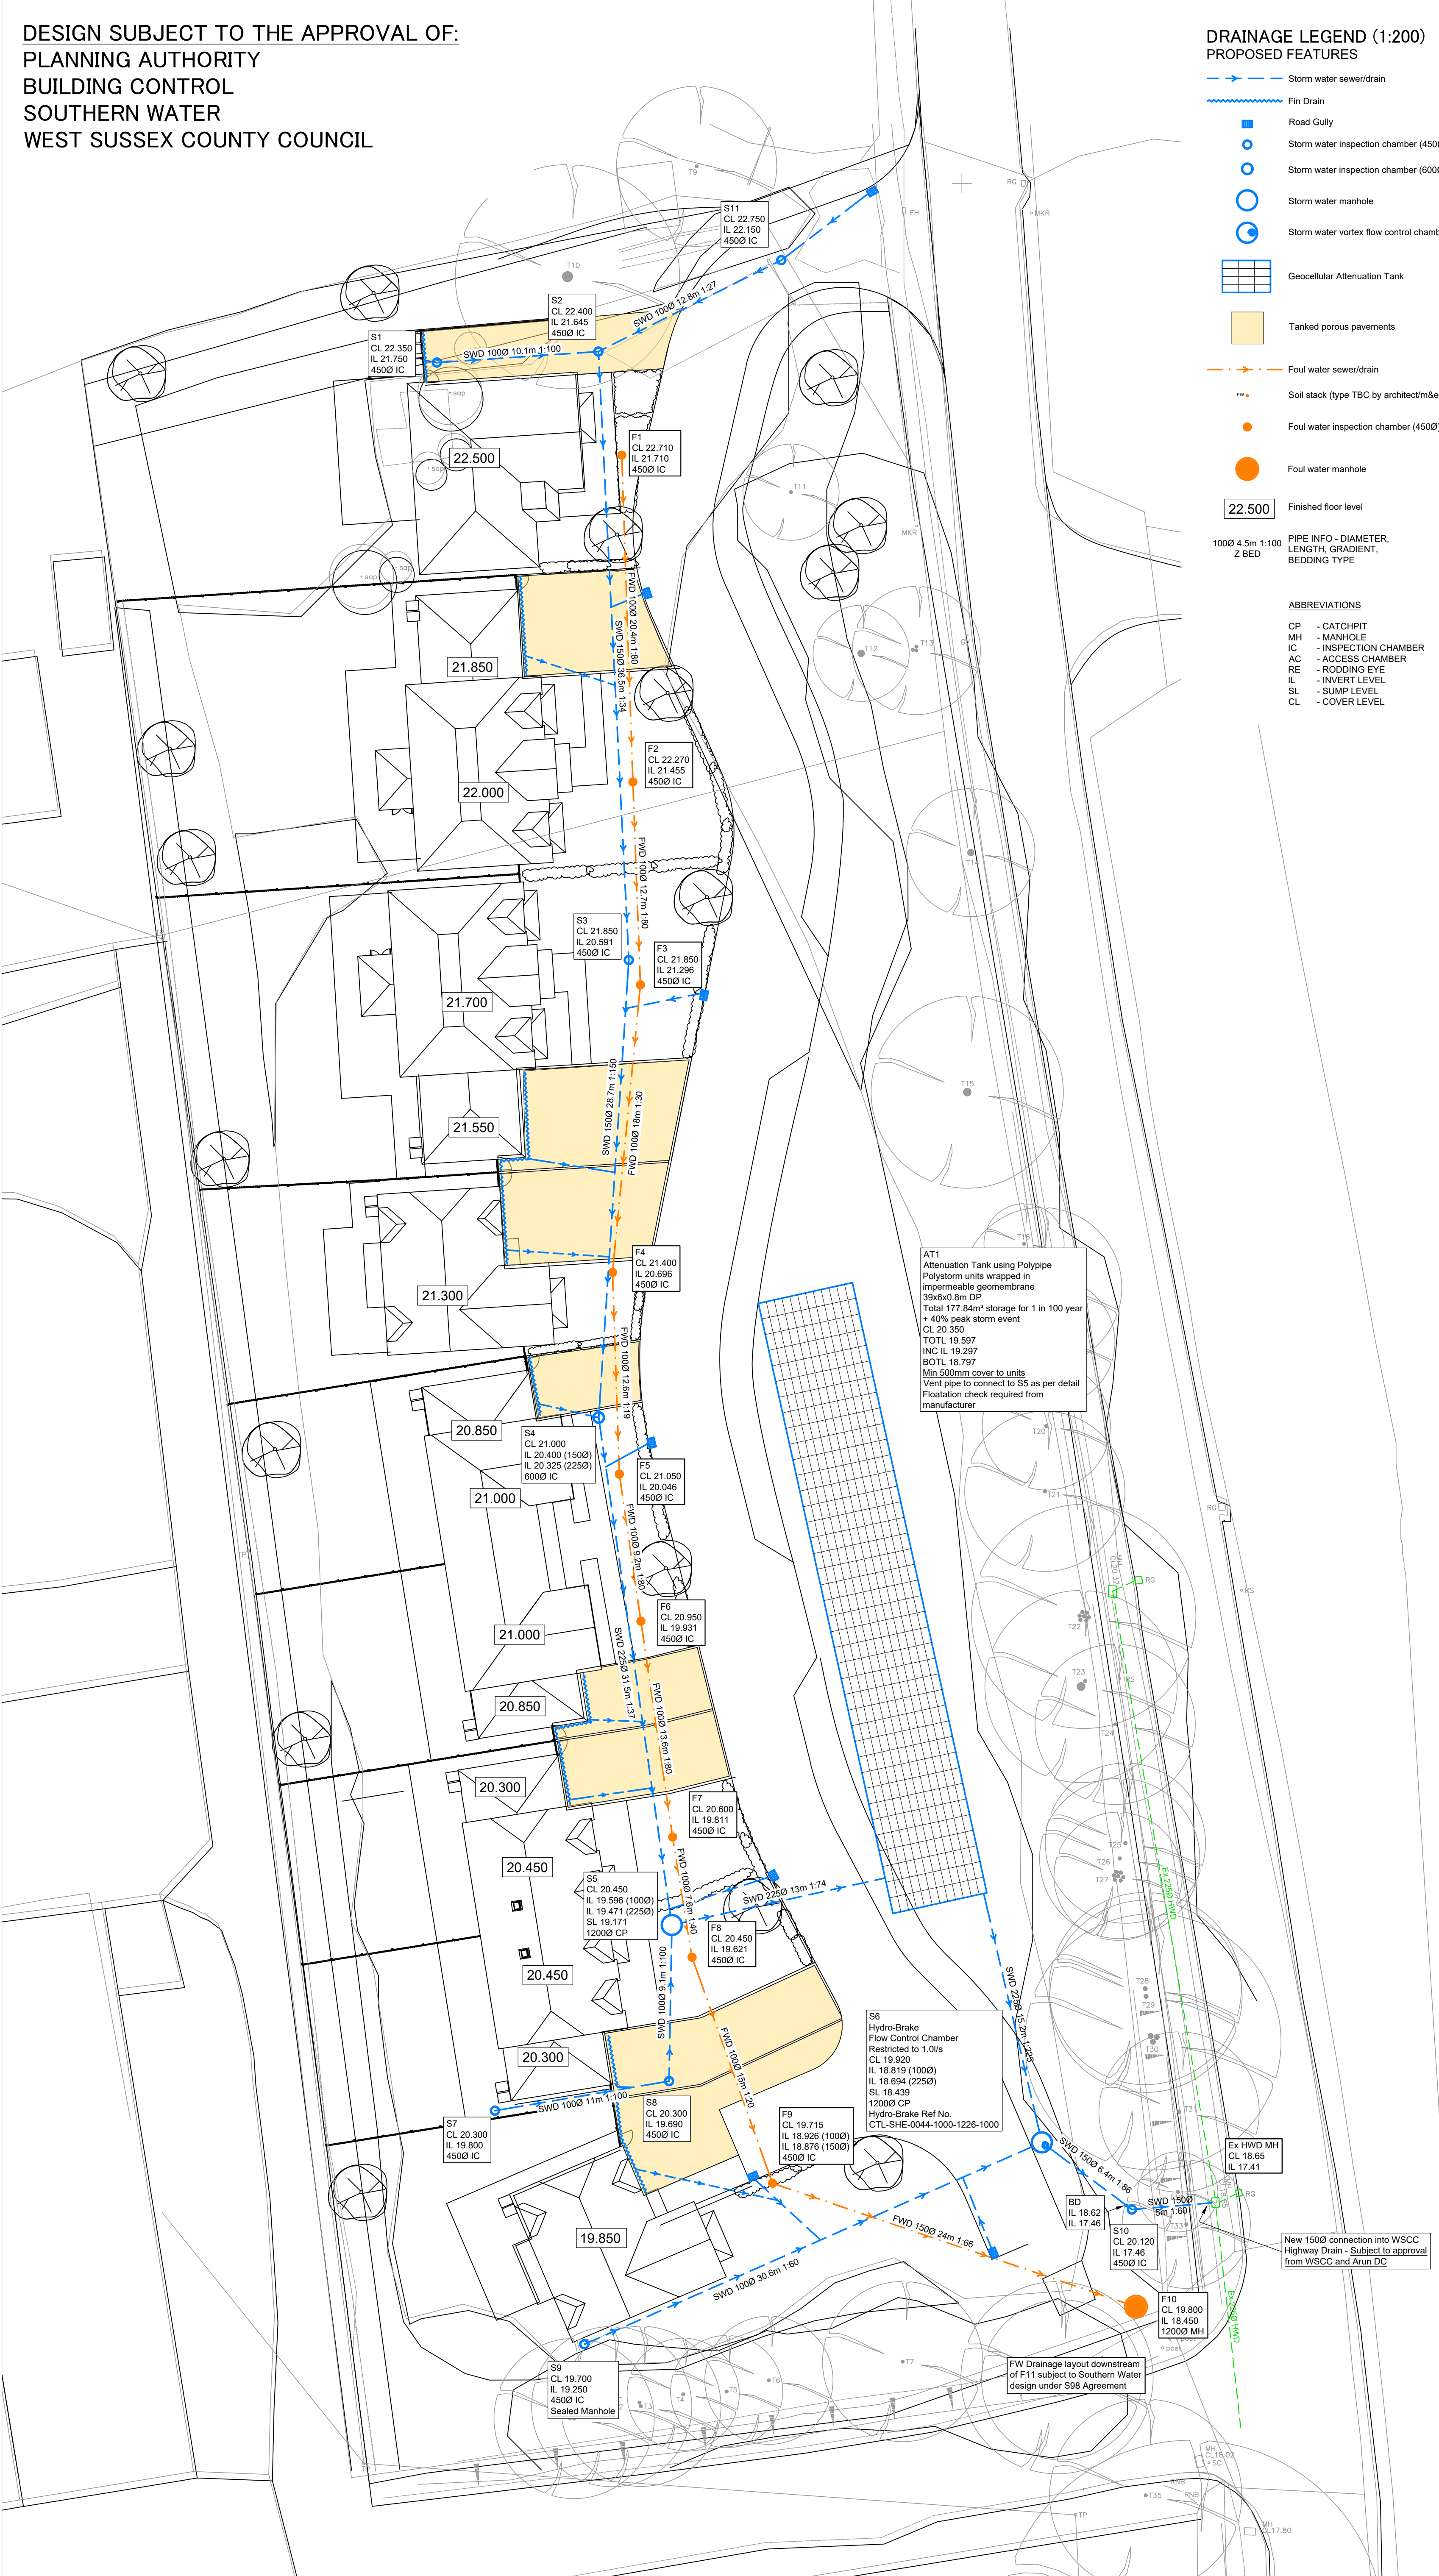

DRAINAGE LEGEND (1:200)
PROPOSED FEATURES

- Storm water sewer/drain
- Fin Drain
- Road Gully
- Storm water inspection chamber (4500)
- Storm water inspection chamber (6000)
- Storm water manhole
- Storm water vortex flow control chamber
- Geocellular Attenuation Tank
- Tanked porous pavements
- Foul water sewer/drain
- Soil stack (type TBC by architect/m&e engineer)
- Foul water inspection chamber (4500)
- Foul water manhole
- Finished floor level

1000 4.5m 1:100
Z BED


ABBREVIATIONS

- CP - CATCHPIT
- MH - MANHOLE
- IC - INSPECTION CHAMBER
- AC - ACCESS CHAMBER
- RE - RODDING EYE
- IL - INVERT LEVEL
- SL - SUMP LEVEL
- CL - COVER LEVEL

PIPE INFO - DIAMETER,
LENGTH, GRADIENT,
BEDDING TYPE

STANDARD DRAINAGE NOTES

- DO NOT SCALE FROM THIS DRAWING. REFER TO FIGURED DIMENSIONS ONLY. THE CONTRACTOR SHOULD CHECK ALL DIMENSIONS ON SITE.
- ALL DIMENSIONS IN MILLIMETRES AND ALL LEVELS ARE IN METERS UNLESS NOTED OTHERWISE.
- THIS DRAWING SHOULD BE READ IN CONJUNCTION WITH ALL OTHER RELEVANT ARCHITECT AND ENGINEERING DETAILS, DRAWINGS AND SPECIFICATIONS.
- ANY DISCREPANCIES SHOULD BE REPORTED TO THE ARCHITECT AND/OR ENGINEER IMMEDIATELY, SO THAT CLARIFICATION CAN BE SOUGHT PRIOR TO THE COMMENCEMENT OF WORK.
- BEFORE COMMENCING CONSTRUCTION THE CONTRACTOR MUST CHECK THE INVERT LEVELS OF EXISTING SEWERS TO WHICH CONNECTIONS ARE MADE. IN ADDITION THE CONTRACTOR MUST LOCATE AND DETERMINE INVERT LEVELS OF THE EXISTING SPURS TO WHICH CONNECTIONS ARE PROPOSED. ANY DISCREPANCIES ARE TO BE NOTIFIED TO THE ENGINEER IMMEDIATELY, PRIOR TO CONSTRUCTION.
- ALL DRAINAGE WORKS SHOULD COMMENCE AT THE PROPOSED DOWNSTREAM CONNECTION POINT. THE WORKS CONTINUING UPSTREAM FOLLOWING CONFIRMATION OF THE TIE-IN INVERT LEVELS TO THE ENGINEER. CONNECTIONS TO MANHOLES OR LARGER SIZED PIPES ETC. SHOULD BE SOFFIT TO SOFFIT UNLESS OTHERWISE INSTRUCTED BY THE ENGINEER. IF THIS IS NOT POSSIBLE INFORM THE ENGINEER IMMEDIATELY.
- COVER LEVELS SHOWN ARE APPROXIMATE. COVERS AND FRAMES SHALL BE SET TO FINISHED GROUND LEVELS AND FALLS.
- ALL UN-REFERENCED PIPES ARE ASSUMED TO BE 100mm DIA.
- ALL PIPES TO BE ADOPTED, OR CONNECTING TO ADOPTED SEWERS, TO BE VITRIFIED CLAY TO BS EN 295 AND BS65 (SWS ONLY), OR CONCRETE PIPES TO BE EN 1916 AND BS5911-PART 1.
- ROAD GULLY OUTLET PIPES ARE TO BE 150mm DIA. WITH CONCRETE SURROUND AND FLEXIBLE JOINTS. ALL GULLIES SHALL BE FITTED WITH GRADE D400 GRATINGS AND FRAMES TO BS EN124, UNLESS OTHERWISE STATED.
- ALL ADOPTABLE SEWERS SHALL BE CONSTRUCTED TO THE STANDARDS AND SPECIFICATION LAID DOWN IN 'SEWERS FOR ADOPTION' 6th EDITION, WITH A VIEW TO ADOPTION UPON COMPLETION OF WORKS.
- ALL PRIVATE DRAINAGE TO BE IN ACCORDANCE WITH THE BUILDING REGULATIONS APPROVED DOCUMENT PART-H AND TO THE SATISFACTION OF THE BUILDING CONTROL INSPECTOR.
- THE CONTRACTOR IS TO KEEP A RECORD OF ANY VARIATIONS MADE ON SITE, INCLUDING THE RELOCATION OF SEWERS OR DRAINS, SO THAT AN AS CONSTRUCTED DRAWING CAN BE PREPARED UPON COMPLETION OF THE PROJECT.
- STUB CONNECTIONS TO ADOPTABLE MANHOLES SHALL BE MADE FROM VITRIFIED CLAY AND CONSIST OF TWO ROCKER PIPES LAID AT THE SAME GRADIENT AS THE UP OR DOWNSTREAM PIPE.
- IF ANY SUB SOIL DRAINAGE SYSTEMS ARE UNCOVERED DURING THE WORKS CONTACT THE ENGINEER FOR INSTRUCTIONS. SUB SOIL DRAINS ARE TO BE DIVERTED AROUND NEW WORKS AND CONNECTED INTO THE SURFACE WATER.
- ALL EXISTING MANHOLE COVERS, GULLIES, ETC. ARE TO BE RAISED/LOWERED TO SUIT NEW LEVELS.

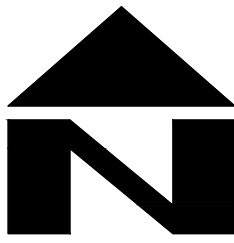

01

P2	17.02.20	UPDATED TO SUIT NEW SITEPLAN	LH	CS	CS
P1	07.01.20	CONNECTION TO HWD INDICATED	LH	CS	CS
P	16.01.20	PRELIMINARY ISSUE	LH	CS	CS
REV	DATE	DESCRIPTION	BY	CHK	APP

 Consulting Civil Engineers					
CLIENT GD GROUP					
ARCHITECT CITYZEN					
JOB TITLE ARUNDEL ROAD ANGMERING					
DRAWING TITLE DRAINAGE LAYOUT					
DRAWN LH	ENGINEER CS	CHECKED CS	APPROVED		
DATE NOVEMBER 2019	SCALE @ A1 1:200				
JOB NO. C1276	STATUS P	DRAWING No. 100	REV. P2		

PRELIMINARY