




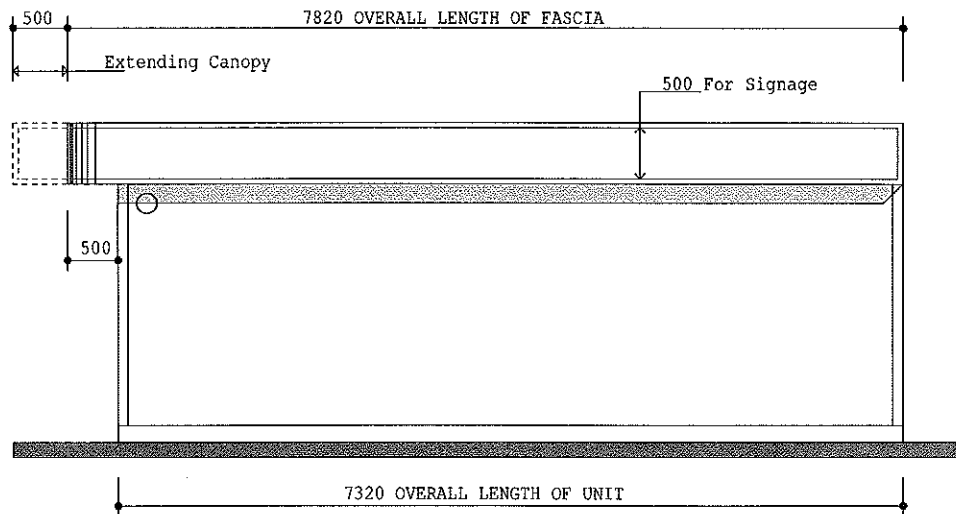


SIDE ELEVATION

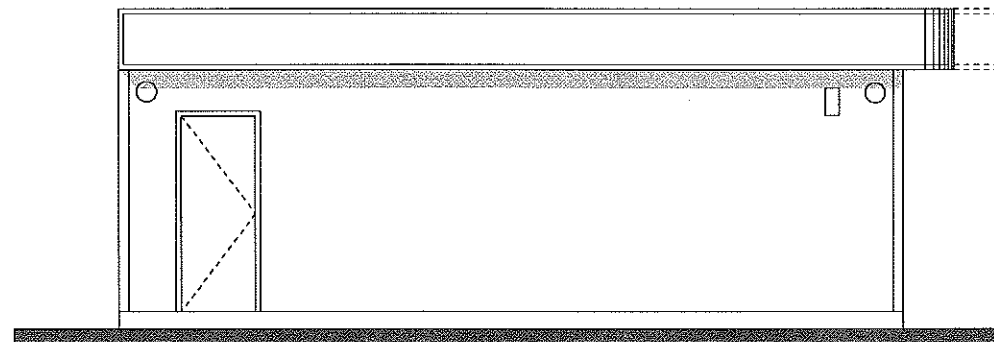

SIDE ELEVATION

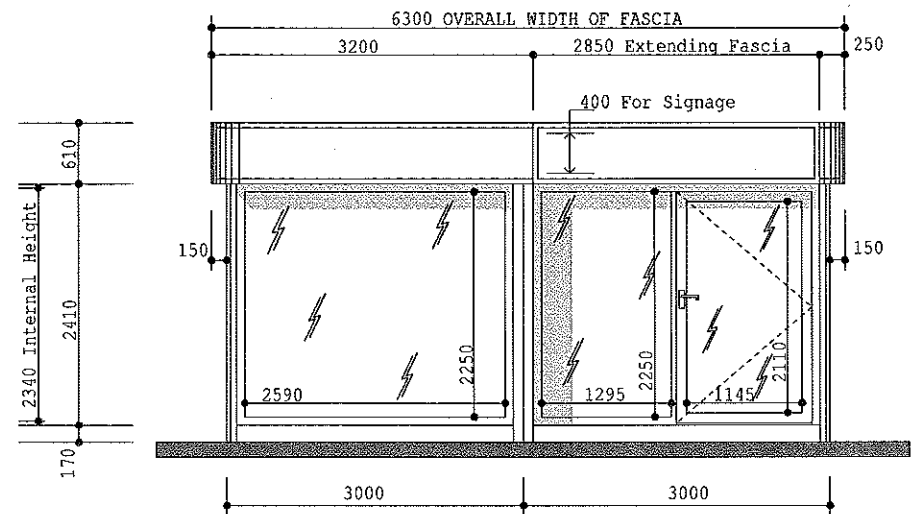

FRONT ELEVATION

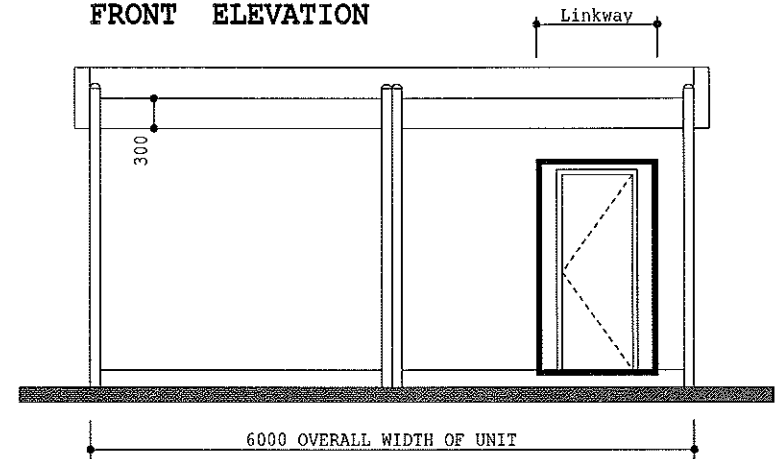

REAR ELEVATION

1		2		3		4		5		6		7		8		9		Scale 1:50
TITLE																		NOTES
TEL/FAX LGCHA061																		
CONTRACT																		
DRAWING No 02 DATE DRAWN BY																		
REVISION No																		KEY
Single switched socket Two switched sockets Switched fused spur 30A socket point Cable Light Fluorescent light fitting																		
Light switch Light switch cord Extractor fan Condenser unit Heater																		
Power Panel On/Off Control Box Phone Alarm Button Cable Mounted recessed light																		

