


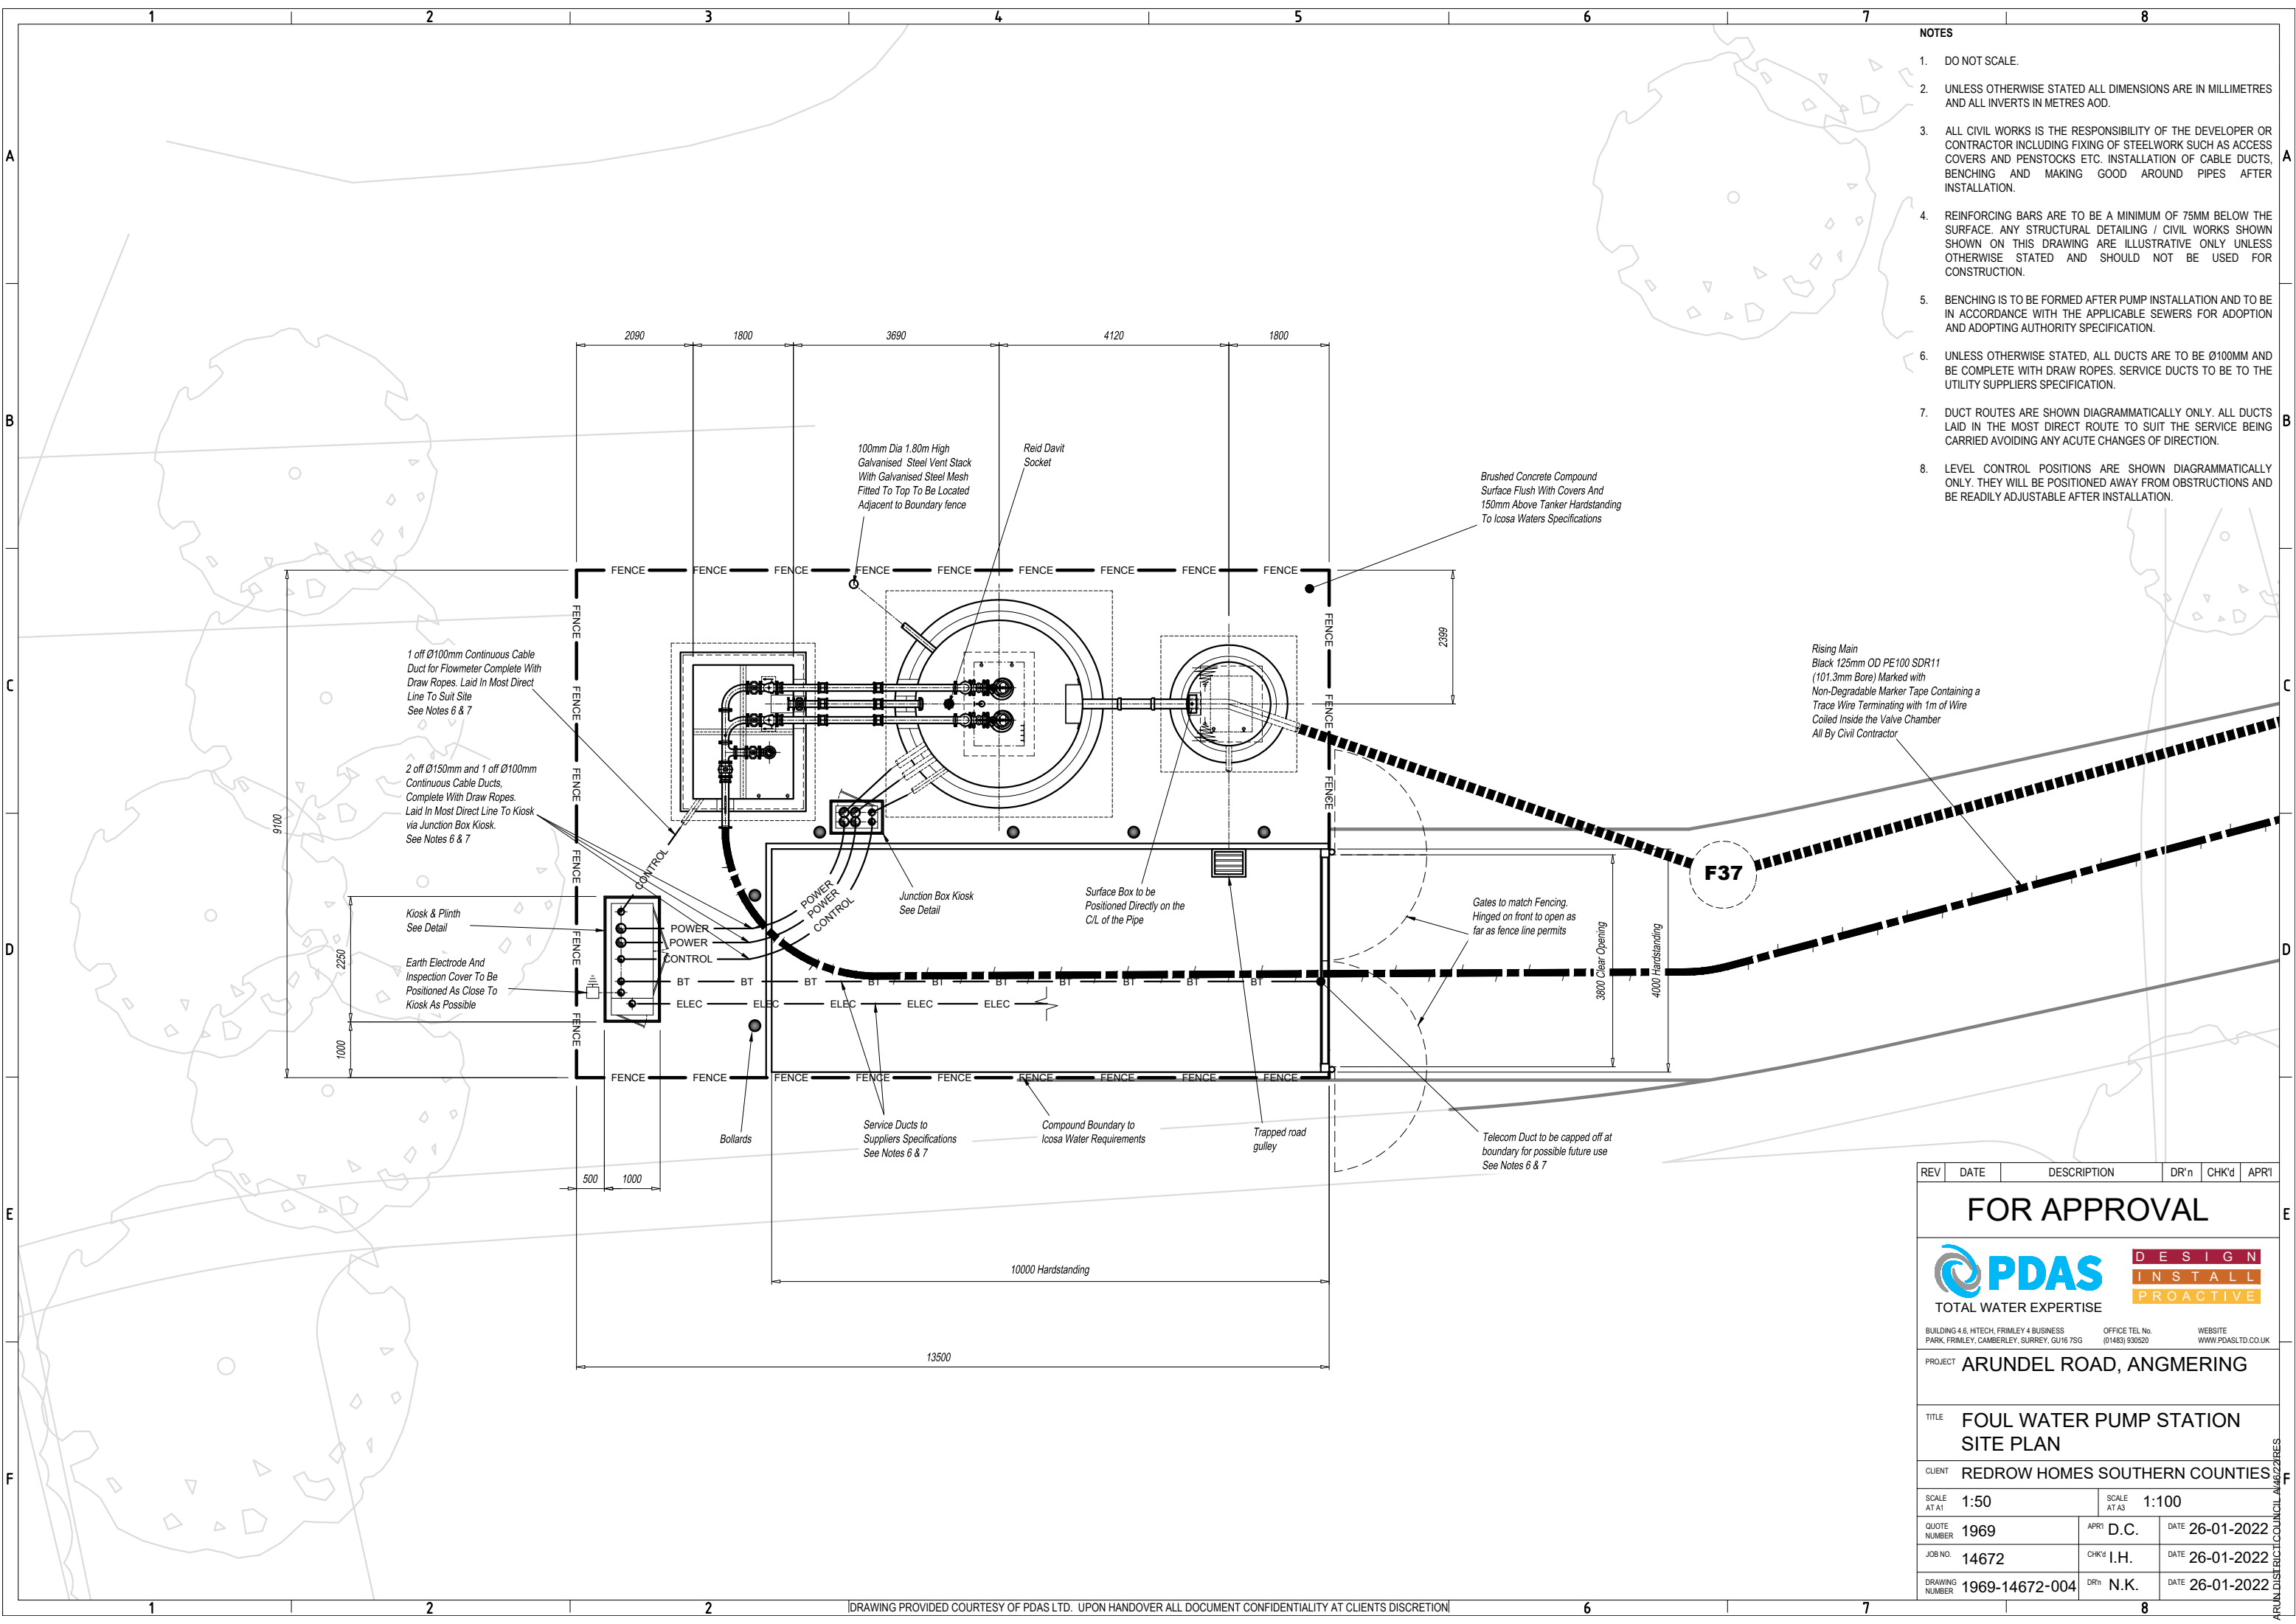

- NOTES
- DO NOT SCALE.
 - UNLESS OTHERWISE STATED ALL DIMENSIONS ARE IN MILLIMETRES AND ALL INVERTS IN METRES AOD.
 - ALL CIVIL WORKS IS THE RESPONSIBILITY OF THE DEVELOPER OR CONTRACTOR INCLUDING FIXING OF STEELWORK SUCH AS ACCESS COVERS AND PENSTOCKS ETC. INSTALLATION OF CABLE DUCTS, BENCHING AND MAKING GOOD AROUND PIPES AFTER INSTALLATION.
 - REINFORCING BARS ARE TO BE A MINIMUM OF 75MM BELOW THE SURFACE. ANY STRUCTURAL DETAILING / CIVIL WORKS SHOWN SHOWN ON THIS DRAWING ARE ILLUSTRATIVE ONLY UNLESS OTHERWISE STATED AND SHOULD NOT BE USED FOR CONSTRUCTION.
 - BENCHING IS TO BE FORMED AFTER PUMP INSTALLATION AND TO BE IN ACCORDANCE WITH THE APPLICABLE SEWERS FOR ADOPTION AND ADOPTING AUTHORITY SPECIFICATION.
 - UNLESS OTHERWISE STATED, ALL DUCTS ARE TO BE Ø100MM AND BE COMPLETE WITH DRAW ROPES. SERVICE DUCTS TO BE TO THE UTILITY SUPPLIERS SPECIFICATION.
 - DUCT ROUTES ARE SHOWN DIAGRAMMATICALLY ONLY. ALL DUCTS LAID IN THE MOST DIRECT ROUTE TO SUIT THE SERVICE BEING CARRIED AVOIDING ANY ACUTE CHANGES OF DIRECTION.
 - LEVEL CONTROL POSITIONS ARE SHOWN DIAGRAMMATICALLY ONLY. THEY WILL BE POSITIONED AWAY FROM OBSTRUCTIONS AND BE READILY ADJUSTABLE AFTER INSTALLATION.

REV	DATE	DESCRIPTION	DR'n	CHK'd	APR'l
FOR APPROVAL					
		DESIGN INSTALL PROACTIVE			
TOTAL WATER EXPERTISE					
BUILDING 4 & 5, ITECH, FRIMLEY 4 BUSINESS PARK, FRIMLEY, CAMBERLEY, SURREY, GU16 7SG			OFFICE TEL No. (01483) 930520		WEBSITE WWW.PDASLTD.CO.UK
PROJECT ARUNDEL ROAD, ANGMERING					
TITLE FOUL WATER PUMP STATION SITE PLAN					
CLIENT REDROW HOMES SOUTHERN COUNTIES					
SCALE AT A1 1:50		SCALE AT A3 1:100			
QUOTE NUMBER 1969	APR'l D.C.	DATE 26-01-2022			
JOB NO. 14672	CHK'd I.H.	DATE 26-01-2022			
DRAWING NUMBER 1969-14672-004	DR'n N.K.	DATE 26-01-2022			