


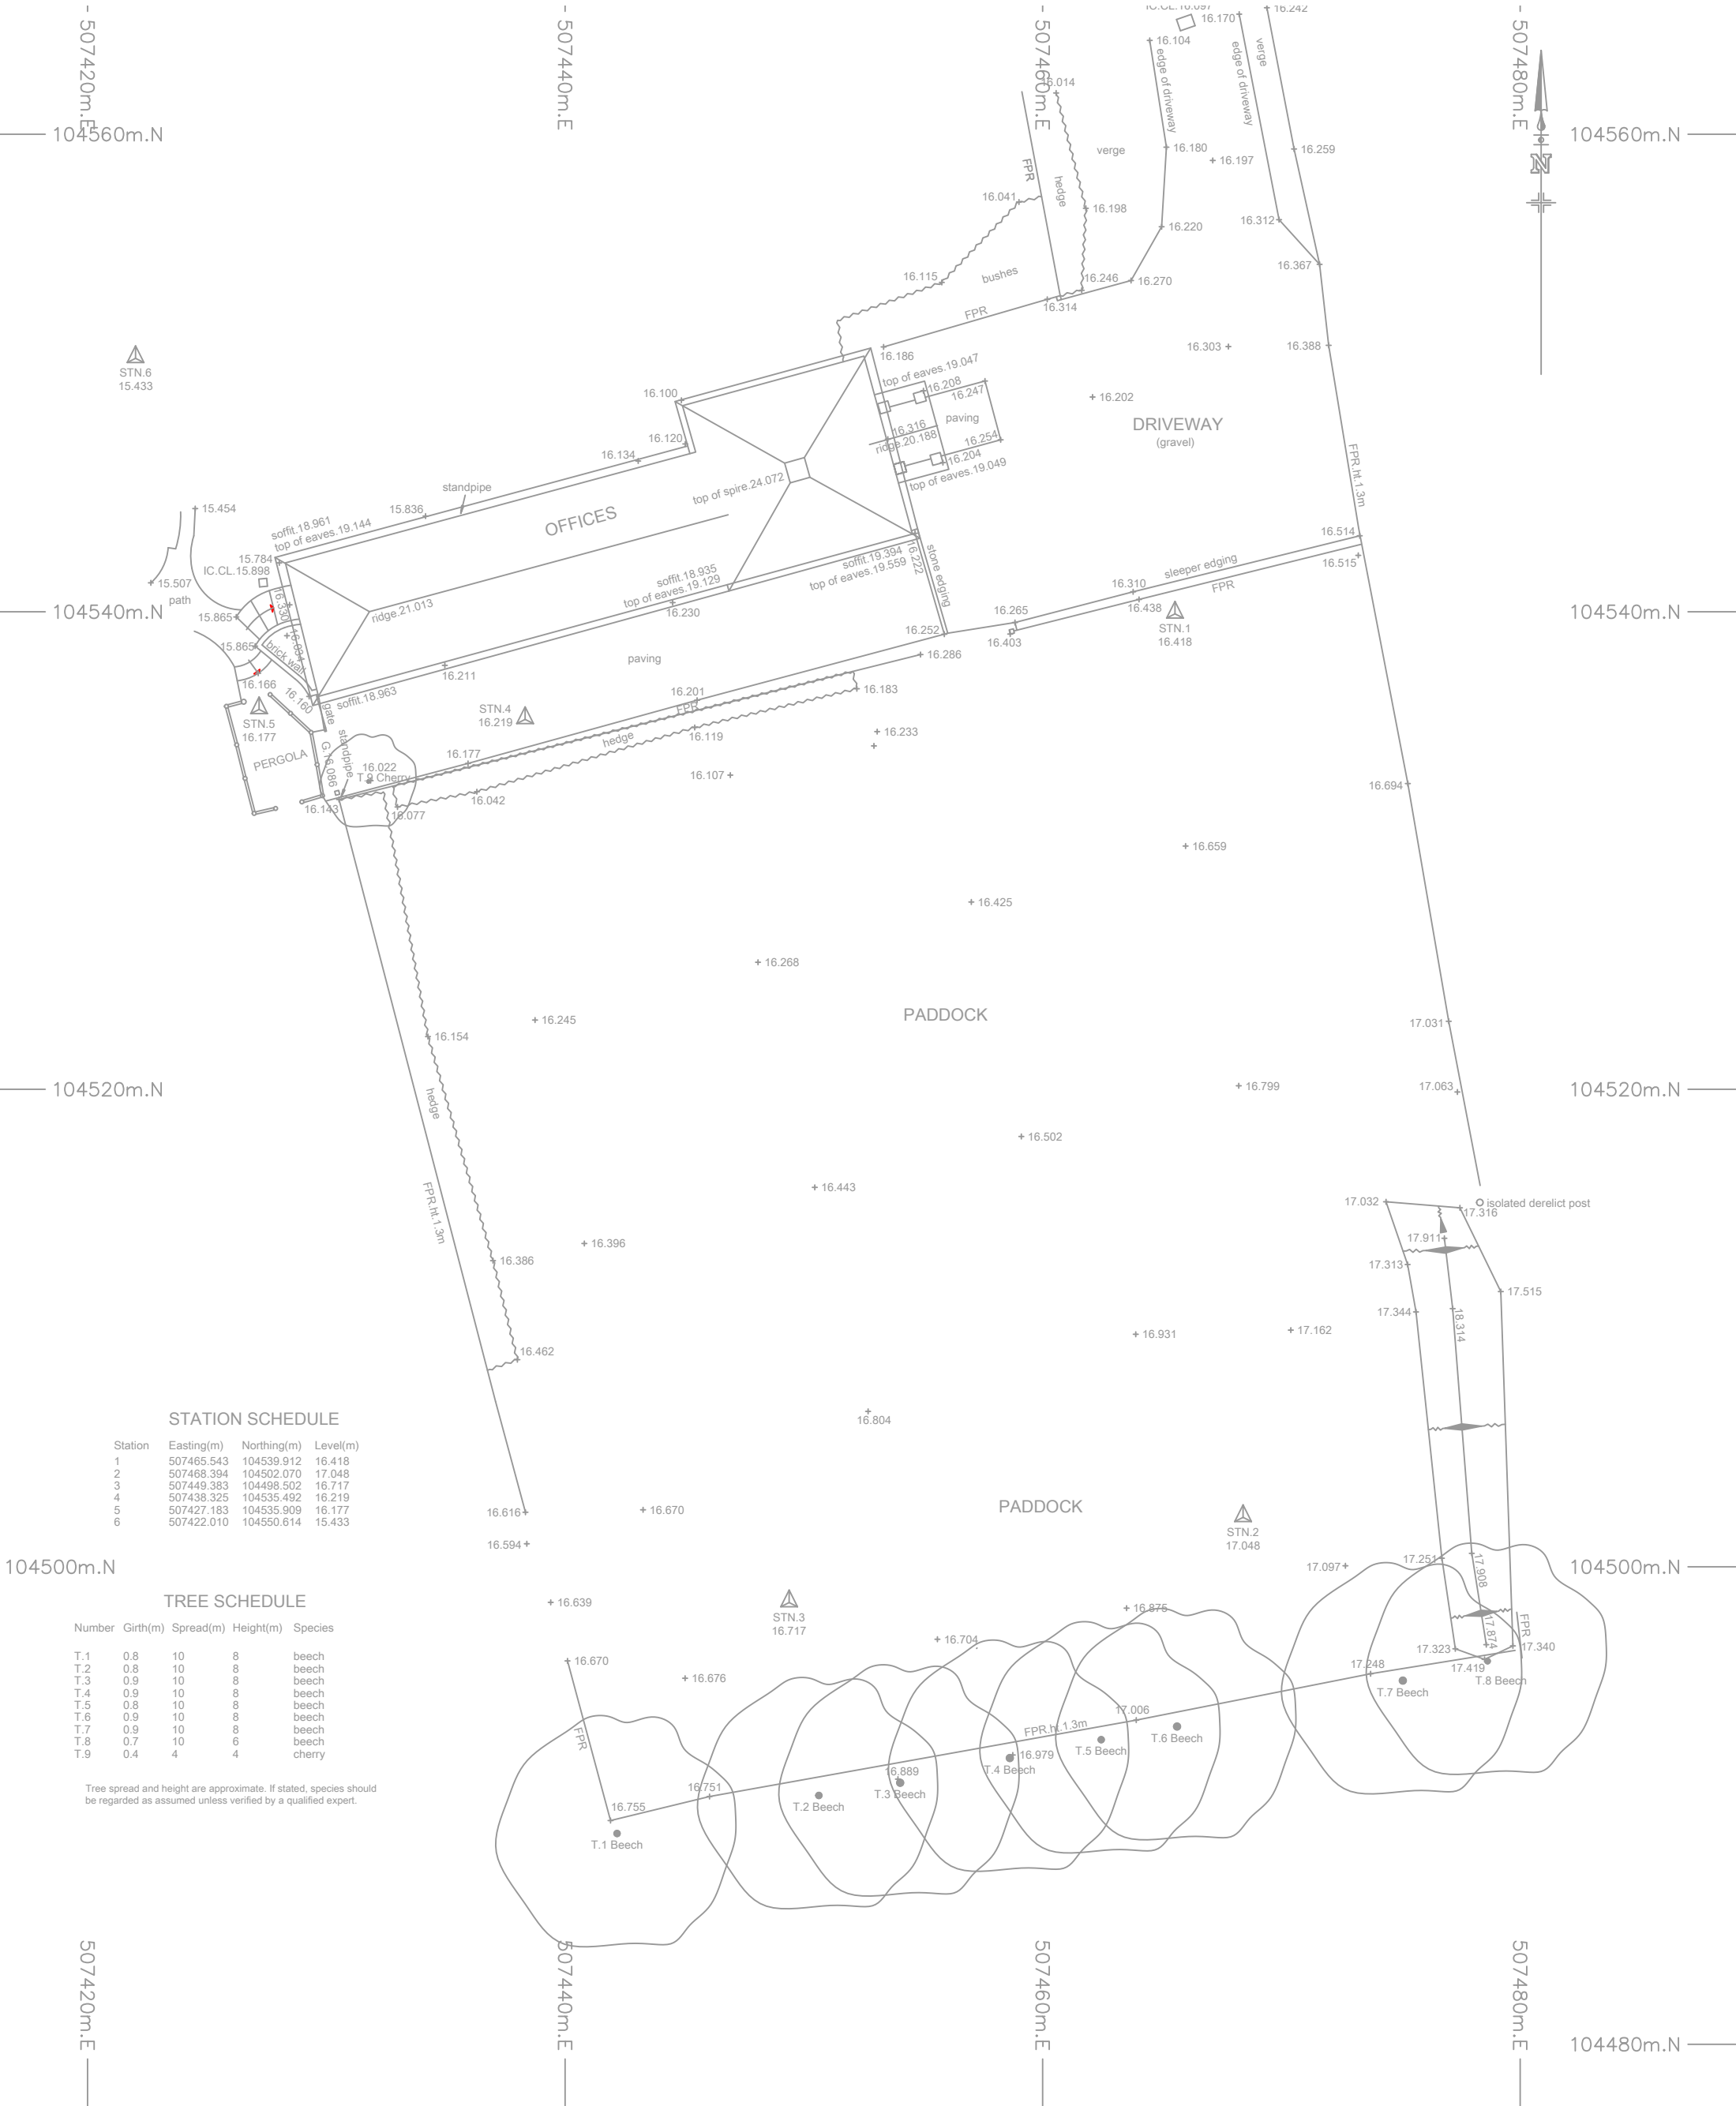

STATION SCHEDULE			
Station	Easting(m)	Northing(m)	Level(m)
1	507465.543	104539.912	16.418
2	507468.394	104502.070	17.048
3	507449.383	104498.502	16.717
4	507438.325	104535.492	16.219
5	507427.183	104535.909	16.177
6	507422.010	104550.614	15.433

TREE SCHEDULE				
Number	Girth(m)	Spread(m)	Height(m)	Species
T.1	0.8	10	8	beech
T.2	0.8	10	8	beech
T.3	0.9	10	8	beech
T.4	0.9	10	8	beech
T.5	0.8	10	8	beech
T.6	0.9	10	8	beech
T.7	0.9	10	8	beech
T.8	0.7	10	6	beech
T.9	0.4	4	4	cherry

Tree spread and height are approximate. If stated, species should be regarded as assumed unless verified by a qualified expert.

Chartered Surveyors

Copyright © 1917

Offington Land Surveys Ltd

29 Offington Drive

Worthing

West Sussex BN14 9PW

Tel/fax 01903 267883

ARUN DISTRICT COUNCIL A75/17/PL

surveyors@offington.com

Job

AVENALS FARM

WATER LANE

ANGMERING

BN16 4EP

Drawing No.

15090117 Site Plan

Client

MR C CHAPMAN

Survey Date(s)

18/01/2017

Surveyor

ST

Drafted by

JW

Checked by

ST

STANDARD REFERENCE

Datum Used Newlyn

Survey translated to ODN & OSGB36(15) by non-scaled best fit to GNSS RTK of controls (GNSS accuracy +/- 50mm rmse).

Survey Station Shown Thus:

Foul Water Drainage

Storm Water Drainage

Water Mains

Gas Mains

Electricity Cable

British Telecom Cable

True north direction shown is indicative only.

The details shown hereon relating to all underground services are as obtained by normal above-ground survey observation and methods and where indicated also by reference to available utility records. Although all reasonable efforts have been made no guarantee can be given for the completeness or accuracy of this information.

ABBREVIATIONS

AV Air Valve

BL Bed Level

BT British Telecom IC

CATV Television Cable Pit

CB Concrete Bollard

CE Cleaning Eye

CL Cover Level

CM Cable Marker

CP Catch Pit

dp Depth

ECP Electricity Cable Pit

EP Electricity Pole

ER Earth Rod

FA Fire Alarm

FH Fire Hydrant

FL Floor Level

FP Footpath

G Gully

IC Inspection Cover

FENCES

FCB Close Boarded

FCL Chain Link

FCP Chestnut Paling

FCW Chicken Wire

FIR Iron Railings

FPK Picket

IL Invert Level

LP Lamp Post

MH Manhole

MP Marker Post

OHC Overhead Cable

PVM Permit Vending Machine

RG Road Gully

RS Road Sign

RWP Rain Water Pipe

SC Stop Cock

SH Service Housing

SV Stop Valve

SVP Soil & Vent Pipe

SW Storm Water

TP Telegraph Pole

VP Vent Pipe

WM Water Meter

WO Water Wash Out

FPal Metal Palisade

FPan Panel

FPR Post & Rail

FPW Post & Wire

FTT Trellis

SCALE

Plot Scale: 1:250

Sheet Size: A3 Portrait

Sheet: 1 of 1

If printing a PDF version, to retain scale please ensure print options are selected for 100% original size / no scaling / no shrink to fit, as appropriate.

0m 10m

SCALE BAR

VERSION HISTORY

Version	Date	Description
1.0	23/01/2017	Original Version