

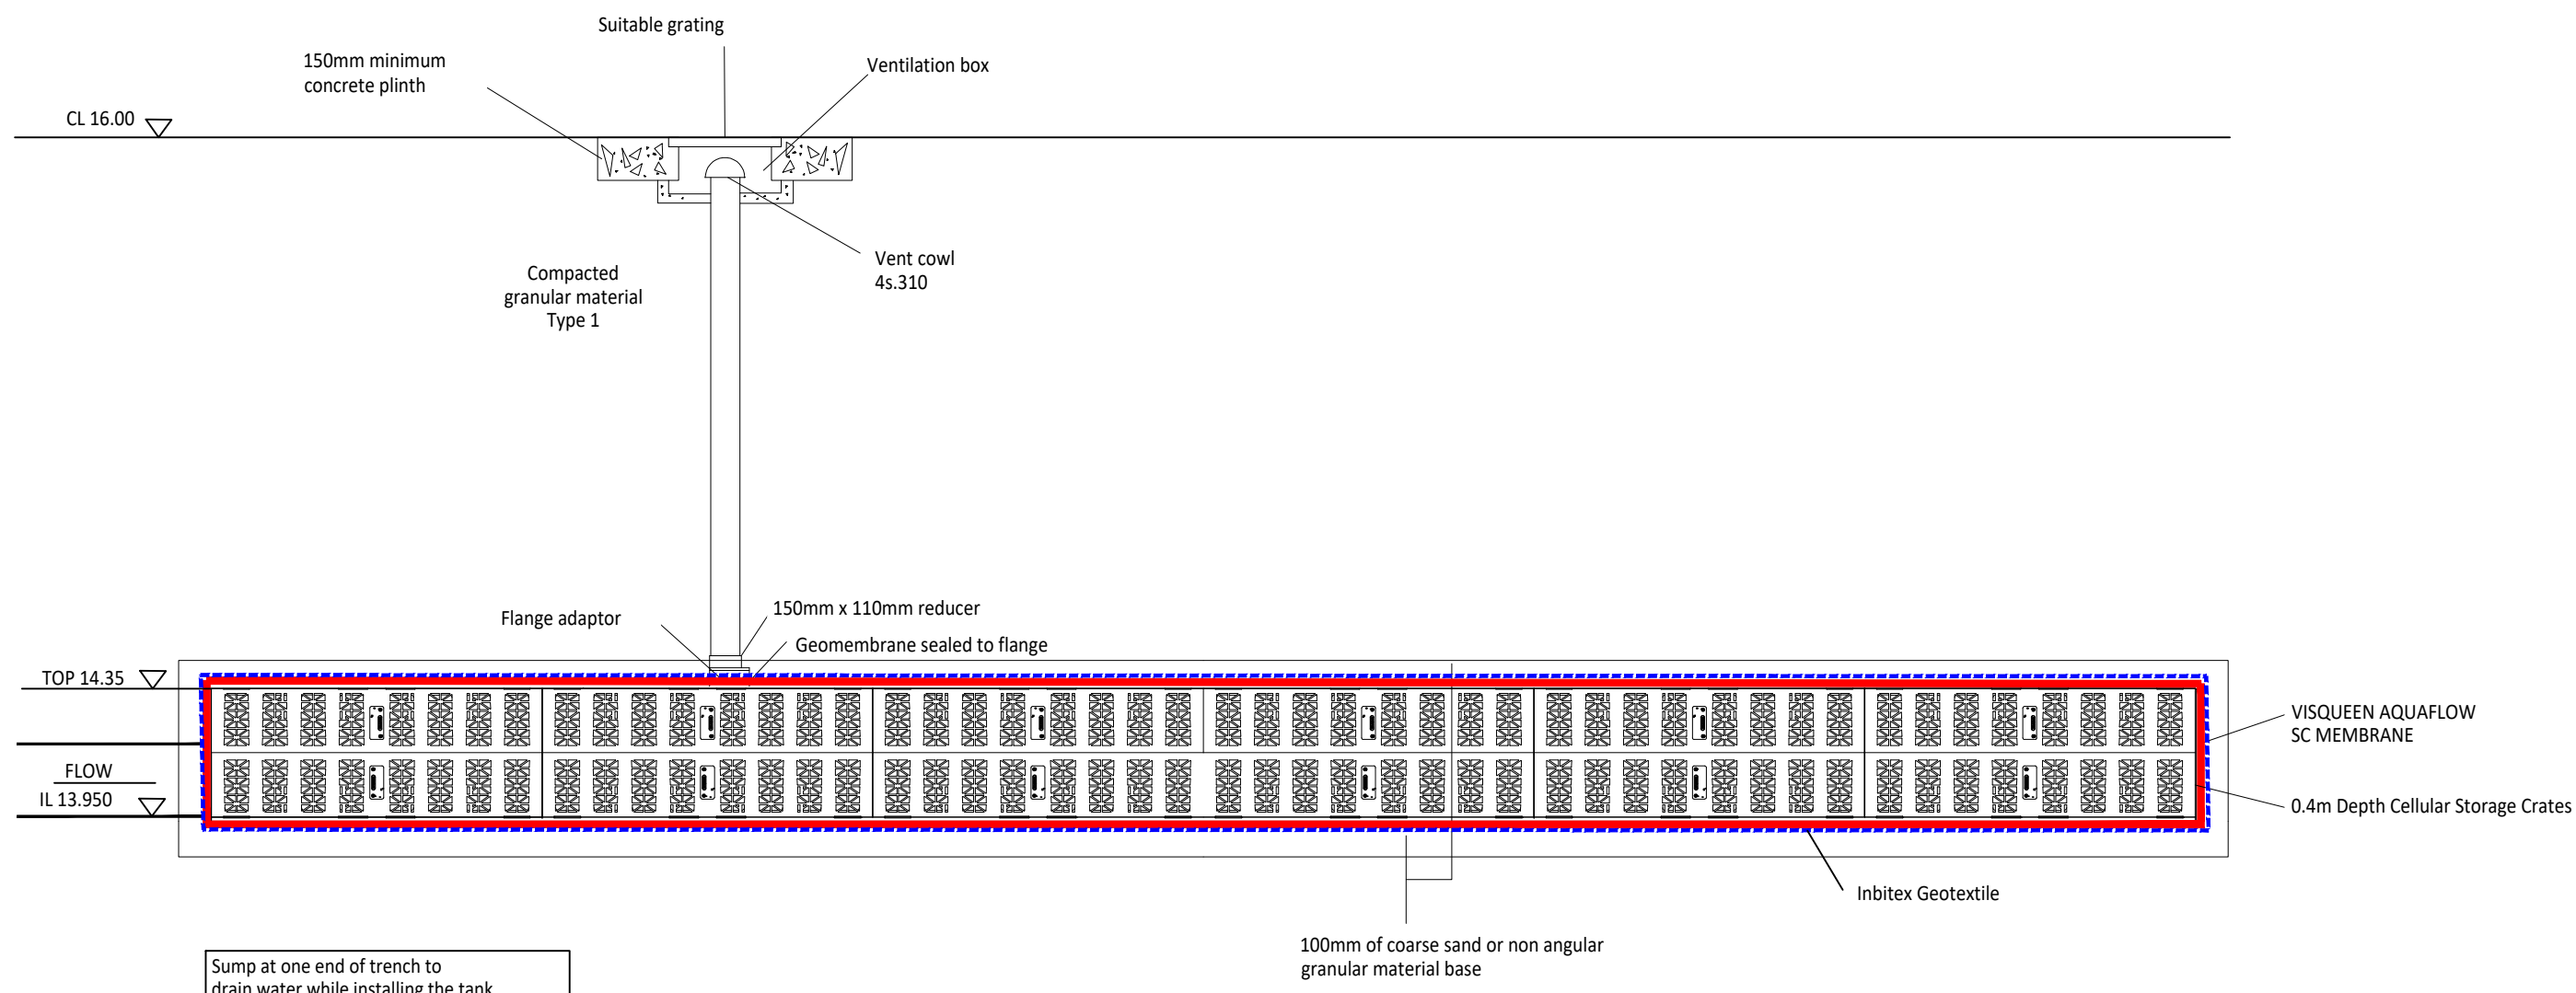
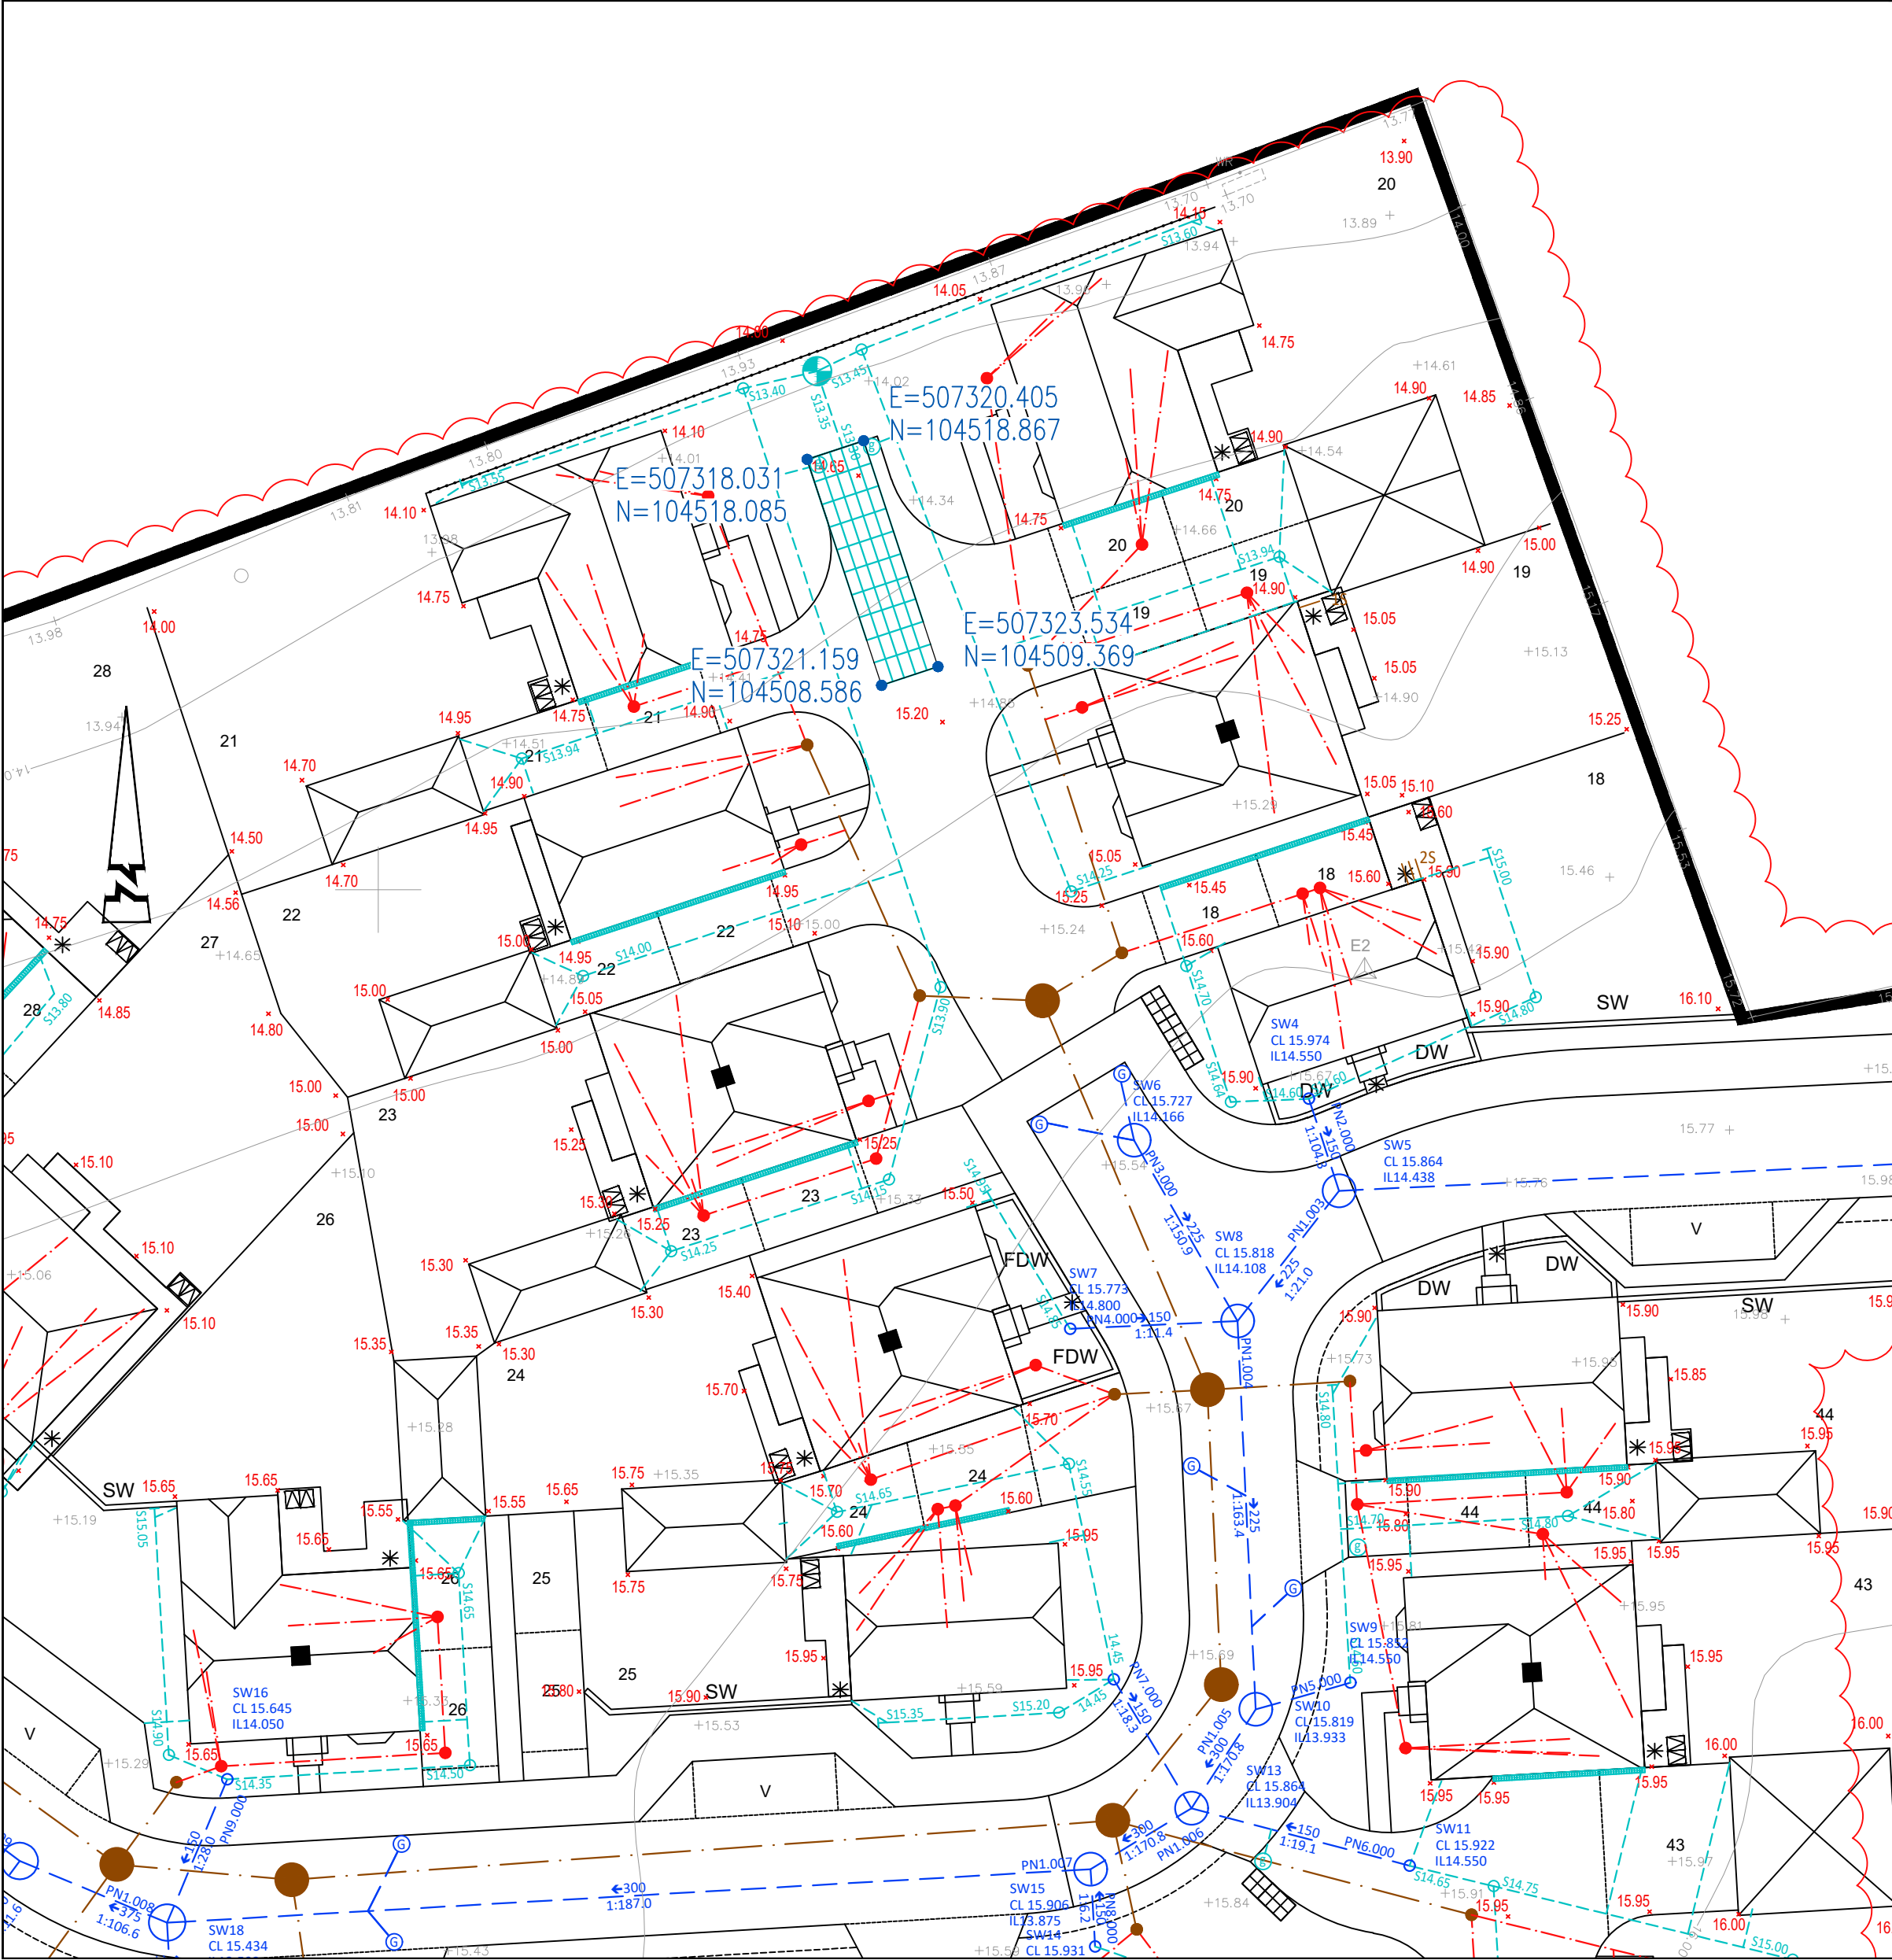


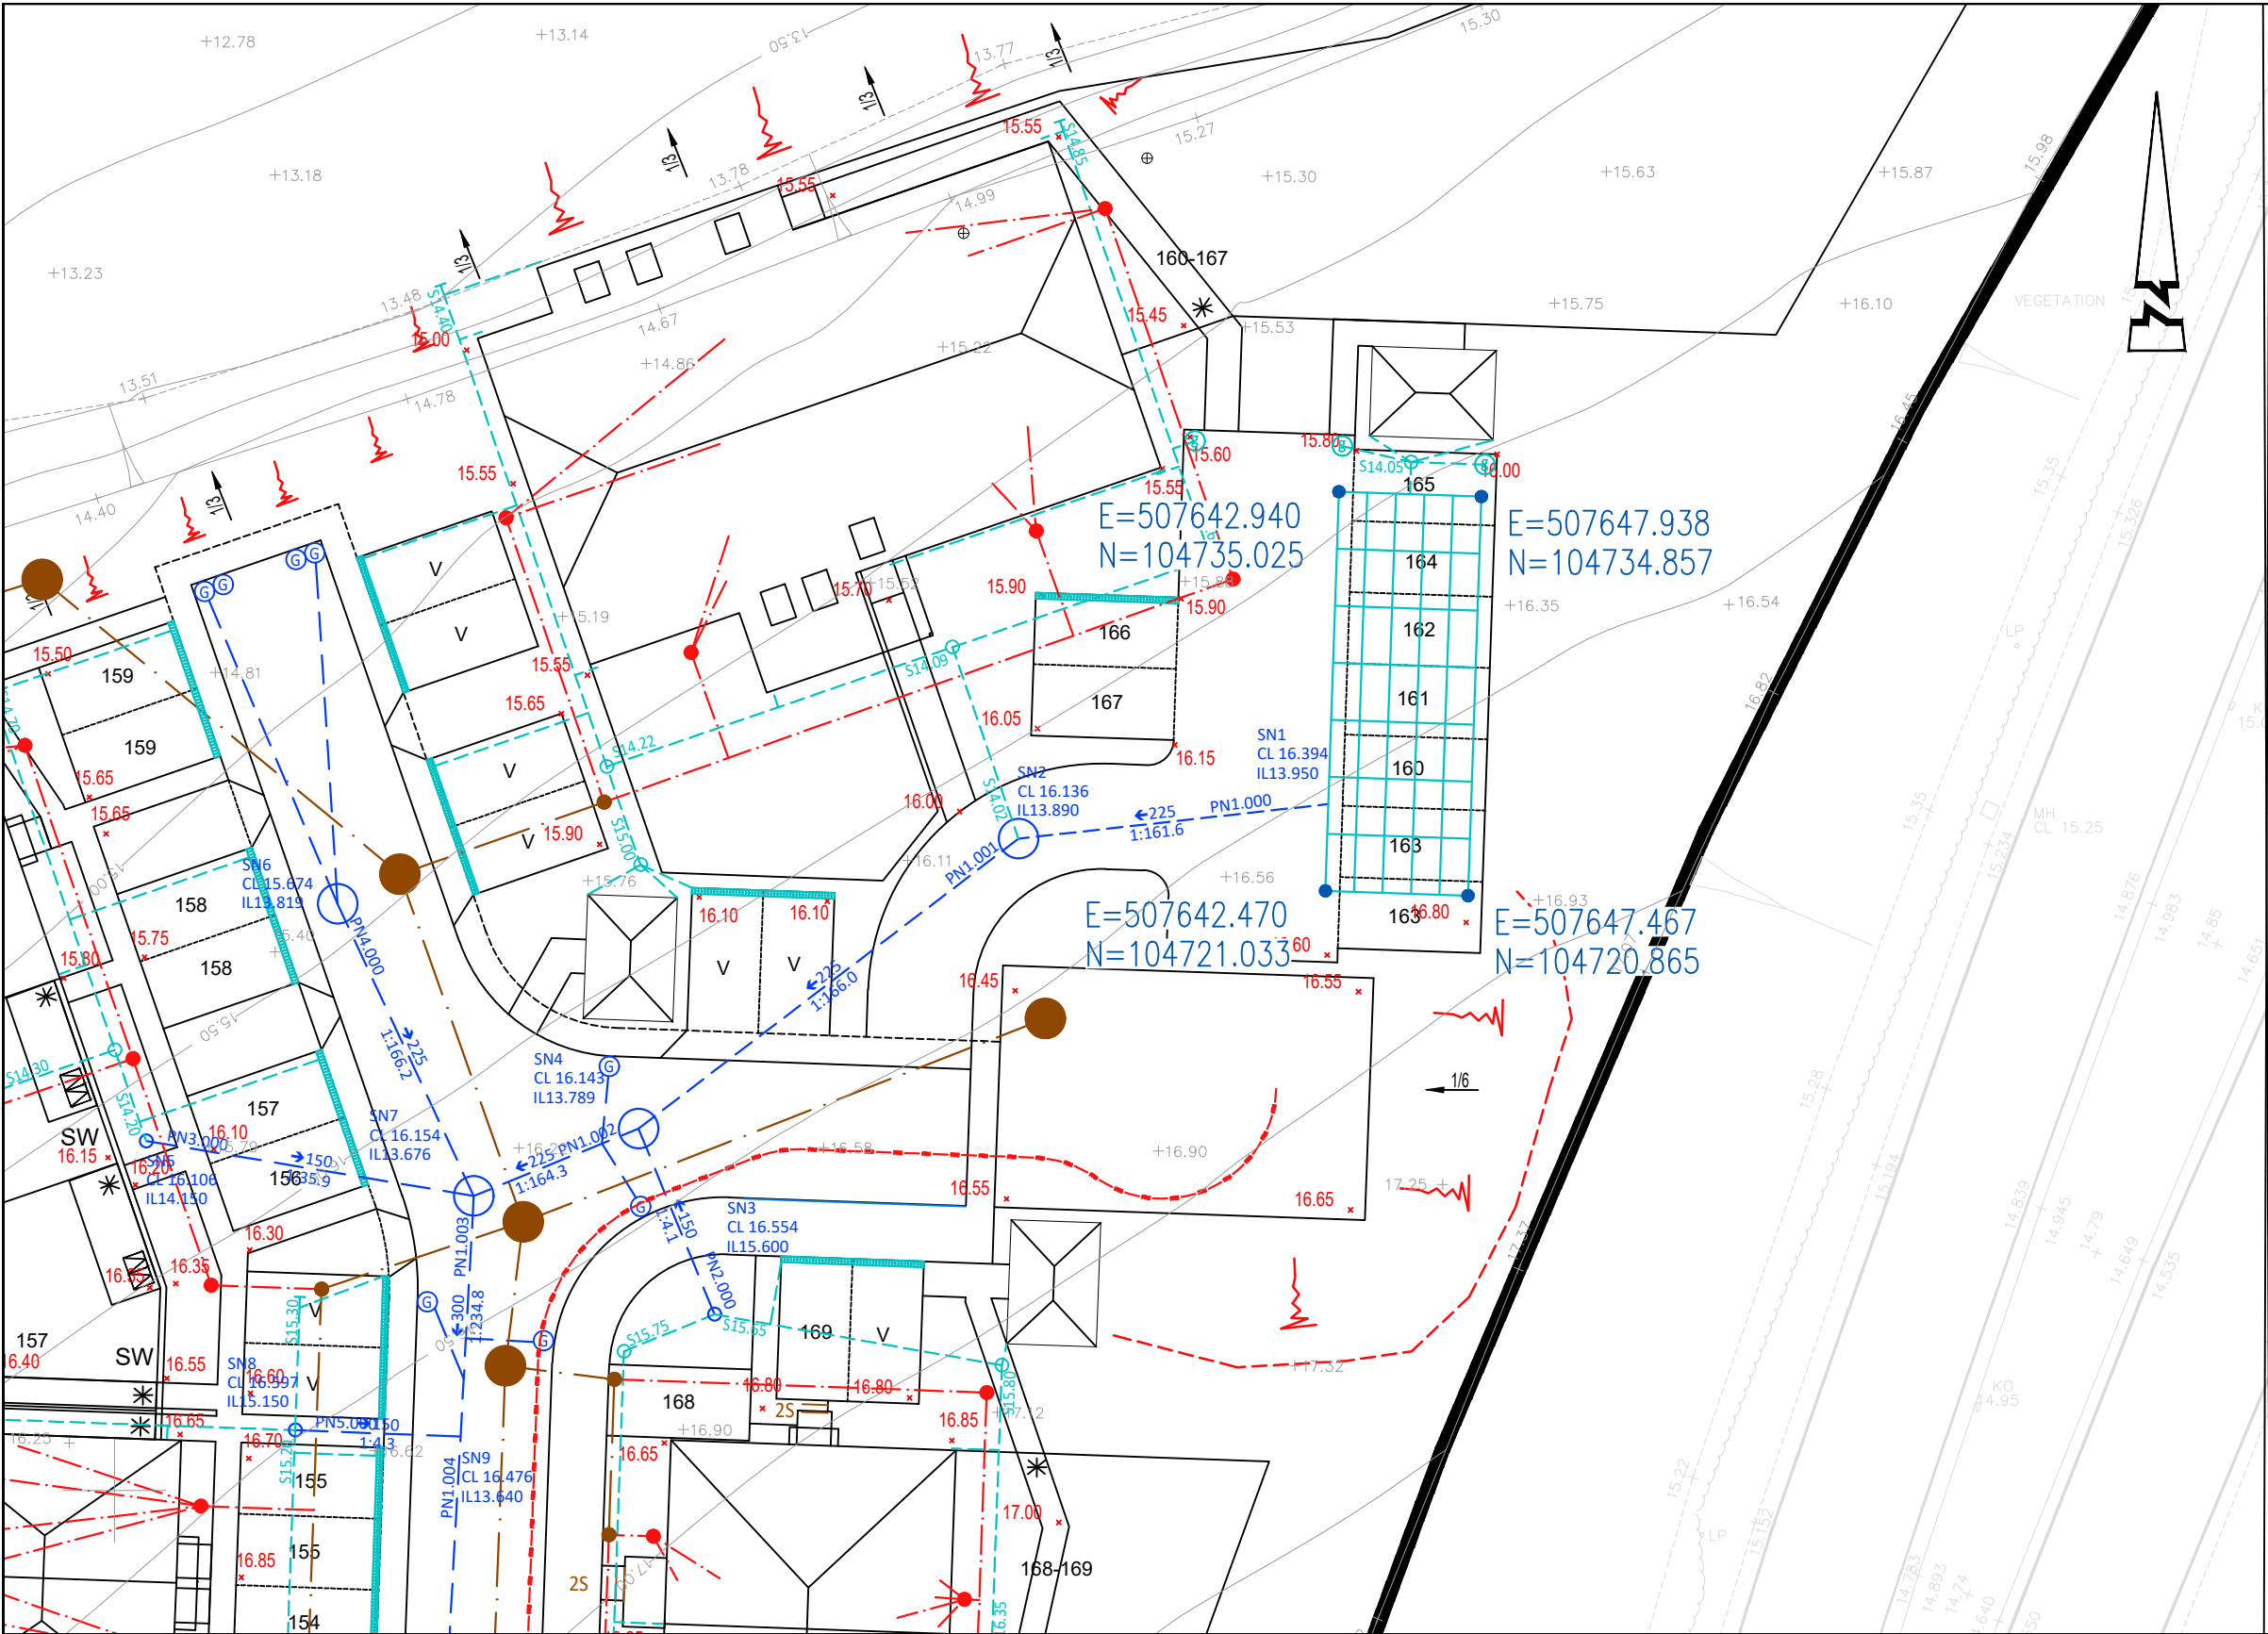

CELLULAR ATTENUATION DETAIL
(REFER TO DRAINAGE LAYOUT FOR SITE SPECIFIC DETAIL)

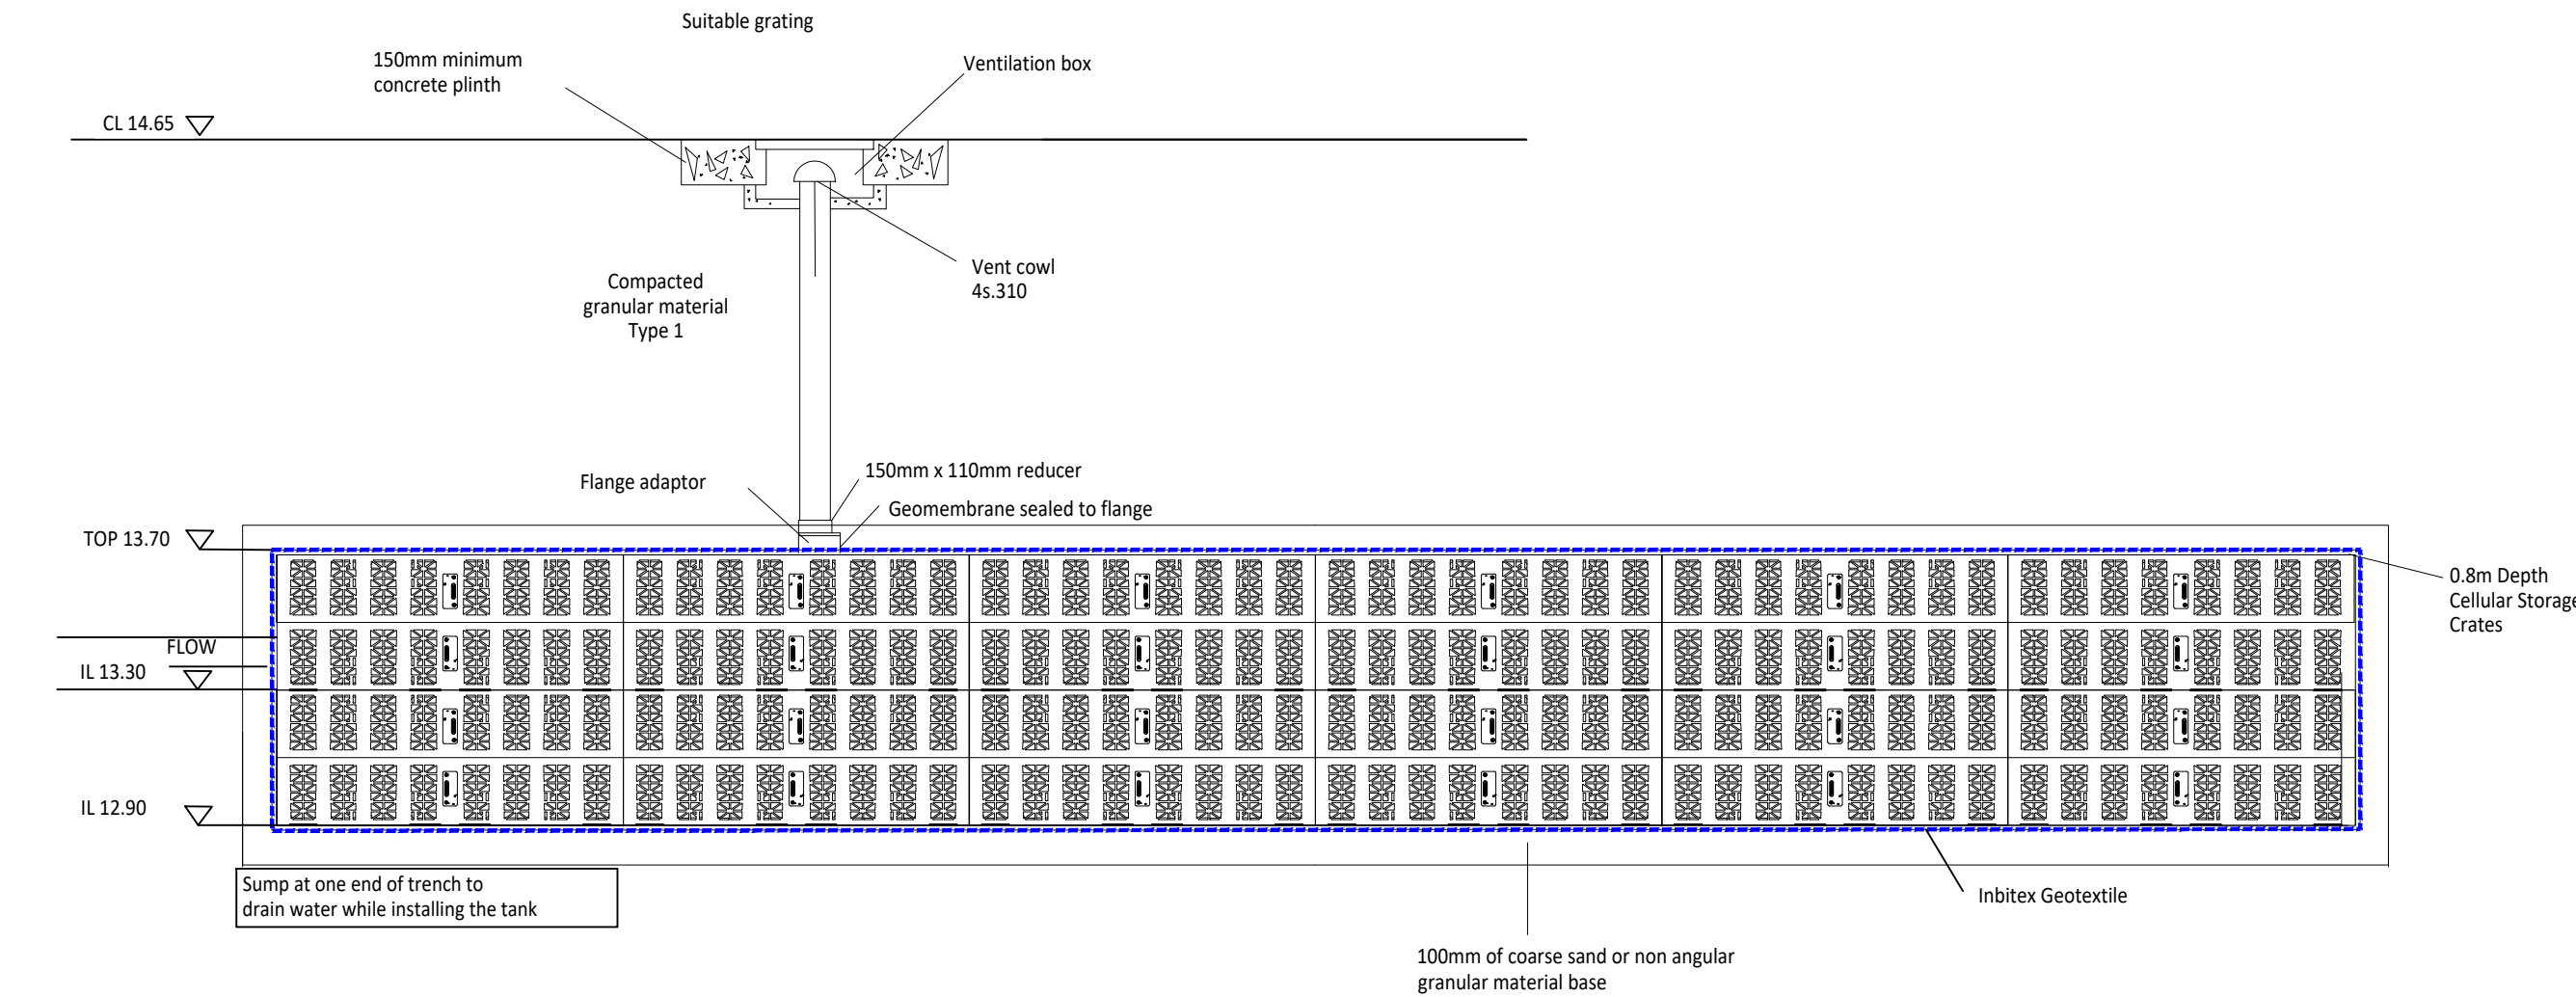

CELLULAR SOAKAWAY DETAIL

© ABLE LETCHFORD PARTNERSHIP LTD.
This drawing should not be reproduced without consent.

GENERAL NOTES:

1. Do not scale.
2. Refer to all other Project Drawings.
3. All sewers to comply with the requirements of the water authorities publication "Sewer Sector Guidance (SSG)" together with Southern Waters Technical Advisories.
4. All public sewers are to be the subject of a Section 104 agreement of the Water Industry Act 1991.
5. Invert levels of existing manholes and sewers are to be checked on site before construction commences and results reported to engineers.
6. All manhole ironworks to comply with BS EN124, and be stamped with BSI Kitemark. Covers to suit loading as below:
 - Carriageways and Roads - D400
 - Driveways and Verges - C250
 - Footways and Pedestrian Areas - B125
 - Gardens/Landscaping - A15
7. All sewer pipes, up to, and including 225mm are to be vitrified clay to BS EN295. All sewer pipes 300mm diameter and above to concrete pipes to BS EN1916.
8. All drainage shall be installed and tested strictly in accordance with the Manufacturers' printed instructions, BS EN 752, BS EN 1601, Local Water Authority requirements and the Building Regulations.
9. All bedding shall be Class 5 unless noted otherwise.
10. All trenches under existing and proposed public highways are to be backfilled with thoroughly compacted Type 1 granular sub-base material.
11. Drainage laid beneath roads and areas of vehicular access (car parking etc) with less than 1200mm of cover shall be encased in concrete bed and surround with associated movement joints. Drainage laid beneath paths, footways and pedestrian areas with less than 900mm of cover shall be similarly treated.
12. Chambers with outgoing pipes greater than 600mm diameter shall be fitted with guard bars, safety chains or other approved safety devices.
13. The use of precast concrete products made with sulphate resisting cement is mandatory, unless a laboratory report proves such precautions are not necessary.
14. All gully connections to use a minimum diameter pipe of 150mm and to be surrounded by a minimum of 150mm of grade C8/C10 concrete over its full length (which should not exceed 15m) and its connection to the carrier system.

FOR CONSTRUCTION

THIS DRAWING IS NOT TECHNICALLY APPROVED
ISSUED FOR CONSTRUCTION AT RISK

C	04.21	Updated following Adur and Worthing Council Comments	JS	SL
B	03.21	Updated following Adur and Worthing Council Comments	JS	SL
A	01.21	Issued for construction	JS	SL
Rev	Date	Description	Drawn	Checked

ABLE LETCHFORD PARTNERSHIP
Consulting Engineers
3 Tealgate, Charnham Park
Hungerford, Berkshire RG17 0YT
www.alpce.co.uk Tel: 01488 684390

Client:
BARRATT DAVID WILSON HOMES

Project:
WATER LANE, ANGMERING

Title:
PERMEABLE CAR PARK & ATTENUATION SETTING OUT & DETAILS

Status:
FOR CONSTRUCTION

Scale	Date	Drawn	Checked
1:250 @ A1	JAN 21	JS	SL
Drawing No.	Rev	Revision	
A290-509	CV-1-4059 C		C