



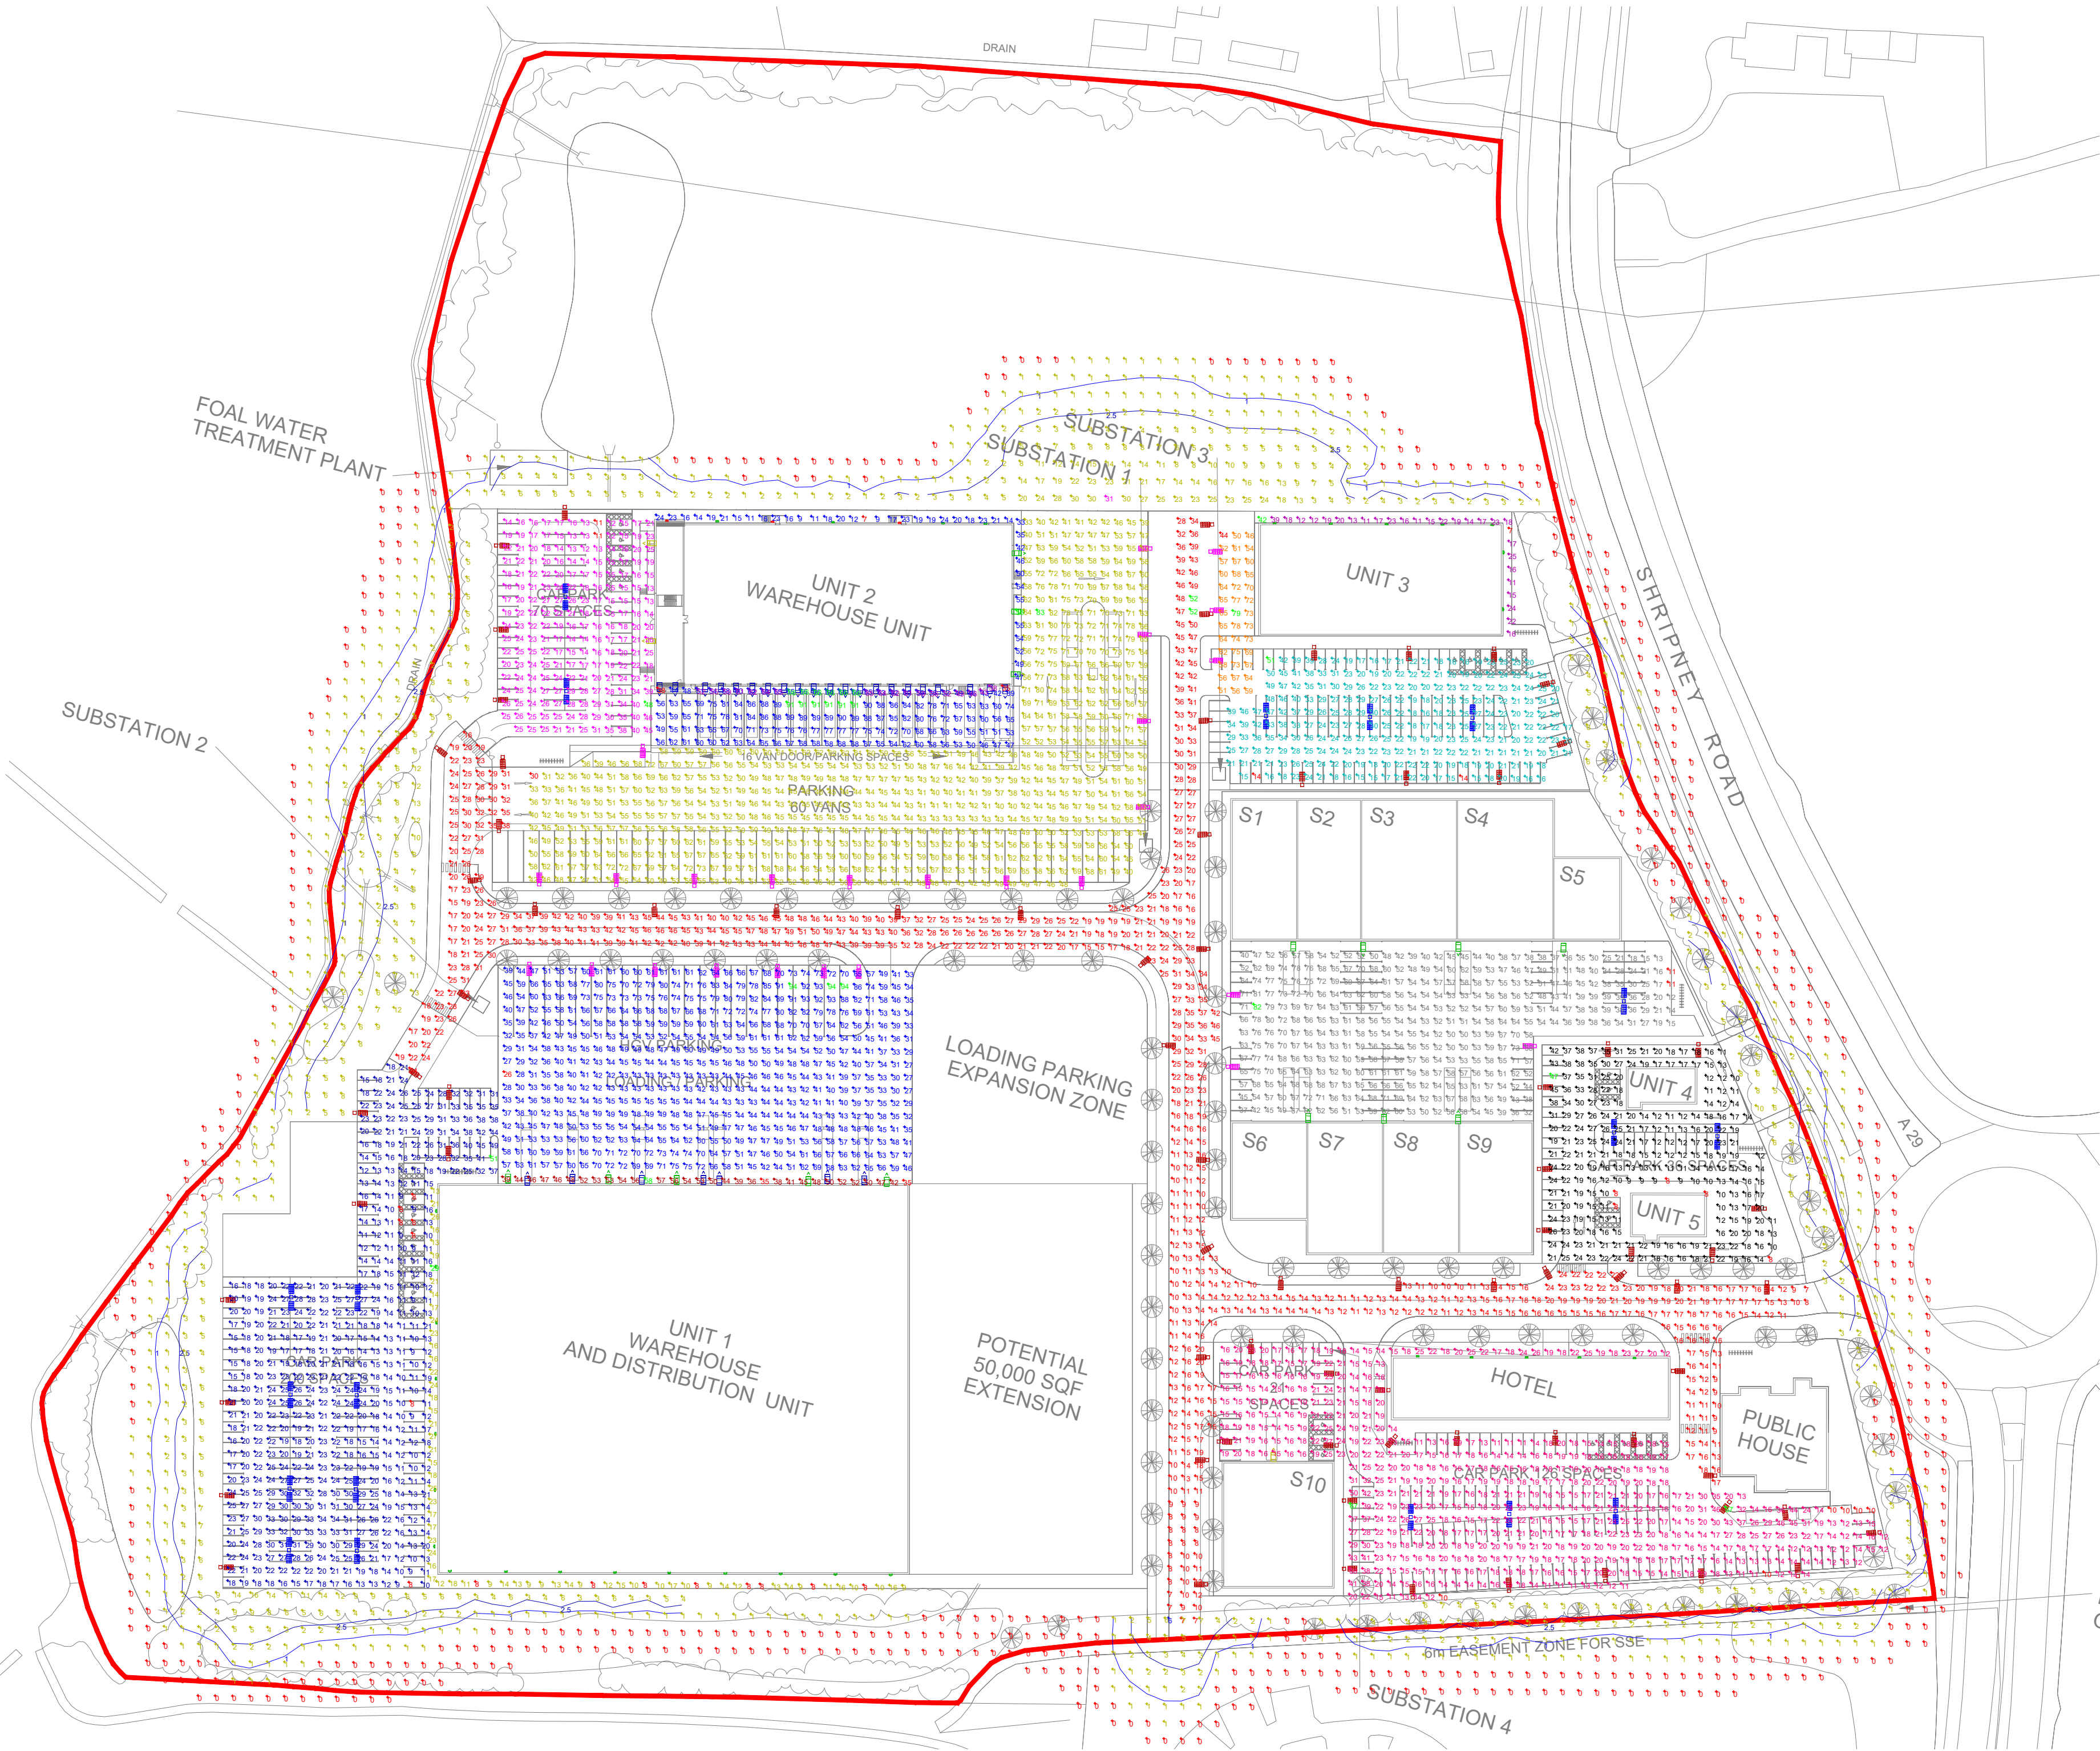

LUMINAIRE SCHEDULE									
Symbol	Label	Qty	Catalog Number	Description	Lamp	File	Lumens	LLF	Watts
	K	26	DSX2.2.LA034.FW	D-Series 2 Luminaire 10m Column mount	LED C.30000LM-4000K	DSX2.2.LA034.FW.ies	Absolute	0.90	282
	L	15	DSX2.2.LA034.FW	D-Series 2 Luminaire Wall mount at 10m	LED C.30000LM-4000K	DSX2.2.LA034.FW.ies	Absolute	0.90	282
	M	28	DSX1.2.LA064.FW	D-Series 1 Luminaire Wall mount at 8.5m	LED C.9000LM-4000K	DSX1.2.LA064.FW.ies	Absolute	0.90	68
	O	32	DEW.LA014.NR.C.GL	Denver Elite Wall Mount at 3m	LED C.1000LM - 4000K	DEW.LA014.NR.C.GL.ies	Absolute	0.90	12
	Oe	3	DEW.LA014.NR.C.GL	Denver Elite Wall Mount at 3m	LED C.1000LM - 4000K	DEW.LA014.NR.C.GL.ies	Absolute	0.90	12
	P	32	DSX1.2.LA064.AY	D-Series 1 Luminaire Column mount at 8m	LED C.9000LM-4000K	DSX1.2.LA064.AY.ies	Absolute	0.90	52
	Q	19	DSX1.2.LA054.AY	D-Series 1 Luminaire Column mount at 6m	LED C.5000LM-4000K	DSX1.2.LA054.AY.ies	Absolute	0.90	72
	R	47	DSX1.2.LA054.AY	D-Series 1 Luminaire Column at 6m	LED C.5000LM-4000K	DSX1.2.LA054.AY.ies	Absolute	0.90	36
	S	3	DSX1.2.LA054.AY	D-Series 1 Luminaire Wall mount at 5m	LED C.5000LM-4000K	DSX1.2.LA054.AY.ies	Absolute	0.90	36

STATISTICS					
Description	Symbol	Avg	Max	Min	Min/Avg
Car Park for Units 4 & 5	+	19 lux	47 lux	8 lux	0.42
Hotel/Pub/Restaurant Car Park	+	19 lux	67 lux	10 lux	0.53
Roadway	+	23 lux	52 lux	6 lux	0.26
Spill Zone	+	2 lux	31 lux	0 lux	0.00
Unit 1 Car Park	+	20 lux	51 lux	8 lux	0.40
Unit 1 Loading Bays	+	48 lux	58 lux	35 lux	0.73
Unit 1 Perimeter Walkway	+	15 lux	29 lux	8 lux	0.53
Unit 1 Service Yard	+	54 lux	94 lux	26 lux	0.48
Unit 2 Car Park	+	21 lux	48 lux	11 lux	0.52
Unit 2 Loading Area	+	68 lux	91 lux	38 lux	0.56
Unit 2 Loading Bays	+	58 lux	66 lux	35 lux	0.60
Unit 2 Perimeter Walkways	+	27 lux	56 lux	7 lux	0.26
Unit 2 Service Yard	+	55 lux	83 lux	30 lux	0.55
Unit 3 Car Park	+	25 lux	51 lux	14 lux	0.56
Unit 3 Perimeter	+	18 lux	42 lux	7 lux	0.39
Unit 3 Service Yard	+	64 lux	79 lux	44 lux	0.69
Unit 6 Service Area/Car Park	+	55 lux	82 lux	11 lux	0.20

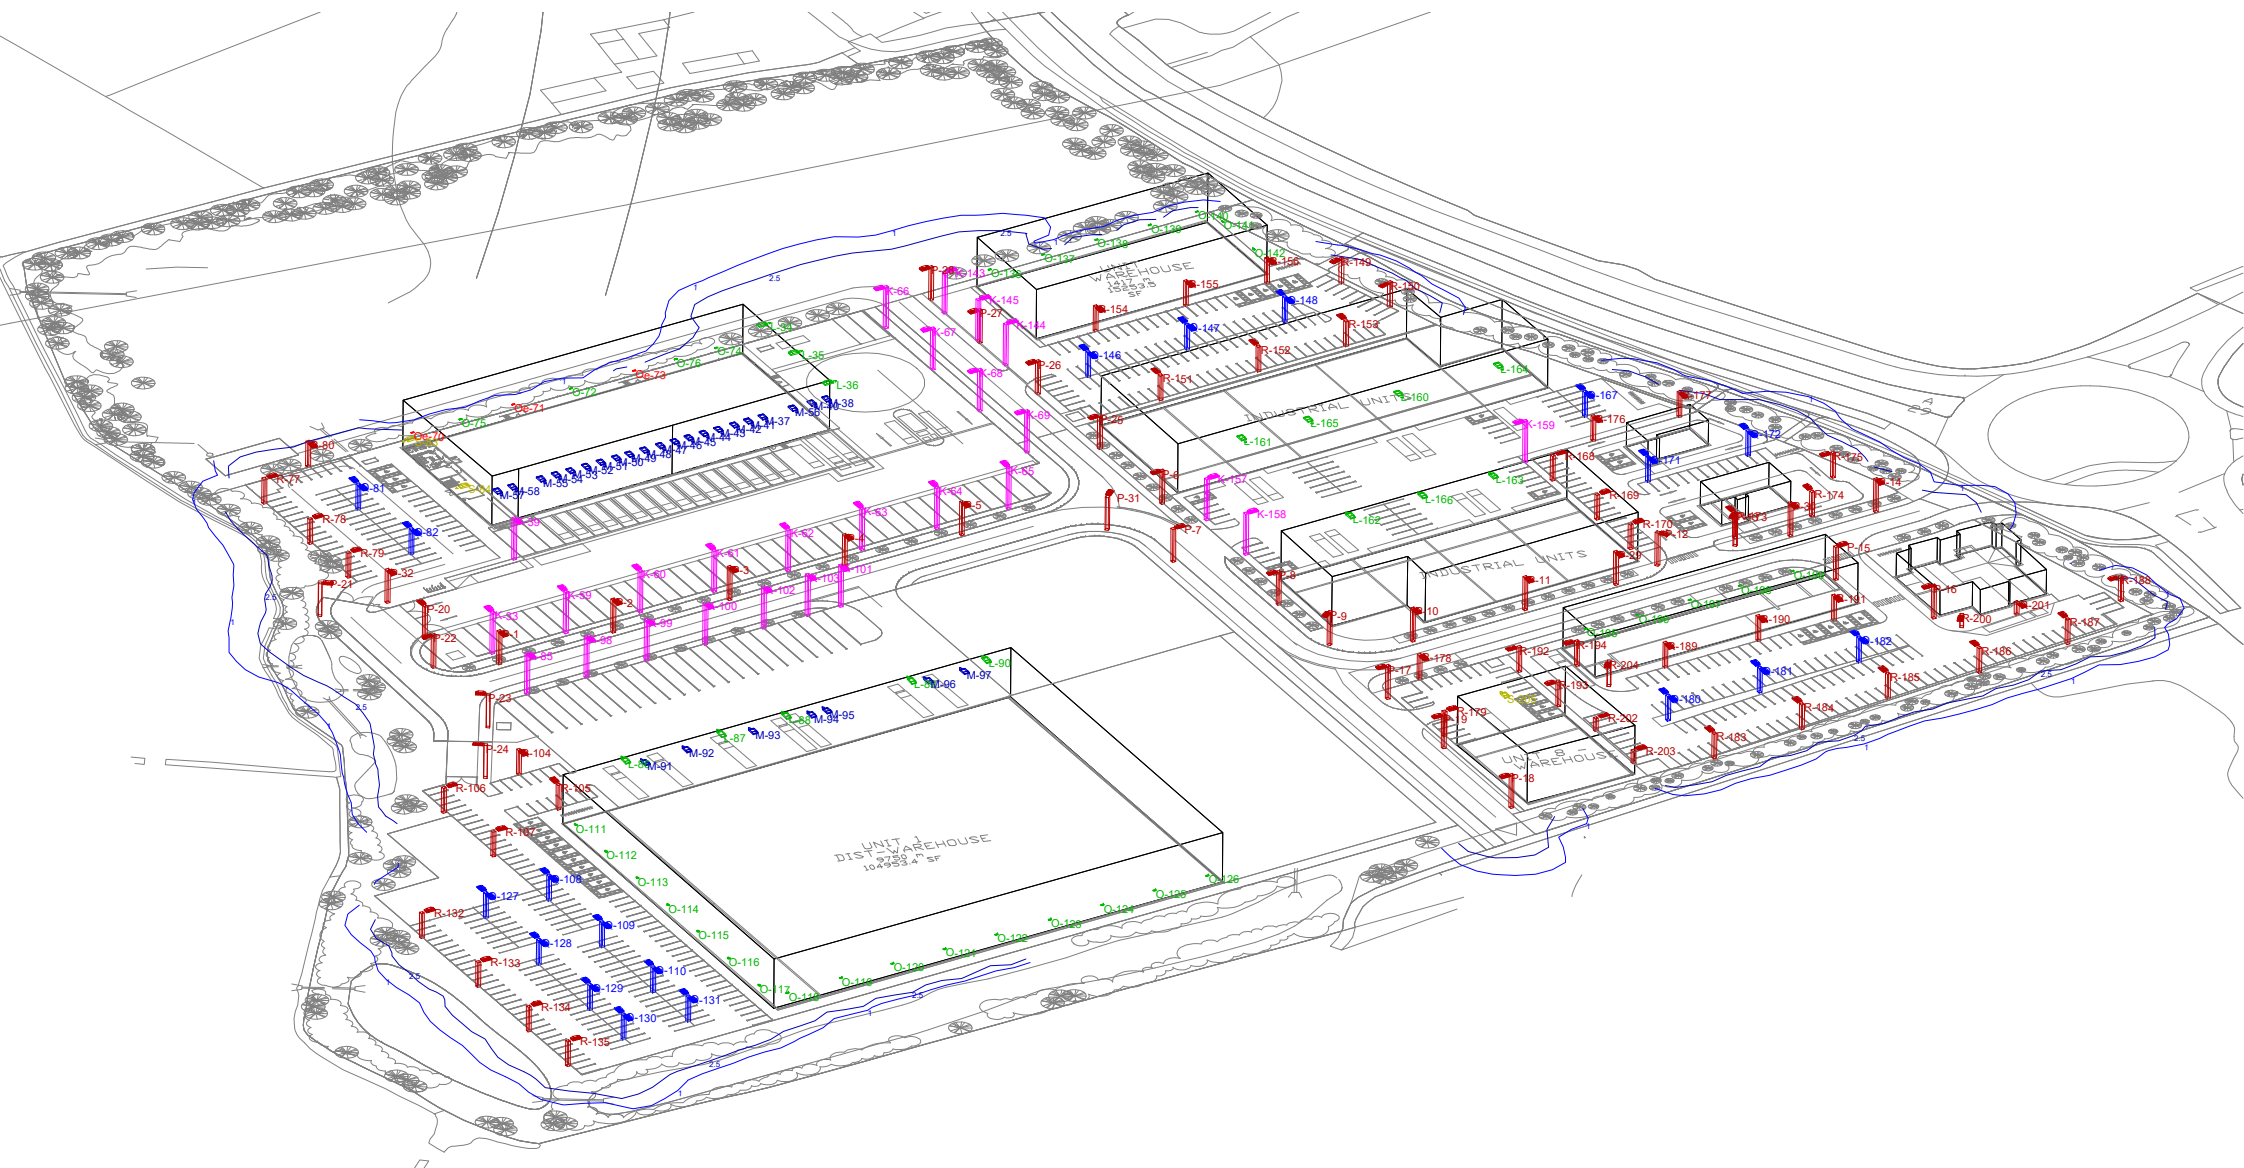

DRAFT



REV	DATE	DESCRIPTION	CAD	CHK	APP
-----	------	-------------	-----	-----	-----

ARCHITECT

MountfordPigott

CLIENT

PROJECT

SALTBOX SITE

DRAWING TITLE

SITE WIDE
PRELIMINARY EXTERNAL
LIGHTING SCHEME

SCOTCH PARTNERS LLP
CLERKENWELL HOUSE
LONDON EC1R 0DT
TEL: +44 (0)203 544 5400
WWW.SCOTCHPARTNERS.COM

SCOTCH
Partners

COPYRIGHT RESERVED. WORK TO FIGURED DIMENSIONS ONLY.
DISCREPANCIES TO BE REPORTED BEFORE PROCEEDING.

ISSUE

DATE

MAY 17

SCALE

1:1000

DRAWN BY

MW

ENG BY

JB

DRAWING NO

5163-SP-E-II0

REV

SIZE

A1