


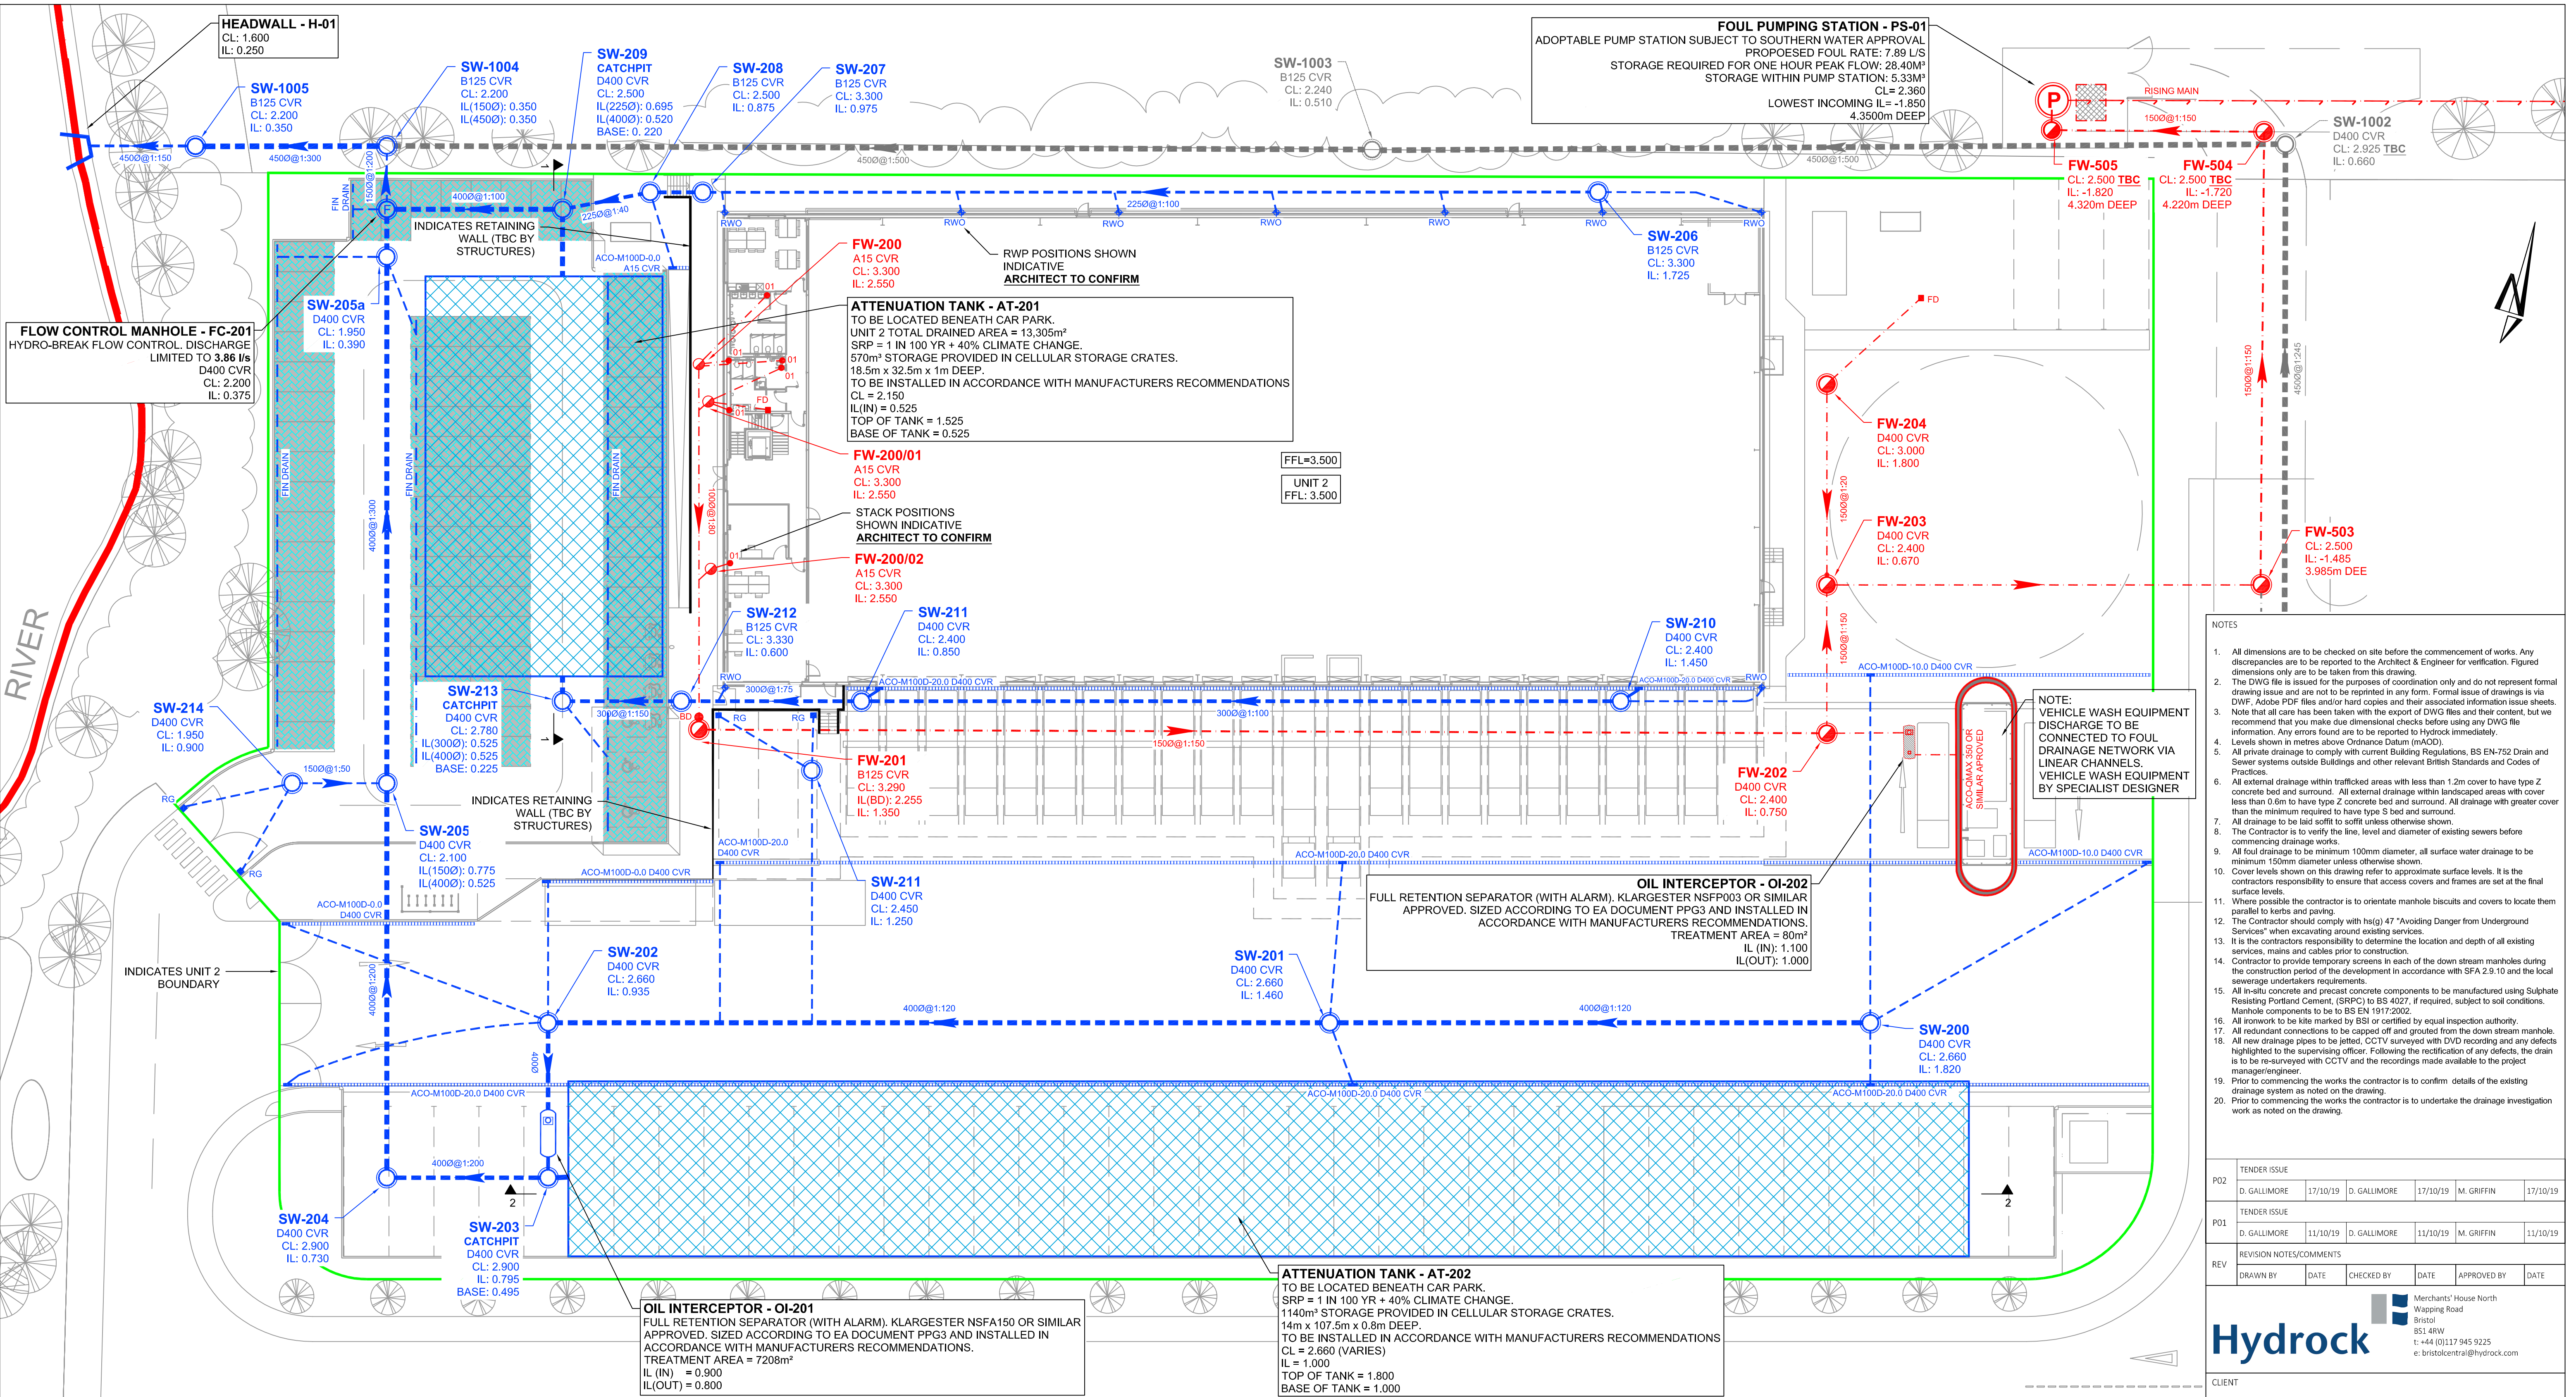

LEGEND

PROPOSED DRAINAGE - FOUL

- 1000@1:100 Foul water drain - clay
- FW-01 Foul water manhole
- FW-01 Foul water inspection chamber
- SAC Foul water shallow access chamber
- RE Foul rodding eye

FOUL YARD GULLY (to be trapped)
Gully reference as noted on drawing.
Cover grade to suit loading.

FLOOR DRAIN (to be trapped)
Internal use only, refer to architect for details / specification.
Roddable from above slab into standard (01) fitting.
Floor Drain / Gully to be kept charged to avoid odours.

FOUL OUTLET / STACK POSITION
Shown indicative, refer to architect for setting out.
All branches 100mm Ø UNO.
01 - Outlet connects into standard 90° rest bend.
01A - Indicates access required in above slab plumbing for rodding, refer to service engineers drawings for details.
SVP - Indicates soil vent pipe by service engineer, with access.

PROPOSED DRAINAGE - STORM

- 1500@1:100 Storm water drain - clay
- SW-01 Storm water manhole
- SW-01 Storm water inspection chamber
- RE Storm rodding eye
- ST Storm silting trap

RAIN WATER OUTLET ACCESS GULLY
AG - Outlet connects to gully.

ROAD GULLY (to be trapped)

YARD GULLY (to be trapped)


PAVED AREA GULLY (to be trapped)

DRAINAGE CHANNEL
(Refer to layout for specification)

THRESHOLD DRAINAGE CHANNEL
(Refer to architect for details / specification)

CONCRETE ENCASUREMENT TO PIPE
Refer to limits of cover table drawing 7101

RAIN WATER OUTLET
Shown indicative, refer to architect for setting out.
All branches 100mm Ø UNO.
01 - Outlet connects into standard 90° rest bend.
01A - Indicates access required in above slab plumbing for rodding, refer to service engineers drawings for details.

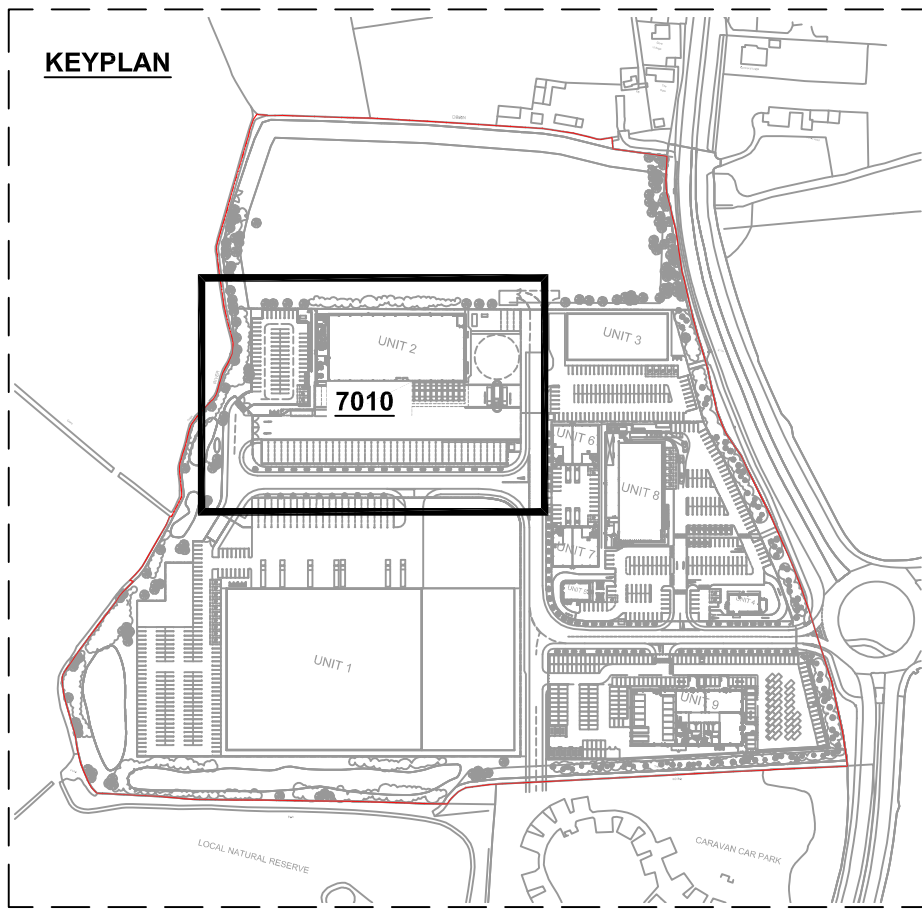

- NOTES**
- All dimensions are to be checked on site before the commencement of works. Any discrepancies are to be reported to the Architect & Engineer for verification. Figured dimensions only are to be taken from this drawing.
 - The DWG file is issued for the purposes of coordination only and does not represent formal drawing issue and are not to be reprinted in any form. Formal issue of drawings is via DWG, Adobe PDF files and/or hard copies and their associated information issue sheets.
 - Note that all care has been taken with the export of DWG files and their content, but we recommend that you make due dimensional checks before using any DWG file information. Any errors found are to be reported to Hydrock immediately.
 - Levels shown in metres above Ordnance Datum (mAOD).
 - All private drainage to comply with current Building Regulations, BS EN-752 Drain and Sewer systems outside Buildings and other relevant British Standards and Codes of Practices.
 - All external drainage within trafficked areas with less than 1.2m cover to have type Z concrete bed and surround. All external drainage within landscaped areas with cover less than 0.6m to have type Z concrete bed and surround. All drainage with greater cover than the minimum required to have type S bed and surround.
 - All drainage to be laid soffit to soffit unless otherwise shown.
 - The Contractor is to verify the line, level and diameter of existing sewers before commencing drainage works.
 - All foul drainage to be minimum 100mm diameter, all surface water drainage to be minimum 150mm diameter unless otherwise shown.
 - Cover levels shown on this drawing refer to approximate surface levels. It is the contractors responsibility to ensure that access covers and frames are set at the final surface levels.
 - Where possible the contractor is to orientate manhole biscuits and covers to locate them parallel to kerbs and paving.
 - The Contractor should comply with hsg 47 "Avoiding Danger from Underground Services" when excavating around existing services.
 - It is the contractors responsibility to determine the location and depth of all existing services, mains and cables prior to construction.
 - Contractor to provide temporary screens in each of the down stream manholes during the construction period of the development in accordance with SFA 2.9.10 and the local sewerage undertakers requirements.
 - All in-situ concrete and precast concrete components to be manufactured using Sulphate Resisting Portland Cement, (SRPC) to BS 4027, if required, subject to soil conditions. Manhole components to be to BS EN 1917:2002.
 - All in-situ concrete to be laid marked by BS1 or certified by equal inspection authority.
 - All new drainage pipes to be jetted, CCTV surveyed with DVD recording and any defects highlighted to the supervising officer. Following the rectification of any defects, the drain is to be re-surveyed with CCTV and the recordings made available to the project manager/engineer.
 - Prior to commencing the works the contractor is to confirm details of the existing drainage system as noted on the drawing.
 - Prior to commencing the works the contractor is to undertake the drainage investigation work as noted on the drawing.

TENDER ISSUE	PO2					
	D. GALLIMORE	17/10/19	D. GALLIMORE	17/10/19	M. GRIFFIN	17/10/19
TENDER ISSUE	PO1					
	D. GALLIMORE	11/10/19	D. GALLIMORE	11/10/19	M. GRIFFIN	11/10/19
REVISION NOTES/COMMENTS						
DRAWN BY	DATE	CHECKED BY	DATE	APPROVED BY	DATE	

CLIENT

LANDLINK ESTATES

PROJECT

SALTBOX
BOGNOR REGIS

TITLE

UNIT 2 DRAINAGE LAYOUT

HYDROCK PROJECT NO.
C-13319-C

SCALE @ A1
1:250

STATUS DESCRIPTION
TENDER

STATUS
D2

DRAWING NO. (PROJECT CODE-ORIGINATOR-ZONE-LEVEL-TYPE-ROLE-NUMBER)
SAL-HYD-00-ZZ-DR-C-7010

REVISION
PO2