


NON DISTINGUERE CONFINI ELETTRICI

SEE DRAWING SAL-HYD-00-GF-DR-C-7020 FOR CONTINUATION

Y.
E
CULVERT

SEE DRAWING SAL-HYD-00-GF-DR-C-7022 FOR CONTINUATION

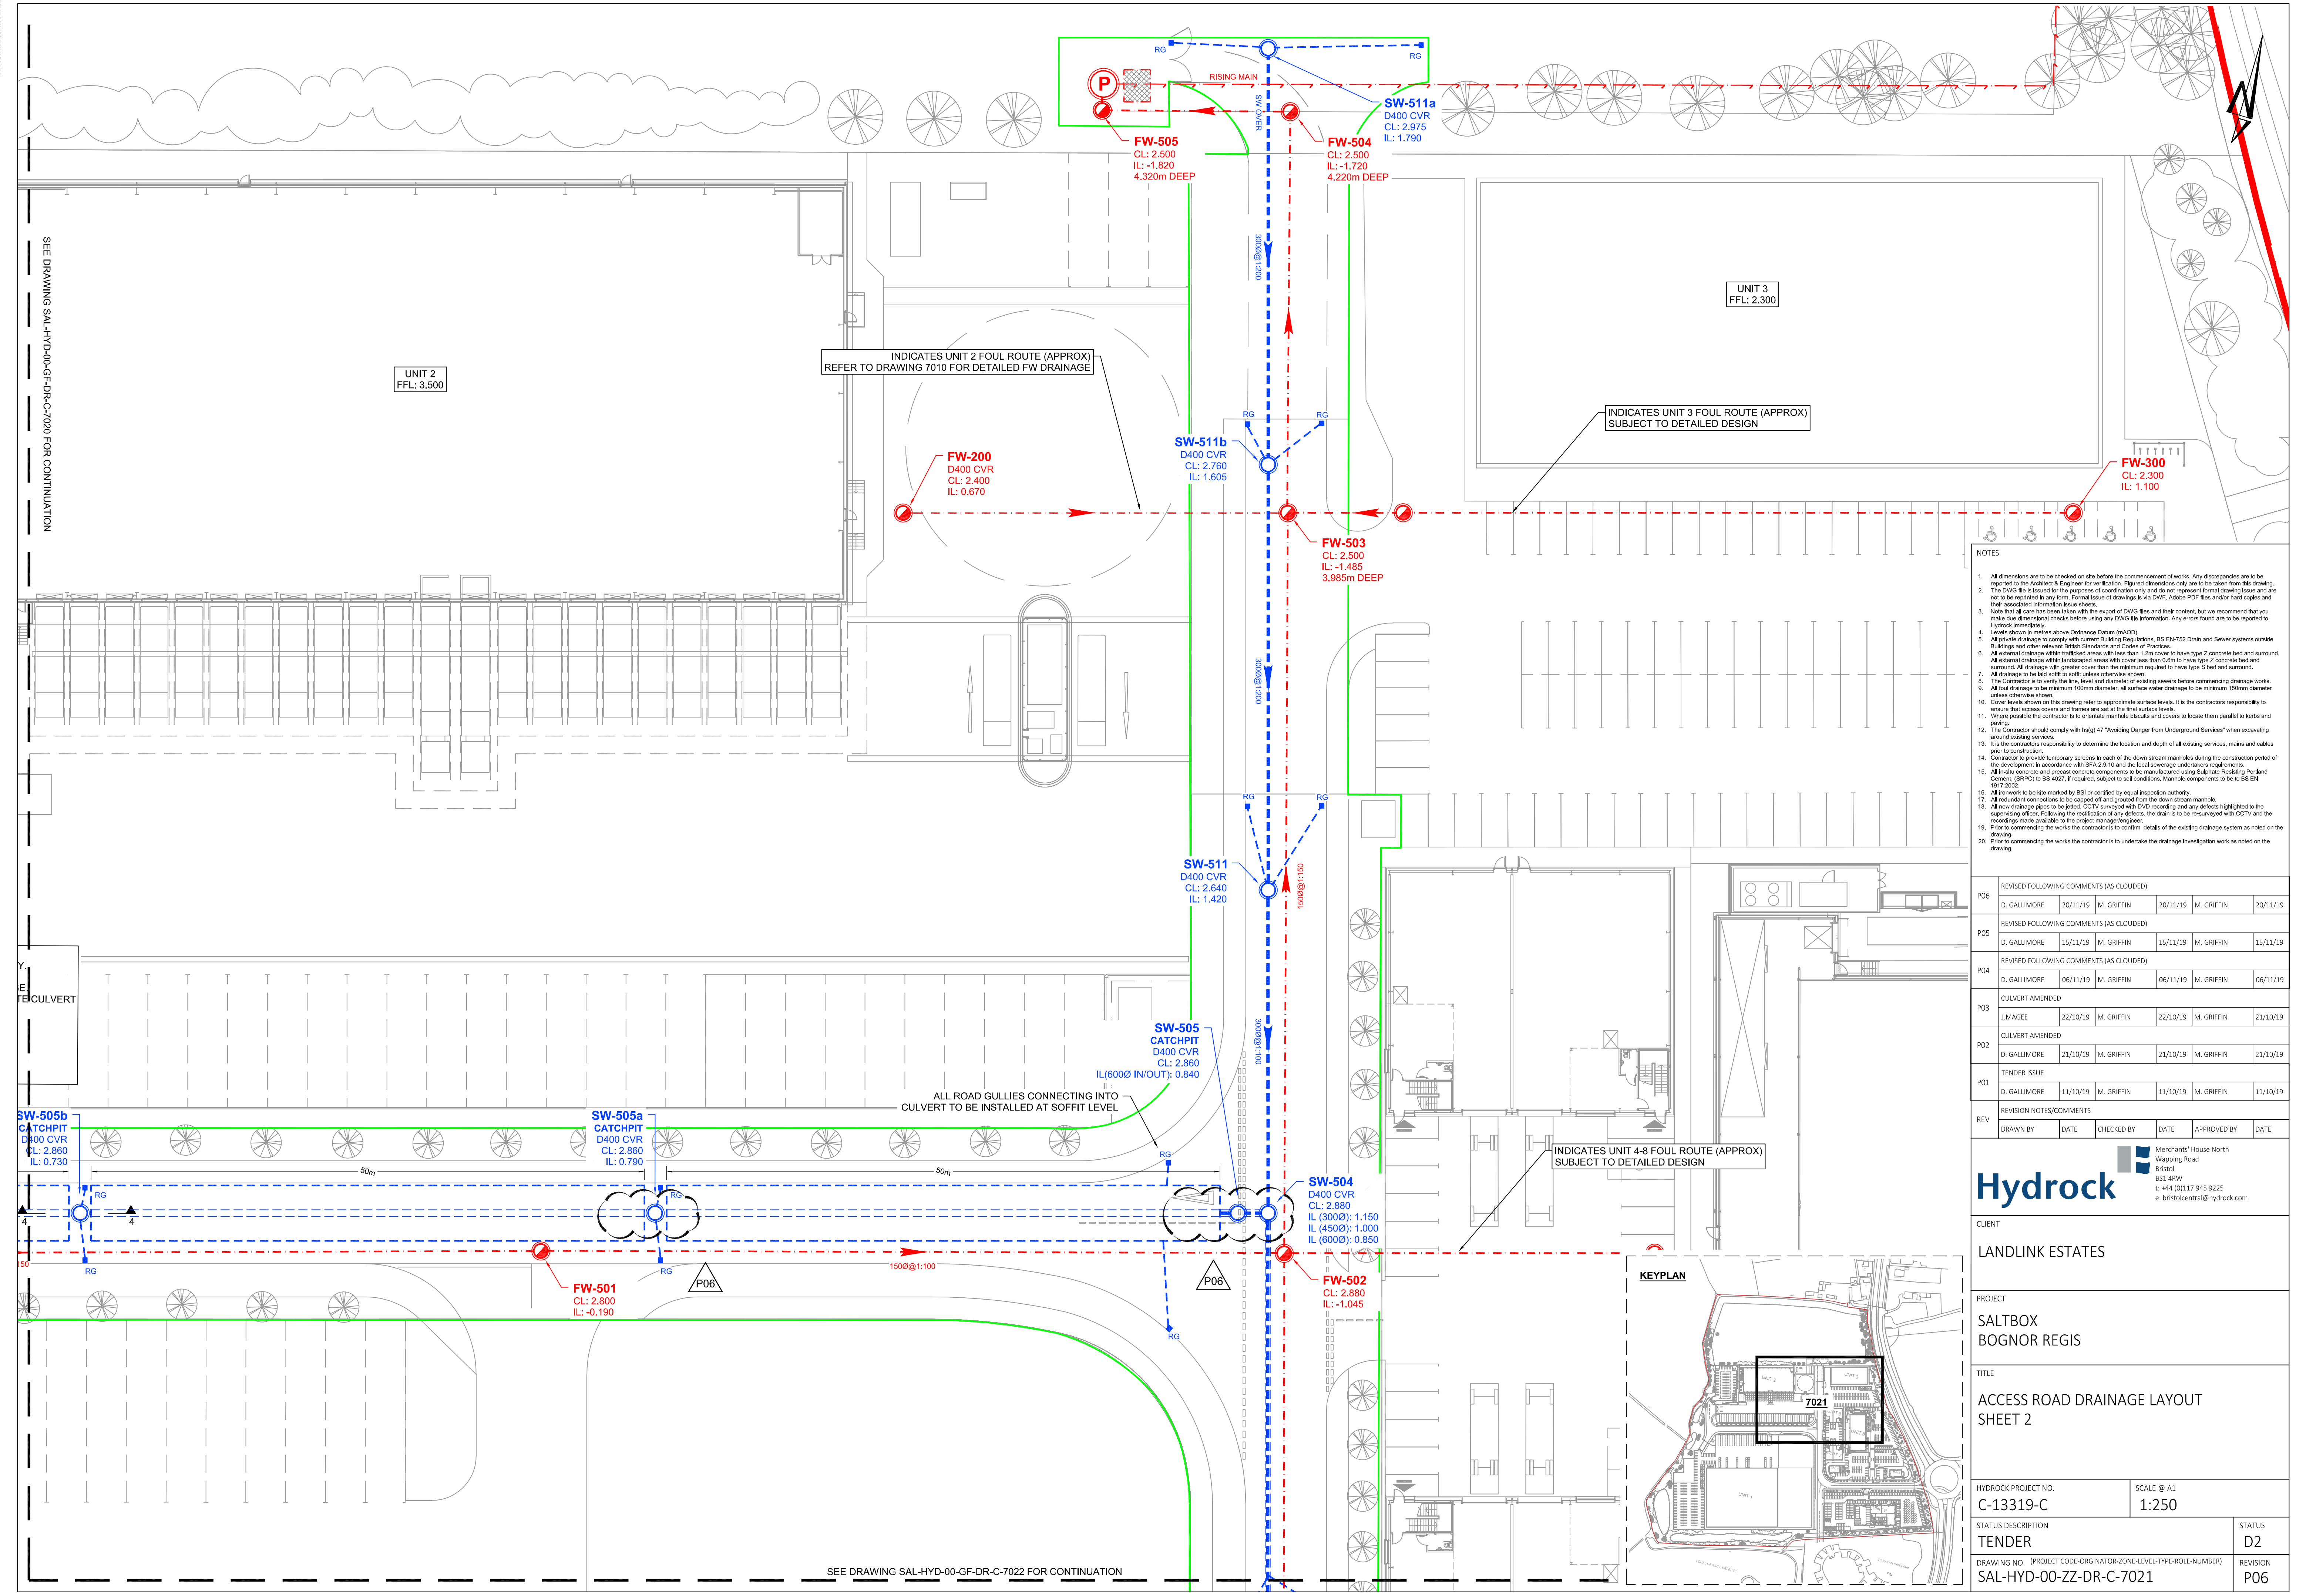

- NOTES
- All dimensions are to be checked on site before the commencement of works. Any discrepancies are to be reported to the Architect & Engineer for verification. Figured dimensions only are to be taken from this drawing.
 - The DWG file is issued for the purposes of coordination only and does not represent formal drawing issue and are not to be reprinted in any form. Formal issue of drawings is via DWG, Adobe PDF files and/or hard copies and their associated information files.
 - Note that all care has been taken with the export of DWG files and their content, but we recommend that you make due dimensional checks before using any DWG file information. Any errors found are to be reported to Hydrock immediately.
 - Levels shown in metres above Ordnance Datum (mAD).
 - All private drainage to comply with current Building Regulations, BS EN752 Drain and Sewer systems outside Buildings and other relevant British Standards and Codes of Practice.
 - All external drainage within trafficked areas with cover less than 1.2m cover to have type Z concrete bed and surround. All drainage with greater cover than the minimum required to have type S bed and surround.
 - All drainage to be laid soffit to soffit unless otherwise shown.
 - The Contractor is to verify the line, level and diameter of existing sewers before commencing drainage works.
 - All foul drainage to be minimum 100mm diameter, all surface water drainage to be minimum 150mm diameter unless otherwise shown.
 - Cover levels shown on this drawing refer to approximate surface levels. It is the contractors responsibility to ensure that access covers and frames are set at the final surface levels.
 - Where possible the contractor is to orientate manhole biscuits and covers to locate them parallel to kerbs and paving.
 - The Contractor should comply with hsigl 47 "Avoiding Danger from Underground Services" when excavating around existing services.
 - It is the contractors responsibility to determine the location and depth of all existing services, mains and cables prior to construction.
 - Contractor to provide temporary screens in each of the down stream manholes during the construction period of the development in accordance with SFA 2.8.10 and the local sewerage undertakers requirements.
 - All in situ concrete and precast concrete components to be manufactured using Salfords Ready-Mix Portland Cement (SRPC) to BS 4027. If required, subject to soil conditions. Manhole components to be to BS EN 1917:2002.
 - All ironwork to be site marked by BSI or certified by equal inspection authority.
 - All redundant connections to be capped off and grounded from the down stream manhole.
 - All new drainage pipes to be jointed, CCTV surveyed with DVC recording and any defects highlighted to the supervising officer. Following the rectification of any defects, the drain is to be re-surveyed with CCTV and the recordings made available to the project manager/engineer.
 - Prior to commencing the works the contractor is to confirm details of the existing drainage system as noted on the drawing.
 - Prior to commencing the works the contractor is to undertake the drainage investigation work as noted on the drawing.

REVISED FOLLOWING COMMENTS (AS CLOUDED)						
P06	D. GALLIMORE	20/11/19	M. GRIFFIN	20/11/19	M. GRIFFIN	20/11/19
REVISED FOLLOWING COMMENTS (AS CLOUDED)						
P05	D. GALLIMORE	15/11/19	M. GRIFFIN	15/11/19	M. GRIFFIN	15/11/19
REVISED FOLLOWING COMMENTS (AS CLOUDED)						
P04	D. GALLIMORE	06/11/19	M. GRIFFIN	06/11/19	M. GRIFFIN	06/11/19
P03	CULVERT AMENDED					
J. MAGEE	22/10/19	M. GRIFFIN	22/10/19	M. GRIFFIN	21/10/19	
P02	CULVERT AMENDED					
D. GALLIMORE	21/10/19	M. GRIFFIN	21/10/19	M. GRIFFIN	21/10/19	
P01	TENDER ISSUE					
D. GALLIMORE	11/10/19	M. GRIFFIN	11/10/19	M. GRIFFIN	11/10/19	
REVISION NOTES/COMMENTS						
DRAWN BY	DATE	CHECKED BY	DATE	APPROVED BY	DATE	

Hydrock

Merchants' House North
Wapping Road
Bristol
BS1 4RW
T: +44 (0)117 945 9225
e: bristolcentral@hydrock.com

CLIENT		LANDLINK ESTATES	
PROJECT		SALTBOX BOGNOR REGIS	
TITLE		ACCESS ROAD DRAINAGE LAYOUT SHEET 2	
HYDROCK PROJECT NO.		SCALE @ A1: 1:250	
C-13319-C			
STATUS DESCRIPTION		STATUS	
TENDER		D2	
DRAWING NO. (PROJECT CODE-ORIGINATOR-ZONE-LEVEL-TYPE-ROLE-NUMBER)		REVISION	
SAL-HYD-00-ZZ-DR-C-7021		P06	