


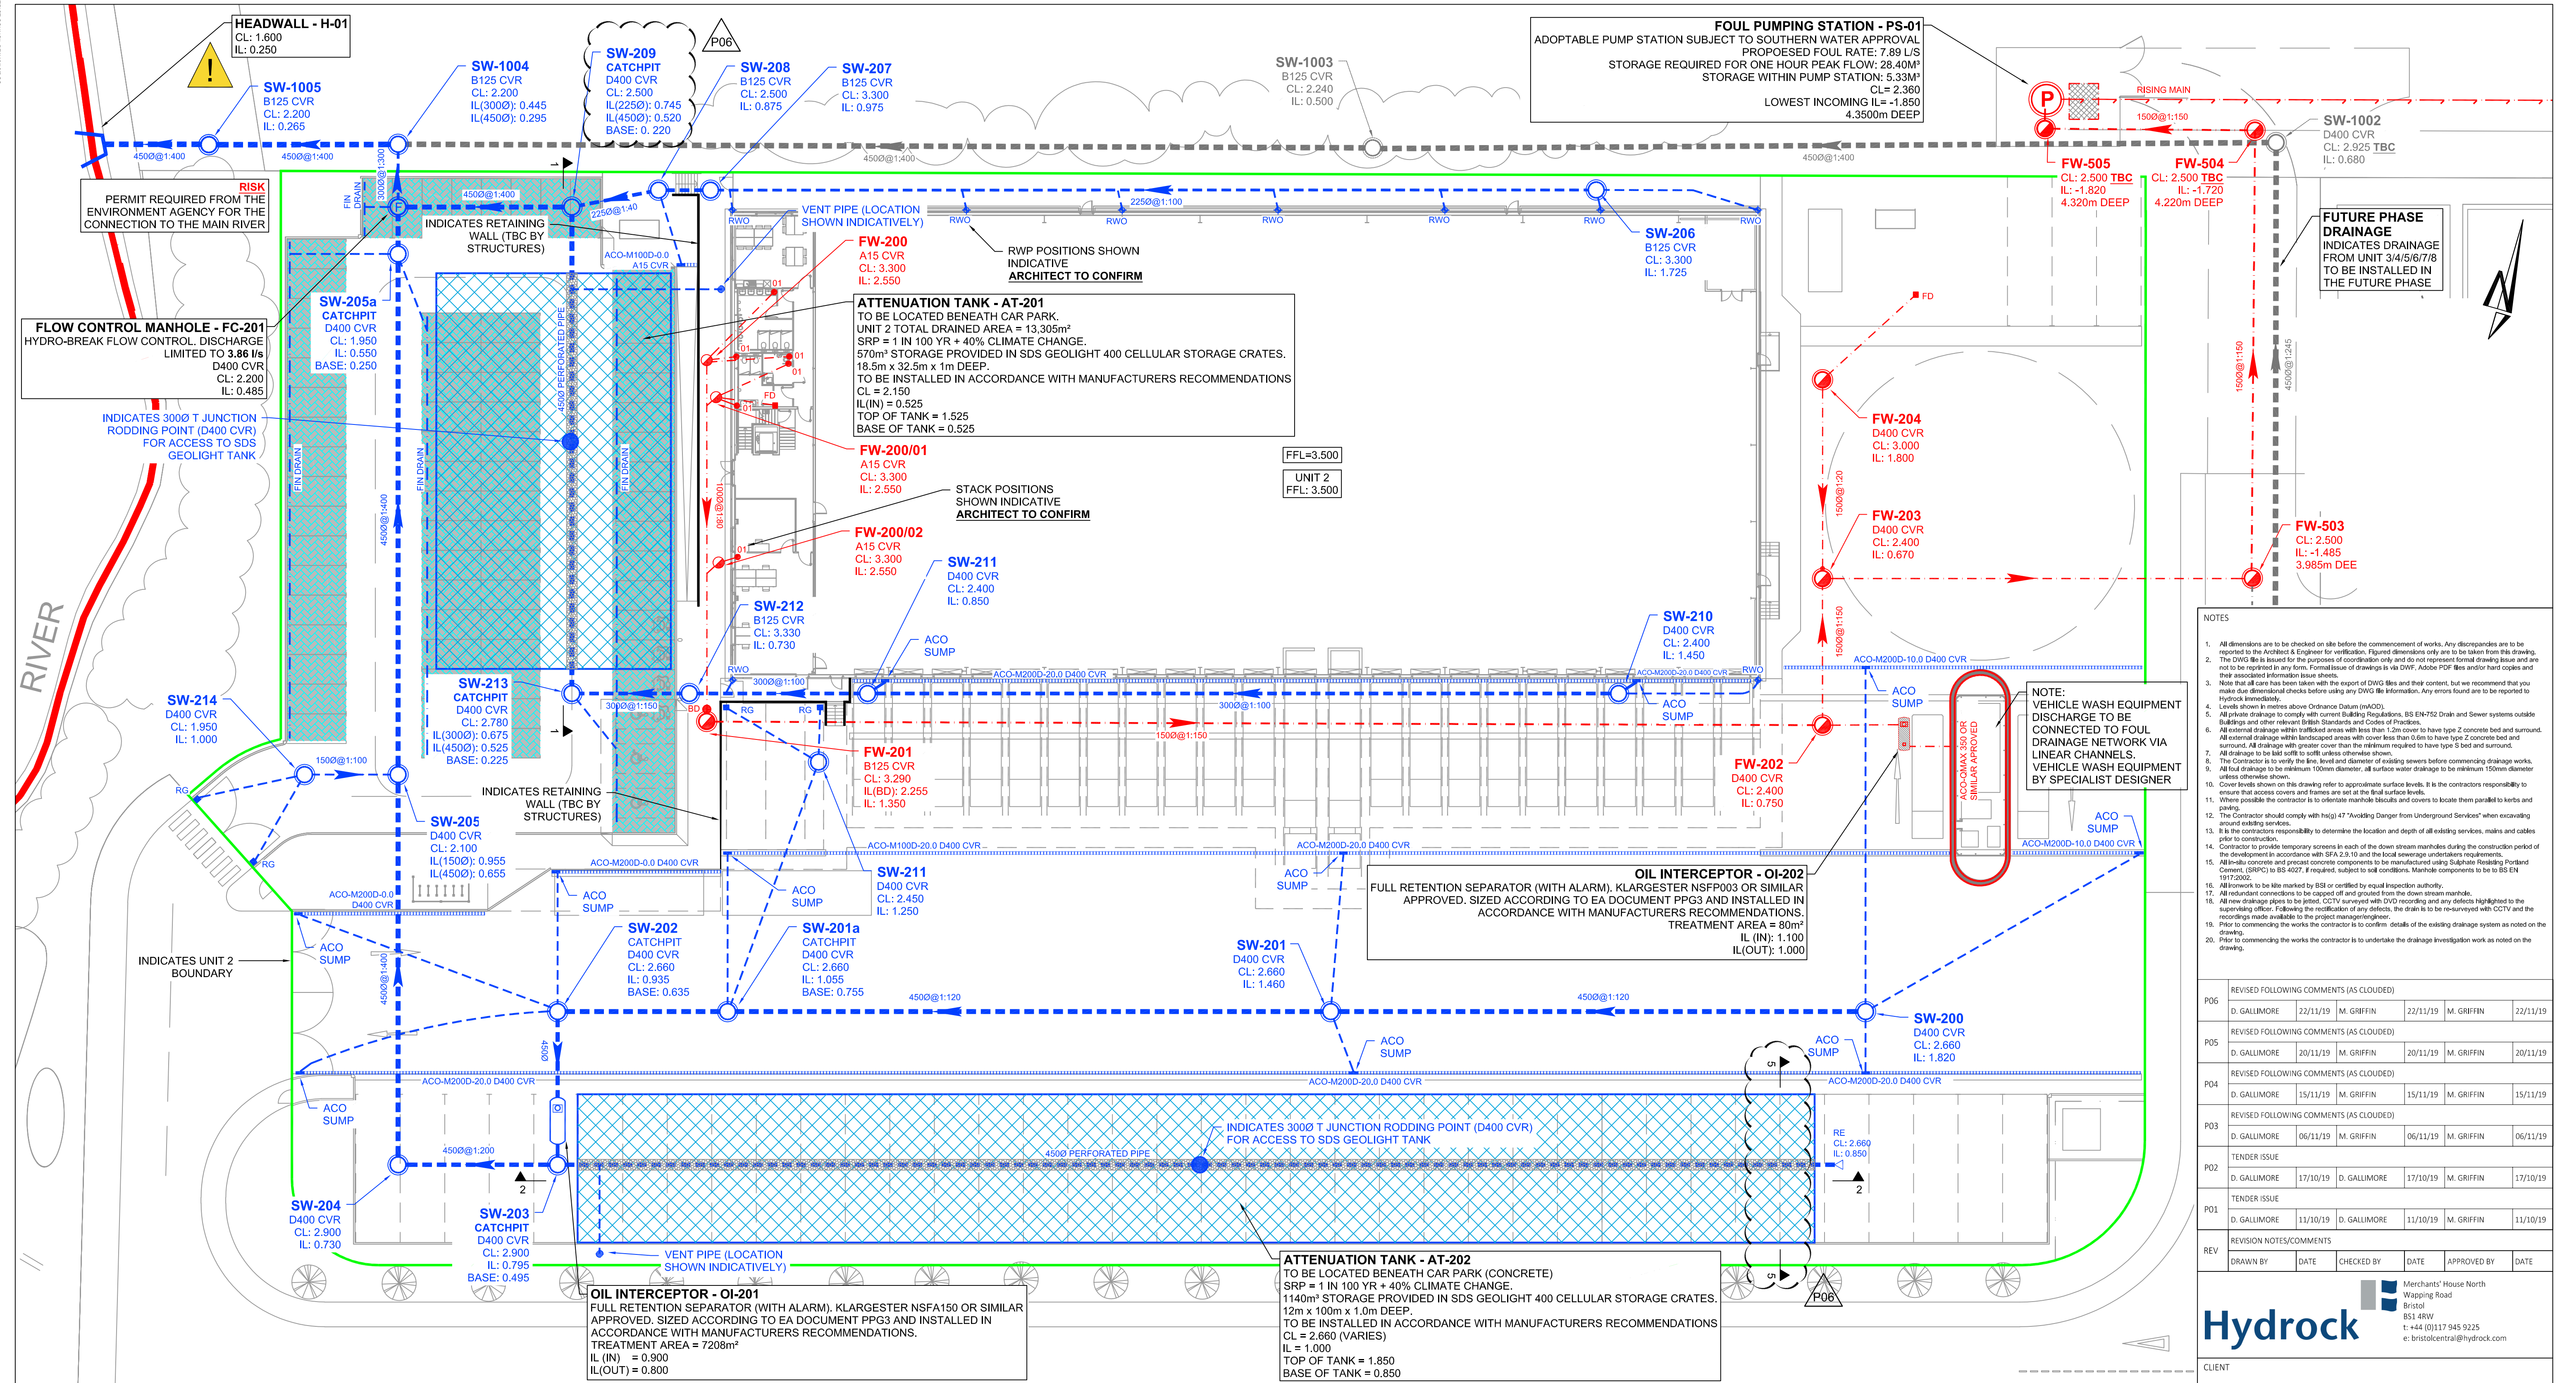

LEGEND
PROPOSED DRAINAGE - FOUL

1000@1:100

FOUL WATER DRAIN - CLAY

Approx. gradient and diameter as noted, 100mm Ø UNO

FW-01

FOUL WATER MANHOLE

PC Ring REFER TO DETAILS FOR MANHOLE DIAMETER

FW-01

FOUL WATER INSPECTION CHAMBER

PVCu 450mm Ø. Max 1.2m depth - reduced access to 3.0m

Note: All internal foul MH's and IC's to have recessed covers. double sealed and locking to prevent odours. Refer to layout for location.

FOUL WATER SHALLOW ACCESS CHAMBER

Max depth to invert 600mm from GL, 300mm Ø

RE

FOUL RODDING EYE

Ø as noted

YG

FOUL YARD GULLY (to be trapped)

Gully reference as noted on drawing.

Cover grade to suit loading.

FD

FLOOR DRAIN (to be trapped)

Internal use only, refer to architect for details / specification.

Roddable from above slab into standard (01) fitting.

Floor Drain / Gully to be kept charged to avoid odours.

01 & 01A

FOUL OUTLET / STACK POSITION

Shown indicative, refer to architect for setting out.

All branches 100mm Ø UNO.

01 - Outlet connects into standard 90° rest bend.

01A - Indicates access required in above slab plumbing for rodding, refer to service engineers drawings for details.

SVP - Indicates soil vent pipe by service engineer; with access.

PROPOSED DRAINAGE - STORM

1500@1:100

STORM WATER DRAIN - CLAY

Approx. gradient and diameter as noted, 150mm Ø UNO

SW-01

STORM WATER MANHOLE

PC Ring - REFER TO DETAILS FOR MH DIAMETER

SW-01

STORM WATER INSPECTION CHAMBER

PVCu 450mm Ø. Max 1.2m depth - reduced access to 3.0m

RE

STORM RODDING EYE

Ø as noted

SILT TRAP

CONCRETE ENCASUREMENT TO PIPE

Refer to limits of cover table drawing 7101

RAIN WATER OUTLET

Shown indicative, refer to architect for setting out.

All branches 100mm Ø UNO.

01 - Outlet connects into standard 90° rest bend.

01A - Indicates access required in above slab plumbing for rodding, refer to service engineers drawings for details.

AG

RAIN WATER OUTLET ACCESS GULLY

AG - Outlet connects to gully.

RG

ROAD GULLY (to be trapped)

YG

YARD GULLY (to be trapped)

PG

PAVED AREA GULLY (to be trapped)

DC

DRAINAGE CHANNEL

(Refer to layout for specification)

TH

THRESHOLD DRAINAGE CHANNEL

(Refer to architect for details / specification)

FIN DRAIN

FIN DRAIN

Refer to details for specifications)

all pipes to be 1500 Ø UNO

KEYPLAN

CLIENT
LANDLINK ESTATES

PROJECT
SALTBOX
BOGNOR REGIS

TITLE
UNIT 2 DRAINAGE LAYOUT

HYDROCK PROJECT NO.	C-13319-C	SCALE @ A1	1:250
STATUS DESCRIPTION	TENDER	STATUS	D2
DRAWING NO.	(PROJECT CODE-ORIGINATOR-ZONE-LEVEL-TYPE-ROLE-NUMBER)	REVISION	P06
SAL-HYD-00-ZZ-DR-C-7010			

NOTES

- All dimensions are to be checked on site before the commencement of works. Any discrepancies are to be reported to the Architect & Engineer for verification. Figured dimensions only are to be taken from this drawing.
- The DWG file is issued for the purposes of coordination only and does not represent formal drawing issue and are not to be reprinted in any form. Formal issue of drawings is via DWF, Adobe PDF files and/or hard copies and their associated information leave sheets.
- Note that all care has been taken with the export of DWG files and their content, but we recommend that you make due dimensional checks before using any DWG file information. Any errors found are to be reported to Hydrock immediately.
- Levels shown in metres above Ordnance Datum (mAOD).
- All private drainage to comply with current Building Regulations, BS EN752 Drain and Sewer systems outside buildings and other relevant British Standards and Codes of Practice.
- All external drainage within trafficked areas with less than 1.2m cover to have type 2 concrete bed and surround.
- All external drainage within landscaped areas with cover less than 0.6m to have type 2 concrete bed and surround. All drainage with greater cover than the minimum required to have type 3 bed and surround.
- All drainage to be laid soft to soft unless otherwise shown.
- The Contractor is to verify the line, level and diameter of existing sewers before commencing drainage works.
- All foul drainage to be minimum 100mm diameter, all surface water drainage to be minimum 150mm diameter unless otherwise shown.
- Cover levels shown on this drawing refer to approximate surface levels. It is the contractors responsibility to ensure that access covers and frames are set at the final surface levels.
- Where possible the contractor is to orientate manhole biscuits and covers to locate them parallel to kerbs and paving.
- The Contractor should comply with height 47 "Avoiding Danger from Underground Services" when excavating around existing services.
- It is the contractors responsibility to determine the location and depth of all existing services, mains and cables prior to construction.
- Contractor to provide temporary screens in each of the down stream manholes during the construction period of the development in accordance with SFA 2.3.10 and the local sewerage undertakers requirements.
- All in-situ concrete and precast concrete components to be manufactured using Salbridge Reading Portland Cement, (SRPC) to BS 4027. If required, subject to sell conditions. Manhole components to be to BS EN 1917:2002.
- All known to be site marked by BS1 or certified by equal inspection authority.
- All redundant connections to be capped off and grouted from the down stream manhole.
- All new drainage pipes to be fitted, CCTV surveyed with CVD recording and any defects highlighted to the supervising officer. Following the rectification of any defects, the drain is to be re-surveyed with CCTV and the recordings made available to the project manager/engineer.
- Prior to commencing the works the contractor is to confirm details of the existing drainage system as noted on the drawing.
- Prior to commencing the works the contractor is to undertake the drainage investigation work as noted on the drawing.

REVISED FOLLOWING COMMENTS (AS CLOUDED)					
P06	D. GALLIMORE	22/11/19	M. GRIFFIN	22/11/19	M. GRIFFIN
REVISED FOLLOWING COMMENTS (AS CLOUDED)					
P05	D. GALLIMORE	20/11/19	M. GRIFFIN	20/11/19	M. GRIFFIN
REVISED FOLLOWING COMMENTS (AS CLOUDED)					
P04	D. GALLIMORE	15/11/19	M. GRIFFIN	15/11/19	M. GRIFFIN
REVISED FOLLOWING COMMENTS (AS CLOUDED)					
P03	D. GALLIMORE	06/11/19	M. GRIFFIN	06/11/19	M. GRIFFIN
TENDER ISSUE					
P02	D. GALLIMORE	17/10/19	D. GALLIMORE	17/10/19	M. GRIFFIN
TENDER ISSUE					
P01	D. GALLIMORE	11/10/19	D. GALLIMORE	11/10/19	M. GRIFFIN
REVISION NOTES/COMMENTS					
REV	DRAWN BY	DATE	CHECKED BY	DATE	APPROVED BY

Merchants' House North
Wapping Road
Bristol
BS1 4RW
t: +44 (0)117 945 9225
e: bristolcentral@hydrock.com

Hydrock