


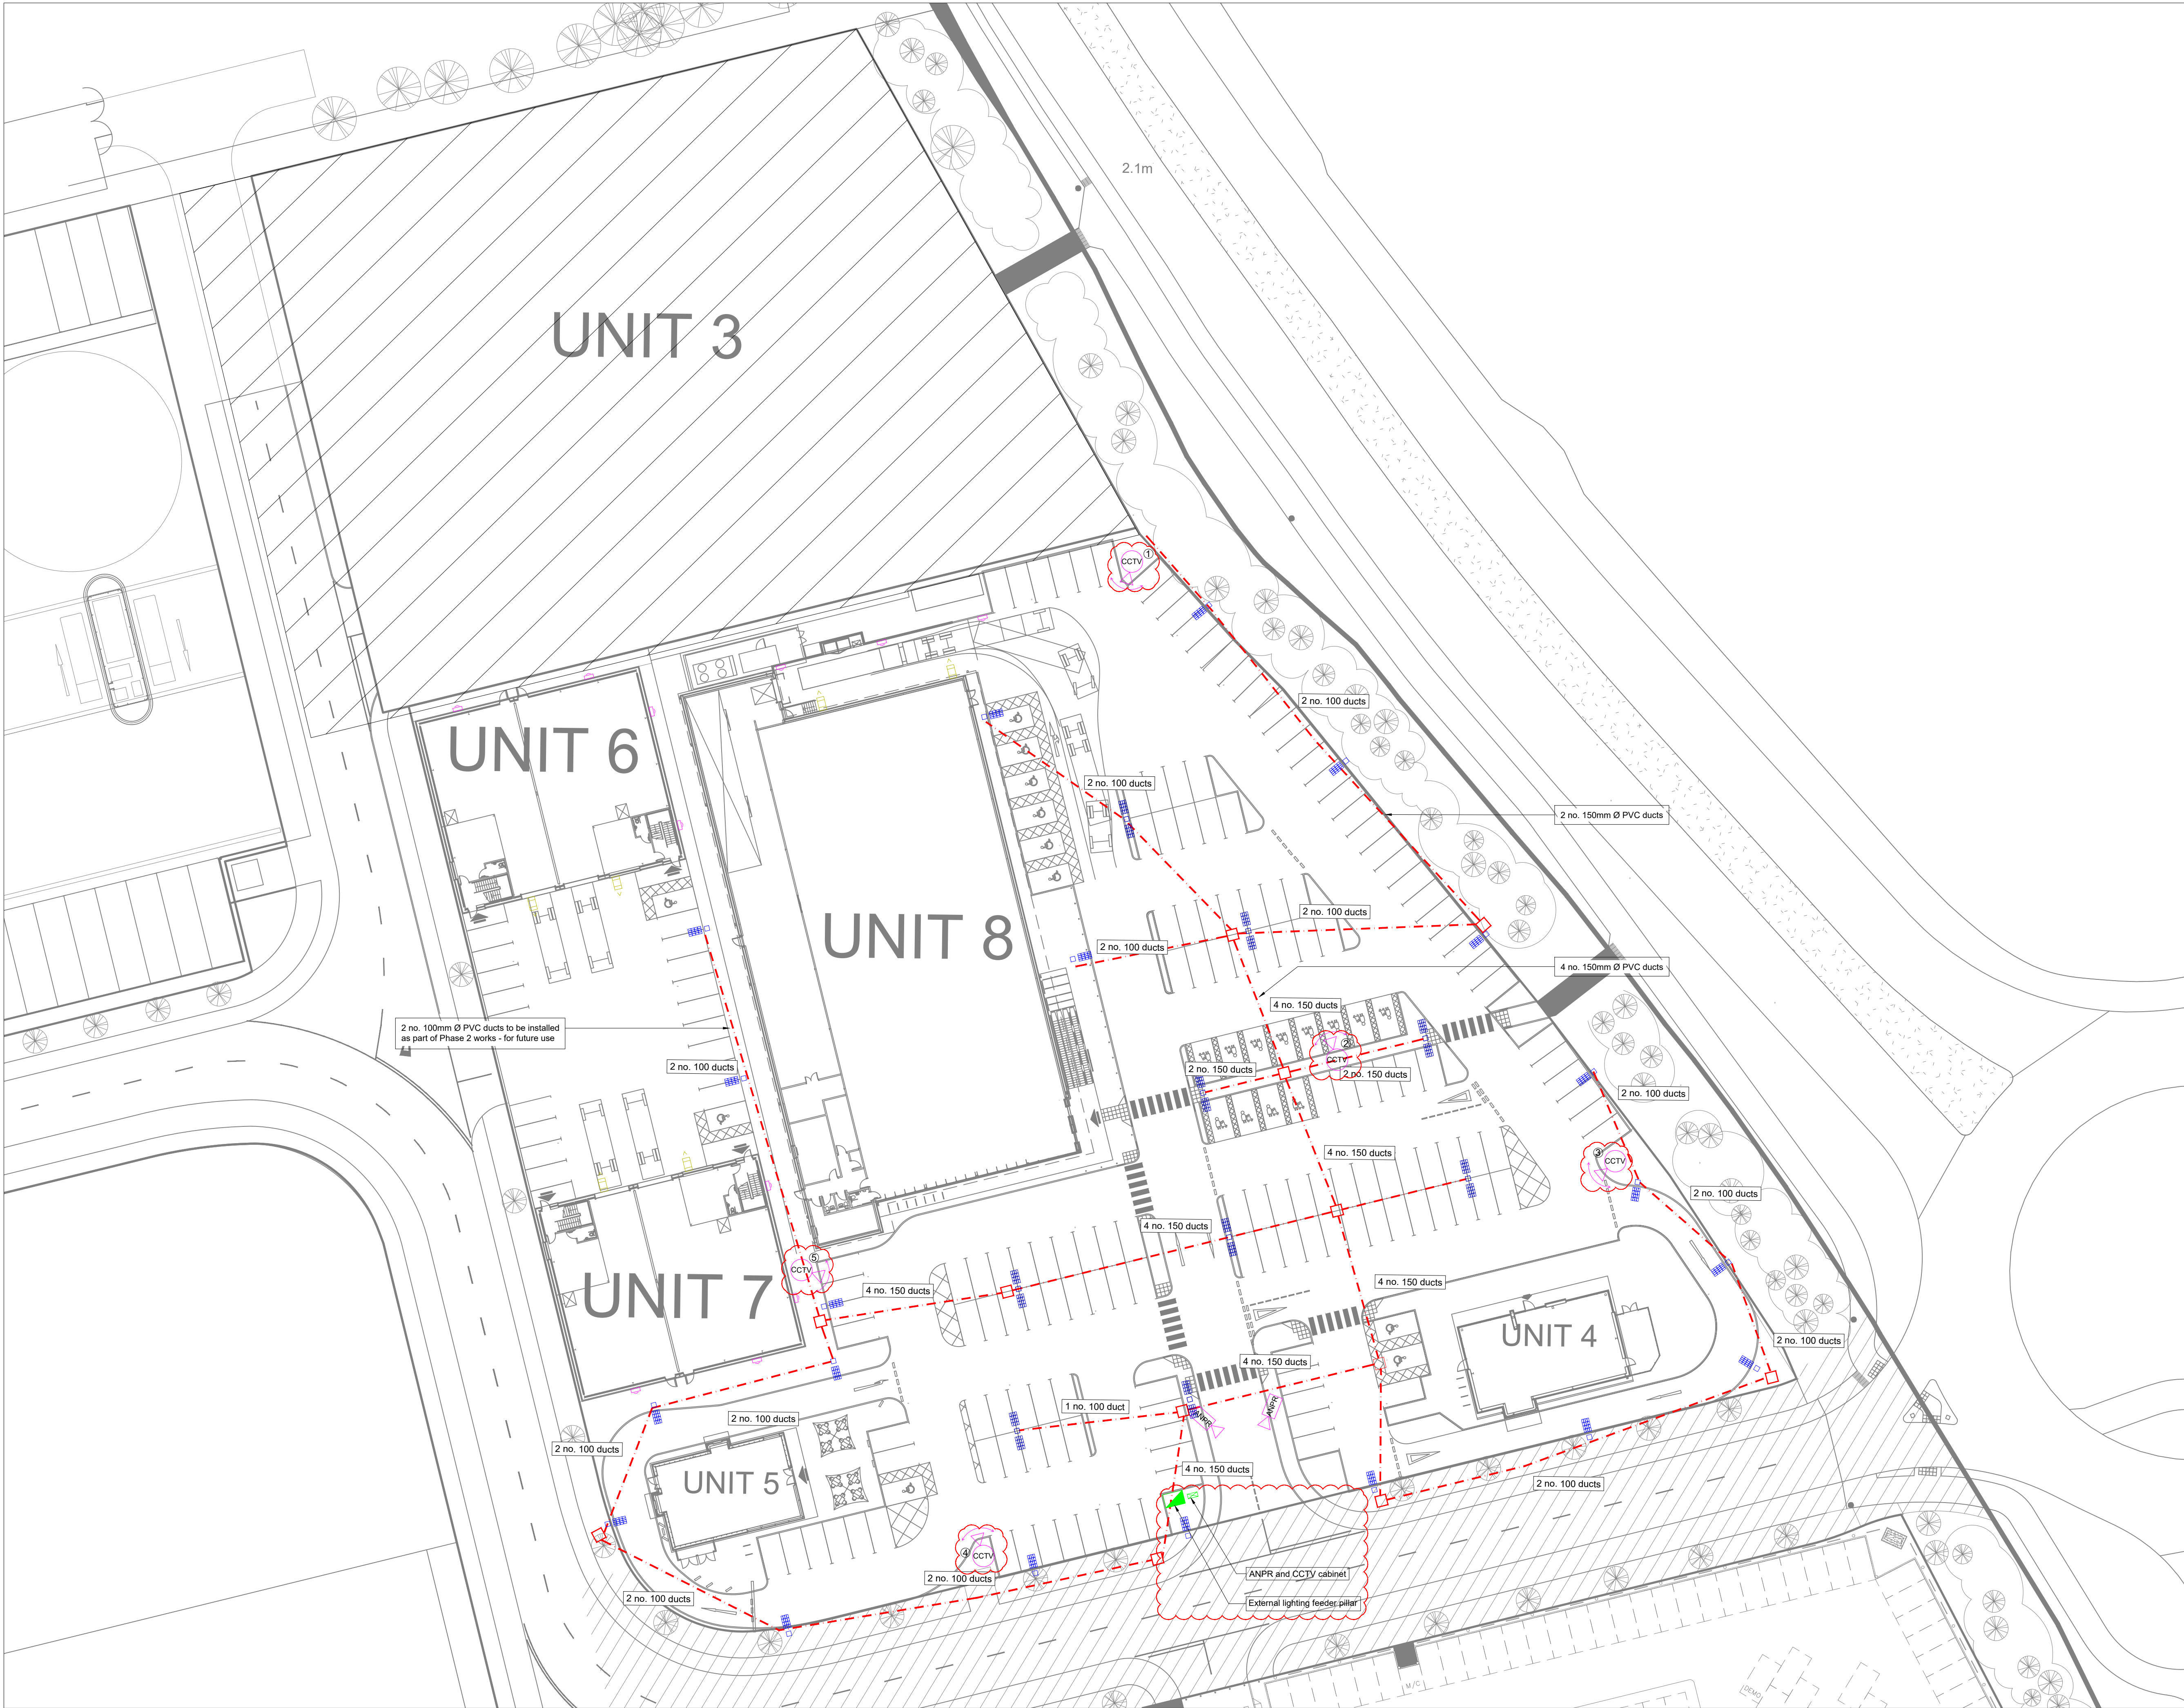

- Notes
- Cable draw pits shall be constructed by the main contractor. All sizes indicated refer to internal dimensions. Pits to have heavy duty, weather-proof covers
 - Cable duct specification as follows:
 - all buried ducts to be Ø150mm pvc unless stated;
 - all duct bends to have 'slow' bends;
 - all cable duct installations to include nylon draw wires;
 - duct entries in to draw pits are to incorporate bell mouths.
 - Minimum service depths (unless otherwise stated) below carriageways to be as follows:
 - BT = 450mm B.G.L
 - Electricity = 700mm B.G.L
 - Gas = 600mm B.G.L
 - Water = 900mm B.G.L
 - Minimum space between services under 2m footways to be as follows:
 - BT = 430mm from carriageway
 - Electricity - hv = 1500mm from carriageway
 - Electricity - lv = 1500 / 1720mm from carriageway
 - Gas = 960mm from carriageway
 - Water = 690mm from carriageway

Legend

- PVC rigiduct complete with nylon draw cords
- 800 x 800 cable draw pit
- ANPR ANPR camera
- CCTV 6m column mounted PTZ camera

3	22/06/2021	Site Layout Updated	KS	JB
2	11/02/2020	PTZ cameras added and cabinet locations revised	AP	JB
1	04/02/2020	Duct layout updated and ANPR cameras added	AP	JB
Rev	Date	Description	Cad CHK	

Architect
MountfordPigott
Architecture | Interiors | Design

Client
LandLink Estates

Project
Saltbox

Drawing Title
**Electrical Services
Sitewide
External Ducts and CCTV Layout**

ScotchPartners
Building Services Engineering | Sustainability | Acoustics
Scotch Court
107 Farringham Road
London EC1R 3AD
020 3544 5400
www.scotchpartners.com

Issue	Contract Issue		
Date	Nov 19	Scale @ A1	N.T.S
Drawn By	AP	Checked By	JB
Drawing No.	5163-SP-EX-120		
Rev	3		