


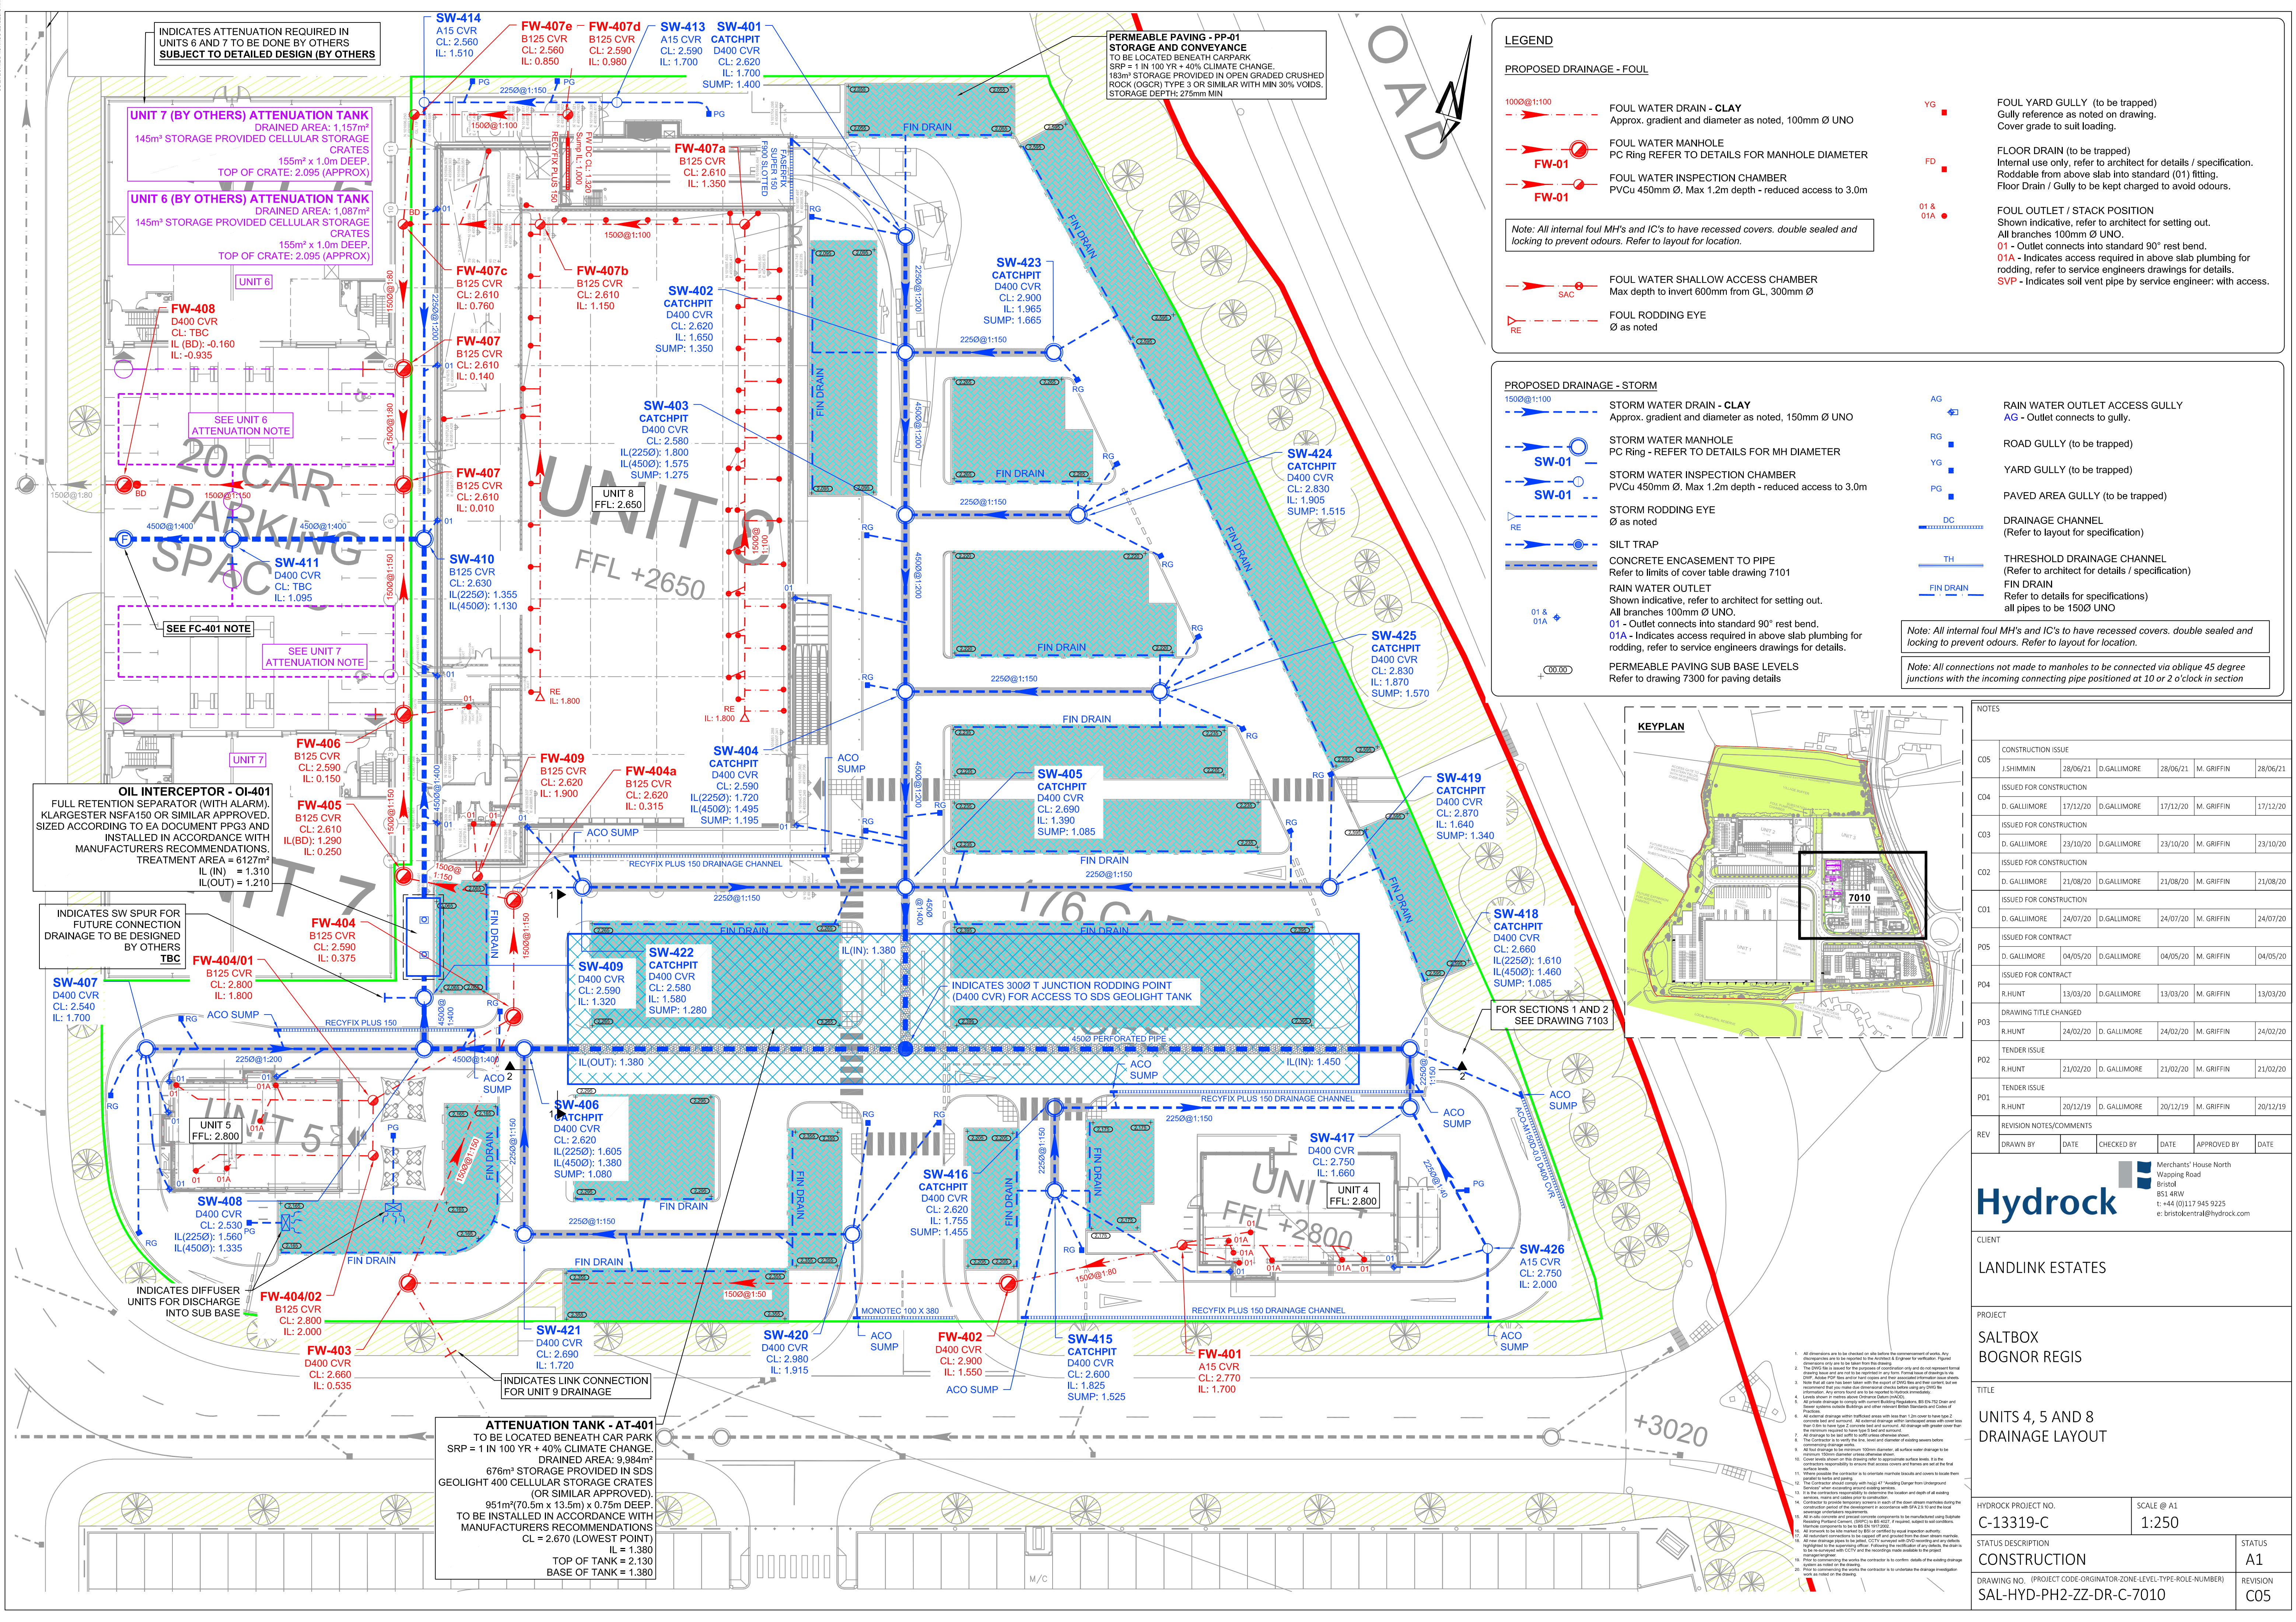

LEGEND

PROPOSED DRAINAGE - FOUL

- 1000@1:100 Foul Water Drain - Clay
- FW-01 Foul Water Manhole
- FW-01 Foul Water Inspection Chamber
- SAC Foul Water Shallow Access Chamber
- RE Foul Rodding Eye

PROPOSED DRAINAGE - STORM

- 1500@1:100 Storm Water Drain - Clay
- SW-01 Storm Water Manhole
- SW-01 Storm Water Inspection Chamber
- RE Storm Rodding Eye
- TH Threshold Drainage Channel
- FIN DRAIN

FOUL YARD GULLY (to be trapped)
Gully reference as noted on drawing.
Cover grade to suit loading.

FLOOR DRAIN (to be trapped)
Internal use only, refer to architect for details / specification.
Roddable from above slab into standard (01) fitting.
Floor Drain / Gully to be kept charged to avoid odours.

FOUL OUTLET / STACK POSITION
Shown indicative, refer to architect for setting out.
All branches 100mm Ø UNO.
01 - Outlet connects into standard 90° rest bend.
01A - Indicates access required in above slab plumbing for rodding, refer to service engineers drawings for details.
SVP - Indicates soil vent pipe by service engineer: with access.

RAIN WATER OUTLET ACCESS GULLY
AG - Outlet connects to gully.

ROAD GULLY (to be trapped)

YARD GULLY (to be trapped)

PAVED AREA GULLY (to be trapped)

DRAINAGE CHANNEL
(Refer to layout for specification)

THRESHOLD DRAINAGE CHANNEL
(Refer to architect for details / specification)

FIN DRAIN
Refer to details for specifications
all pipes to be 150Ø UNO

Note: All internal foul MH's and IC's to have recessed covers. double sealed and locking to prevent odours. Refer to layout for location.

Note: All connections not made to manholes to be connected via oblique 45 degree junctions with the incoming connecting pipe positioned at 10 or 2 o'clock in section

KEYPLAN

FOR SECTIONS 1 AND 2
SEE DRAWING 7103

NOTES

CD5	CONSTRUCTION ISSUE	J.SHIMMIN	28/06/21	D.GALLIMORE	28/06/21	M. GRIFFIN	28/06/21
CD4	ISSUED FOR CONSTRUCTION	D. GALLIMORE	17/12/20	D. GALLIMORE	17/12/20	M. GRIFFIN	17/12/20
CD3	ISSUED FOR CONSTRUCTION	D. GALLIMORE	23/10/20	D. GALLIMORE	23/10/20	M. GRIFFIN	23/10/20
CD2	ISSUED FOR CONSTRUCTION	D. GALLIMORE	21/08/20	D. GALLIMORE	21/08/20	M. GRIFFIN	21/08/20
CD1	ISSUED FOR CONSTRUCTION	D. GALLIMORE	24/07/20	D. GALLIMORE	24/07/20	M. GRIFFIN	24/07/20
PO5	ISSUED FOR CONTRACT	D. GALLIMORE	04/05/20	D. GALLIMORE	04/05/20	M. GRIFFIN	04/05/20
PO4	ISSUED FOR CONTRACT	R. HUNT	13/03/20	D. GALLIMORE	13/03/20	M. GRIFFIN	13/03/20
PO3	DRAWING TITLE CHANGED	R. HUNT	24/02/20	D. GALLIMORE	24/02/20	M. GRIFFIN	24/02/20
PO2	TENDER ISSUE	R. HUNT	21/02/20	D. GALLIMORE	21/02/20	M. GRIFFIN	21/02/20
PO1	TENDER ISSUE	R. HUNT	20/12/19	D. GALLIMORE	20/12/19	M. GRIFFIN	20/12/19
REV	REVISION NOTES/COMMENTS	DRAWN BY	DATE	CHECKED BY	DATE	APPROVED BY	DATE

Hydrock

Client: LANDLINK ESTATES

Project: SALTBOX BOGNOR REGIS

Title: UNITS 4, 5 AND 8 DRAINAGE LAYOUT

Hydrock Project No: C-13319-C

Scale: 1:250

Status: CONSTRUCTION

Drawing No: SAL-HYD-PH2-ZZ-DR-C-7010

Status: A1

Revision: C05