



General Notes:


1. Do not scale from this drawing.
2. All dimensions in metres.
3. Extent of outlet protection to be the greater of 1500mm or pipe diameter + 1200mm spanning the outlet pipe.
4. All exposed pipework to be UV stable.
5. Headwall construction detail in accordance with West Sussex County Council drawing no. S278/38/24 revision A.

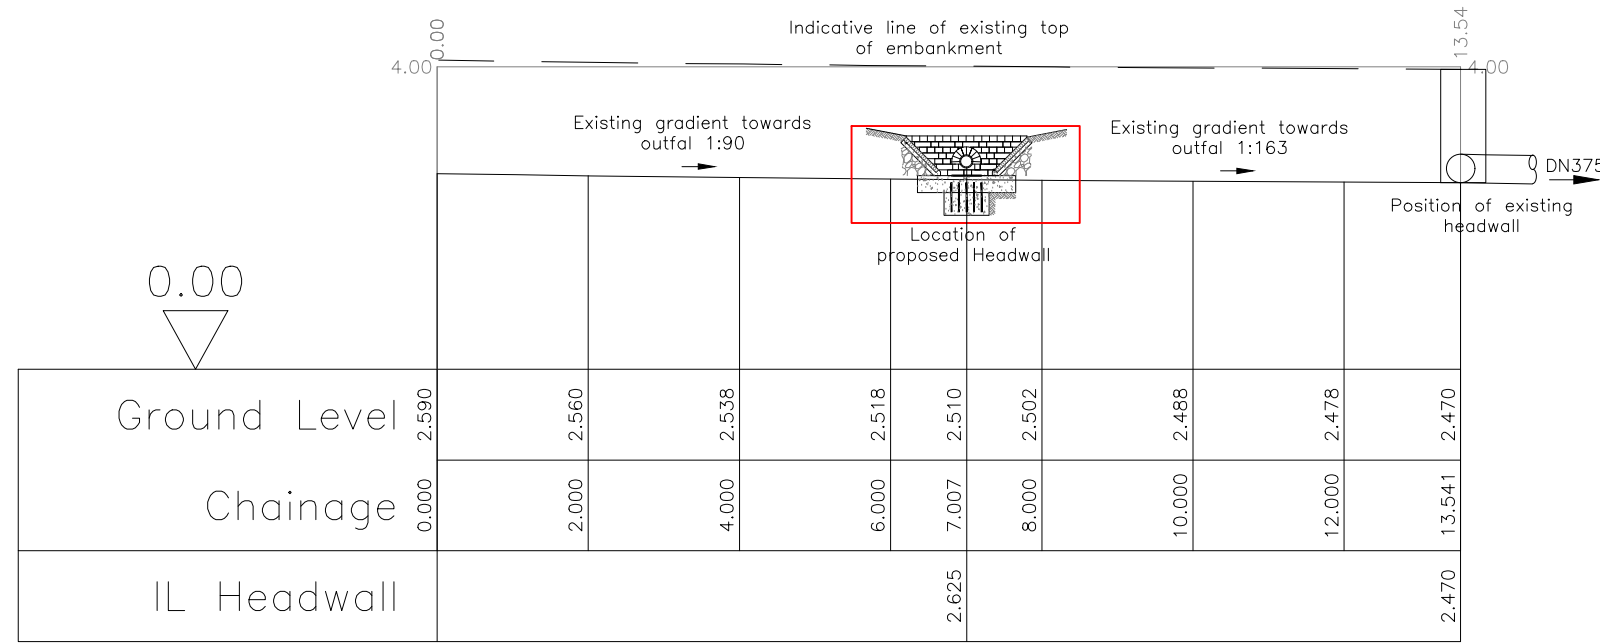


Ditch Section A-A
Horiz. 1:100
Vert. 1:100

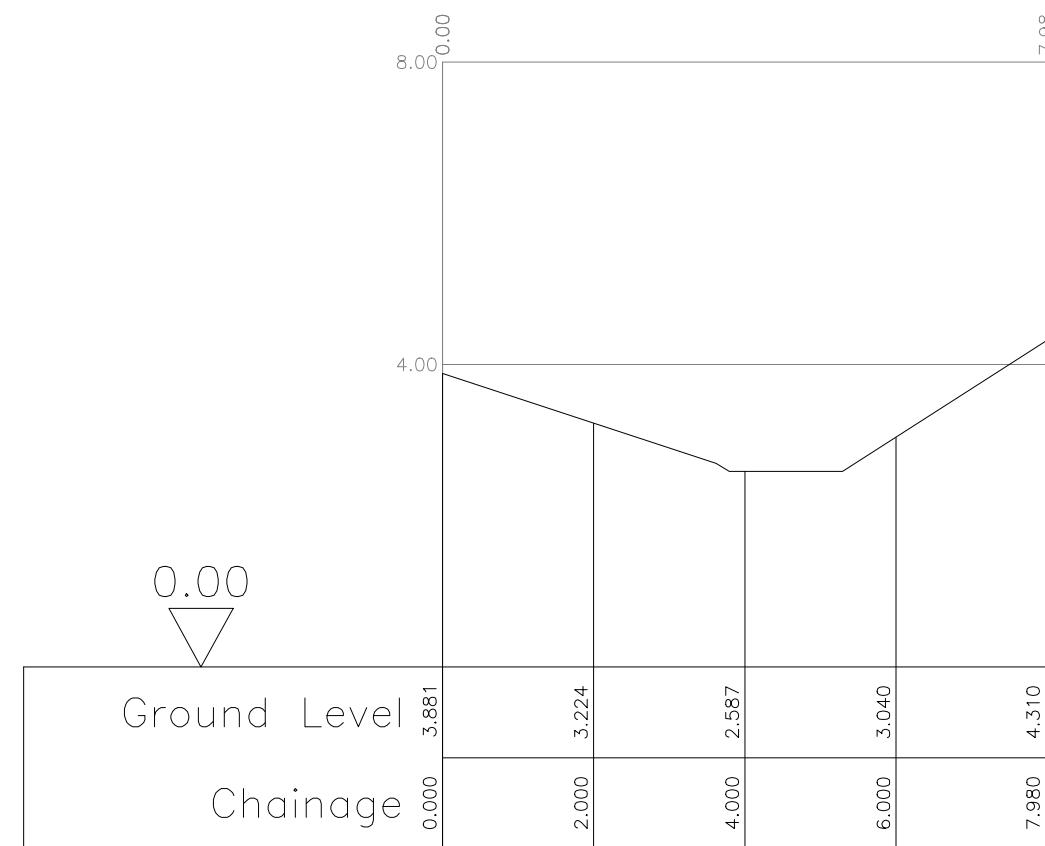



Ditch Section B-B
Horiz. 1:100
Vert. 1:100

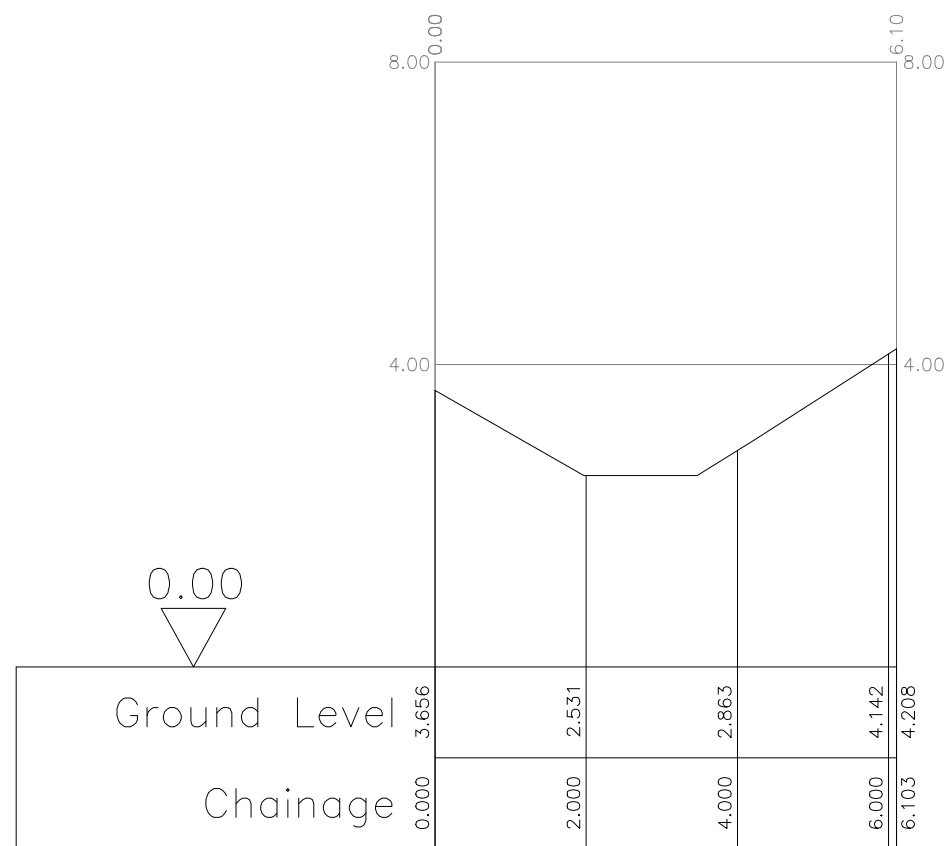


Ditch Section C-C
Horiz. 1:100
Vert. 1:100

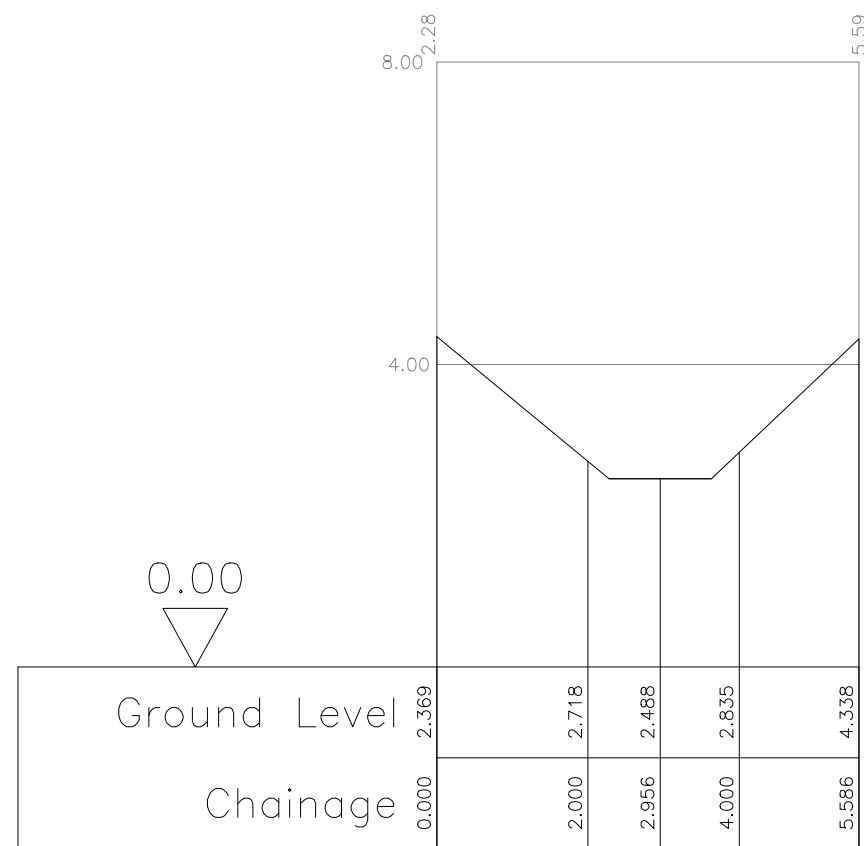


Ditch Section D-D
Horiz. 1:100
Vert. 1:100

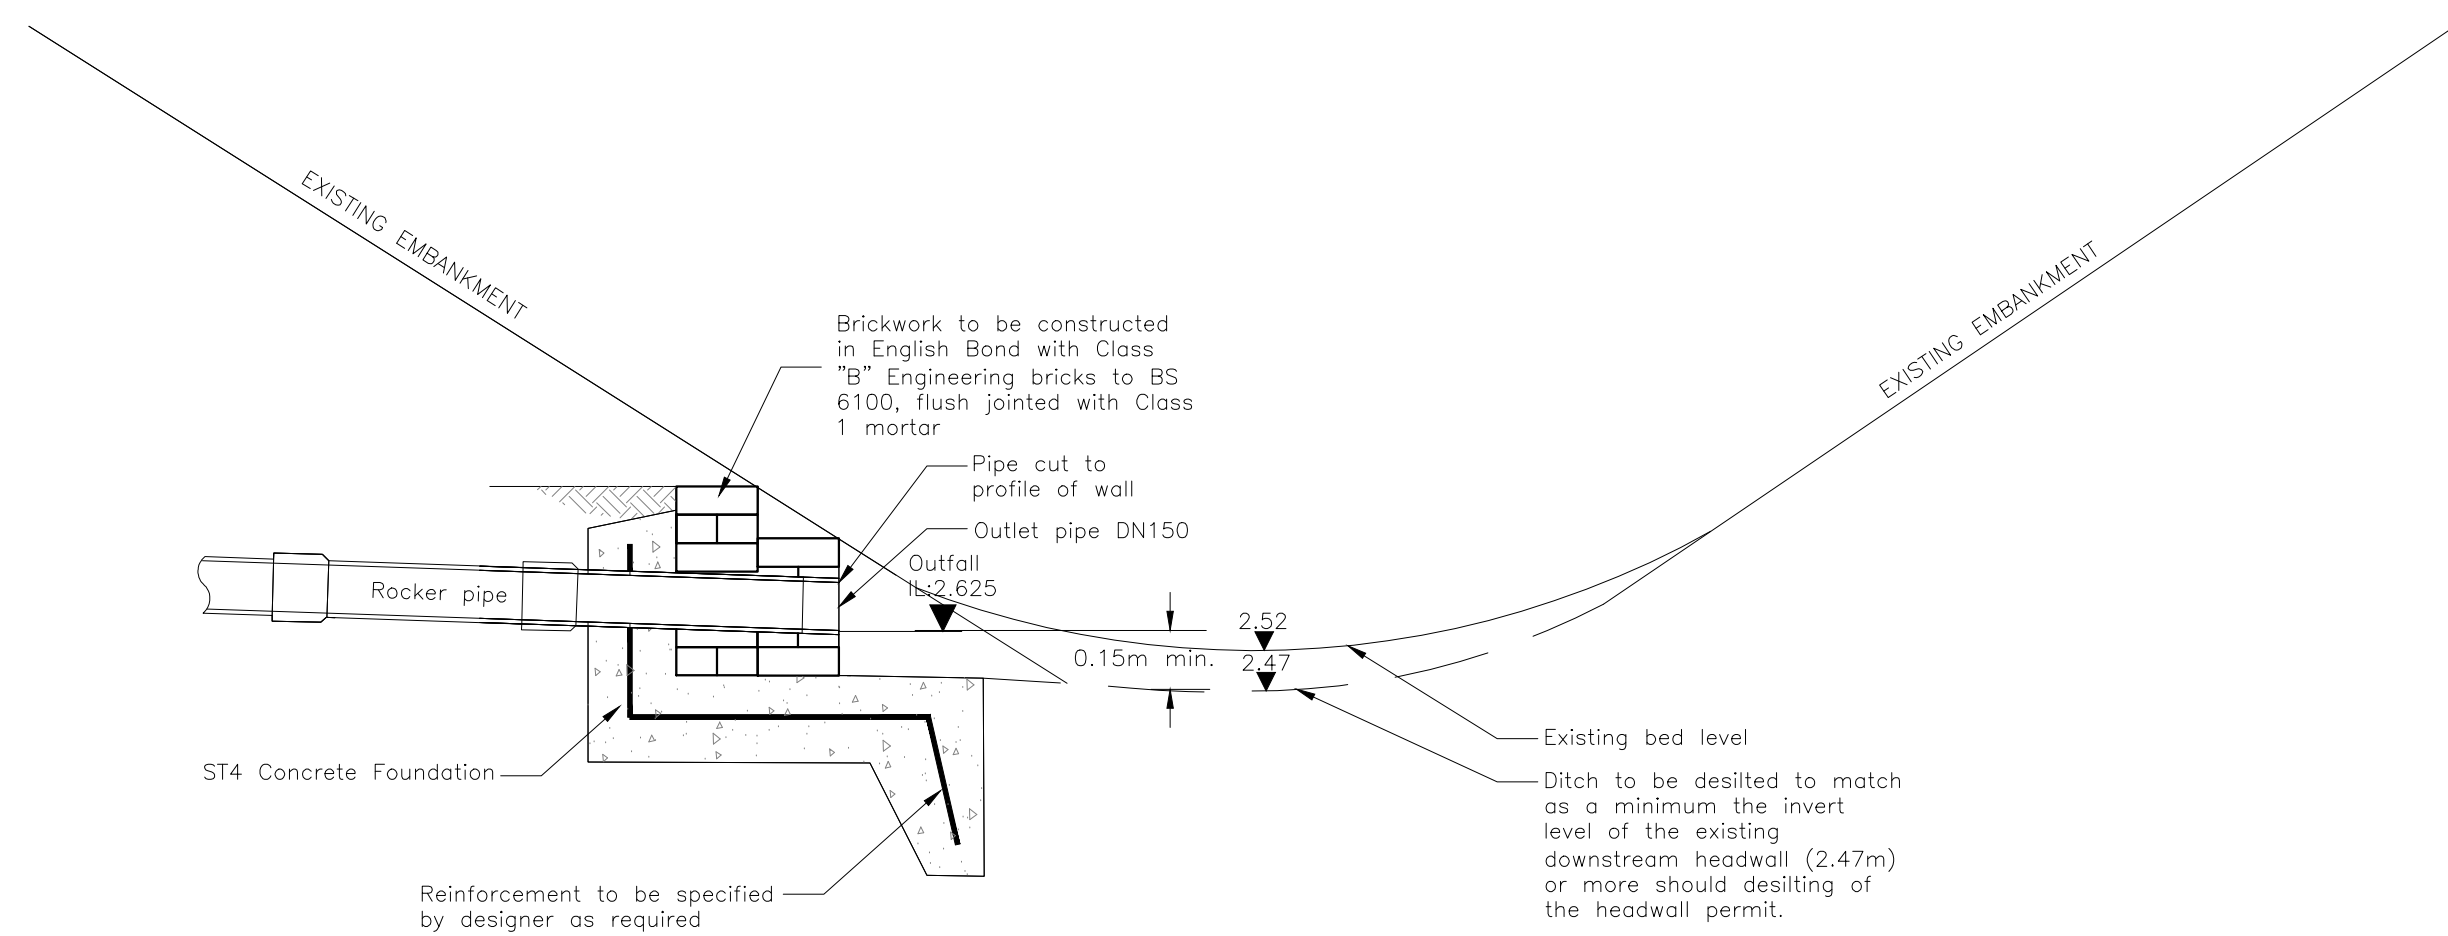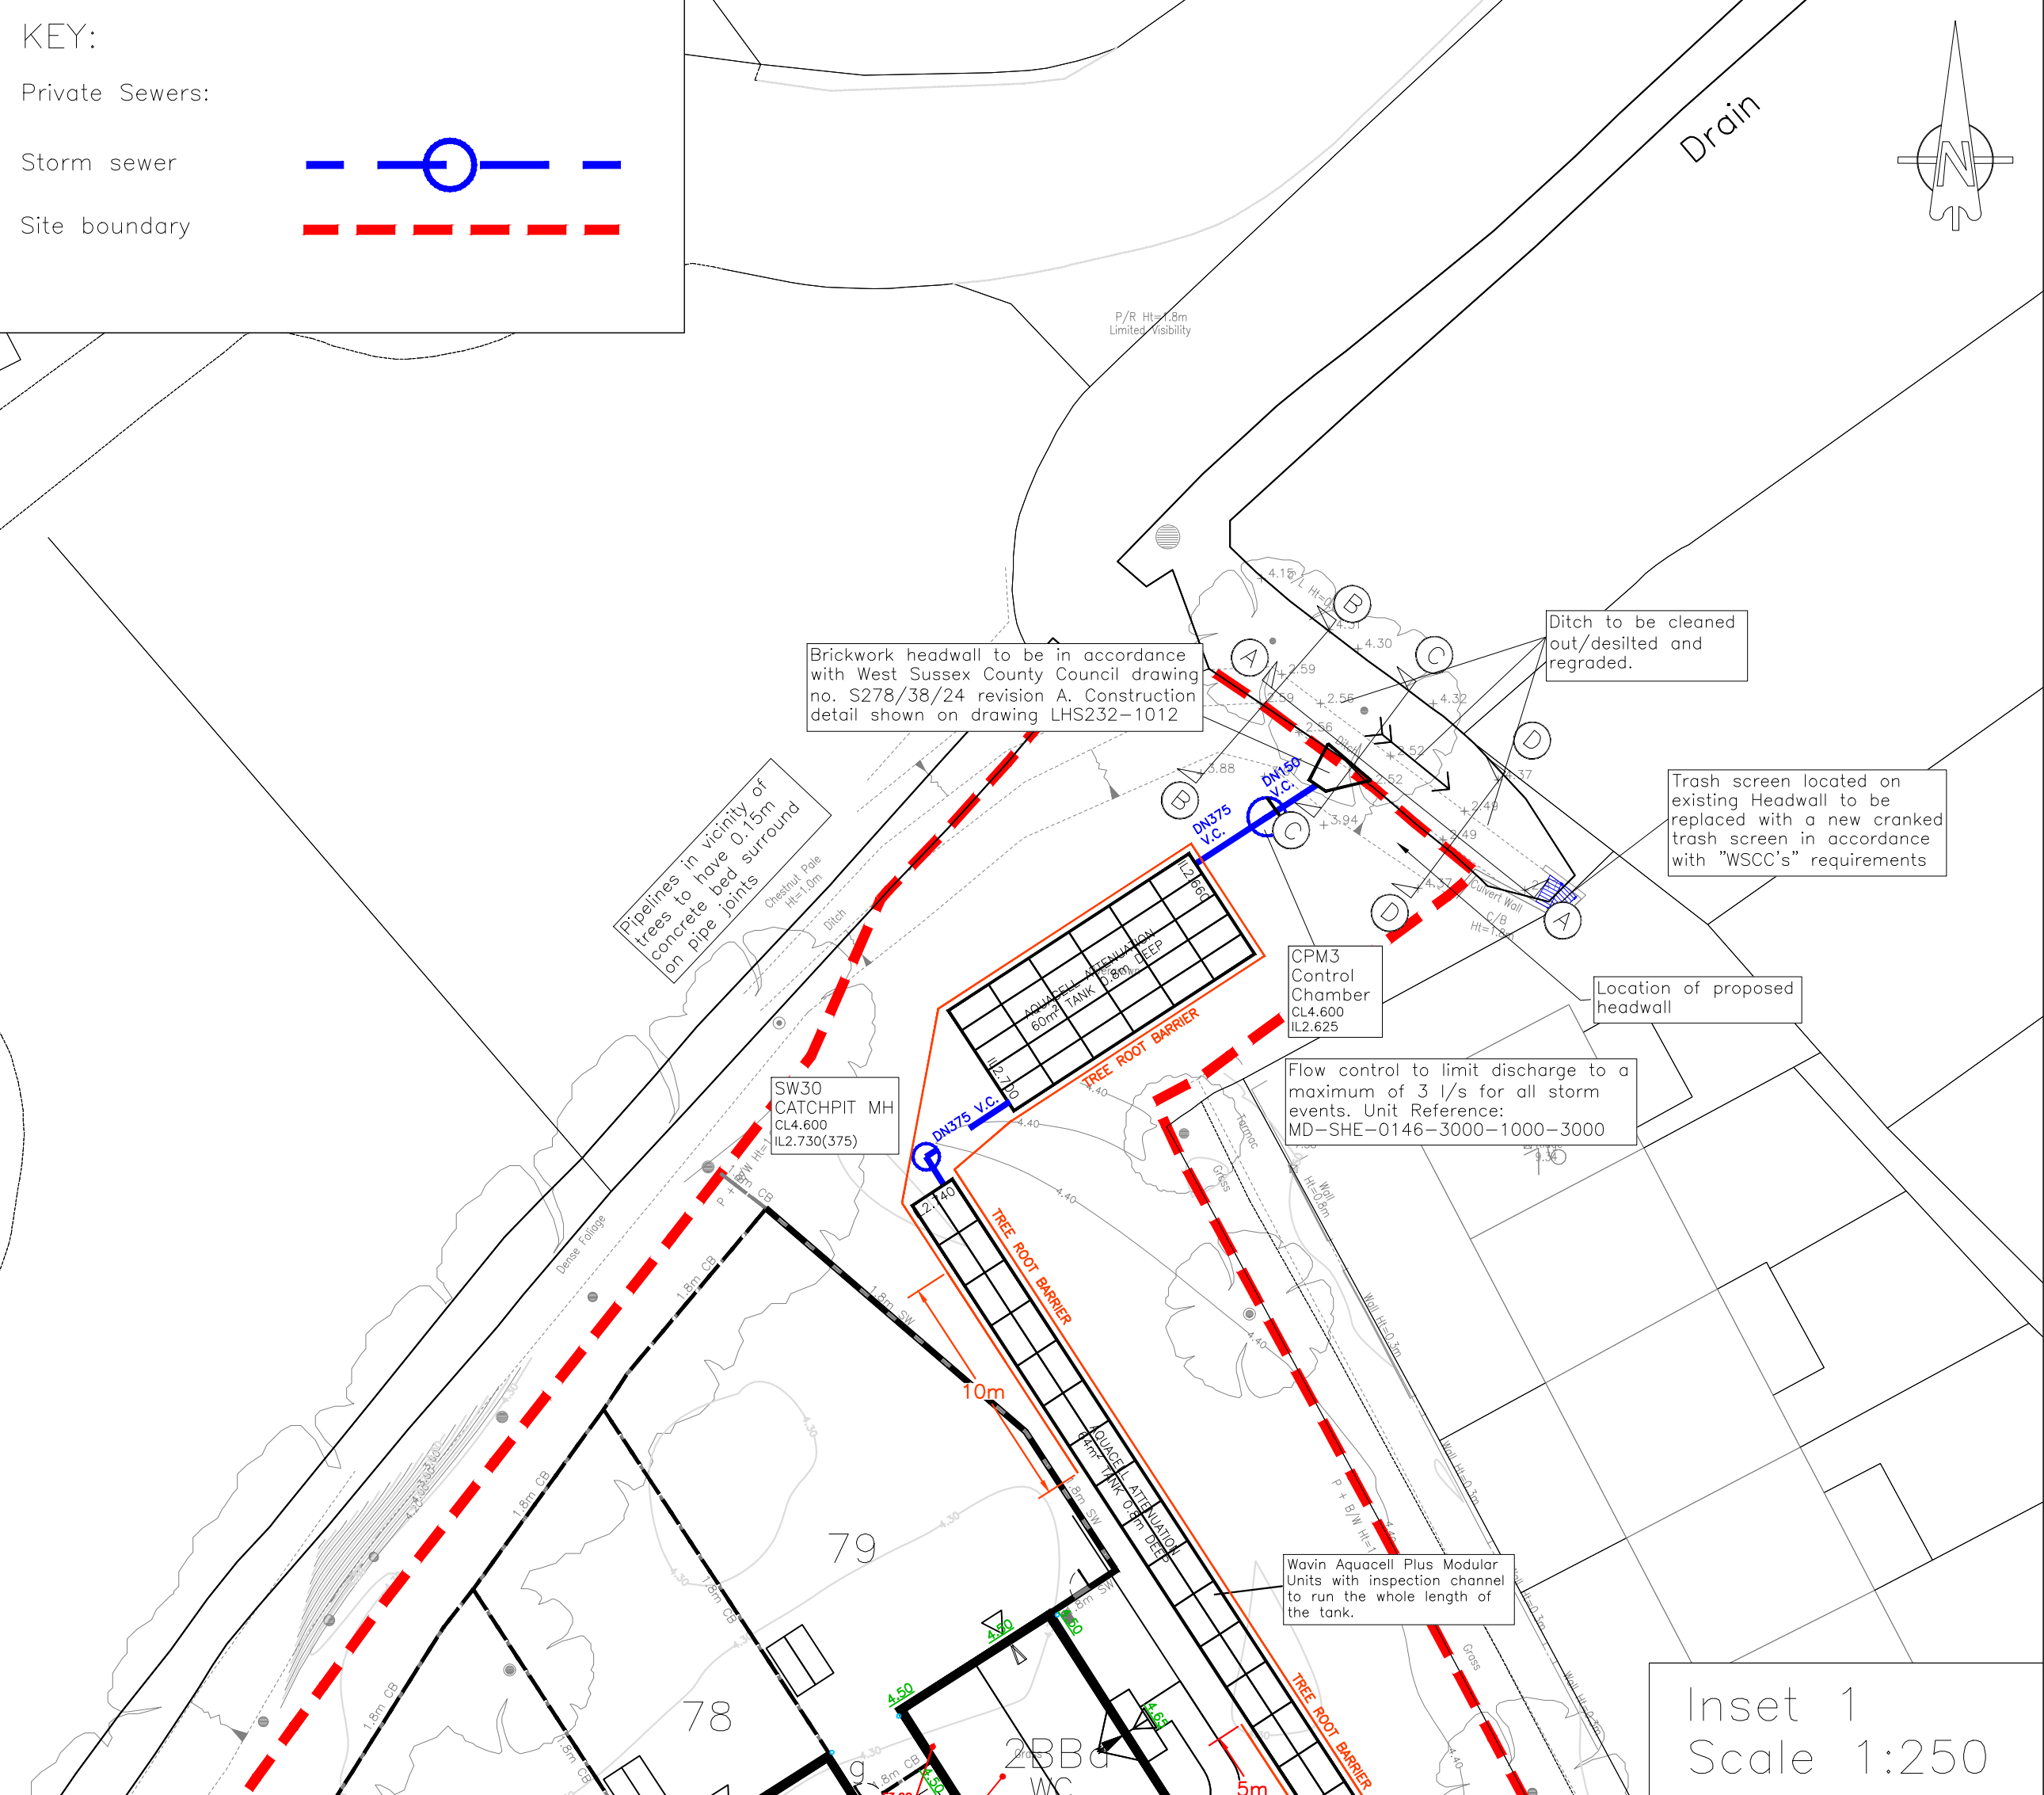



CONNECTION OF HEADWALL TO DRAINAGE DITCH
SCALE 1:20

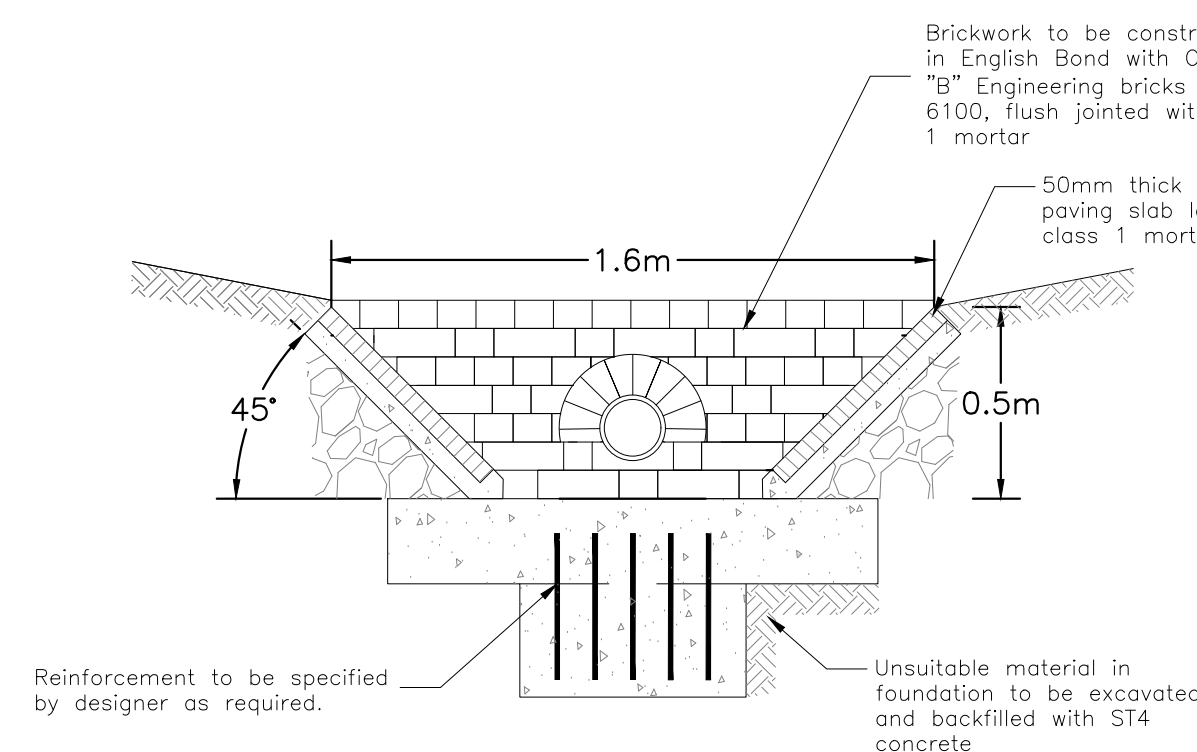

ELEVATION OF HEADWALL
OUTFALL TO END OF DITCH
SCALE 1:20

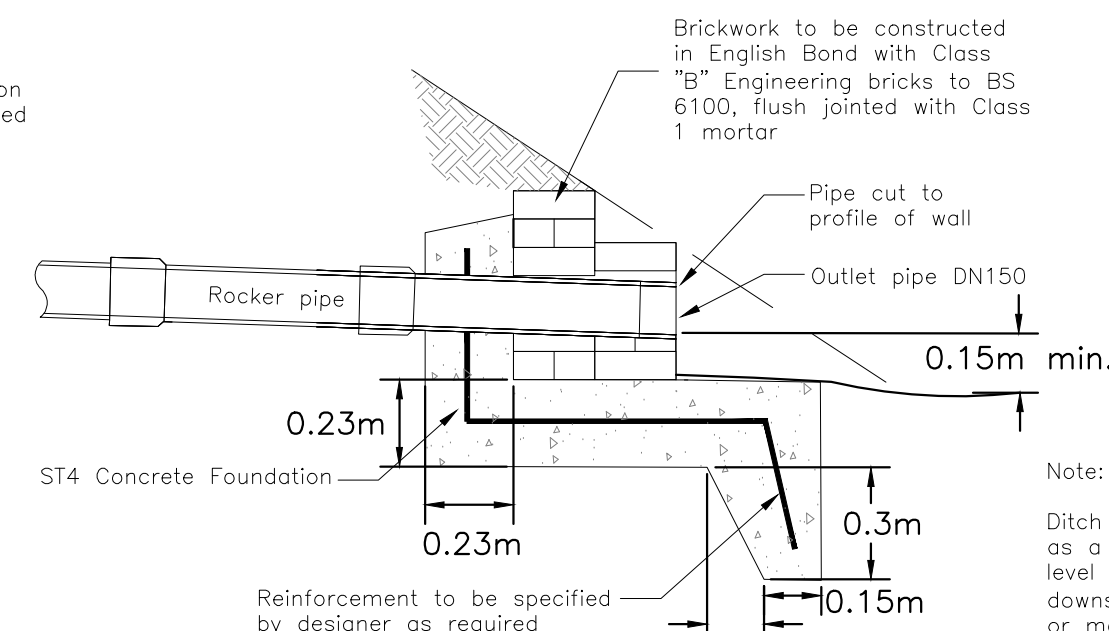

HEADWALL SECTION OUTFALL
TO POND/END OF DITCH
SCALE 1:20

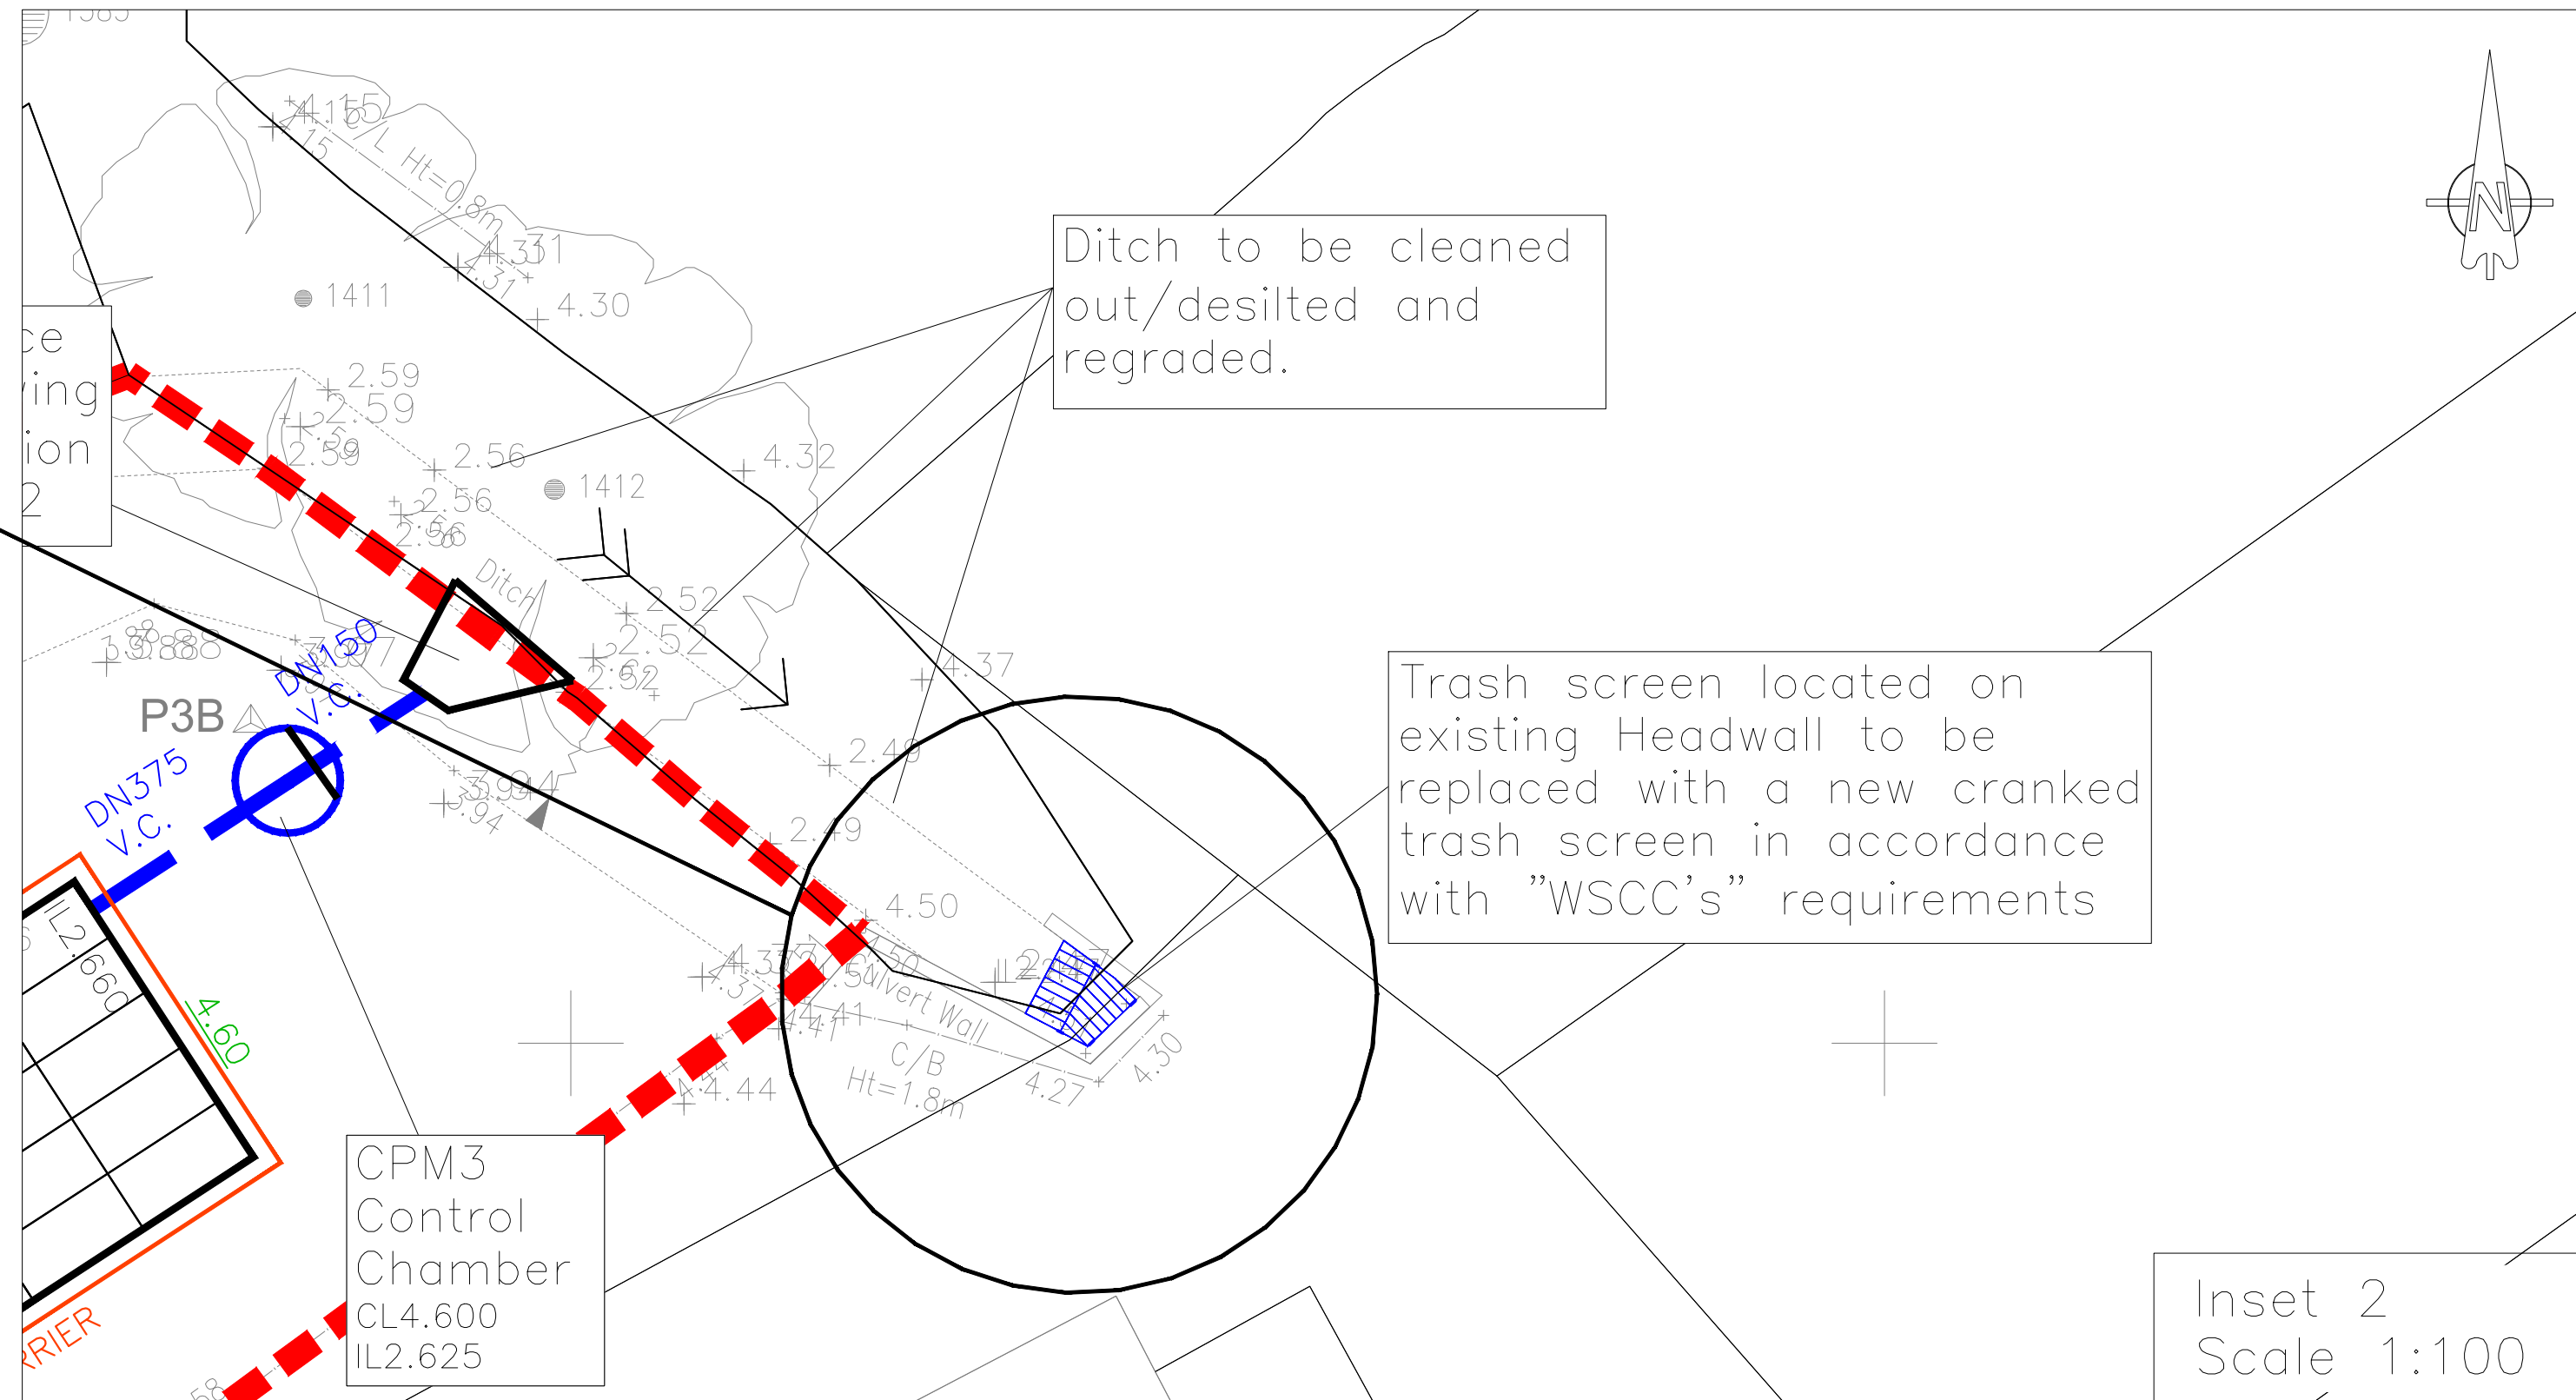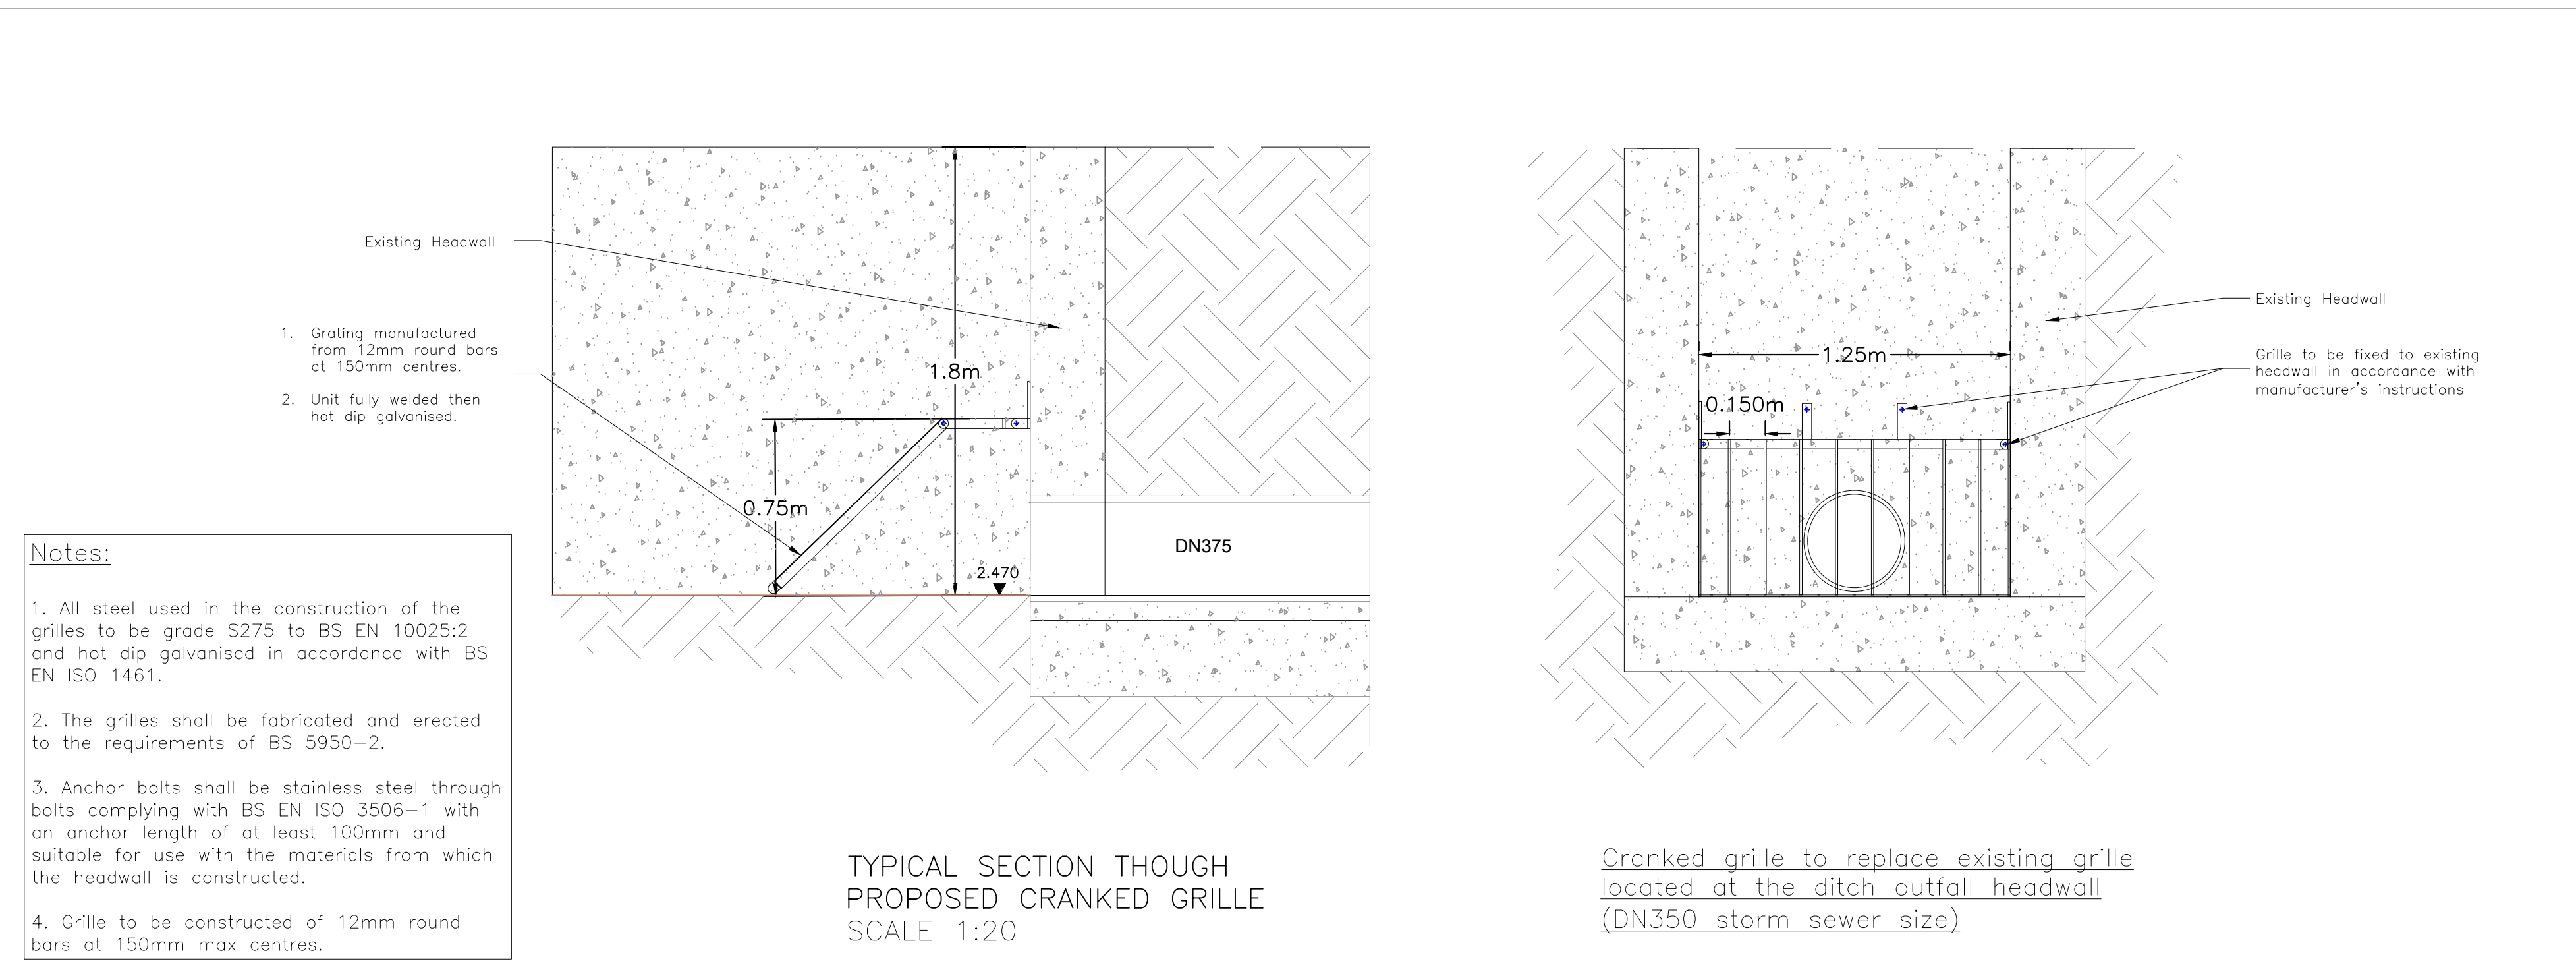

PRELIMINARY - FOR APPROVAL				
D	14.02.19	Longsection revised, cranked grill revised and inset 2 added to drawing.	JRV	
C	11.02.19	Inset updated in accordance with revised drainage strategy drawings. Headwall construction detail and sections revised in accordance with Arun CC's comments. Cranked grill added to drawing.	JRV	
B	04.12.18	Arrangement of attenuation tank 1 revised.	JRV	
A	20.11.18	Proposed headwall construction detail and sections revised as instructed by Arun D.C.	JRV	
REV. No.	DATE	DESCRIPTION	INITIALS	
Client				
Project New Barn lane North Bersted		MJA CONSULTING CIVIL AND STRUCTURAL ENGINEERS Monarch House, Barton Lane, Abingdon, Oxon, OX14 3NB Tel: 01235 555173 Fax: 01235 523226		
Title Sections Through Existing Ditch and Proposed Headwall		Scale As shown@A1	Date Apr'18	Drawing No. LHS232-1012
Checked KTG		Drawn JRV	Rev D	