


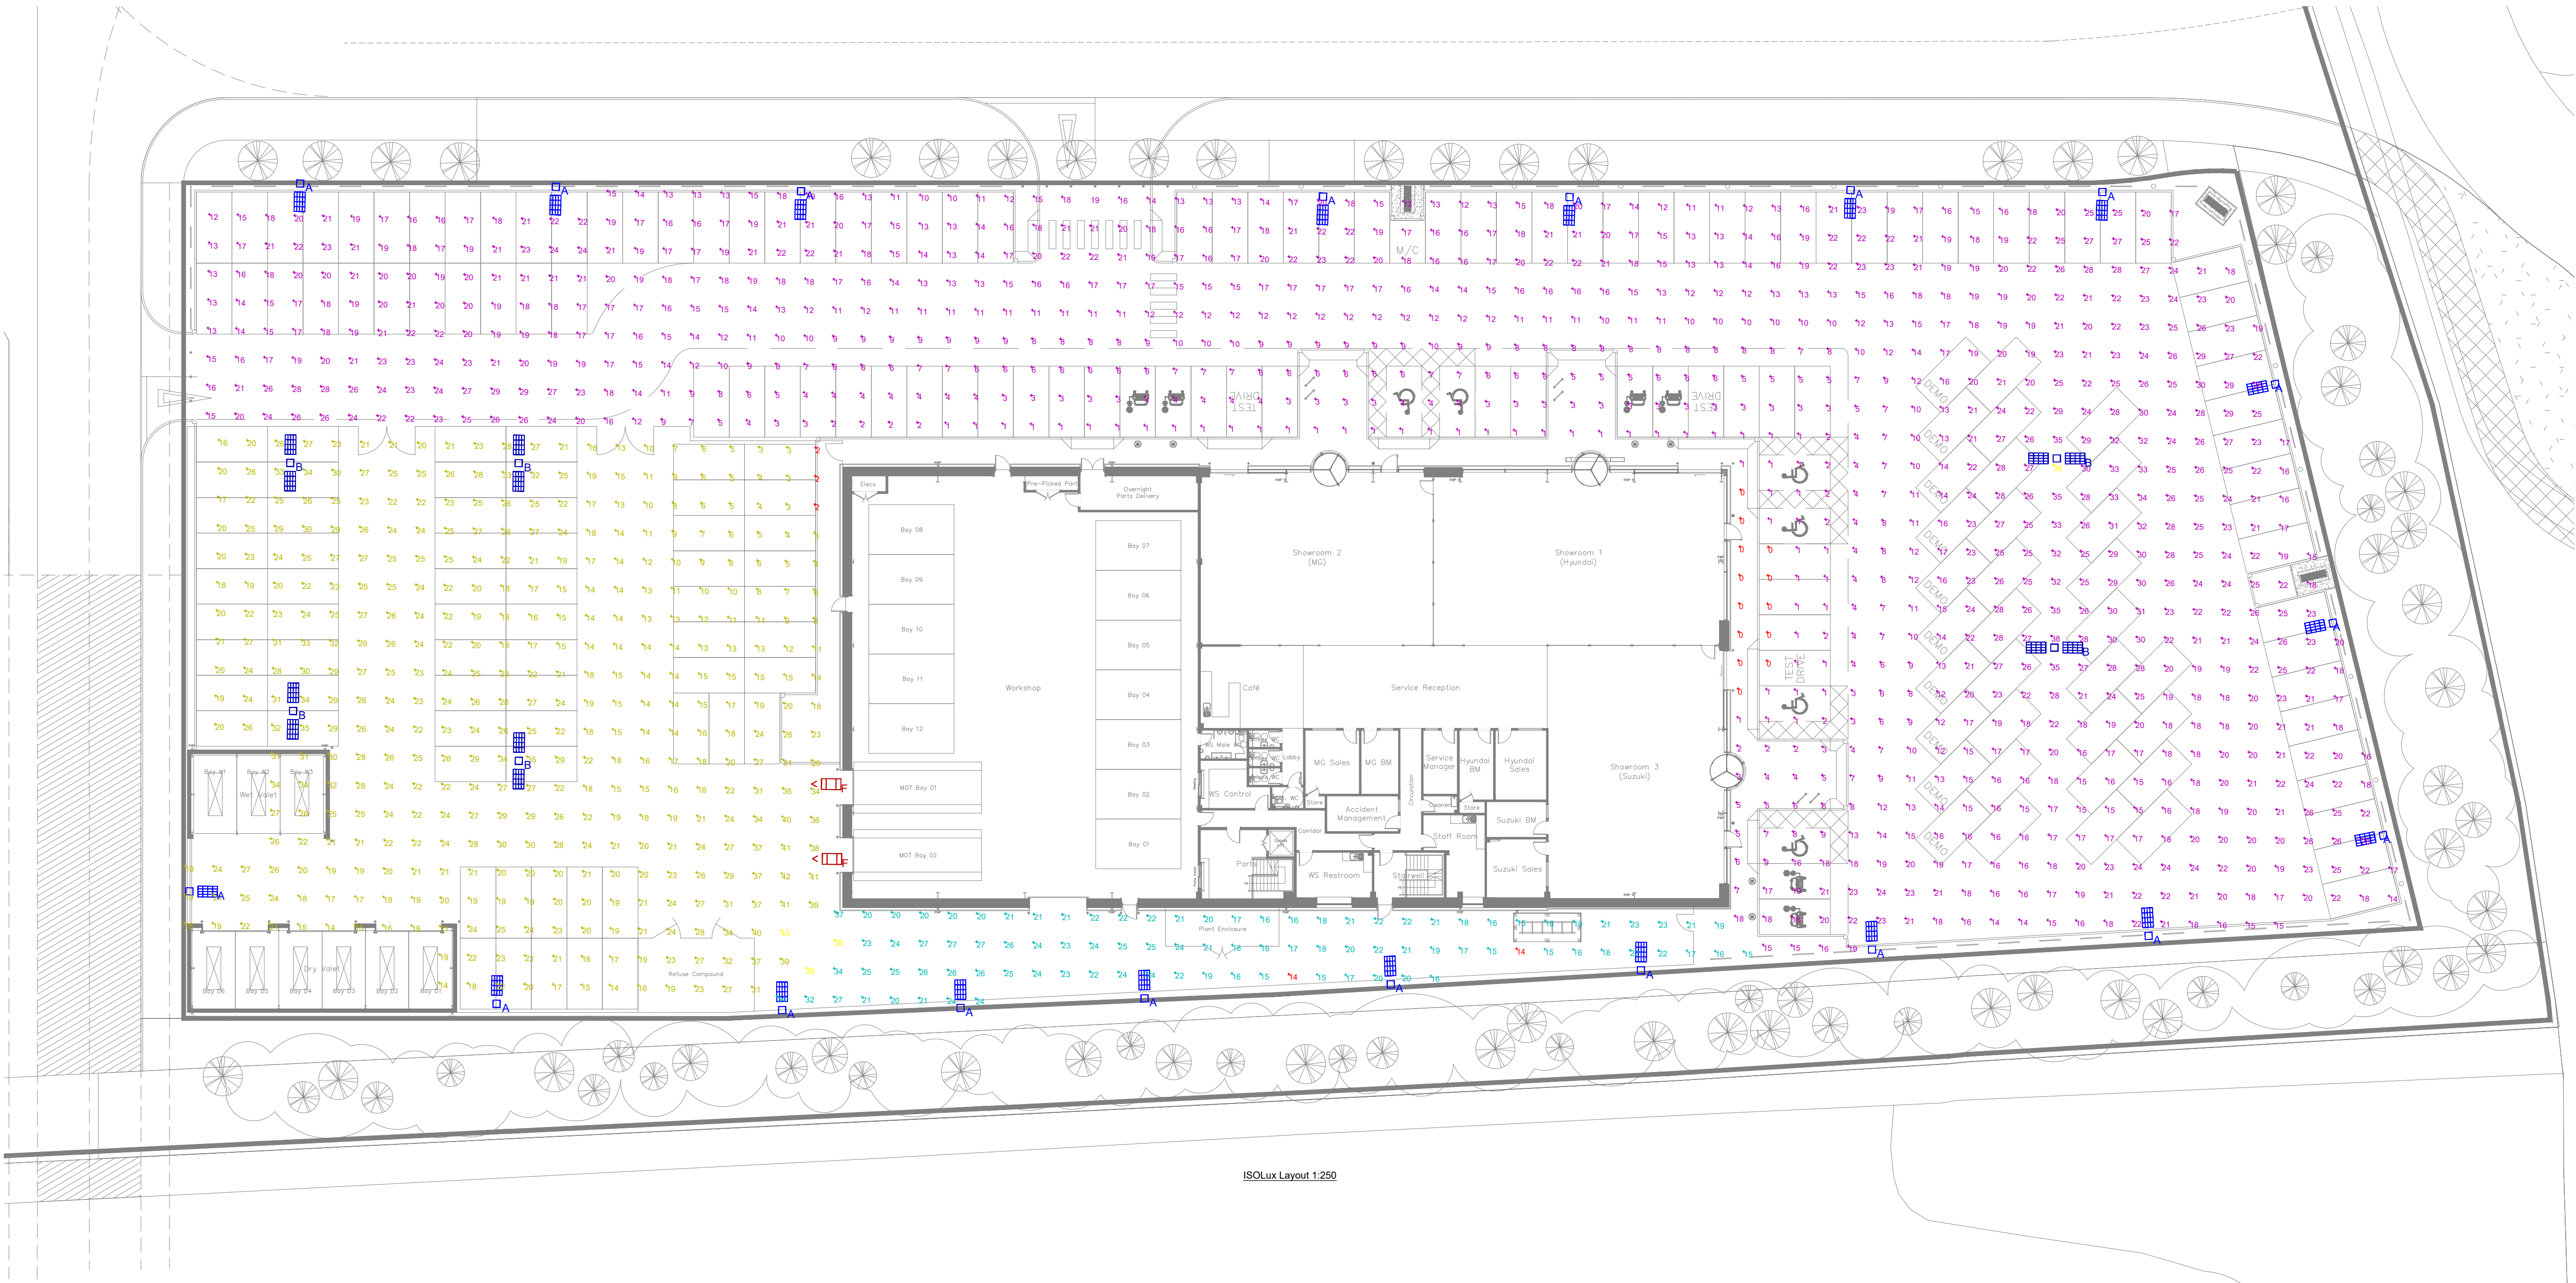

LUMINAIRE SCHEDULE									
Symbol	Label	Qty	Catalog Number	Description	Lamp	File	Lumens	LLF	Watts
	A	20	FTS.2.LA054.AY	FACTOR SMALL STREETLIGHT Single Head Column mount at 6m	LED C.5000LM-4000K	FTS.2.LA054.A.Y.ies	Absolute	0.90	35
	B	6	FTS.2.LA054.AY	FACTOR SMALL STREETLIGHT Twin Head column mount at 6m	LED C.5000LM-4000K	FTS.2.LA054.A.Y.ies	Absolute	0.90	70
	F	2	FTS.2.LA054.AY	FACTOR SMALL STREETLIGHT Single Head Column mount at 6m	LED C.5000LM-4000K	FTS.2.LA054.A.Y.ies	Absolute	0.90	35

STATISTICS					
Description	Symbol	Avg	Max	Min	Min/Avg
Access Area	+	22 lux	38 lux	14 lux	0.64
Car Park	+	16 lux	39 lux	0 lux	0.00
Service Yard Car Park	+	21 lux	43 lux	2 lux	0.10



A Type light fitting



D Type light fitting

Rev	Date	Description	Cad	Chk
-----	------	-------------	-----	-----



Client
Richmond Motor Group

Project
RMG Showroom

Drawing Title
Electrical Services
External Lighting
Isolux Plot



Building Services Engineering | Sustainability | Acoustics
ScotchPartners
107 Farringham Road
London EC1R 3AD
020 3544 5400
www.scotchpartners.com

Issue	Date	Scale	Rev
Planning	Nov 18	@ A1	P0
Drawn By	MW	Checked By	JB
Drawing No.	5203-SP-E-151		