


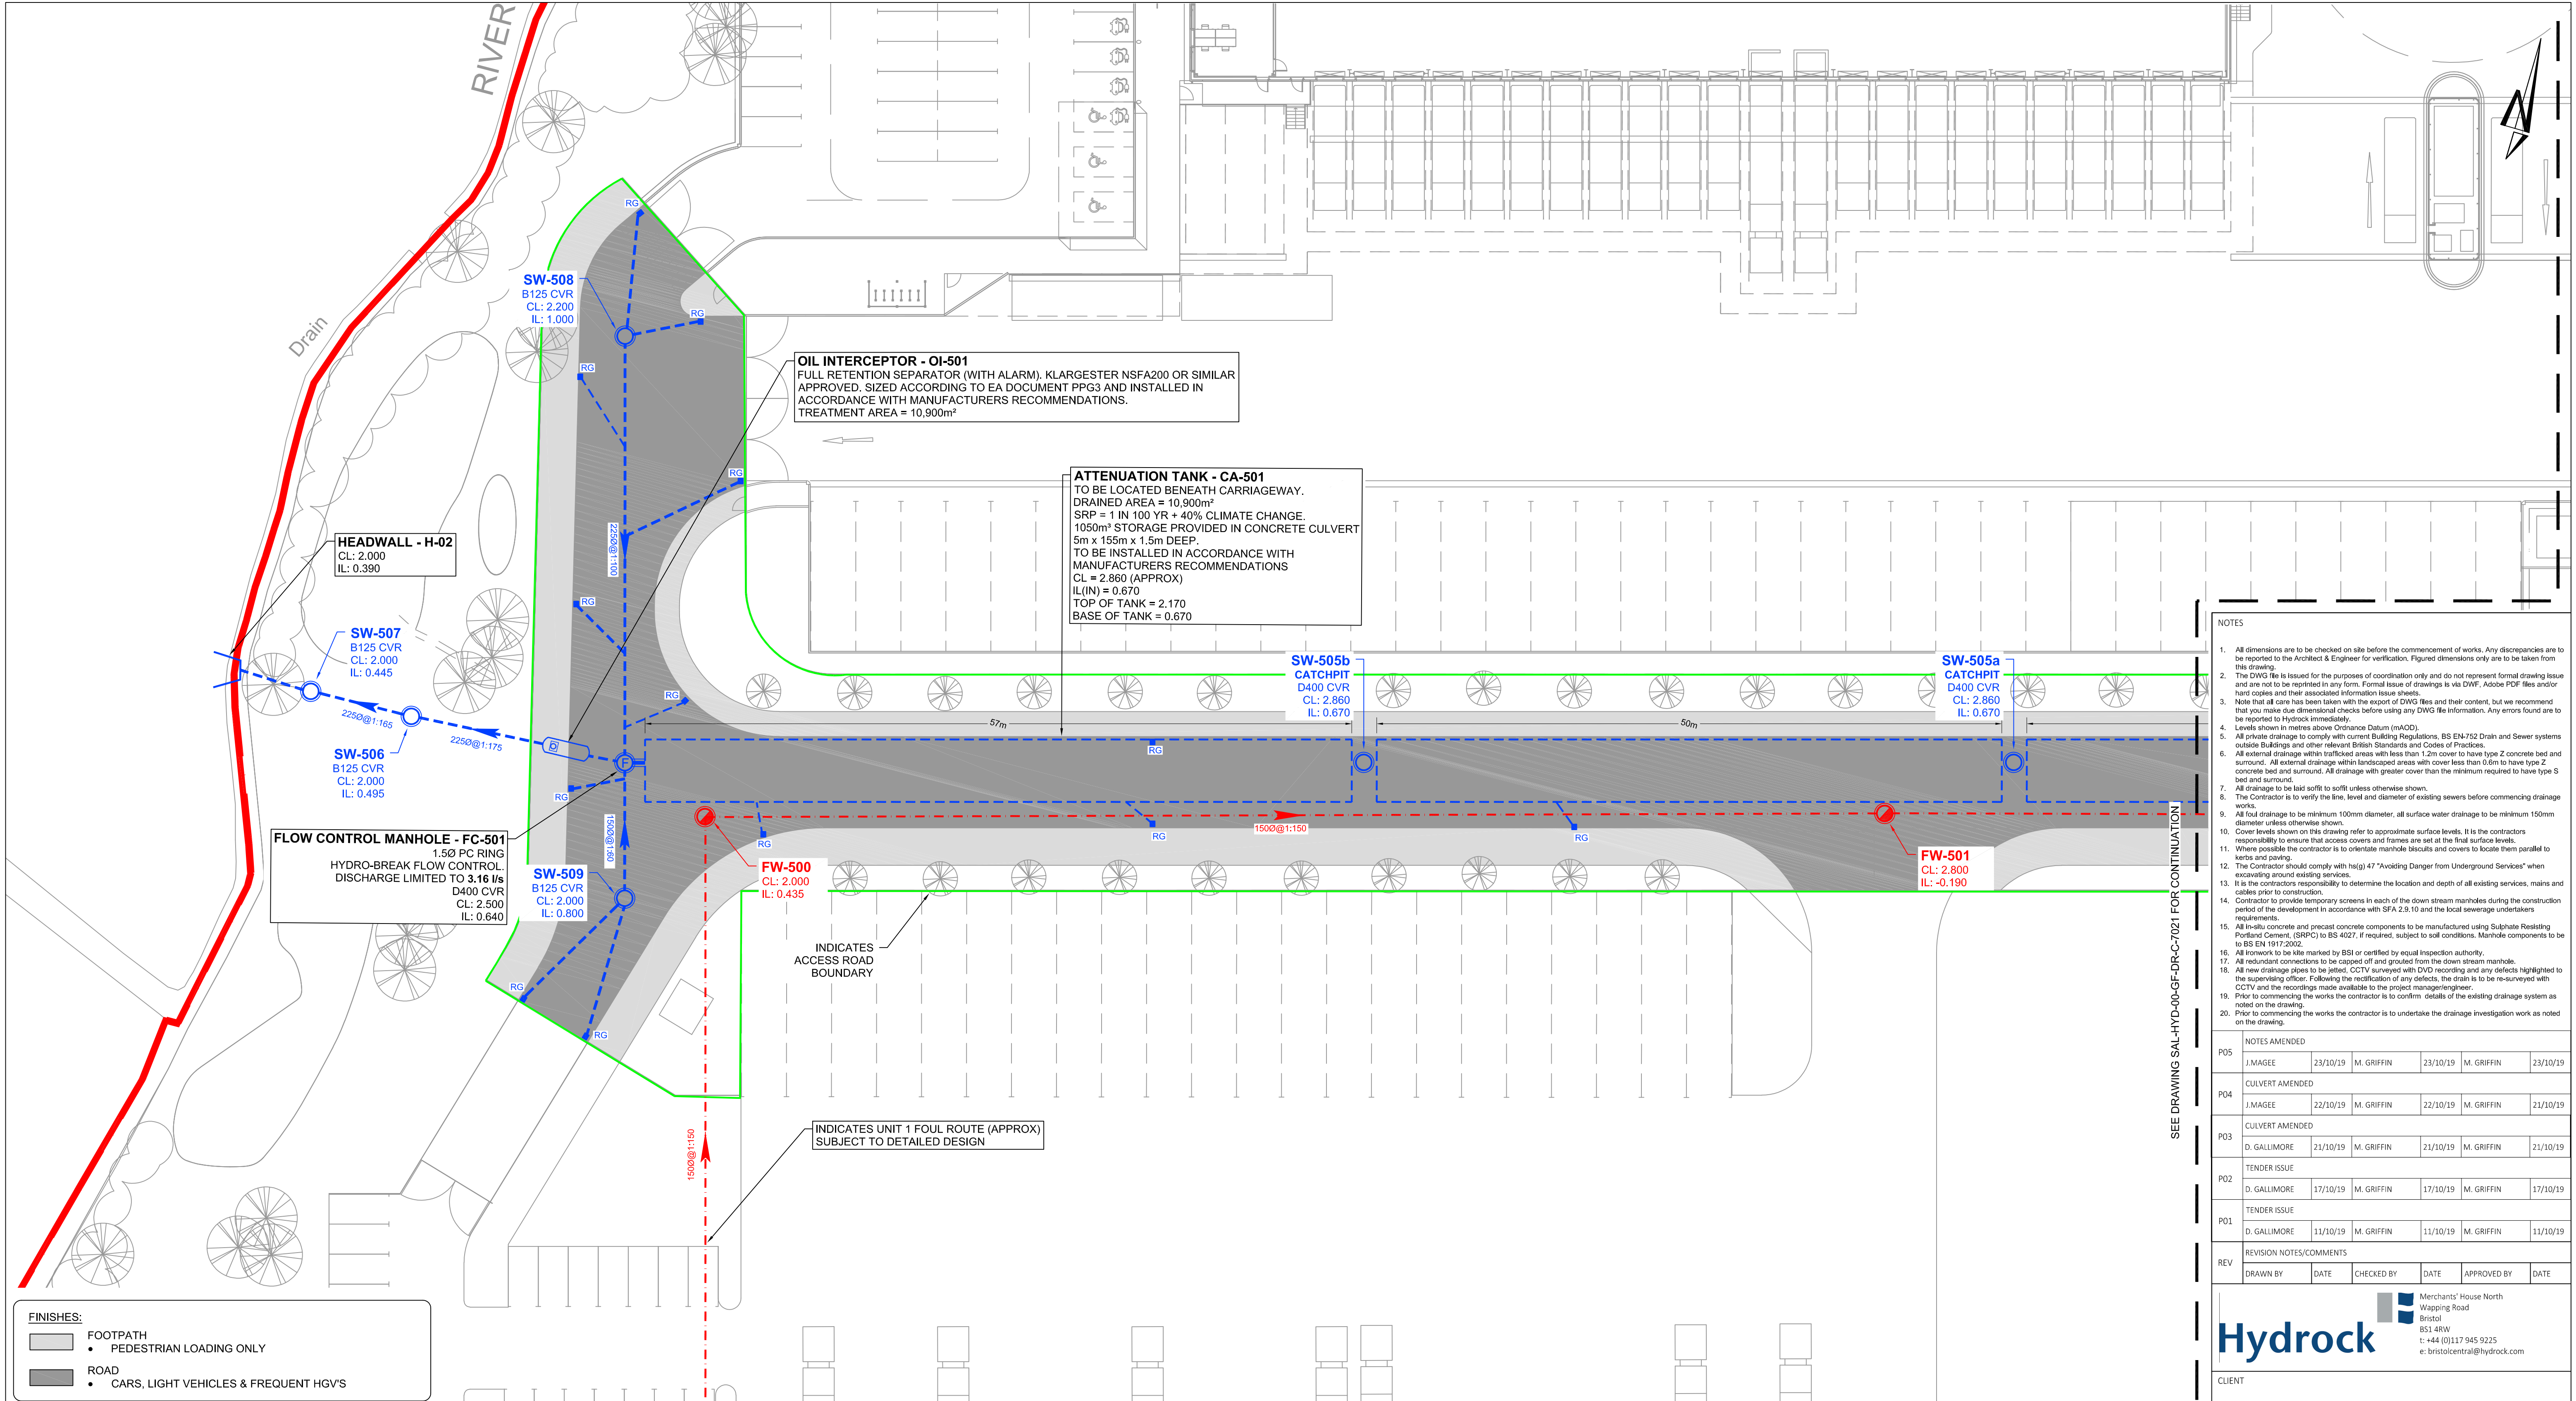

LEGEND
PROPOSED DRAINAGE - FOUL

1000@1:100

FOUL WATER DRAIN - CLAY

Approx. gradient and diameter as noted, 100mm Ø UNO

FW-01

FOUL WATER MANHOLE

PC Ring 1.2m Ø UNO

FW-01

FOUL WATER INSPECTION CHAMBER

PVCu 450mm Ø. Max 1.2m depth - reduced access to 3.0m

Note: All internal foul MH's and IC's to have recessed covers, double sealed and locking to prevent odours. Refer to layout for location.

SAC

FOUL WATER SHALLOW ACCESS CHAMBER

Max depth to invert 600mm from GL, 300mm Ø

RE

FOUL RODDING EYE

Ø as noted

YG

FOUL YARD GULLY (to be trapped)

Gully reference as noted on drawing. Cover grade to suit loading.

FD

FLOOR DRAIN (to be trapped)

Internal use only, refer to architect for details / specification. Roddable from above slab into standard (01) fitting. Floor Drain / Gully to be kept charged to avoid odours.

01 & 01A

FOUL OUTLET / STACK POSITION

Shown indicative, refer to architect for setting out. All branches 100mm Ø UNO.
01 - Outlet connects into standard 90° rest bend.
01A - Indicates access required in above slab plumbing for rodding, refer to service engineers drawings for details.
SVP - Indicates soil vent pipe by service engineer: with access.

PROPOSED DRAINAGE - STORM

1500@1:100

STORM WATER DRAIN - CLAY

Approx. gradient and diameter as noted, 150mm Ø UNO

SW-01

STORM WATER MANHOLE

PC Ring 1.2m Ø UNO

SW-01

STORM WATER INSPECTION CHAMBER

PVCu 450mm Ø. Max 1.2m depth - reduced access to 3.0m

RE

STORM RODDING EYE

Ø as noted

SILT TRAP

CONCRETE ENCASEMENT TO PIPE

Refer to limits of cover table drawing 7101

RAIN WATER OUTLET

Shown indicative, refer to architect for setting out. All branches 100mm Ø UNO.
01 - Outlet connects into standard 90° rest bend.
01A - Indicates access required in above slab plumbing for rodding, refer to service engineers drawings for details.

AG

RAIN WATER OUTLET ACCESS GULLY

AG - Outlet connects to gully.

RG

ROAD GULLY (to be trapped)

YG

YARD GULLY (to be trapped)

PG

PAVED AREA GULLY (to be trapped)

DC

DRAINAGE CHANNEL

(Refer to layout for specification)

TH

THRESHOLD DRAINAGE CHANNEL

(Refer to architect for details / specification)

Note: All internal foul MH's and IC's to have recessed covers, double sealed and locking to prevent odours. Refer to layout for location.

FINISHES:

FOOTPATH

PEDESTRIAN LOADING ONLY

ROAD

CARS, LIGHT VEHICLES & FREQUENT HGV'S

NOTES

- All dimensions are to be checked on site before the commencement of works. Any discrepancies are to be reported to the Architect & Engineer for verification. Figured dimensions only are to be taken from this drawing.
- The DWG file is issued for the purposes of coordination only and does not represent formal drawing issue and are not to be reprinted in any form. Formal issue of drawings is via DWG, Adobe PDF files and/or hard copies and their associated information issue sheets.
- Note that all care has been taken with the export of DWG files and their content, but we recommend that you make due dimensional checks before using any DWG file information. Any errors found are to be reported to Hydrock immediately.
- Levels shown in metres above Ordnance Datum (mAOD).
- All private drainage to comply with current Building Regulations, BS EN-752 Drain and Sewer systems outside Buildings and other relevant British Standards and Codes of Practice.
- All external drainage within landscaped areas with less than 1.2m cover to have type 2 concrete bed and surround. All external drainage within landscaped areas with cover less than 0.6m to have type 2 concrete bed and surround. All drainage with greater cover than the minimum required to have type 5 bed and surround.
- All drainage to be laid soffit to soffit unless otherwise shown.
- The Contractor is to verify the line, level and diameter of existing sewers before commencing drainage works.
- All foul drainage to be minimum 100mm diameter, all surface water drainage to be minimum 150mm diameter unless otherwise shown.
- Cover levels shown on this drawing refer to approximate surface levels. It is the contractors responsibility to ensure that access covers and frames are set at the final surface levels.
- Where possible the contractor is to orientate manhole biscuits and covers to locate them parallel to kerbs and paving.
- The Contractor should comply with hse(g) 47 "Avoiding Danger from Underground Services" when excavating around existing services.
- It is the contractors responsibility to determine the location and depth of all existing services, mains and cables prior to construction.
- Contractor to provide temporary screens in each of the down stream manholes during the construction period of the development in accordance with SFA 2.8.10 and the local sewerage undertakers requirements.
- All in-situ concrete and precast concrete components to be manufactured using Sulphate Resisting Portland Cement, (SRPC) to BS 4027, if required, subject to soil conditions. Manhole components to be to BS EN 1917:2002.
- All ironwork to be site marked by equal inspection authority.
- All redundant connections to be capped off and grouted from the down stream manhole.
- All new drainage plans to be jetted, CCTV surveyed with DVD recording and any defects highlighted to the supervising officer. Following the rectification of any defects, the drain is to be re-surveyed with CCTV and the recordings made available to the project manager/engineer.
- Prior to commencing the works the contractor is to confirm details of the existing drainage system as noted on the drawing.
- Prior to commencing the works the contractor is to undertake the drainage investigation work as noted on the drawing.

POS	NOTES AMENDED	J.MAGEE	23/10/19	M. GRIFFIN	23/10/19	M. GRIFFIN	23/10/19
P04	CULVERT AMENDED	J.MAGEE	22/10/19	M. GRIFFIN	22/10/19	M. GRIFFIN	21/10/19
P03	CULVERT AMENDED	D. GALLIMORE	21/10/19	M. GRIFFIN	21/10/19	M. GRIFFIN	21/10/19
P02	TENDER ISSUE	D. GALLIMORE	17/10/19	M. GRIFFIN	17/10/19	M. GRIFFIN	17/10/19
P01	TENDER ISSUE	D. GALLIMORE	11/10/19	M. GRIFFIN	11/10/19	M. GRIFFIN	11/10/19
REV	REVISION NOTES/COMMENTS	DRAWN BY	DATE	CHECKED BY	DATE	APPROVED BY	DATE

Hydrock

Merchants' House North
Wapping Road
Bristol
BS1 4RW
t: +44 (0)117 945 9225
e: bristolcentral@hydrock.com

CLIENT	LANDLINK ESTATES		
PROJECT	SALTBOX BOGNOR REGIS		
TITLE	ACCESS ROAD DRAINAGE LAYOUT SHEET 1		
HYDROCK PROJECT NO.	C-13319-C	SCALE @ A1	1:250
STATUS DESCRIPTION	TENDER	STATUS	D2
DRAWING NO. (PROJECT CODE-ORIGINATOR-ZONE-LEVEL-TYPE-ROLE-NUMBER)	SAL-HYD-00-ZZ-DR-C-7020	REVISION	P05