


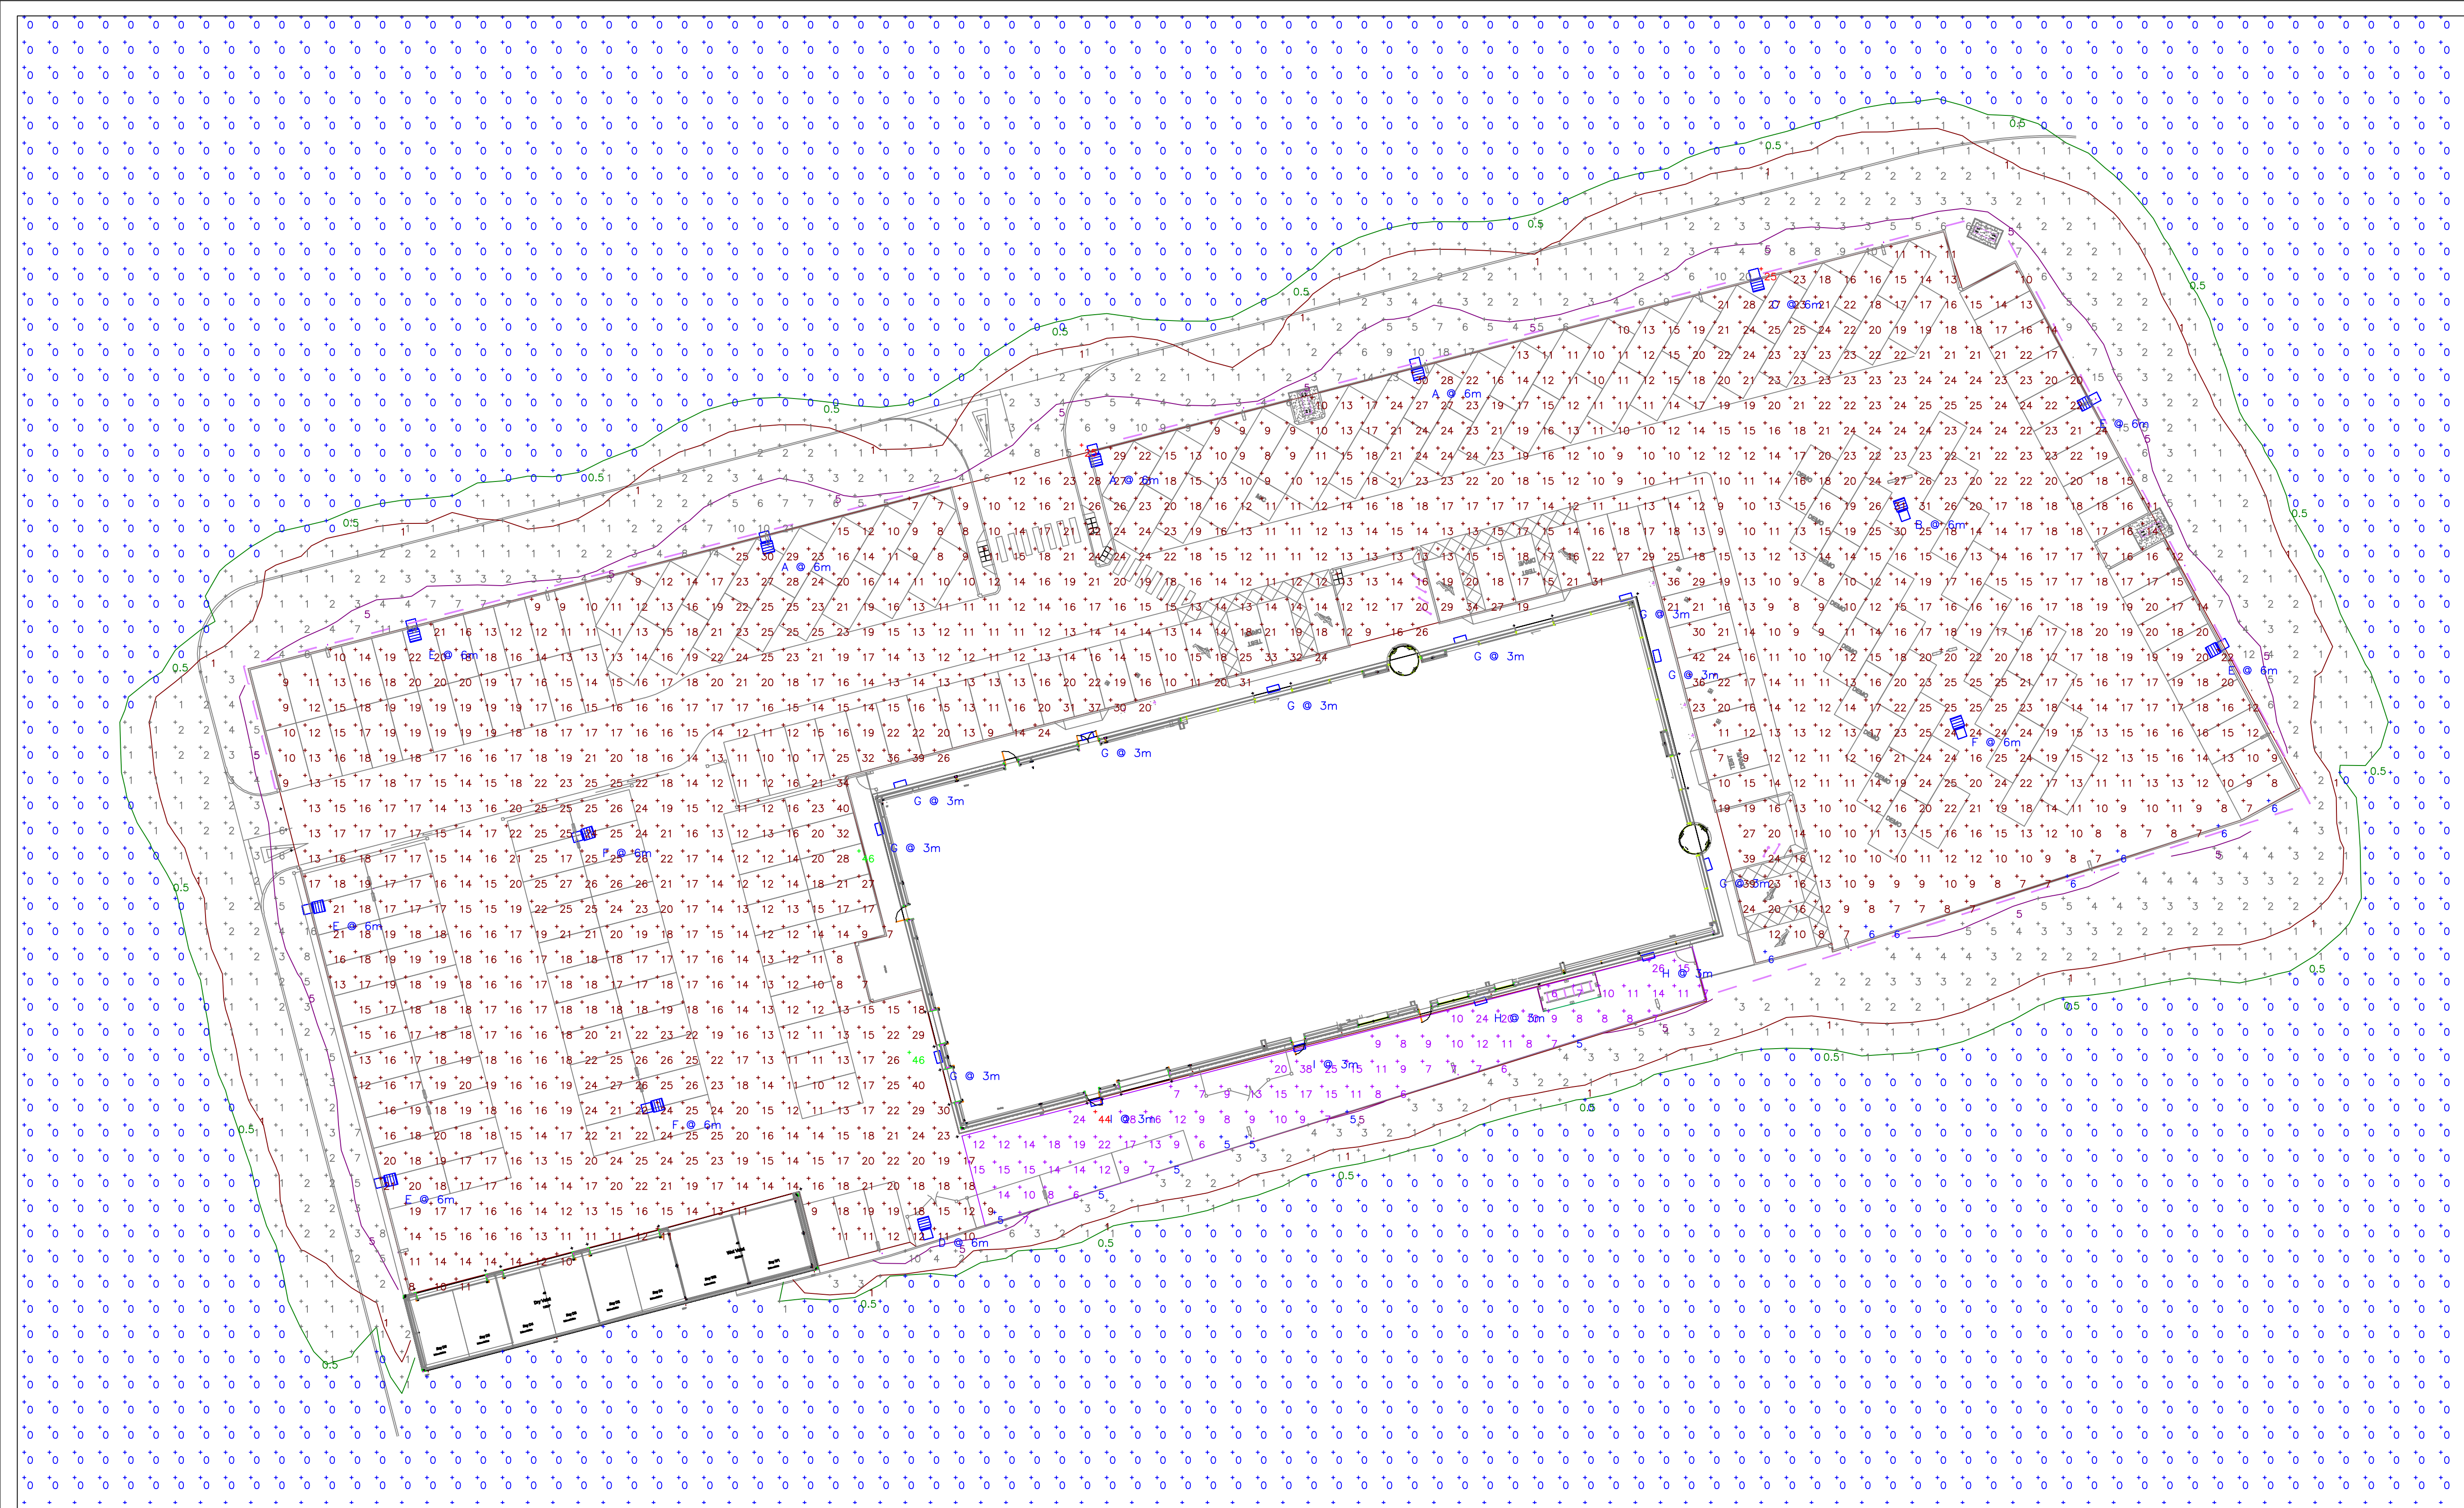

Schedule						
Symbol	Label	Quantity	Catalog Number	Description	Lumens Lamp	Power Wattage
	A	3	DSX0.1.LA104.FW.BLS	D-Series 0 Area luminaire	7553	81
	B	1	DSX0.1.LA104.FW	D-Series 0 Area luminaire	9673	81
	C	1	DSX0.1.LA084.AY.BLS	D-Series 0 Area luminaire	6323	64
	D	1	DSX0.1.LA044.BLC	D-Series 0 Area luminaire	3287	29
	E	5	DSX0.1.LA064.AY.BLS	D-Series 0 Area luminaire	4719	45
	F	3	DSX1.2.LA114.SY	D-Series 1 Luminaire	13055	105
	G	9	DWL.1.LA044.FW.W025	Denver iD Wall	3823	25
	H	2	DWL.1.LA024.AY.W011	Denver iD Wall	1442	10.3
	I	2	DWL.1.LA034.AY.W018	Denver iD Wall	2384	18

Statistics				
Description	Symbol	Avg	Min	Min/Avg
Building Perimeter South	+	12 lux	5 lux	0.42
Car Parking	+	17 lux	6 lux	0.35
Spill Light	+	0 lux	0 lux	N/A

Revisions:						
Revision	Date	Revision Notes			Drawn	Checked

Standard Notes
1. DO NOT SCALE THIS DRAWING. WORK TO DIMENSIONS GIVEN.
2. ALL DIMENSIONS TO BE VERIFIED FROM SITE MEASUREMENT.
3. DIMENSIONS ARE IN MILLIMETRES UNLESS OTHERWISE STATED.

- THIS DRAWING SHALL BE READ IN CONJUNCTION WITH THE ELECTRICAL SPECIFICATION AND ALL OTHER LAYOUT DRAWINGS.
- ALL SETTING OUT TO BE CONFIRMED BY THE ARCHITECT.
- ELECTRICAL INSTALLATION SHALL COMPLY WITH THE CURRENT BS 7671 WIRING REGULATIONS.
- DO NOT SCALE OFF THIS DRAWING, ALWAYS WORK TO NOTED DIMENSIONS.
- THIS DRAWING IS TO BE READ IN CONJUNCTION WITH ALL ARCHITECTURAL AND STRUCTURAL ENGINEERS DRAWINGS.

LUMINAIRE SCHEDULE
Z - FACTOR SMALL STREETLIGHT - SINGLE (FTS.2.LA054.AY)
Y - FACTOR SMALL STREETLIGHT - TWIN (FTS.2.LA054.AY)
X - FACTOR SMALL STREET LIGHT - BUILDING MOUNTED (FTS.2.LA054.AY)

Project:
RMG, Saltbox Bognor Regis

Confidentiality
This drawing is issued confidentially and must not be disclosed to any third parties without the prior written consent of Collina MEP.

Drawing Title:
**ELECTRICAL SERVICES
EXTERNAL LIGHTING LAYOUT**

Status:
PLANNING

Drawn: K.H. Checked: T.H. First Issued: 15.02.22

Drawing Number:
2110-COL-XX-00-DR-E-901

Sheet Size: **A1** Scale: **N.T.S** Revision: **T01**

