



General Notes:


1. Do not scale from this drawing.
2. All dimensions in metres.
3. Extent of outlet protection to be the greater of 1500mm or pipe diameter + 1200mm spanning the outlet pipe.
4. All exposed pipework to be UV stable.
5. Headwall construction detail in accordance with West Sussex County Council drawing no. S278/38/24 revision A.

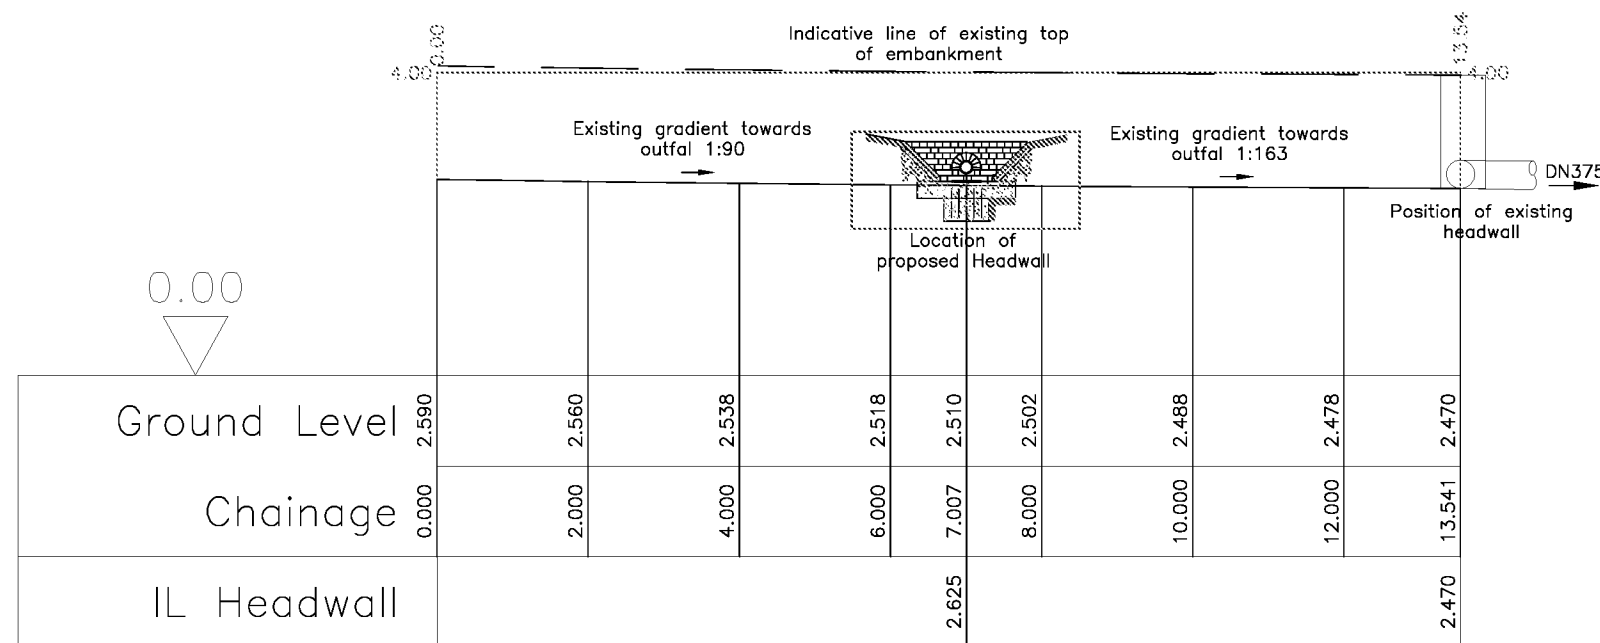


Ditch Section A-A
Horiz. 1:100
Vert. 1:100

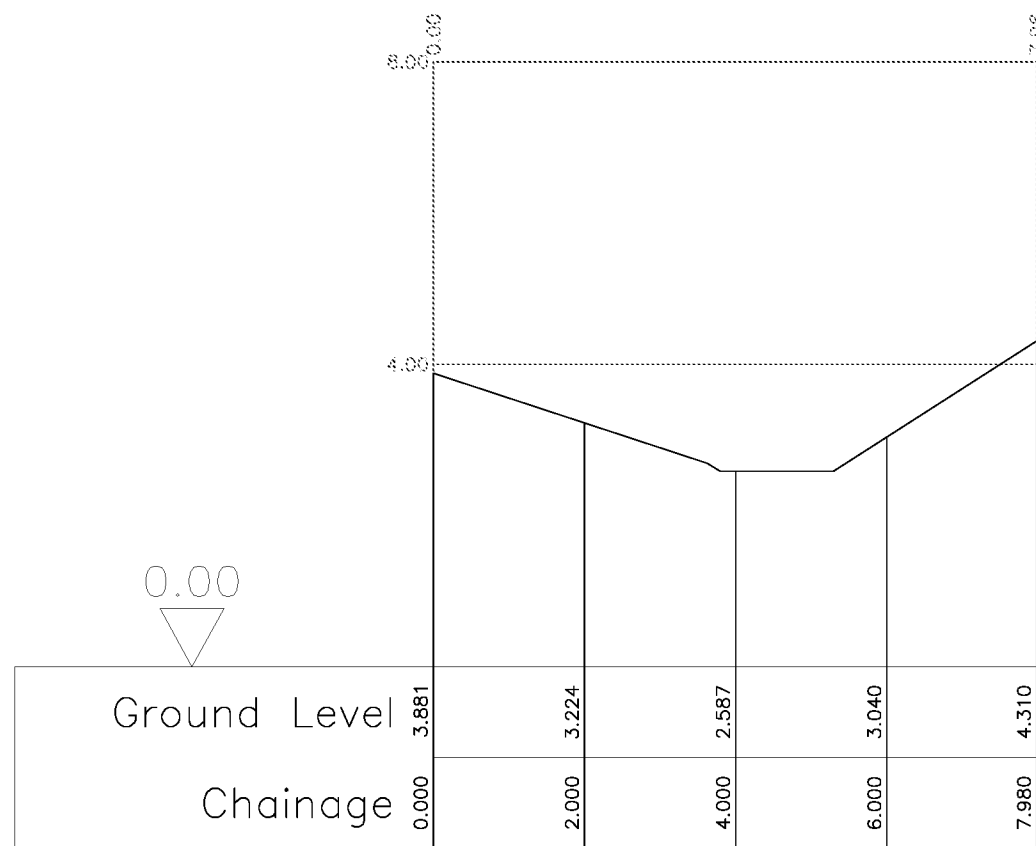



Ditch Section B-B
Horiz. 1:100
Vert. 1:100

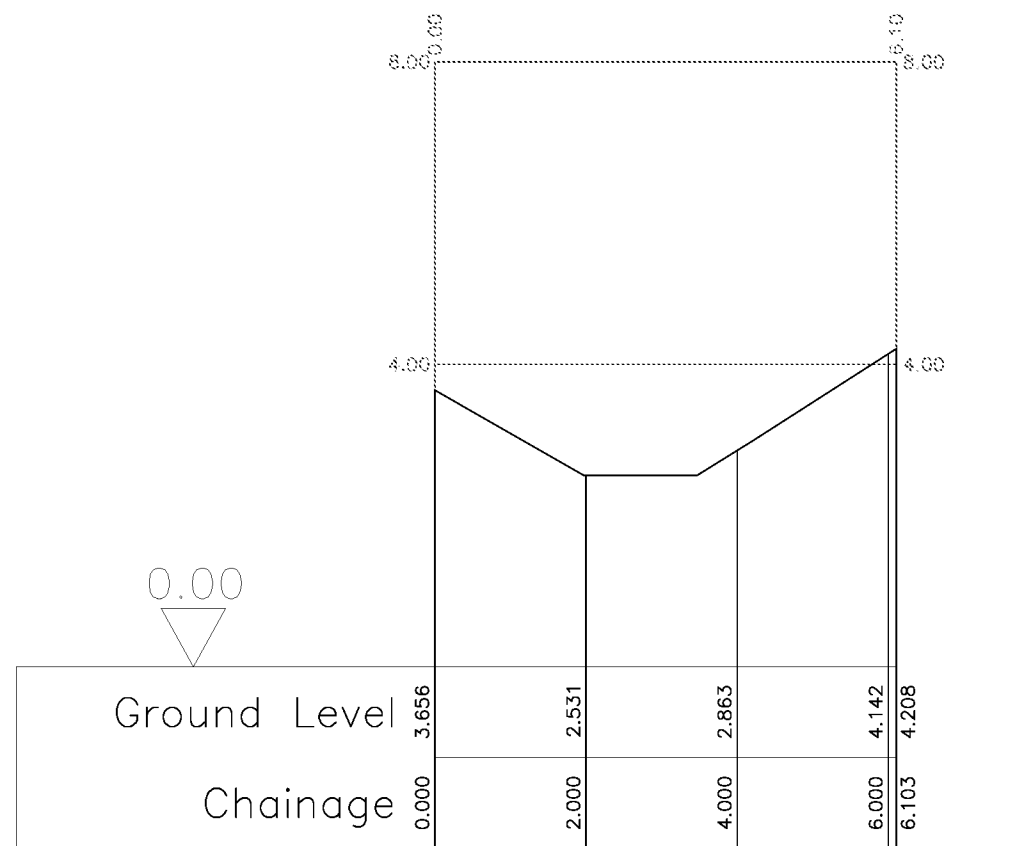


Ditch Section C-C
Horiz. 1:100
Vert. 1:100

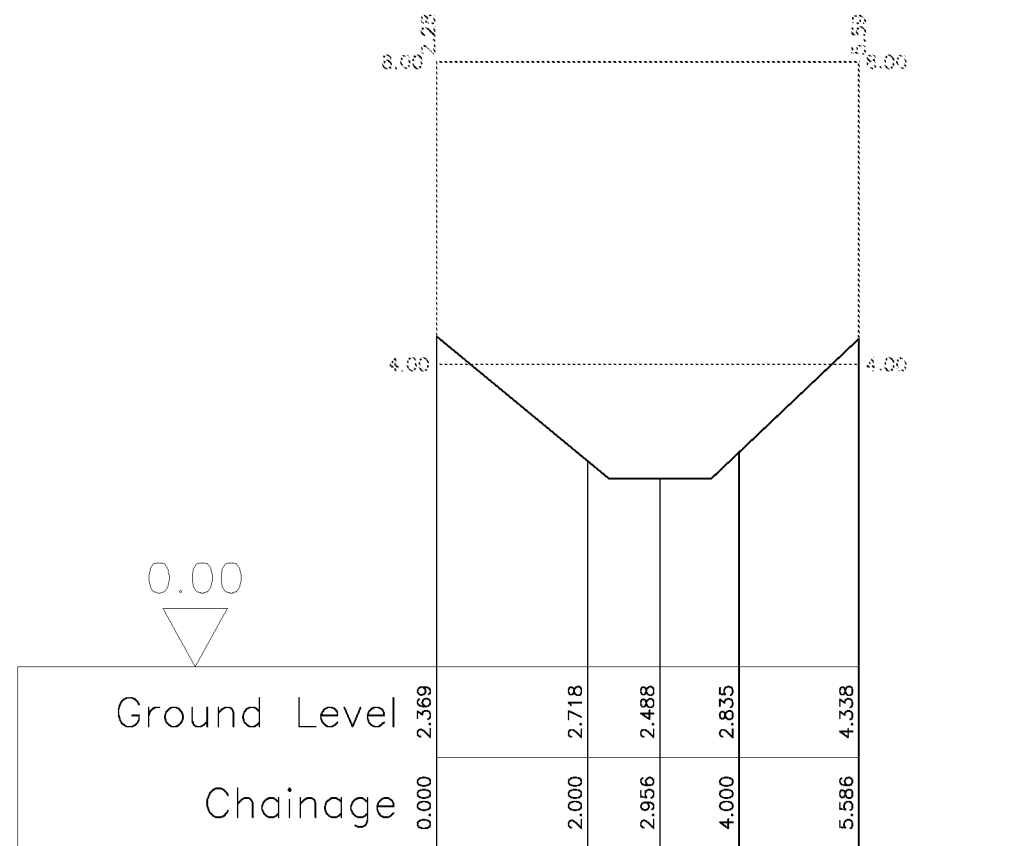


Ditch Section D-D
Horiz. 1:100
Vert. 1:100

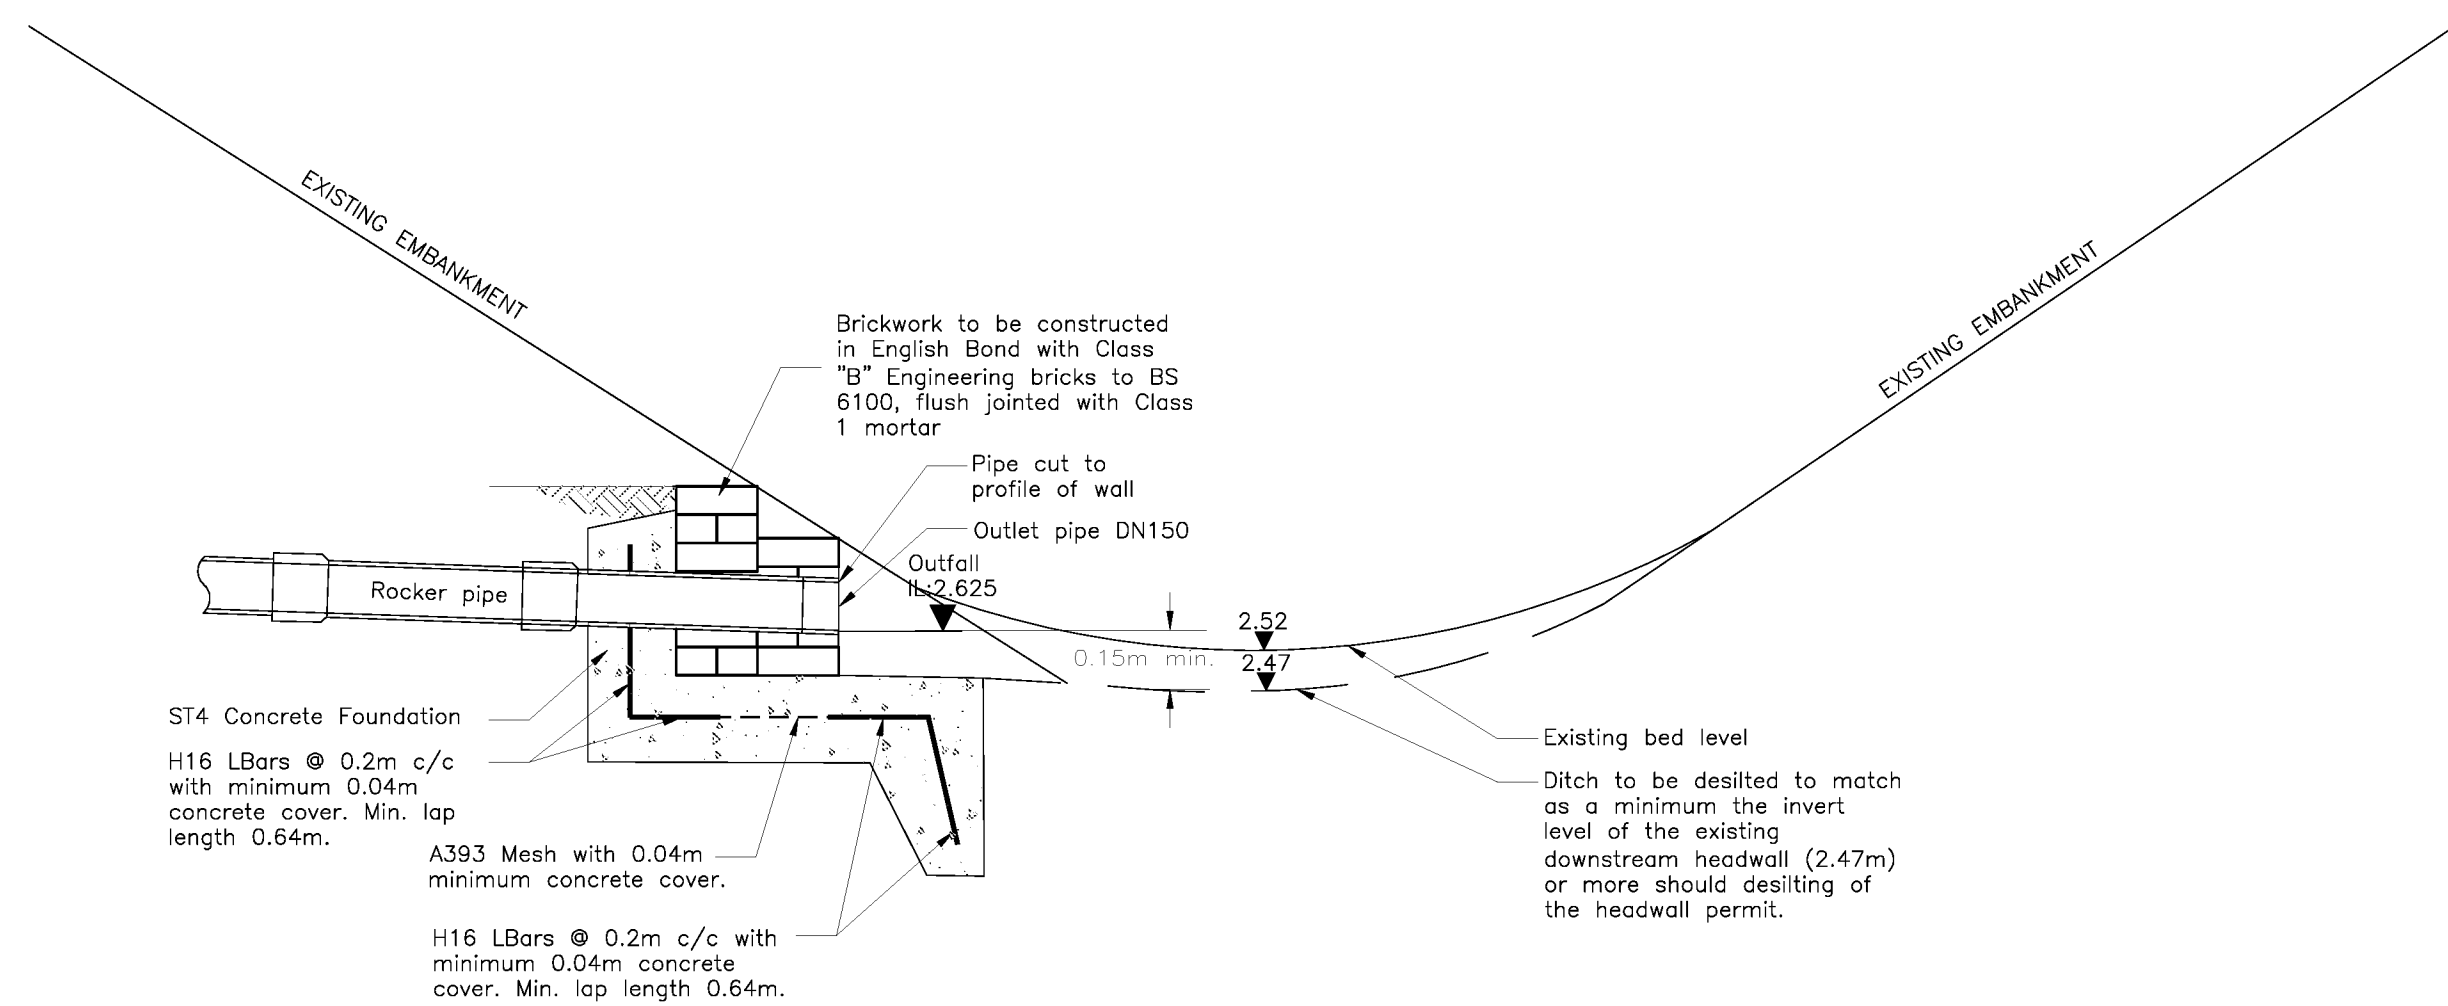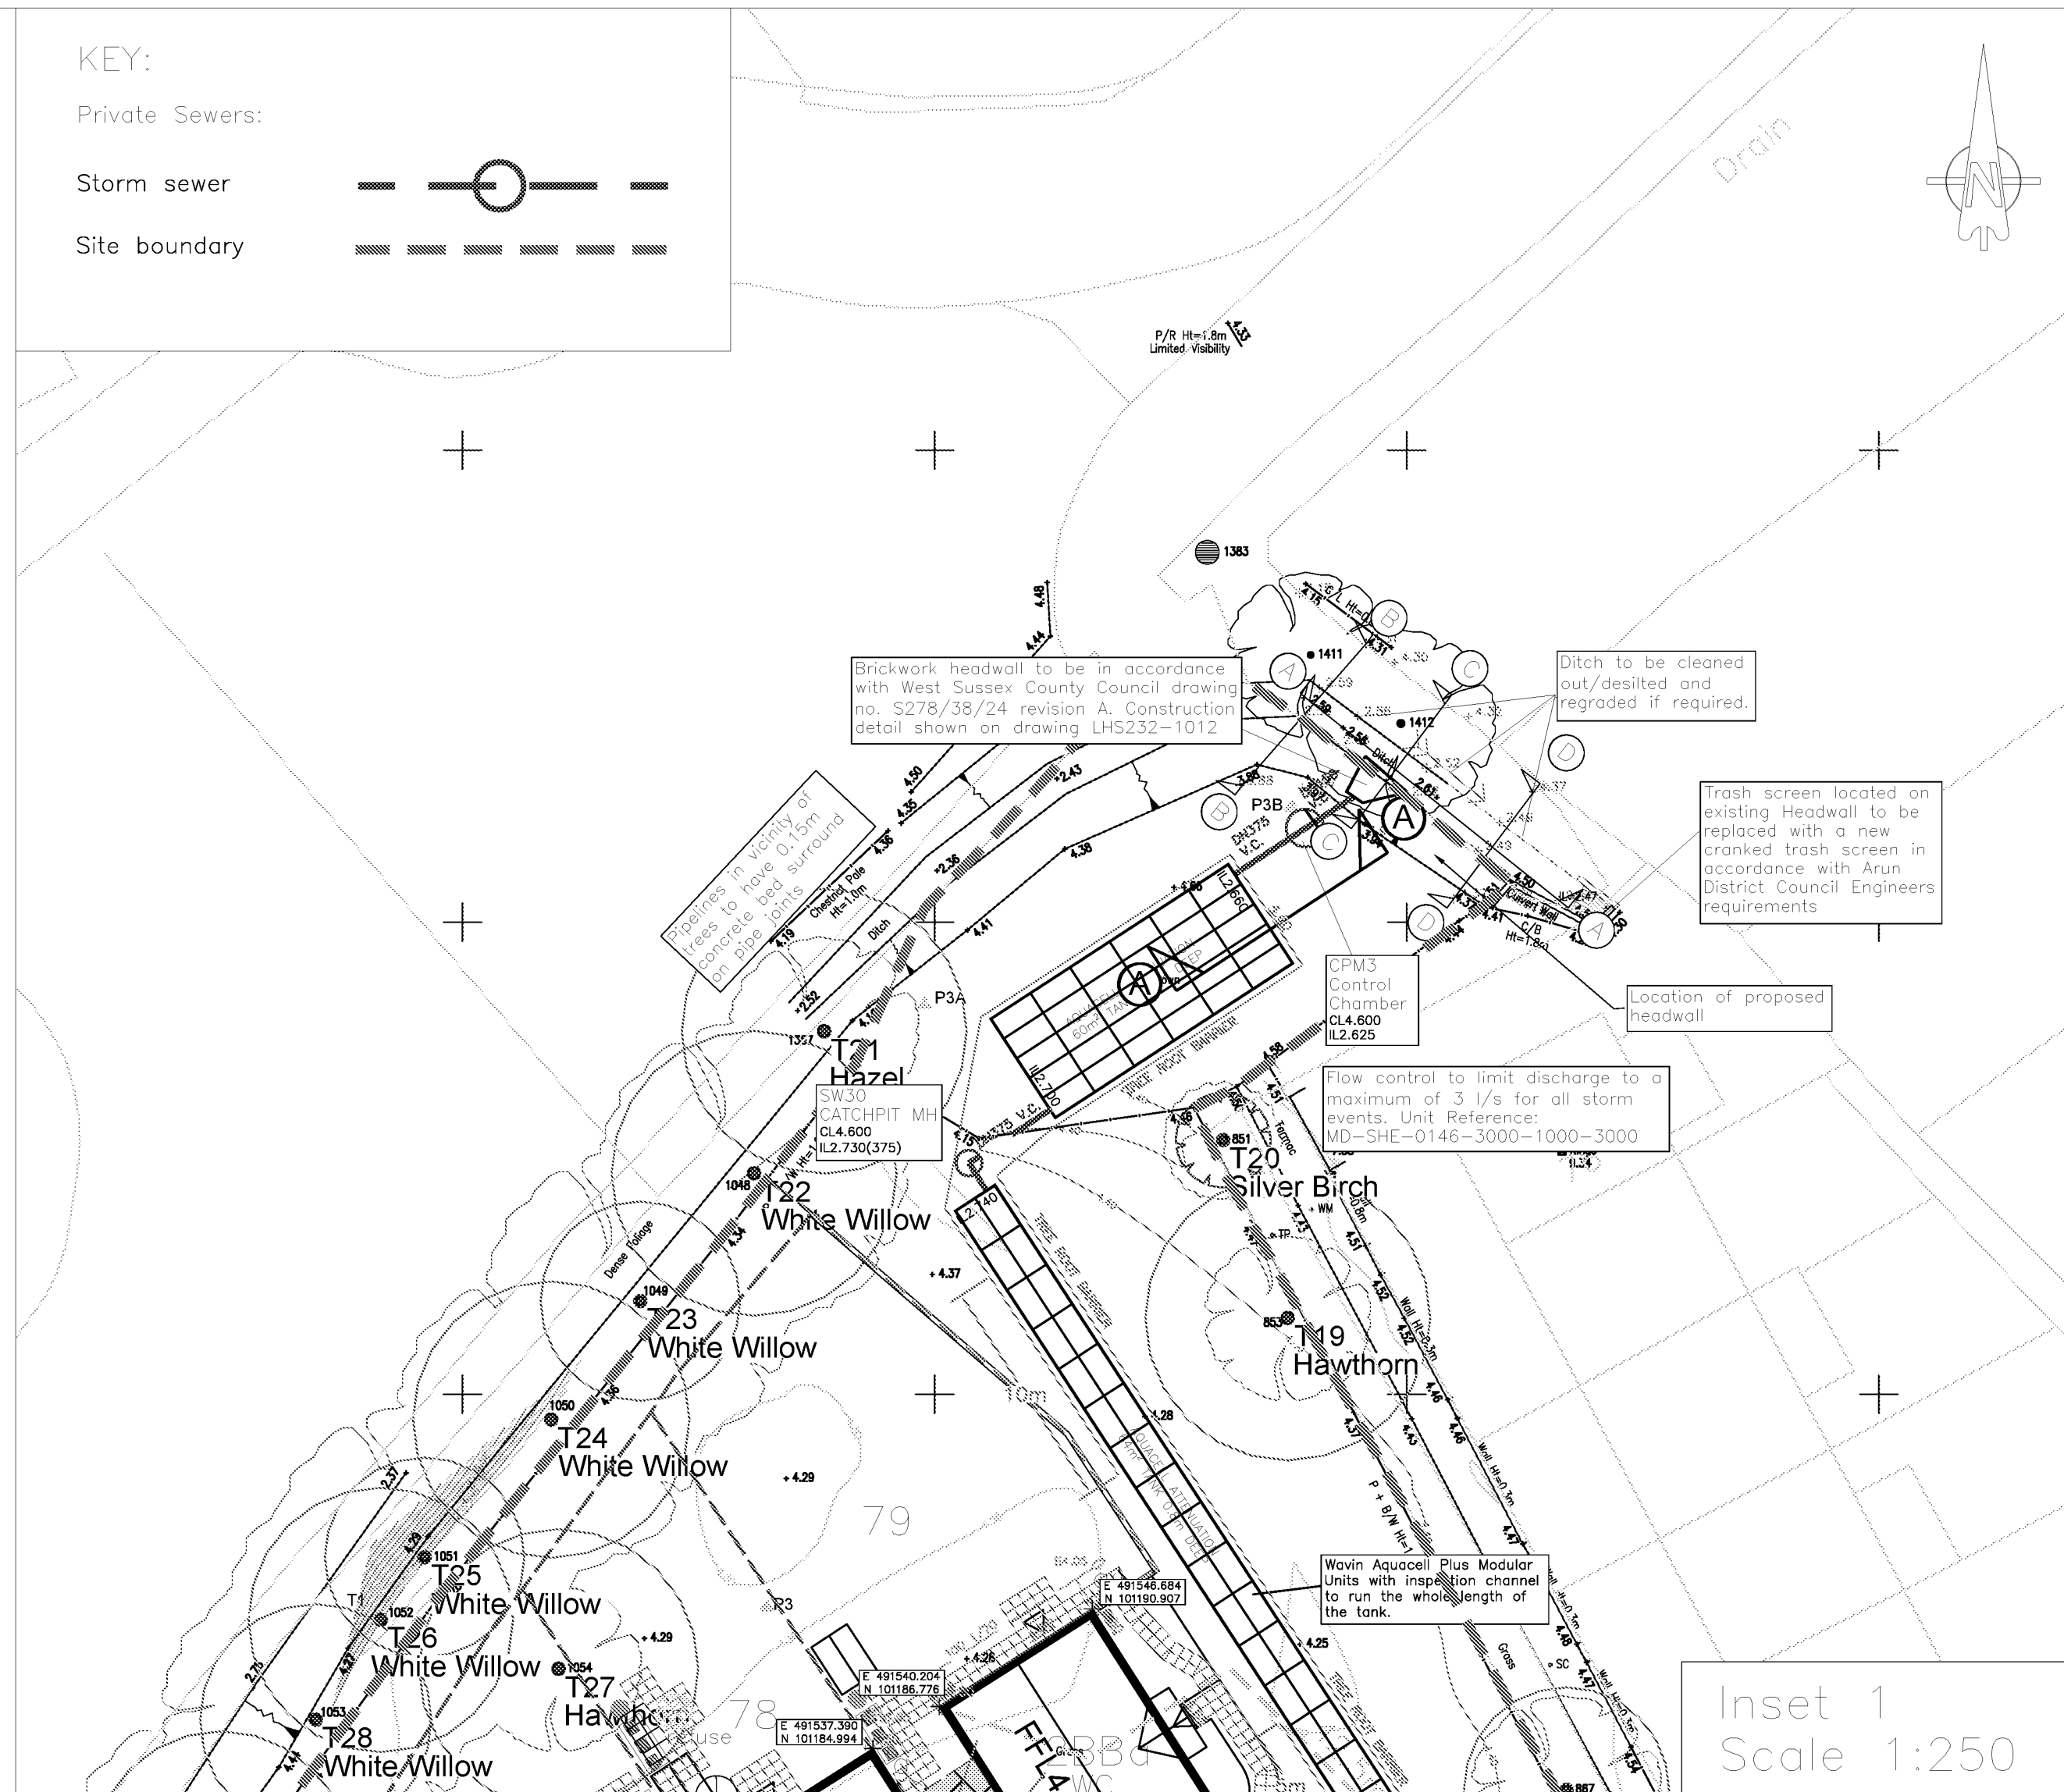



CONNECTION OF HEADWALL TO DRAINAGE DITCH
SCALE 1:20

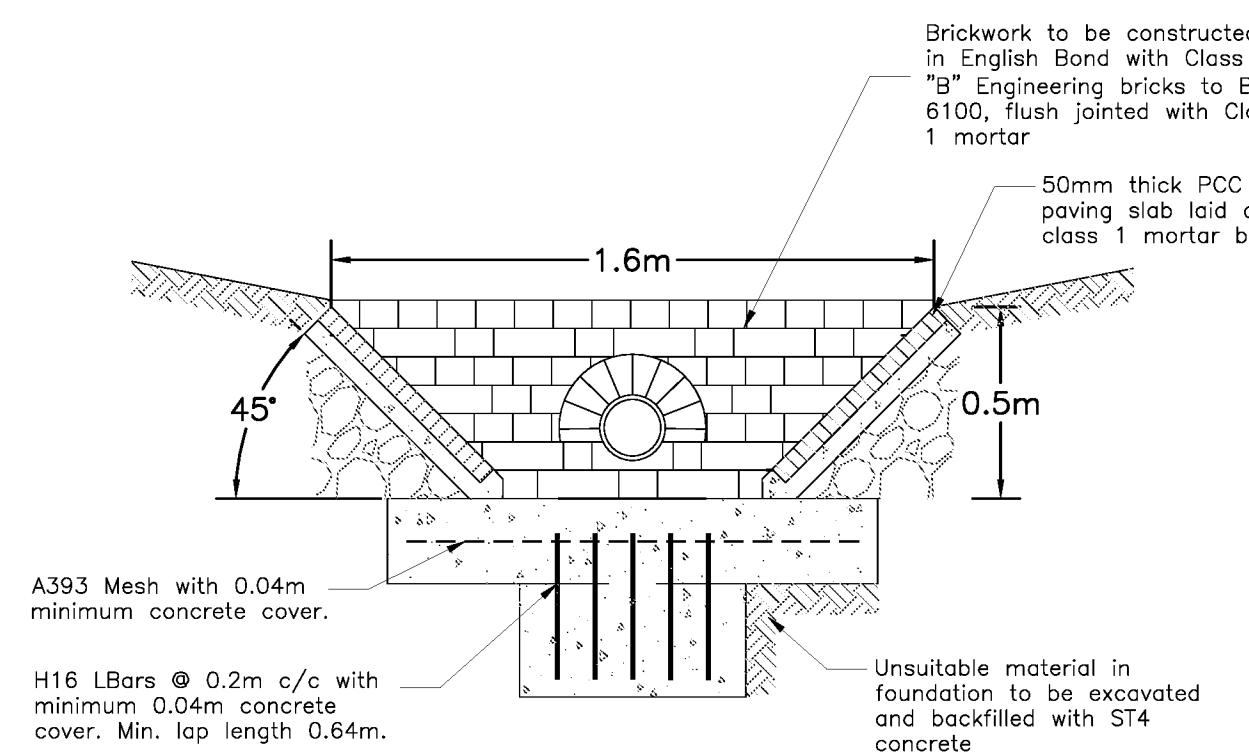

ELEVATION OF HEADWALL
OUTFALL TO END OF DITCH
SCALE 1:20

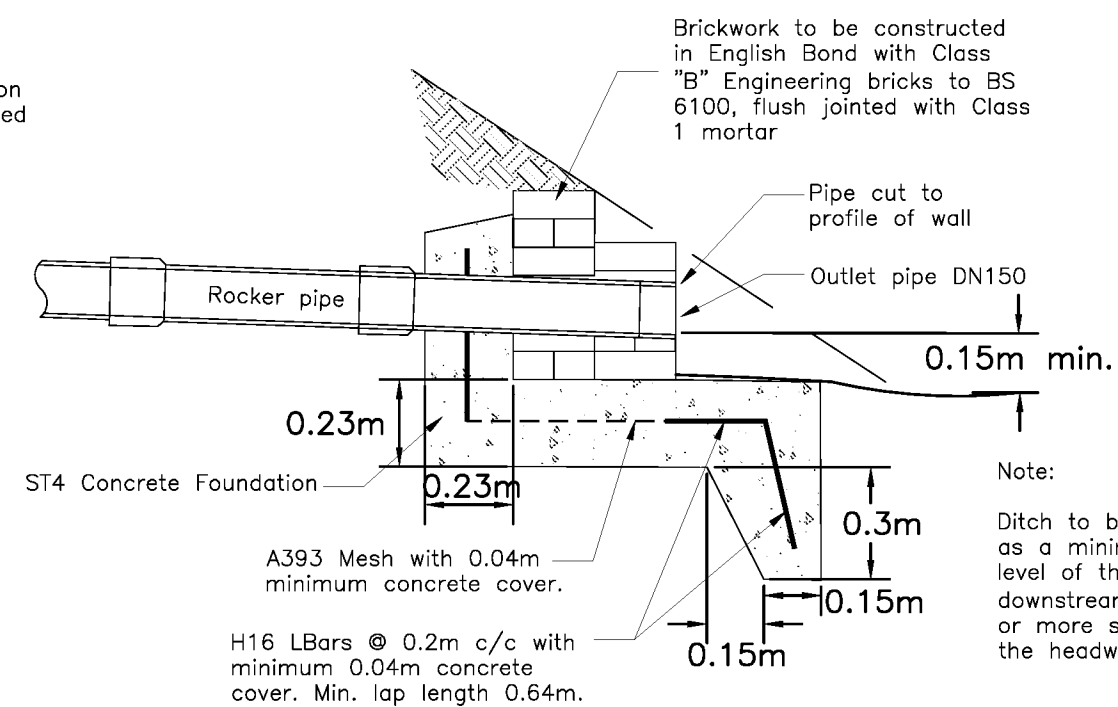

HEADWALL SECTION OUTFALL
TO POND/END OF DITCH
SCALE 1:20

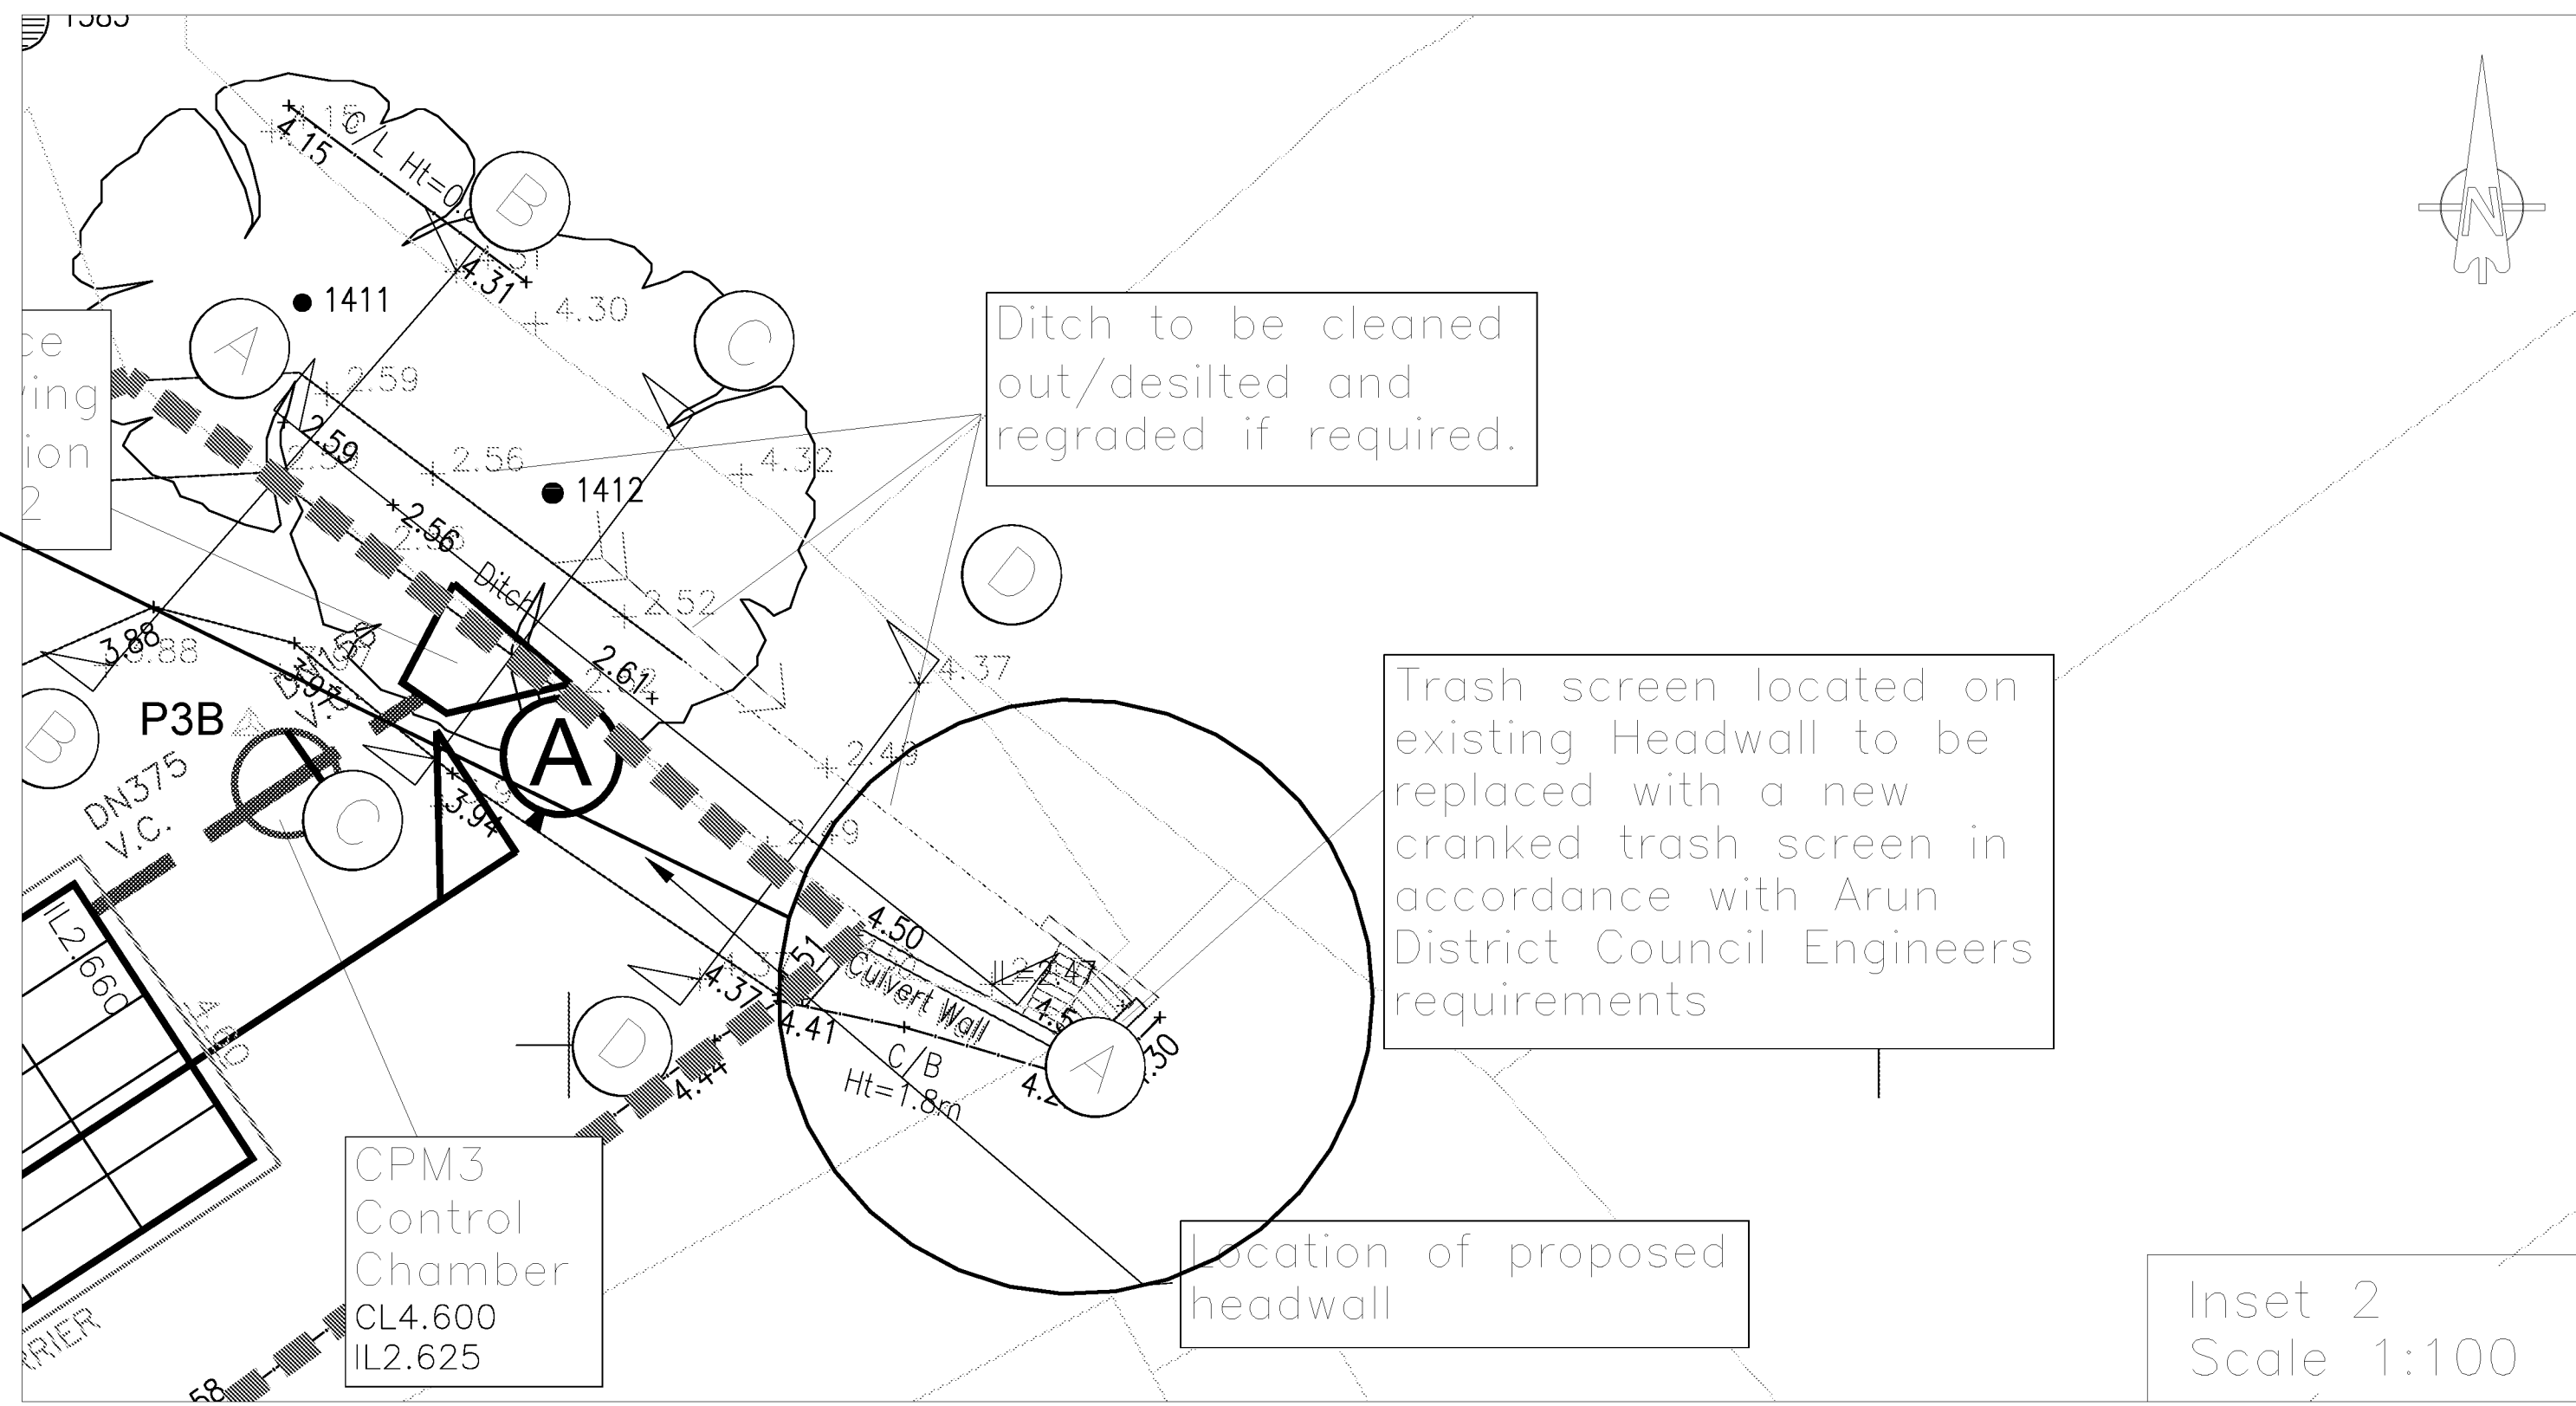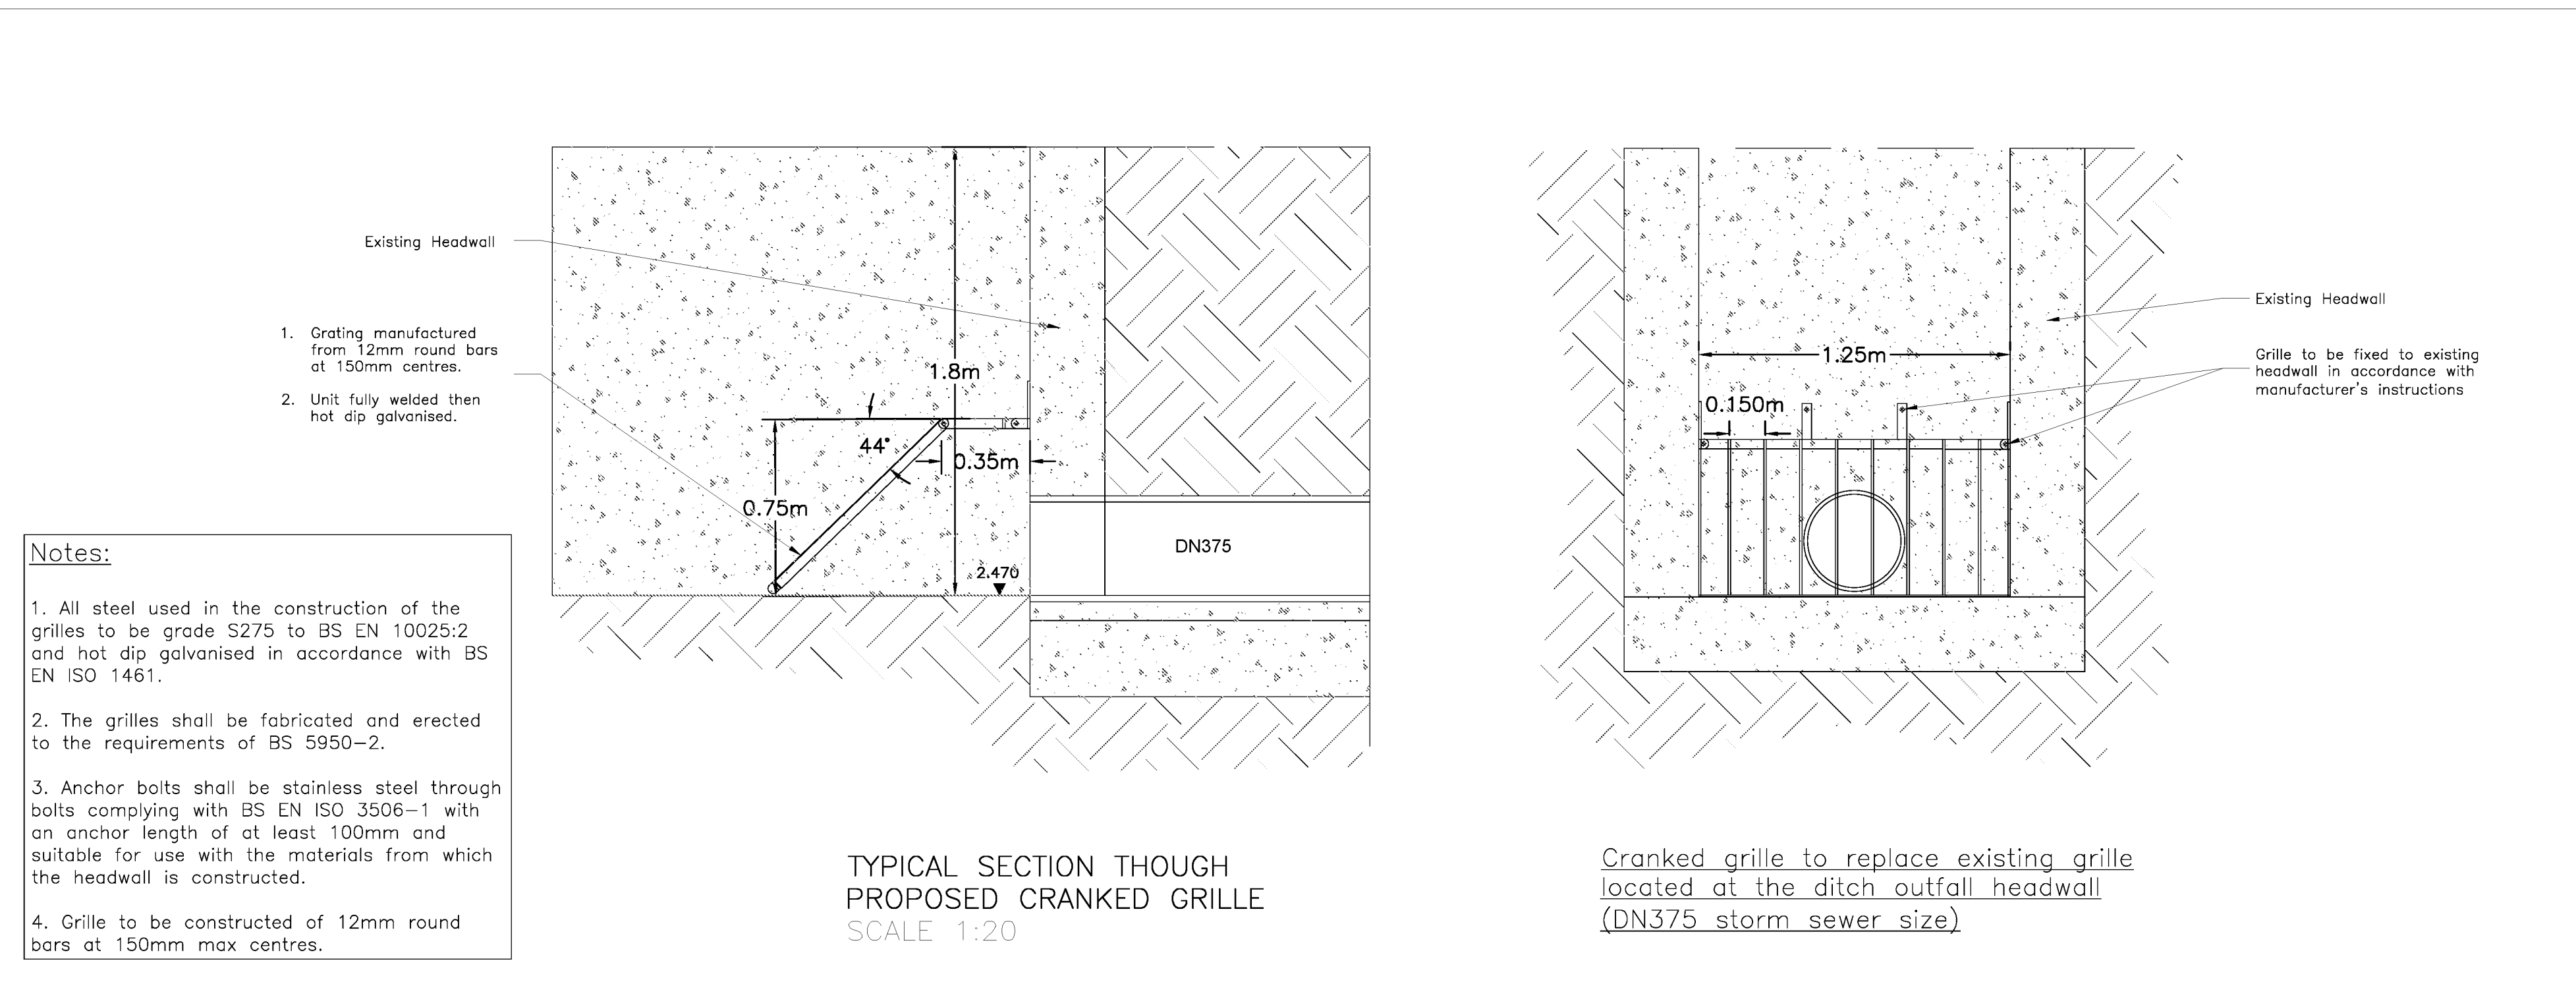

PRELIMINARY - FOR APPROVAL				
REV. No.	DATE	DESCRIPTION	INITIALS	
Client	Linden HOMES			
Project	New Barn lane North Bersted			
Title	Sections Through Existing Ditch and Proposed Headwall 99 Unit Scheme			
Scale	As shown @ A0			
Checked	KTG			
Date	Apr'18			
Drawn	JRV			
Drawing No.	LHS232-3012			
Rev	-			