


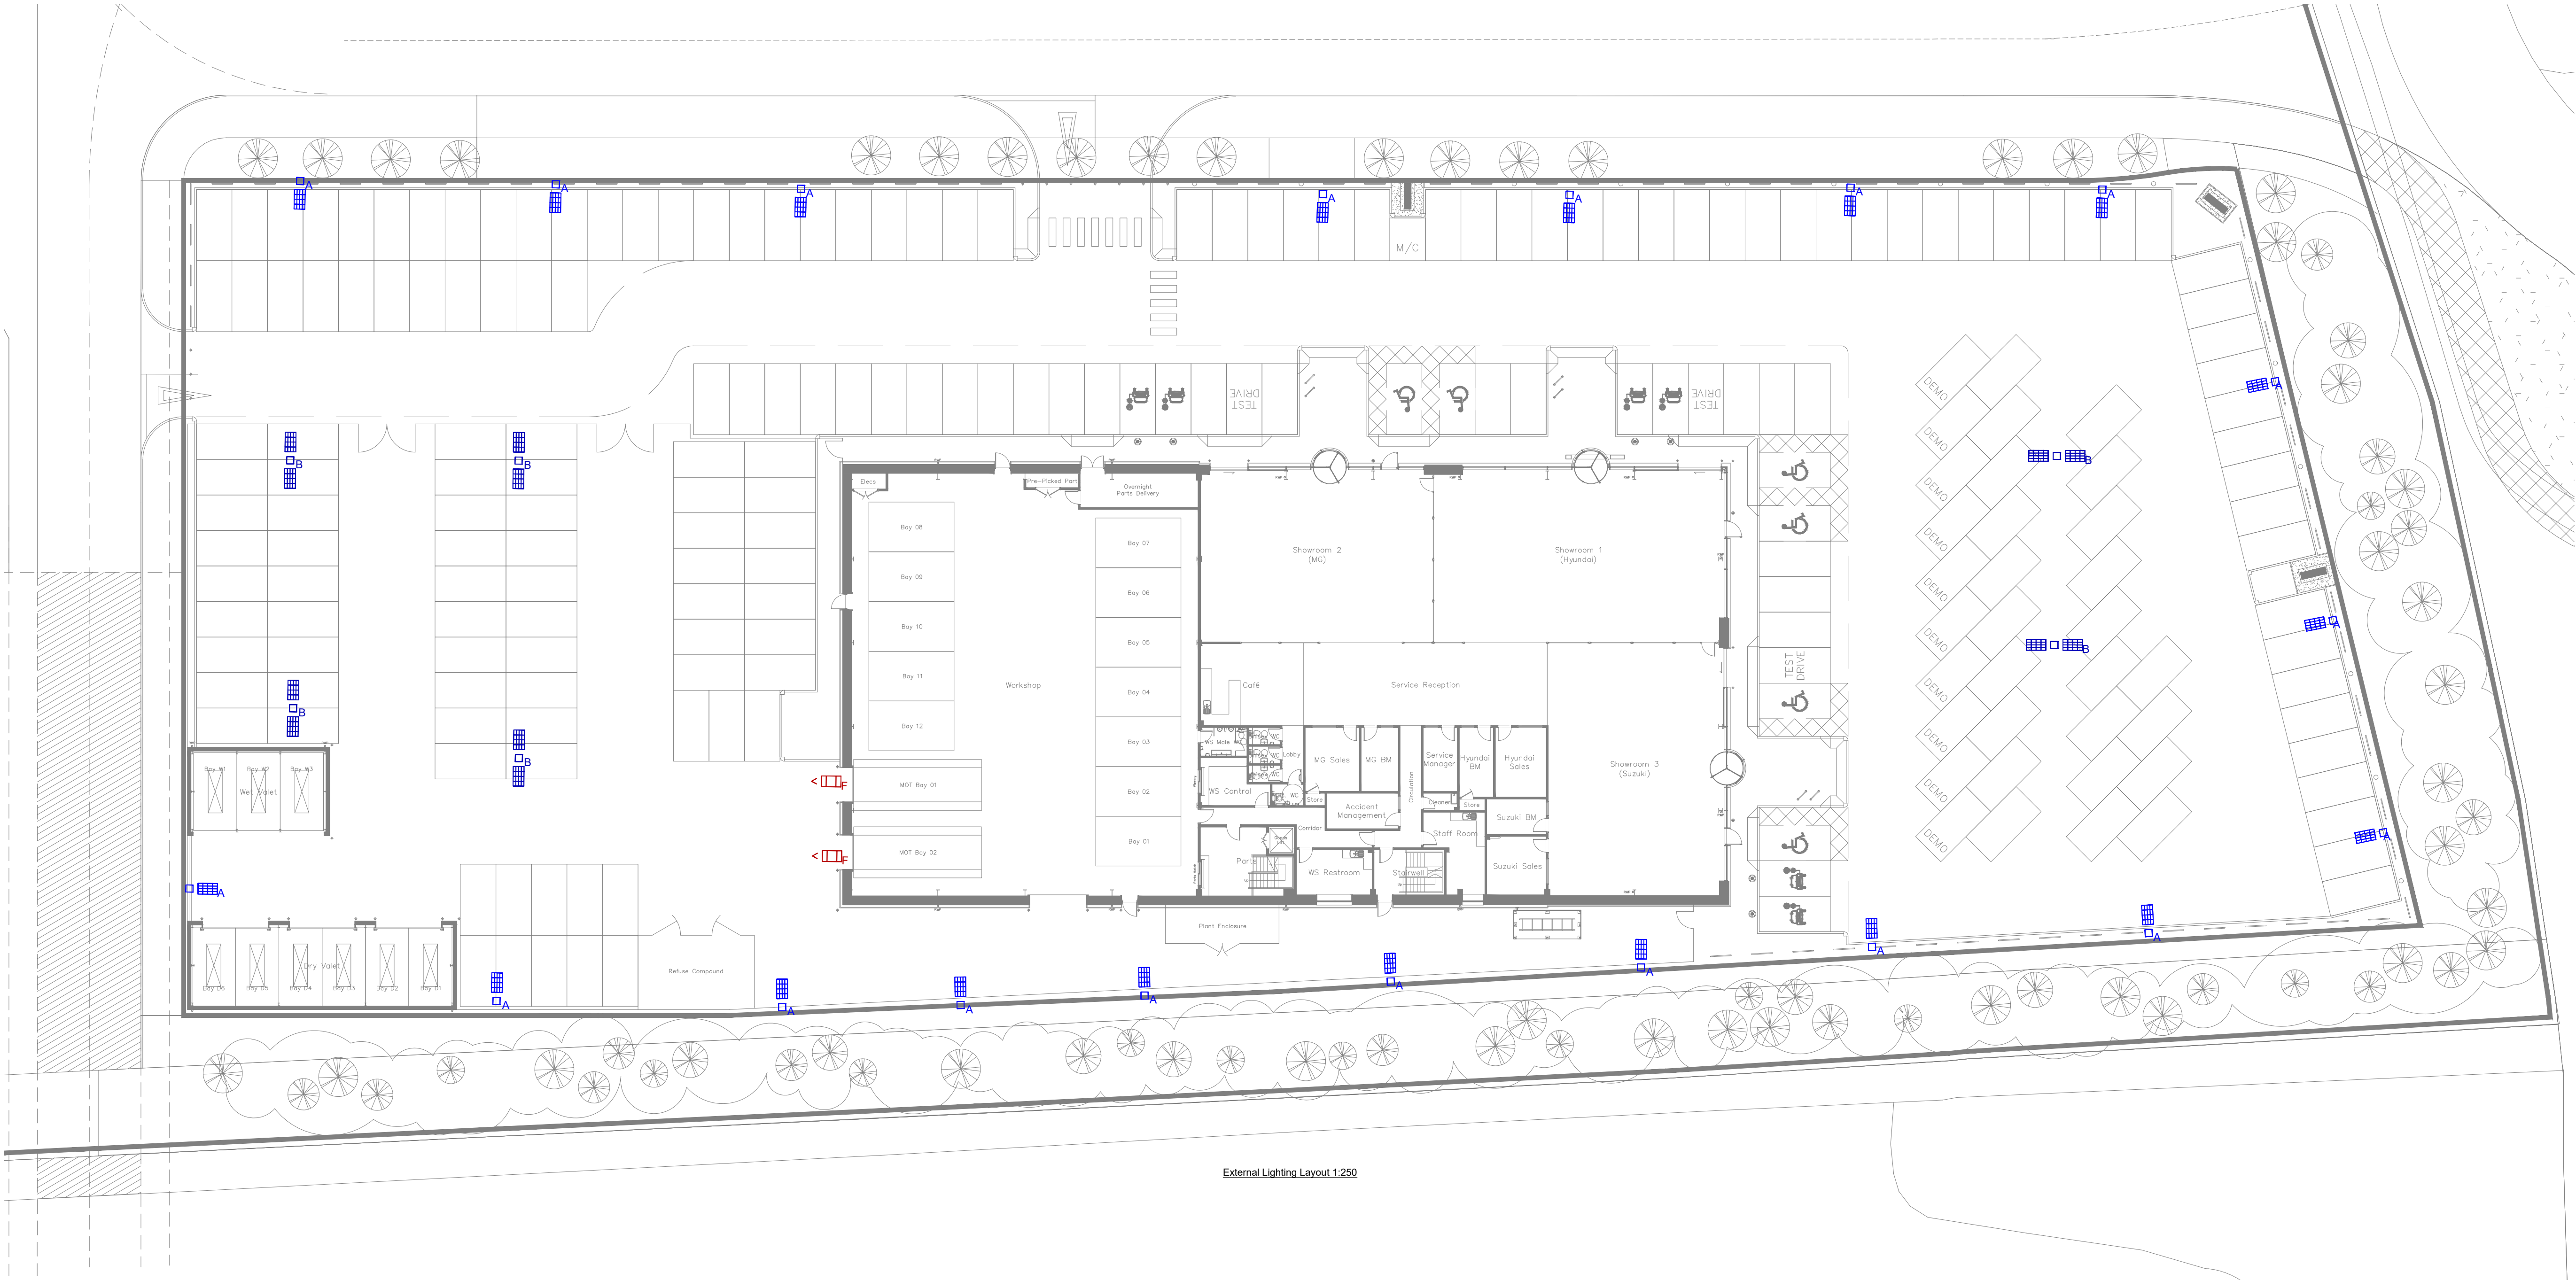

External Lighting Layout 1:250

LUMINAIRE SCHEDULE									
Symbol	Label	Qty	Catalog Number	Description	Lamp	File	Lumens	LLF	Watts
	A	20	FTS.2.LA054.AY	FACTOR SMALL STREETLIGHT Single Head Column mount at 6m	LED C.5000LM-4000K	FTS.2.LA054.A.Y.ies	Absolute	0.90	35
	B	6	FTS.2.LA054.AY	FACTOR SMALL STREETLIGHT Twin Head column mount at 6m	LED C.5000LM-4000K	FTS.2.LA054.A.Y.ies	Absolute	0.90	70
	F	2	FTS.2.LA054.AY	FACTOR SMALL STREETLIGHT Single Head Column mount at 6m	LED C.5000LM-4000K	FTS.2.LA054.A.Y.ies	Absolute	0.90	35



A Type light fitting



D Type light fitting

Rev	Date	Description	Cad Chk
-----	------	-------------	---------

Architect

**BOYLE + SUMMERS**
ARCHITECTS AND INTERIORS

Client
Richmond Motor Group

Project
RMG Showroom

Drawing Title
**Electrical Services
External Lighting Layout**

**ScotchPartners**

Building Services Engineering | Sustainability | Acoustics
Scriptor Court
157 Farringdon Road
London EC1R 3AD
020 3544 5400
www.scotchpartners.com

Issue **Planning**
Date Nov 18 Scale @ A1 1:250
Drawn By MW Checked By JB
Drawing No. **5203-SP-E-150**

Rev **P0**