


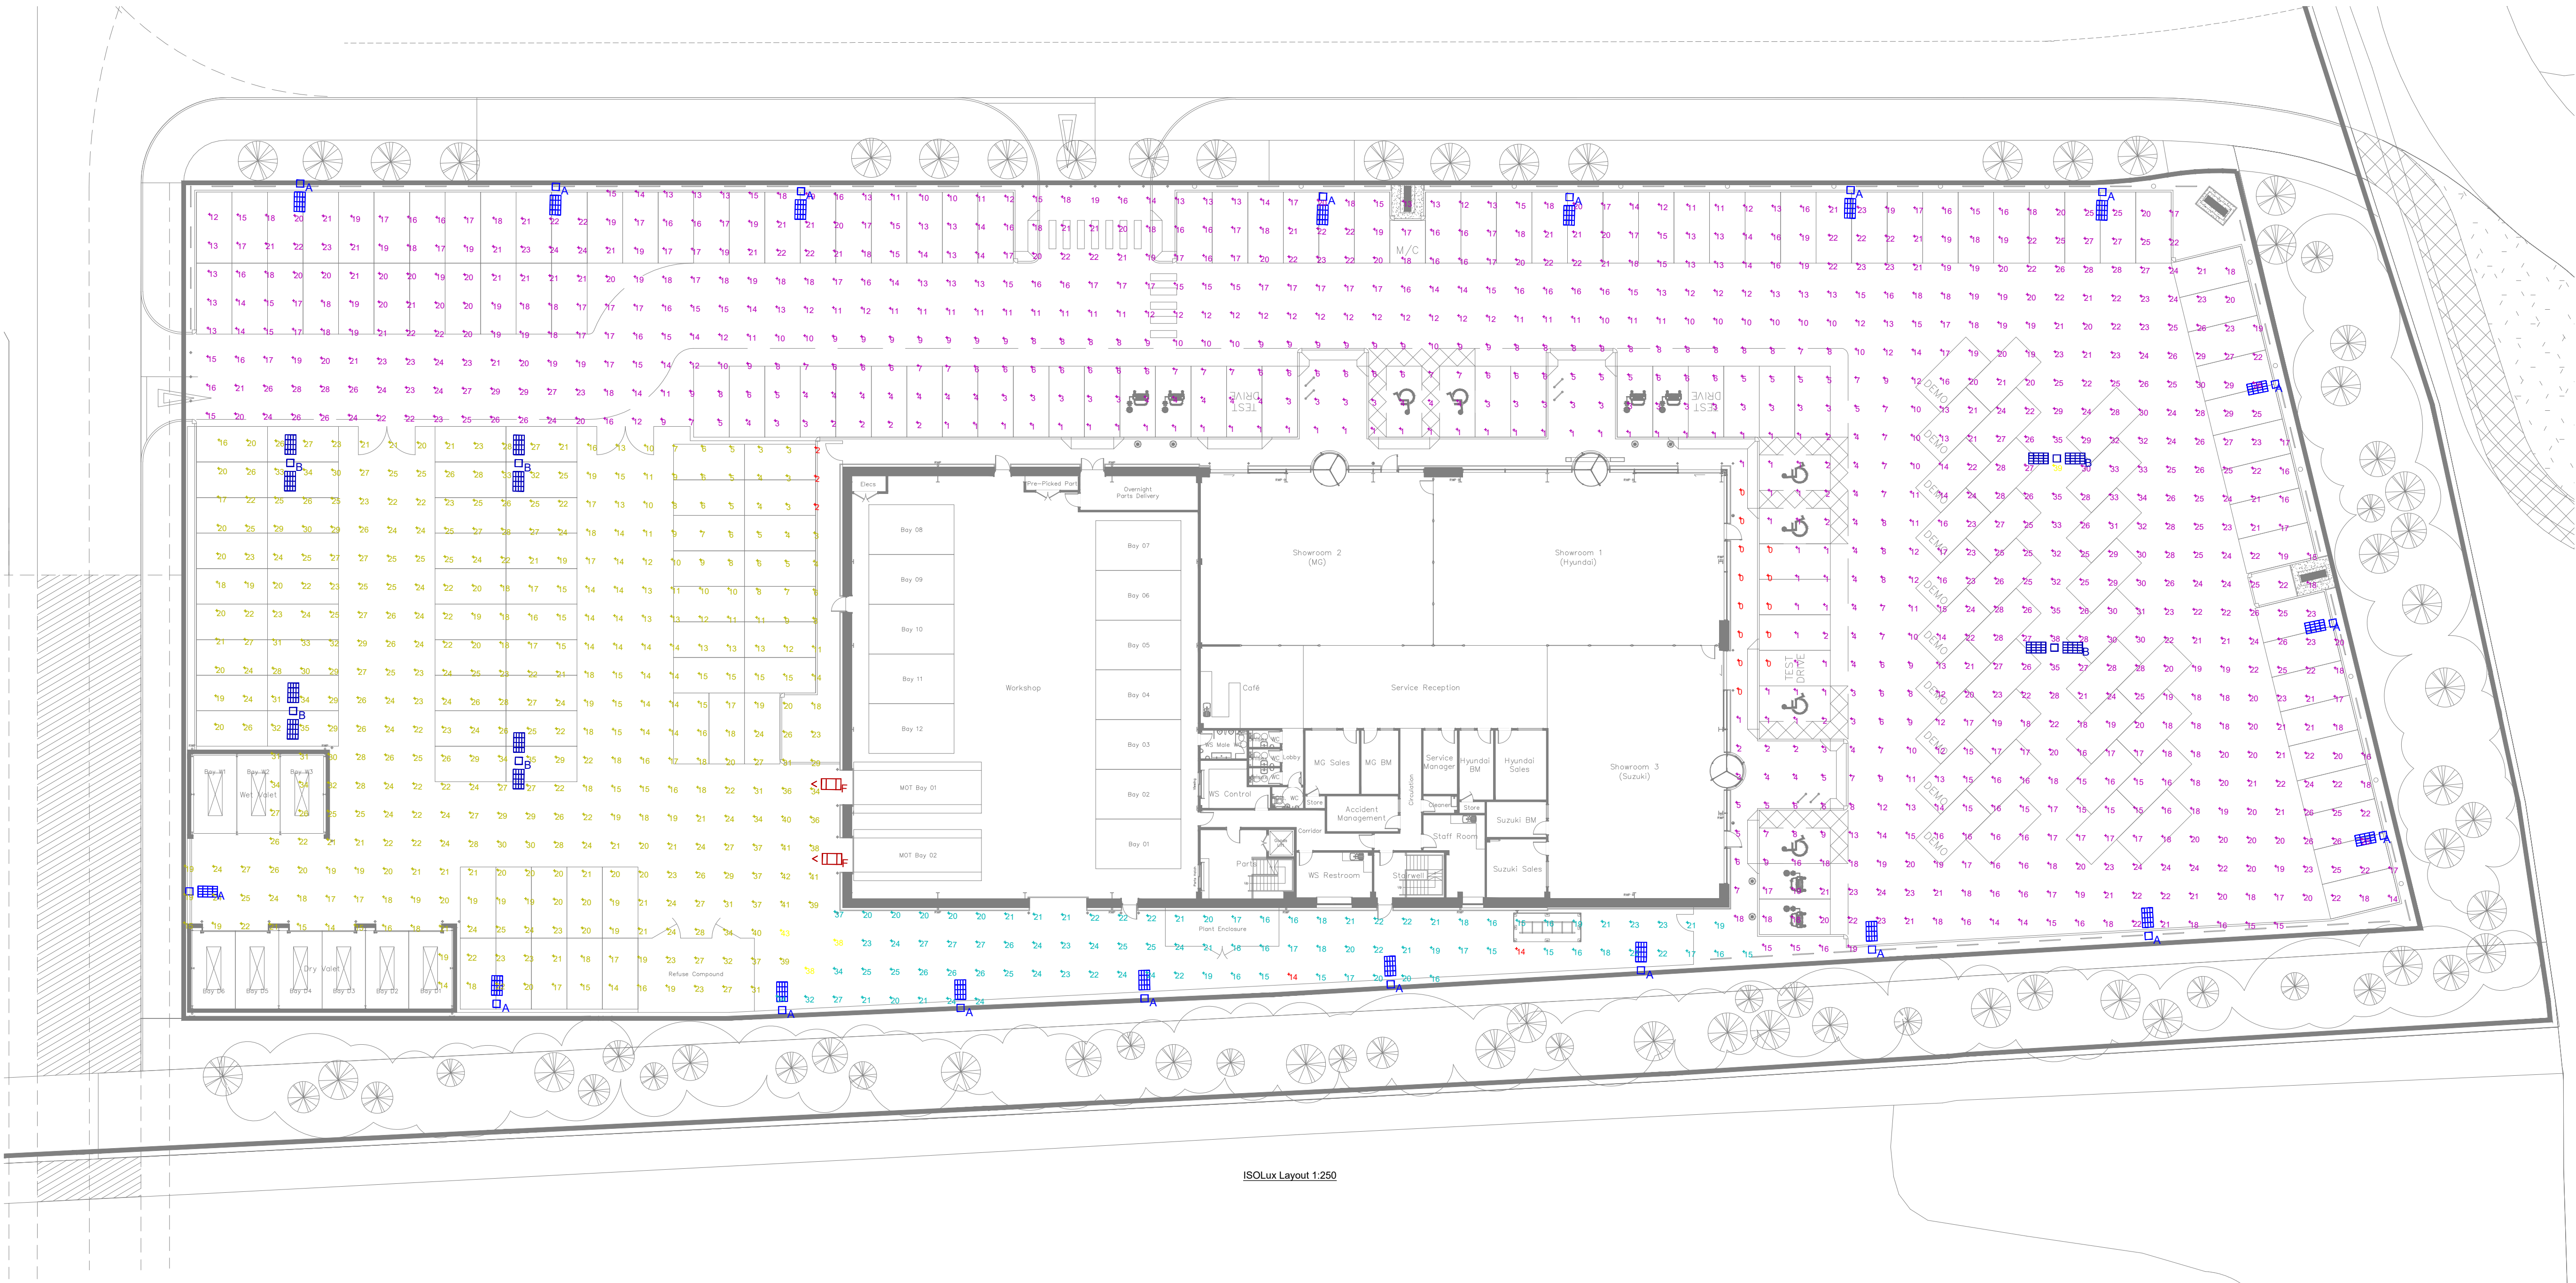

LUMINAIRE SCHEDULE									
Symbol	Label	Qty	Catalog Number	Description	Lamp	File	Lumens	LLF	Watts
	A	20	FTS.2.LA054.AY	FACTOR SMALL STREETLIGHT Single Head Column mount at 6m	LED C.5000LM-4000K	FTS.2.LA054.A.Y.ies	Absolute	0.90	35
	B	6	FTS.2.LA054.AY	FACTOR SMALL STREETLIGHT Twin Head column mount at 6m	LED C.5000LM-4000K	FTS.2.LA054.A.Y.ies	Absolute	0.90	70
	F	2	FTS.2.LA054.AY	FACTOR SMALL STREETLIGHT Single Head Column mount at 6m	LED C.5000LM-4000K	FTS.2.LA054.A.Y.ies	Absolute	0.90	35

STATISTICS					
Description	Symbol	Avg	Max	Min	Min/Avg
Access Area	+	22 lux	38 lux	14 lux	0.64
Car Park	+	16 lux	39 lux	0 lux	0.00
Service Yard Car Park	+	21 lux	43 lux	2 lux	0.10



A Type light fitting



D Type light fitting

Rev	Date	Description	Cad	Chk
-----	------	-------------	-----	-----



Client
Richmond Motor Group

Project
RMG Showroom

Drawing Title
Electrical Services
External Lighting
Isolux Plot



Building Services Engineering | Sustainability | Acoustics
ScotchPartners
107 Farringham Road
London EC1R 3AD
020 3544 5400
www.scotchpartners.com

Copyright reserved. Work is signed dimensions only. Discrepancies to be reported before proceeding.

Issue	Date	Scale	Rev
Planning	Nov 18	@ A1	P0
Drawn By	MW	Checked By	JB
Drawing No.	5203-SP-E-151		