




Site Plan

For details of refuse vehicle turning refer to ABMH drawing FC2921/13B

SCALE 1:250


Underground fire hydrant to BS 750 and BS EN 14339 supplied by dedicated water service with a flow rate of 1500 l/min from the outlet when provided with a constant pressure of 1.7 bar with plate to BS 3251 Specification. Indicator plates for fire hydrants and emergency water supplies (1976). Arrangements should be made by the owners or the occupiers to ensure that, at least once a year, maintenance is carried out on all private fire hydrants by a competent person.

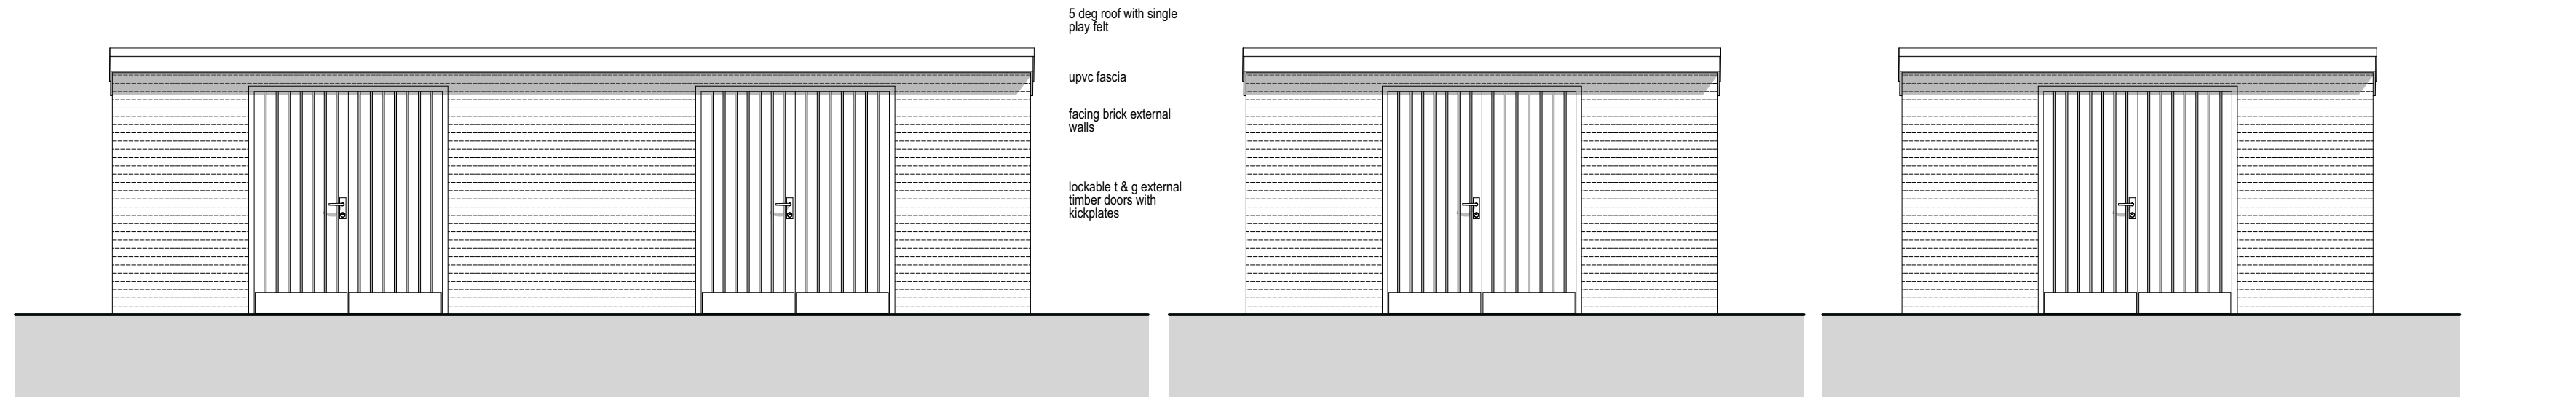

Bin and cycle store 1 front elevation

Bin store 2 front elevation


Cycle store 2 front elevation

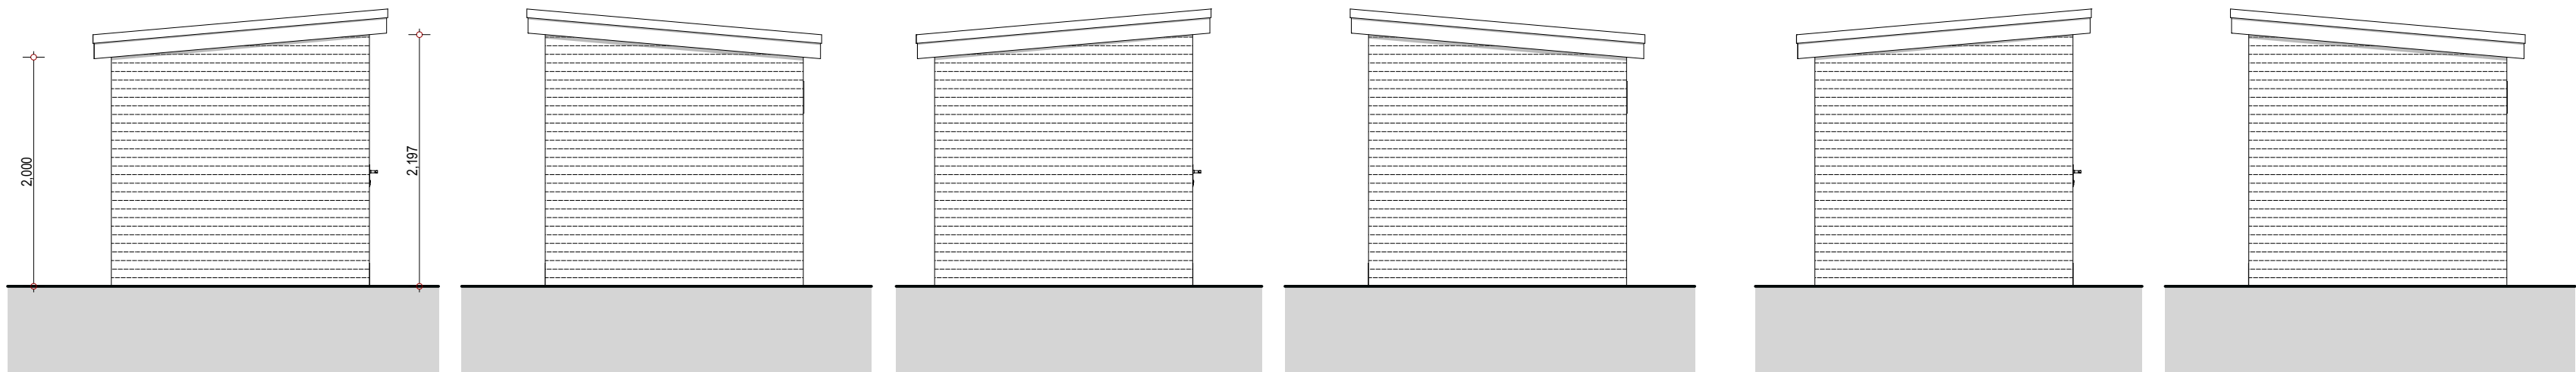

Bin and cycle store 1 side elevations

Bin store 2 side elevations

Cycle store 2 side elevations

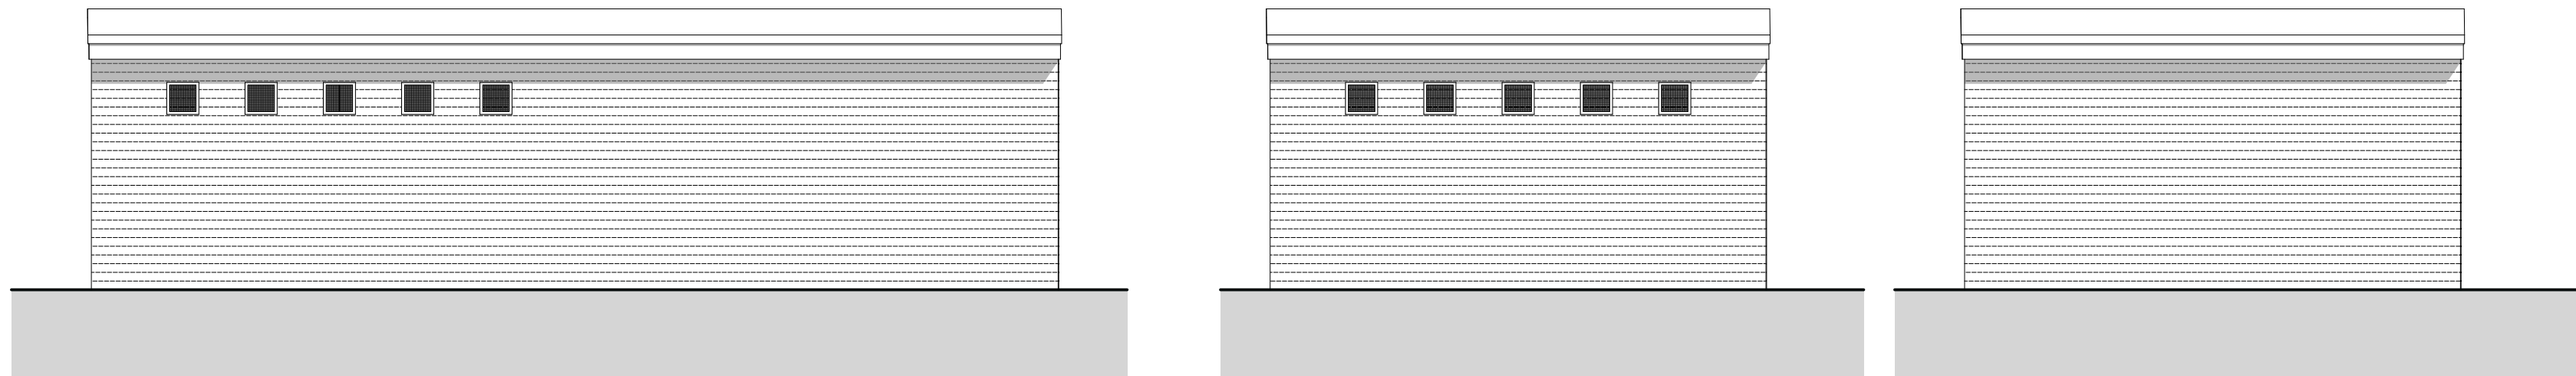


Bin and cycle store 1 rear elevation

Bin store 2 rear elevation


Cycle store 2 rear elevation

SCALE 1:50

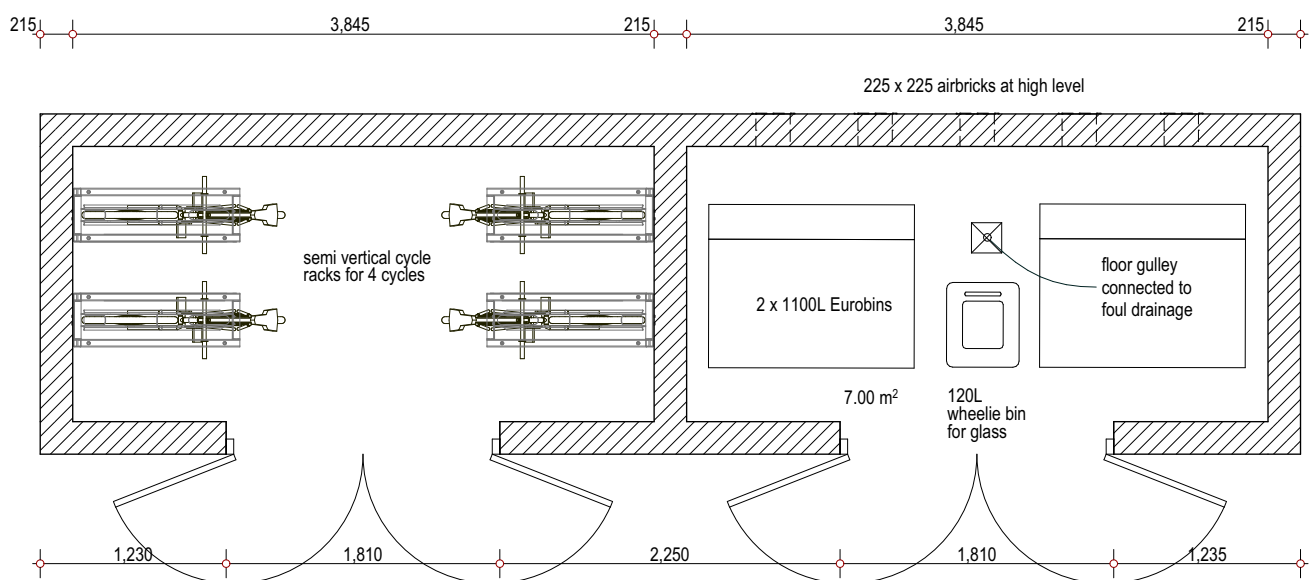


Bin and cycle store 1

SCALE 1:50

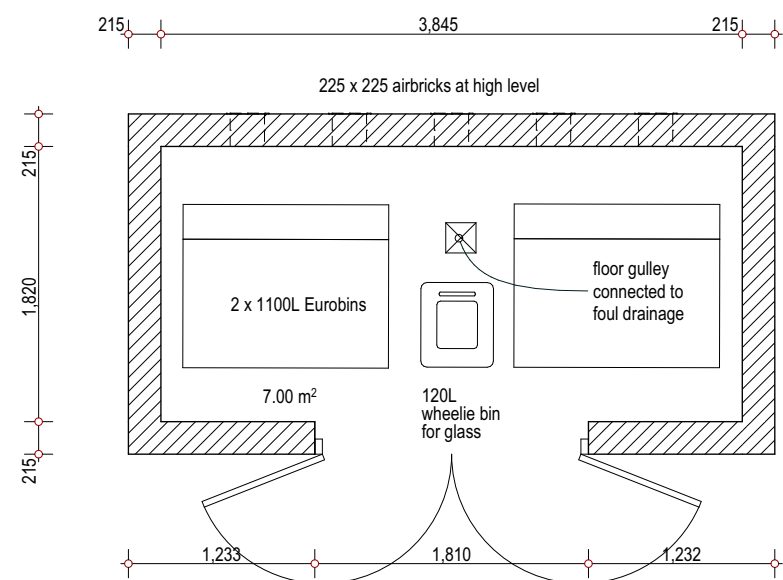

Bin store 2

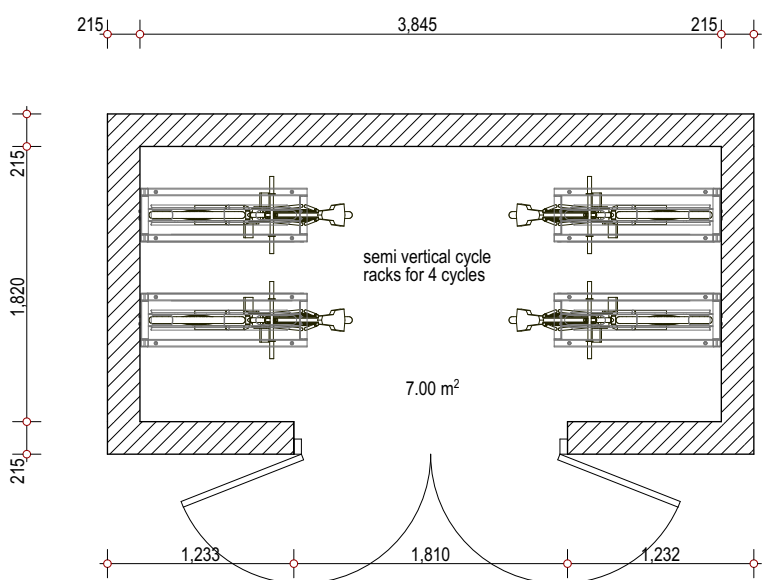

Cycle store 2

All dimensions in millimetres. Where dimensions are not given, drawings must not be scaled and matter referred back to CLOUD9 DESIGN STUDIO with the exception of drawings for planning purposes only.
All dimensions and conditions are to be checked on site by the contractor prior to preparing drawings or commencing any work. The contractor is responsible for checking that there is no conflict between site dimensions and drawn dimensions.
In the event of any detail or dimensional conflict with CLOUD9 DESIGN STUDIO drawings, the matter must be referred back to CLOUD9 DESIGN STUDIO for clarification.

CLOUD9 DESIGN STUDIO
(N) 07792 379302 (E) ryan.siddons.co@gmail.com (R) cloud9designstudio.co.uk

Client Patrick Cullen

Project Proposed Commercial Units
Chalcroft Nursery
Chalcroft Lane
Bersted PO21 5TS

Drawing Title Refuse collection and store details
Fire hydrant location

Drawing CND40_115 Rev
Date OCT 2025 Scale 1 : 250