


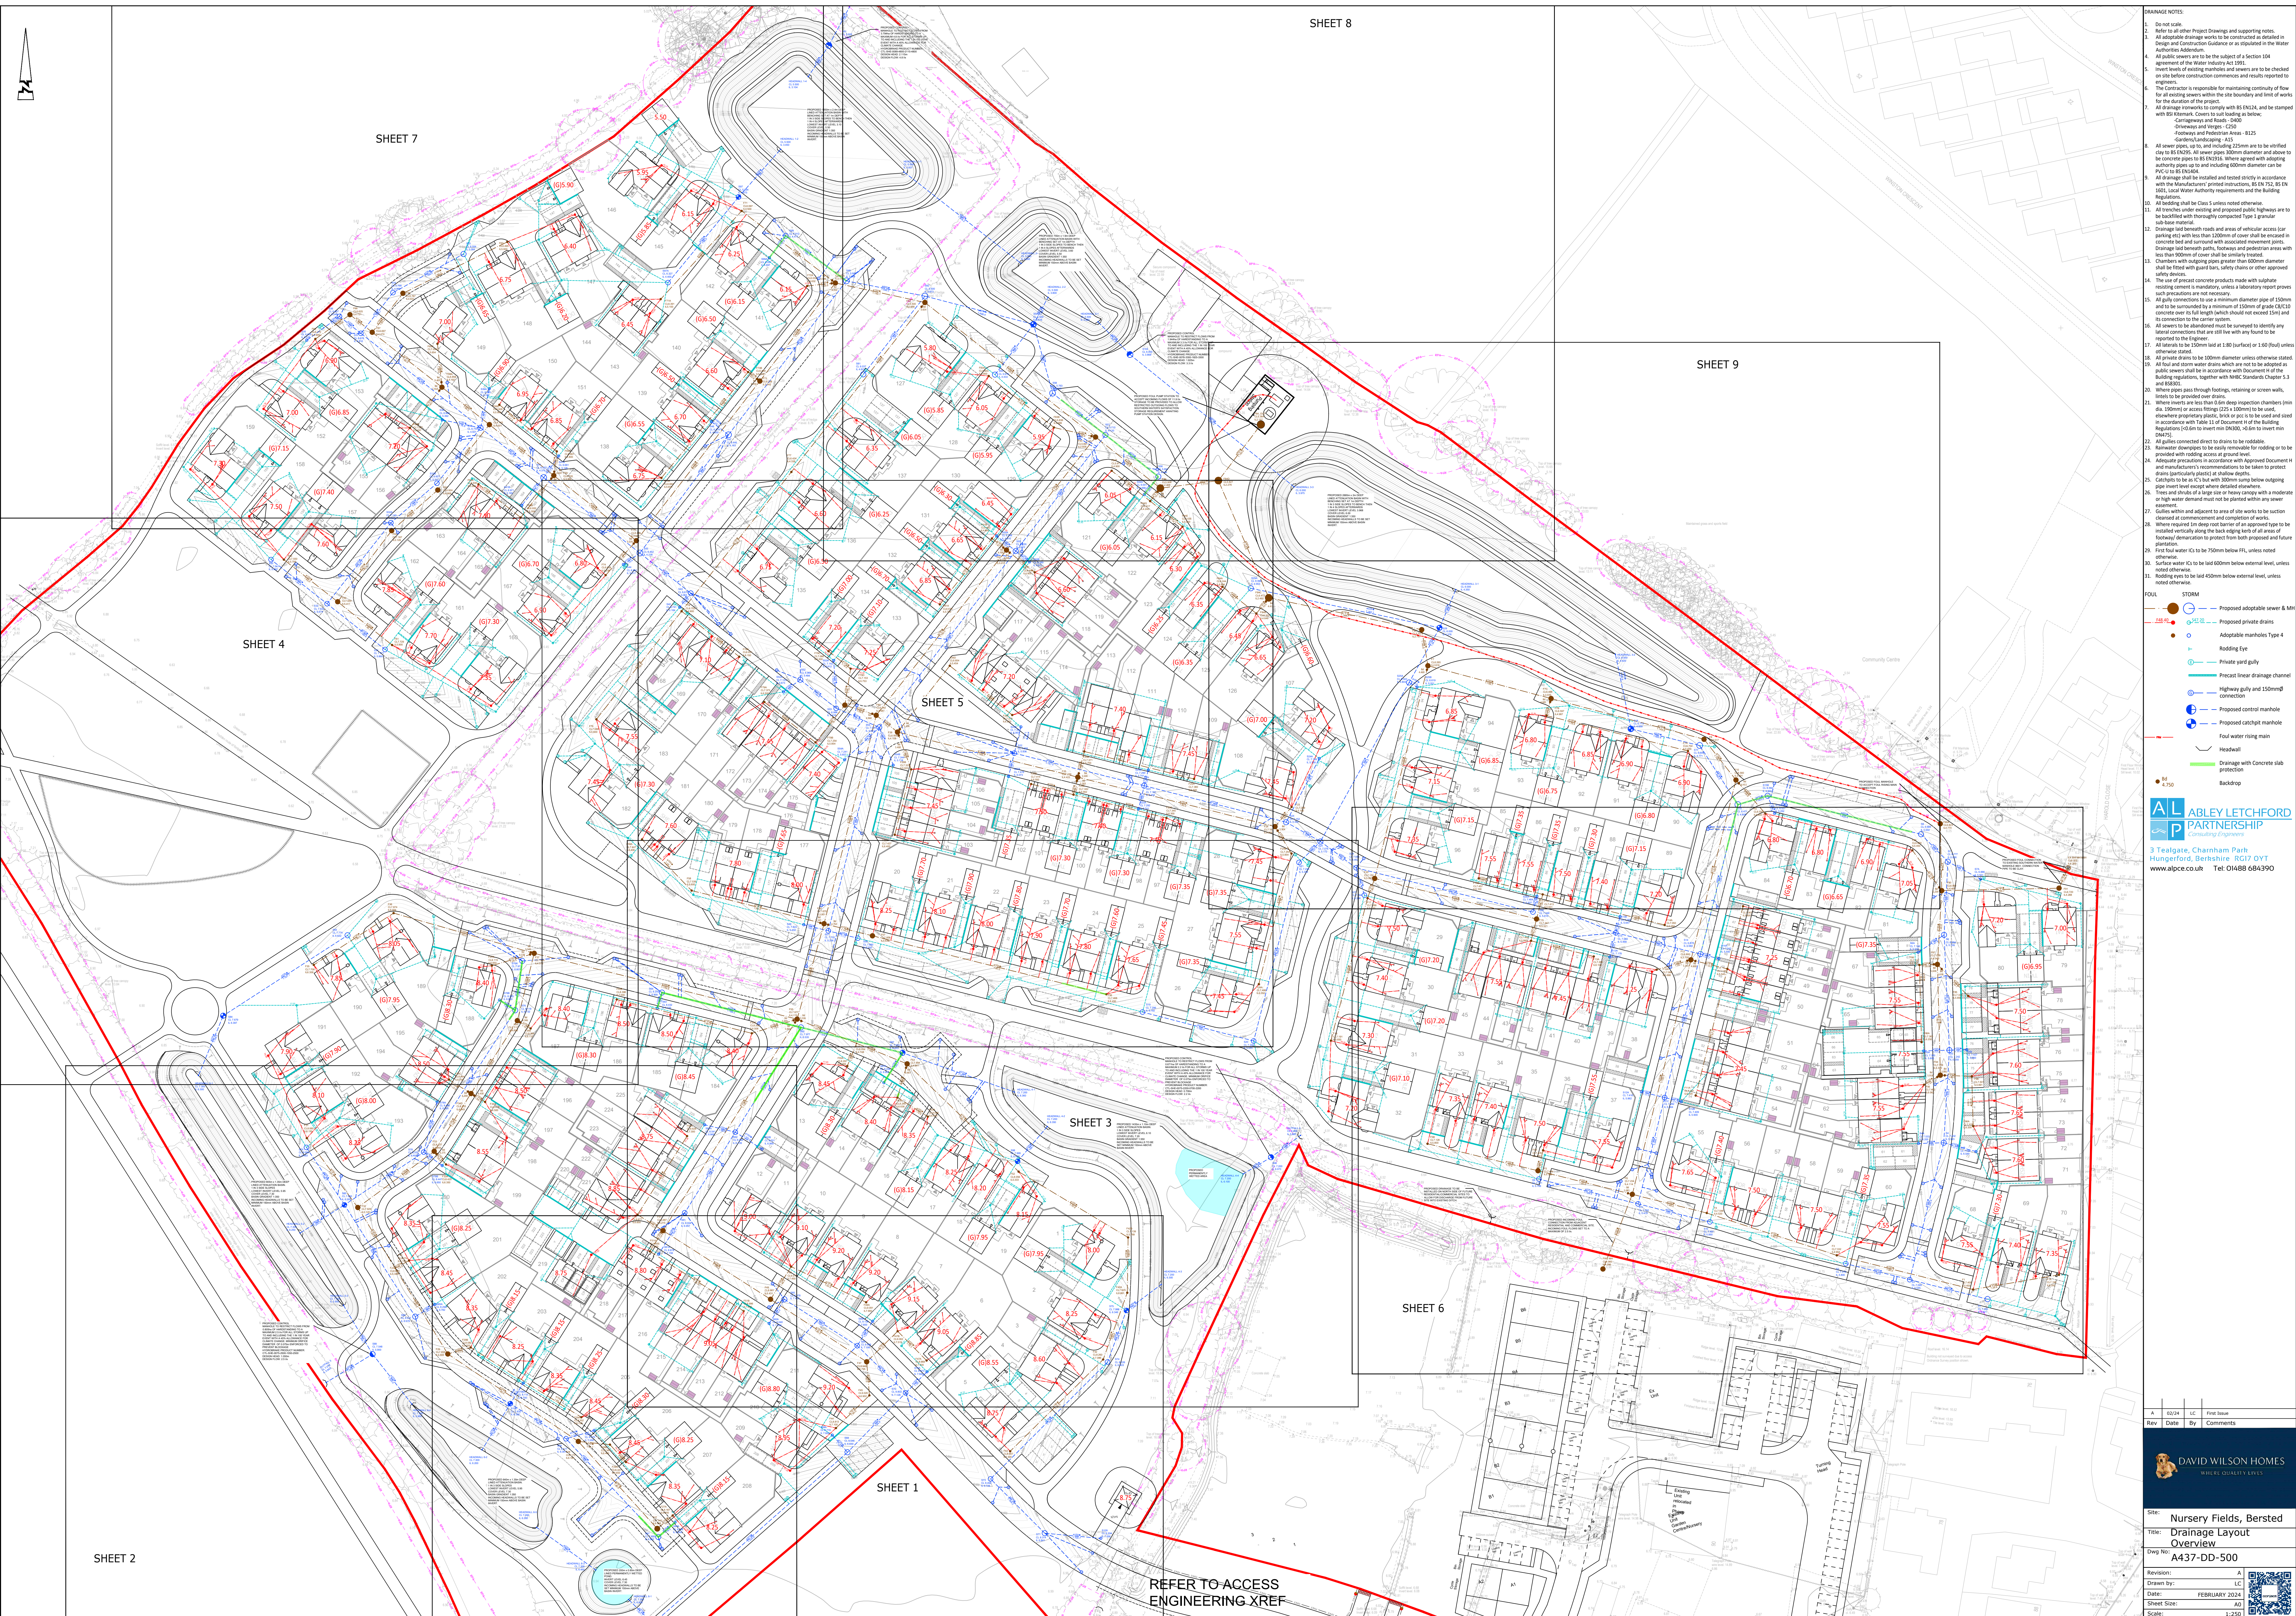

- [illegible]

- FOUL**
- STORM**
- Proposed adoptable sewer & MH
 - Proposed private drains
 - Adoptable manholes Type 4
 - Rodding Eye
 - Private yard gully
 - Precast linear drainage channel
 - Highway gully and 150mmØ connection
 - Proposed control manhole
 - Proposed catchpit manhole
 - Foul water rising main
 - Headwall
 - Drainage with Concrete slab protection
 - Backdrop

AL ABLE LETCHFORD
P PARTNERSHIP
Consulting Engineers

3 Tealgate, Charnham Park
Hungerford, Berkshire RG17 0YT
www.alpce.co.uk Tel: 01488 684390

A	6/2/24	LC	First Issue
Rev	Date	By	Comments



DAVID WILSON HOMES

WHERE QUALITY LIVES

Site: Nursery Fields, Bersted

Title: Drainage Layout Overview

Dwg No: A437-DD-500

Revision: A

Drawn by: LC

Date: FEBRUARY 2024

Sheet Size: A0

Scale: 1:250

