


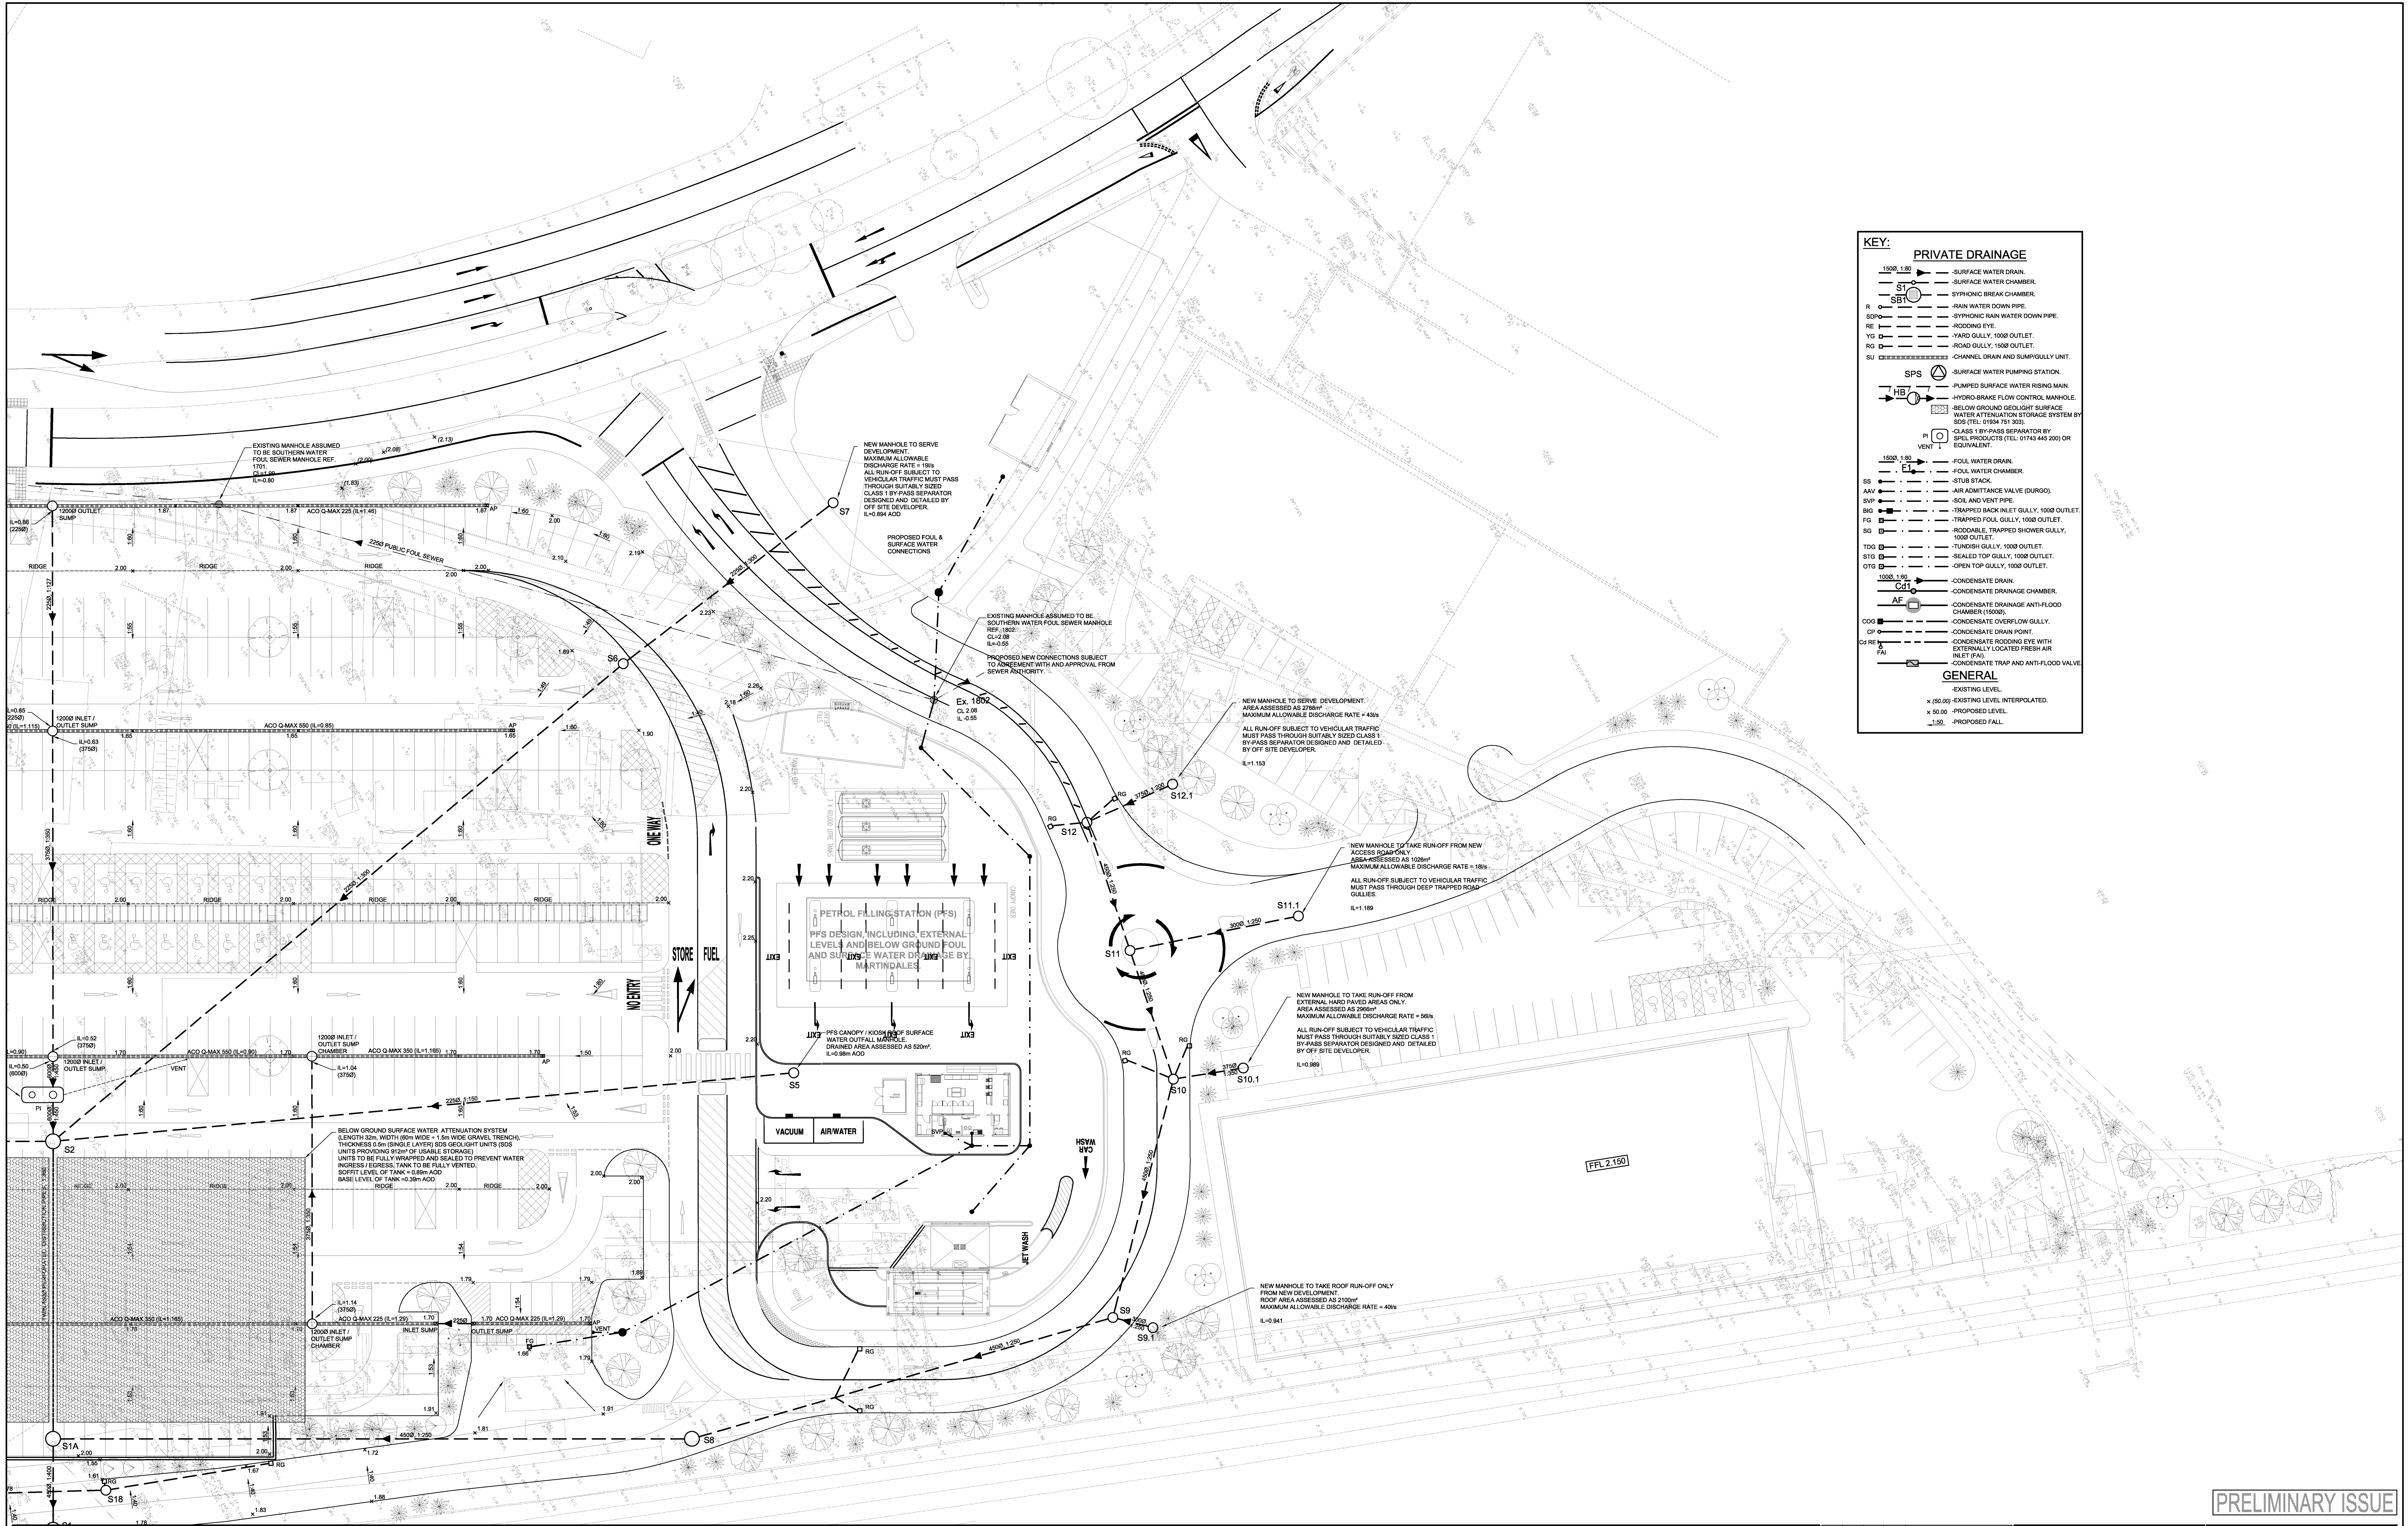

KEY:

PRIVATE DRAINAGE

- 1500, 1.80 — SURFACE WATER DRAIN.
- ST — SURFACE WATER CHAMBER.
- SB — SYPHONIC BREAK CHAMBER.
- R — RAIN WATER DOWN PIPE.
- SDP — SYPHONIC RAIN WATER DOWN PIPE.
- RE — RIDDING EYE.
- YG — YARD GULLY, 1000 OUTLET.
- RG — ROAD GULLY, 1000 OUTLET.
- SU — CHANNEL DRAIN AND SUMP/GULLY UNIT.
- SPS — SURFACE WATER PUMPING STATION.
- HB — PUMPED SURFACE WATER RISING MAIN.
- HB — HYDRO-BRAKE FLOW CONTROL MANHOLE.
- SG — BELOW GROUND GEOLIGHT SURFACE WATER ATTENUATION STORAGE SYSTEM BY SPS (TEL: 01934 751 303).
- PI — CLASS 1 BY-PASS SEPARATOR BY SPEL PRODUCTS (TEL: 01743 445 200) OR EQUIVALENT.
- 1500, 1.80 — FOUL WATER DRAIN.
- E1 — FOUL WATER CHAMBER.
- SS — STUB STACK.
- AAV — AIR ADMITTANCE VALVE (DURDO).
- SVP — SOIL AND VENT PIPE.
- BIG — TRAPPED BACK INLET GULLY, 1000 OUTLET.
- FG — TRAPPED FOUL GULLY, 1000 OUTLET.
- SG — RODDABLE TRAPPED SHOWER GULLY, 1000 OUTLET.
- TG — TUNDRUSH GULLY, 1000 OUTLET.
- STG — SEALED TOP GULLY, 1000 OUTLET.
- OTG — OPEN TOP GULLY, 1000 OUTLET.
- 1000, 1.80 — CONDENSATE DRAIN.
- Cd1 — CONDENSATE DRAINAGE CHAMBER.
- AF — CONDENSATE DRAINAGE ANTI-FLOOD CHAMBER (15000).
- COG — CONDENSATE OVERFLOW GULLY.
- GP — CONDENSATE DRAIN POINT.
- CP — CONDENSATE RIDDING EYE WITH EXTERNALLY LOCATED FRESH AIR INLET (FAL).
- ON — CONDENSATE TRAP AND ANTI-FLOOD VALVE.

GENERAL

- EXISTING LEVEL.
- x (50.00) — EXISTING LEVEL INTERPOLATED.
- x 50.00 — PROPOSED LEVEL.
- 1.50 — PROPOSED FALL.

NOTES

- DO NOT SCALE THIS DRAWING.
- THIS DRAWING TO BE READ IN CONJUNCTION WITH ALL OTHER RELEVANT ENGINEERS' AND ARCHITECTS' DRAWINGS AND SPECIFICATIONS.
- BASE DRAWING INFORMATION IS TAKEN FROM THE FOLLOWING:
a. SHAW COLEGATE, 14107_TOPO, REV A
b. CHQ PARTNERSHIP LTD, DRAWING TITLE: PROPOSED SITE PLAN, CHQ-12-9891-400.
c. CHQ PARTNERSHIP LTD, PROPOSED STORE PLAN, 2296901-SP, REV A
- PUBLIC SEWER INFORMATION, AND STATUTORY SERVICE INFORMATION IF SHOWN IS BASED ON INFORMATION PROVIDED BY OR INTERPOLATED FROM PUBLIC SEWER AUTHORITY AND SERVICE PROVIDERS RECORDS. ALL INFORMATION RELATING TO SEWERS AND SERVICES TO BE VERIFIED ON SITE BY CONTRACTOR AND ENGINEER INFORMED IF INFORMATION DIFFERS FROM THAT SHOWN.
- INVERT LEVELS OF EXISTING DRAINAGE AT PROPOSED OUTFALL TO BE VERIFIED ON SITE BY CONTRACTOR PRIOR TO CONSTRUCTION OF ANY DRAINAGE.

F	19/09/12	14107_TOPO	DISTRIBUTION PIPE THROUGH ATTENUATION TANK AMENDED TO TWIN 450.	
E	14/09/12	14107_TOPO	STORE PLAN UPDATED.	
D	08/09/12	14107_TOPO	CAR PARK DRAINAGE AMENDED.	
C	02/09/12	14107_TOPO	SURFACE WATER DRAINAGE AMENDED.	
B	23/04/12	14107_TOPO	STORE AND SITE PLAN UPDATED, DRAINAGE LAYOUT AMENDED TO SUIT.	
-	12/04/12	14107_TOPO	PRELIMINARY ISSUE.	
-	23/03/12	14107_TOPO	PRELIMINARY ISSUE.	
Mark	Date	By	Chkd.	Revision notes

PRELIMINARY ISSUE

Client: SAINSBURY'S SUPERMARKETS LTD.

Job Title: SAINSBURY'S BOGNOR REGIS.

Drawing Title: ENGINEERING LAYOUT. SHEET 2 OF 2.

Scales: 1:250 at A0

Job No. 28506 Drawing No. 00404 Rev. F

Marked by: gga

gga gary gabriel associates consulting structural & civil engineers

SECRET HOUSE VESTRY ROAD BOGNOR HANTS TEL: 01703 481616 email: info@ggagroup.co.uk www.ggagroup.co.uk