


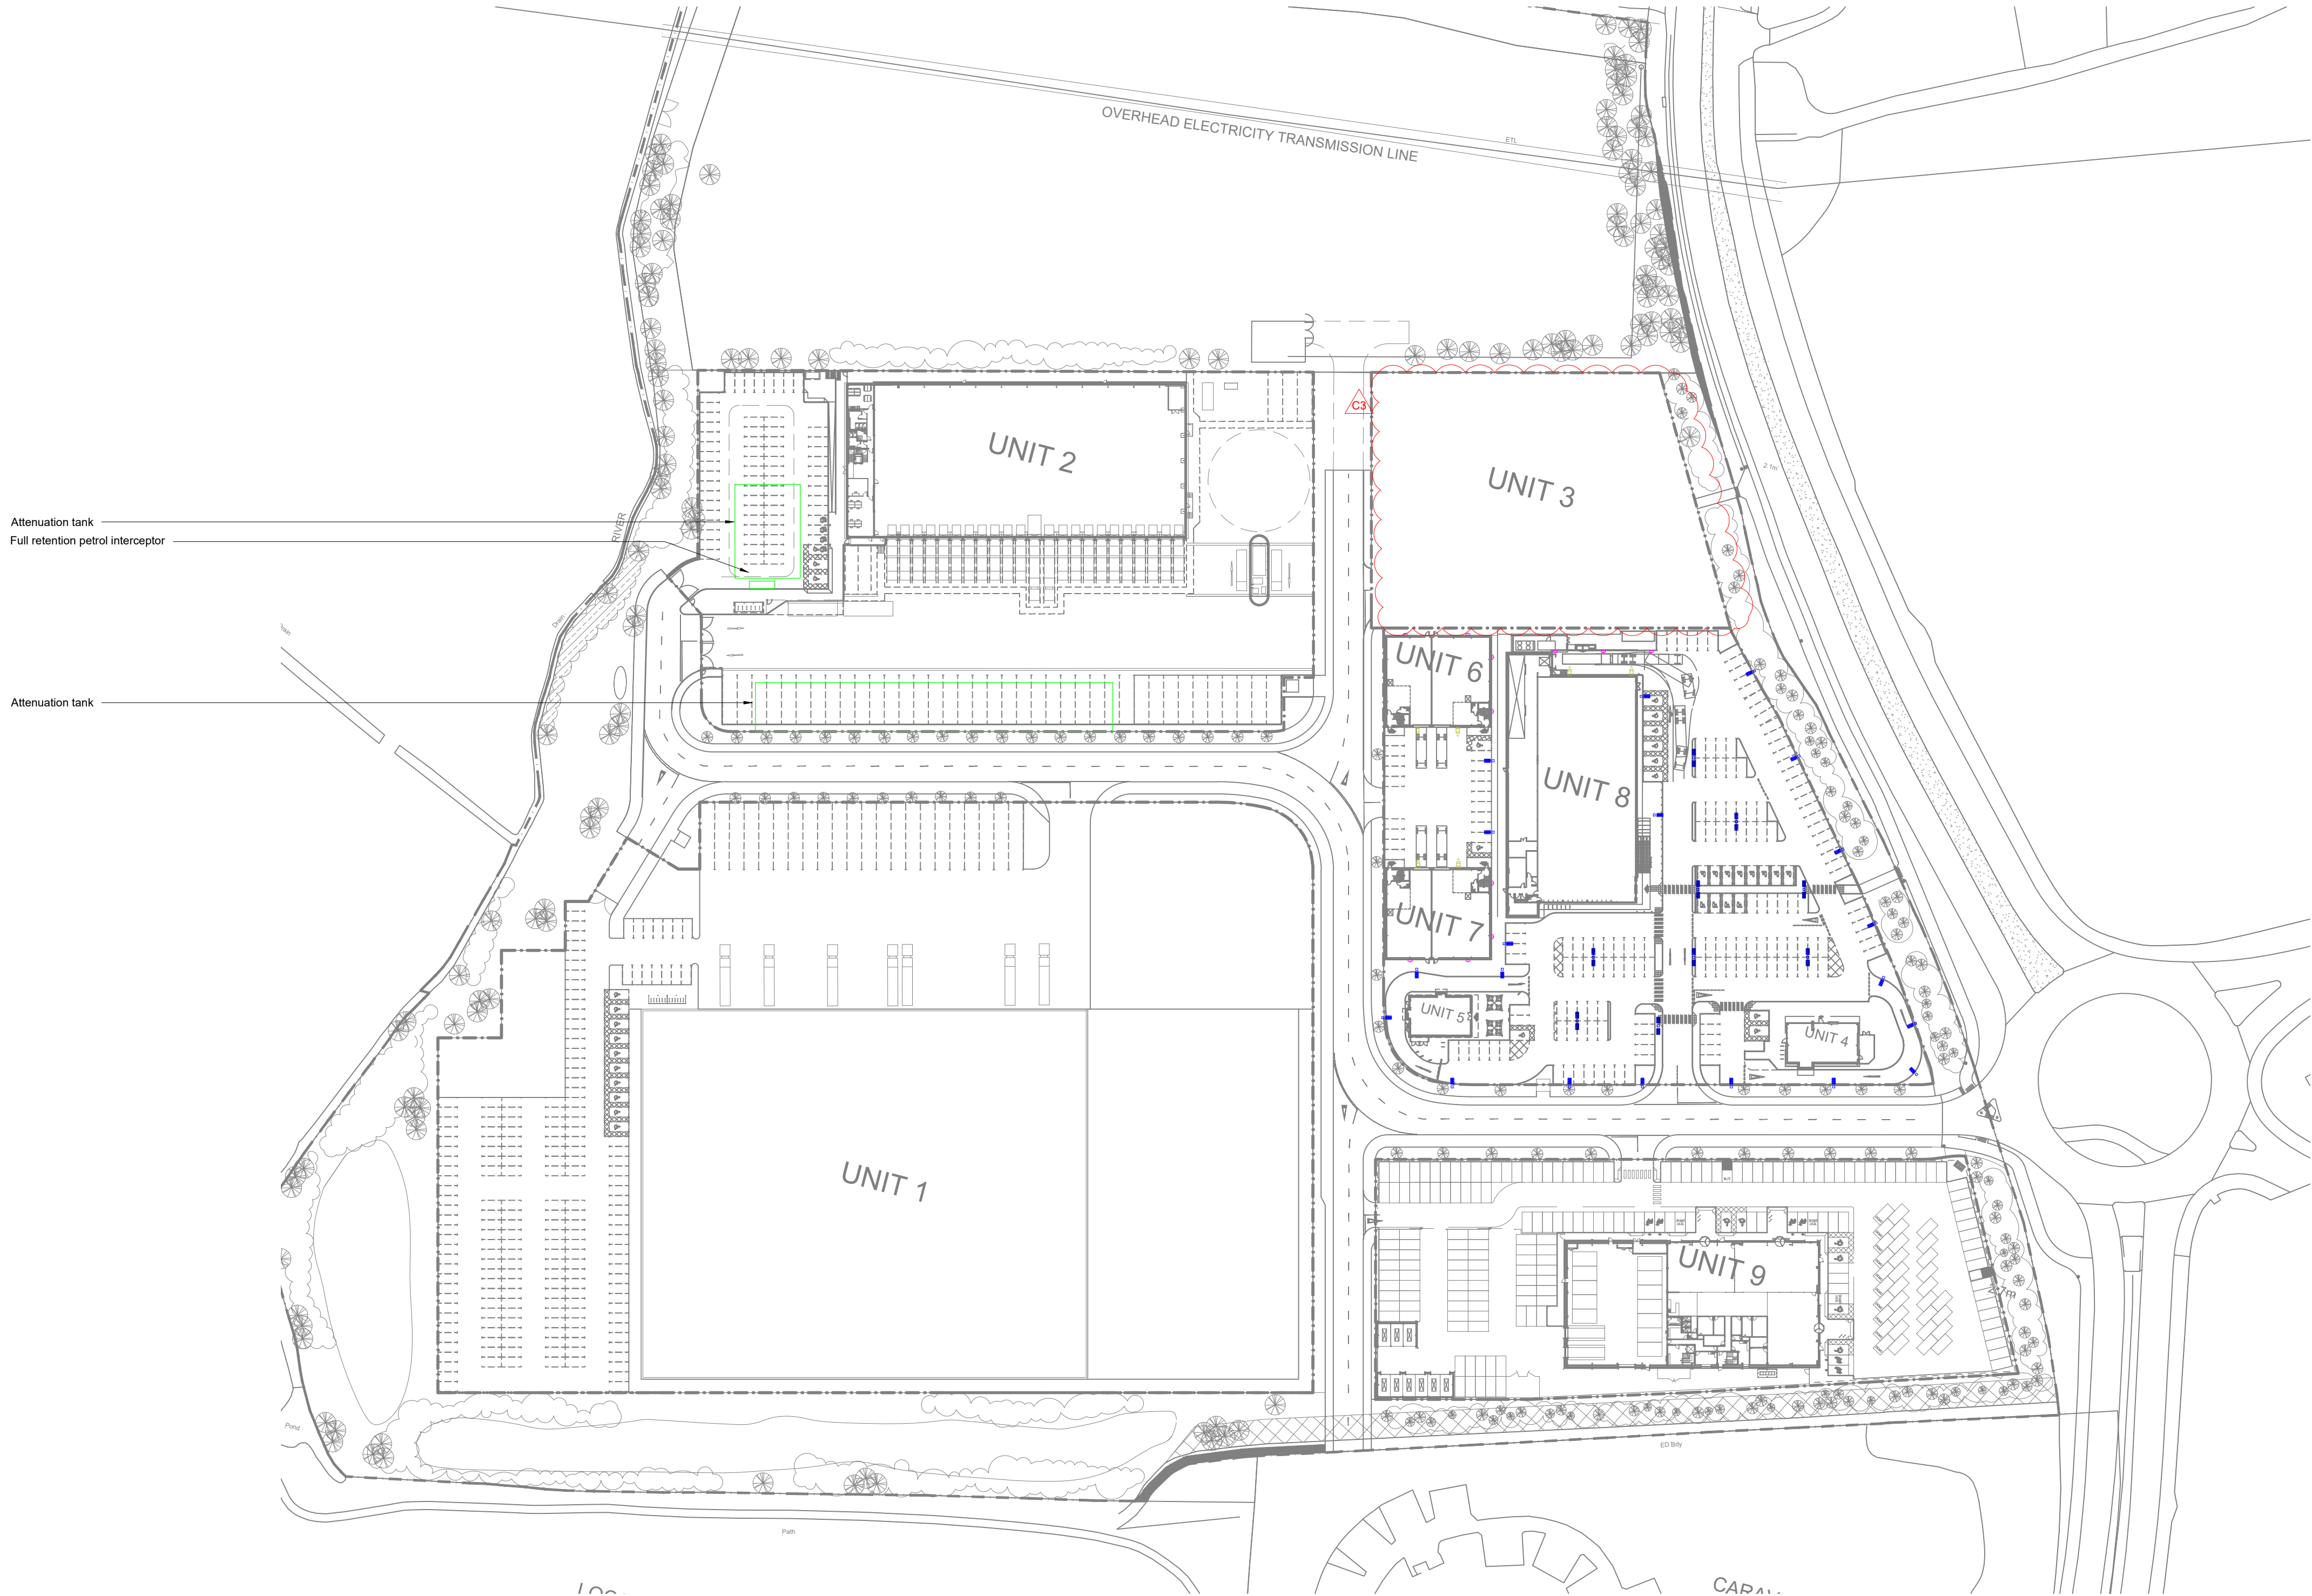

LUMINAIRE SCHEDULE								
Symbol	Label	Qty	Catalog Number	Description	Lamp	File	Lumens	LLF
	A	29	FTS.2.LA054.AY	FACTOR SMALL STREETLIGHT Single Head Column mount at 6m	LED C.5000LM-4000K	FTS.2.LA054.A.Y.Jes	Absolute	0.90
	B	13	FTS.2.LA054.AY	FACTOR SMALL STREETLIGHT Twin Head column mount at 6m	LED C.5000LM-4000K	FTS.2.LA054.A.Y.Jes	Absolute	0.90
	C	2	FTR.2.LA174.AY	FACTOR STREETLIGHT Single Head column mount at 6m	LED C.17000LM-4000K	FTR.2.LA174.A.Y.Jes	Absolute	0.90
	D	17	DEW.LA014.NR.C.GL	Denver Elite Wall mount at 3m	LED C.1000LM - 4000K	DEW.LA014.N.R.CGL.IES	Absolute	0.90
	E	6	FTR.2.LA174.AY	FACTOR STREETLIGHT Wall mount at 3m	LED C.17000LM-4000K	FTR.2.LA174.A.Y.Jes	Absolute	0.90

Note: All external lighting to be photocell / time clock controlled

- Notes
- All external car park lighting shall be supplied / installed and wired by the developer main / electrical contractor
 - All duct sizes and quantities shall be confirmed by the D&B main / electrical contractor
 - Tenant to confirm car park CCTV duct requirements
 - Cable draw pits shall be constructed by the main contractor. All sizes indicated refer to internal dimensions. Pits to have heavy duty, weather-proof covers
 - Cable duct specification as follows:
 - All buried ducts to be Ø150mm PVC unless stated
 - All duct bends to have 'slow bends'
 - All cable duct installations to include nylon draw wires
 - Duct entries into draw pits are to incorporate bell mouths
 - Minimum service depths (unless otherwise stated)below carriageways to be as follows:
 - BT = 450mm B.G.L
 - Electricity = 700mm B.G.L
 - Gas = 600mm B.G.L
 - Water = 900mm B.G.L
 - Minimum space between services under 2m footways to be as follows:
 - BT = 430mm from carriageway
 - Electricity = HV 1500mm from carriageway and LV 1500 / 1720mm from carriageway
 - Gas = 950mm from carriageway
 - Water = 690mm from carriageway
 - 'E' denotes 3hr non maintained emergency battery pack

C3	28/06/2021	Unit 3 lighting omitted	AP	JB
C2	24/01/2020	Revised lighting layout as per updated GA received 24/01/2020	AP	JB
C1	04/09/2019	Revised as clouded to incorporate attenuation tank	AB	JB
Rev	Date	Description	AB	JB
			Rev	CHK

Architect
MountfordPigott
Architecture | Interiors | Design

Client
LandLink Estates

Project
Saltbox

Drawing Title
**Electrical Services
Sitewide
External Lighting Layout**

ScotchPartners
Building Services Engineering | Sustainability | Acoustics
Scotcher Court
107 Farmington Road
London EC1R 3AD
020 3544 5400
www.scotchpartners.com

Issue		Scale @ A1	
Date	Aug 19	1:1000	
Drawn By	AB	Checked By	JB
Drawing No.	5163-SP-EX-111		
Rev	C3		