


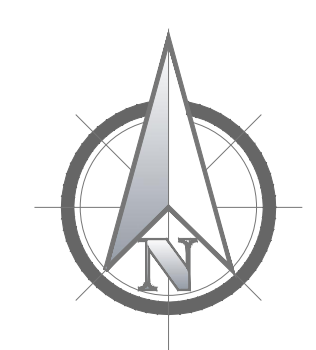


Notes:

GENERAL

1. THIS DRAWING IS FOR PLANNING PURPOSES. CONSULT ALL UTILITY PLANS BEFORE ANY EXCAVATIONS.

2. THIS DRAWING DOES NOT INTEND TO IDENTIFY THE EXACT POSITION OF THE EXISTING APPARATUS. LOCATION OF THE EXISTING APPARATUS MUST IN ALL CASES BE IDENTIFIED BY CONSULTING THE RELEVANT NETWORK OWNERS IN THE AREA.

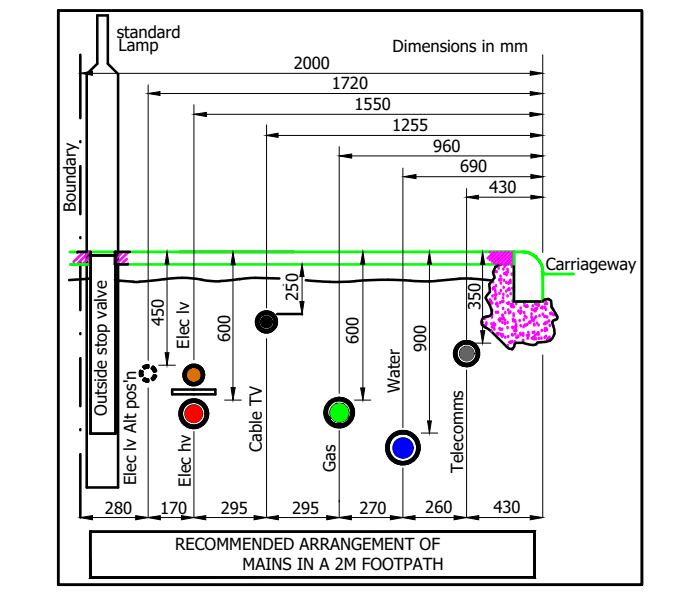


- LEGEND**
- PROPOSED 90mm BT
 - PROPOSED 50mm BT
 - PROPOSED 96mm HYPEROPTIC
 - PROPOSED 54mm HYPEROPTIC
 - PROPOSED MF GAS MAIN
 - PROPOSED LP GAS MAIN
 - 11kV PROPOSED CABLE
 - PROPOSED LV CABLE
 - PROPOSED PRIVATE LV CABLE
 - PROPOSED WATER MAIN
 - PROPOSED LP DUCTED SERVICE
 - PROPOSED LV DUCTED SERVICE
 - PROPOSED COMMUNICATION PIPE
 - CAP END
 - BOTTLE END & EARTH ROD
 - FIRE HYDRANT / WASH ROD
 - BOUNDARY BOX
 - LIGHTING COLUMN
 - FEEDER PILLAR
 - EXISTING BOX JBF 106
 - PROPOSED BT BUILT BOX JBF 104
 - JOINT BOX JBF 104/JUF 102 OR 10
 - DUCT TEE
 - DUCT 54/DUCT 56 REDUCER
 - FIBRE JOINT
 - EXTERNAL FIBRE NODE WITHIN OPENREACH CHAMBER

CONSTRUCTION DRAWING

GAS: REV06 - UNAPPROVED

ELECTRIC: REV05 - UNAPPROVED

WATER: REV05 - PENDING APPROVAL

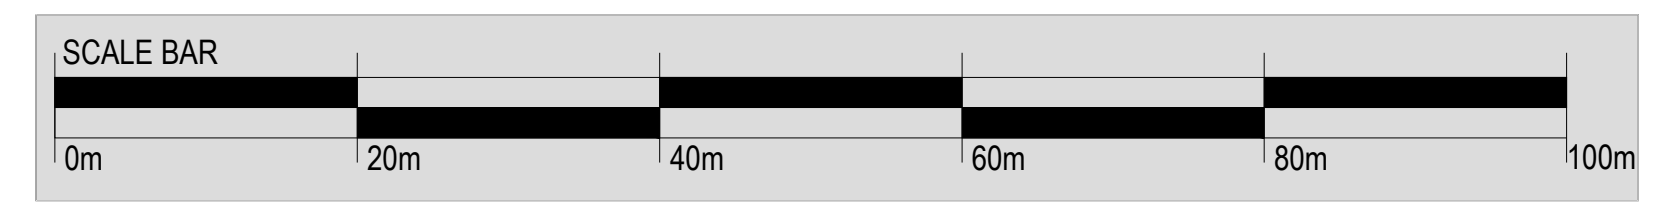

00 DRAFT DRAWING	EG UNAPP.	27/11/20
REV. DESCRIPTION:	BY:	STATUS: DATE:



CONNECT IT UTILITY SERVICES LTD
FOUNDATION HOUSE, UNIT C (WEST)
HAMILTON BUSINESS PARK, HEDGE END,
SOUTHAMPTON
SO30 2JR

SITE:
WINDMILL VIEWS,
YAPTON ROAD, BARNHAM,
PO22 0AU

SCALE AT A0	DATE:	DRAWN:	CHECKED:
1:500	27/11/20	EG	DCI
DRAWING NO:	PROJECT NO:	SWT NO:	REVISION:
MU1115-MU001	MU1115	-	00