


Appendix E Composite Surface Water Drainage Plan

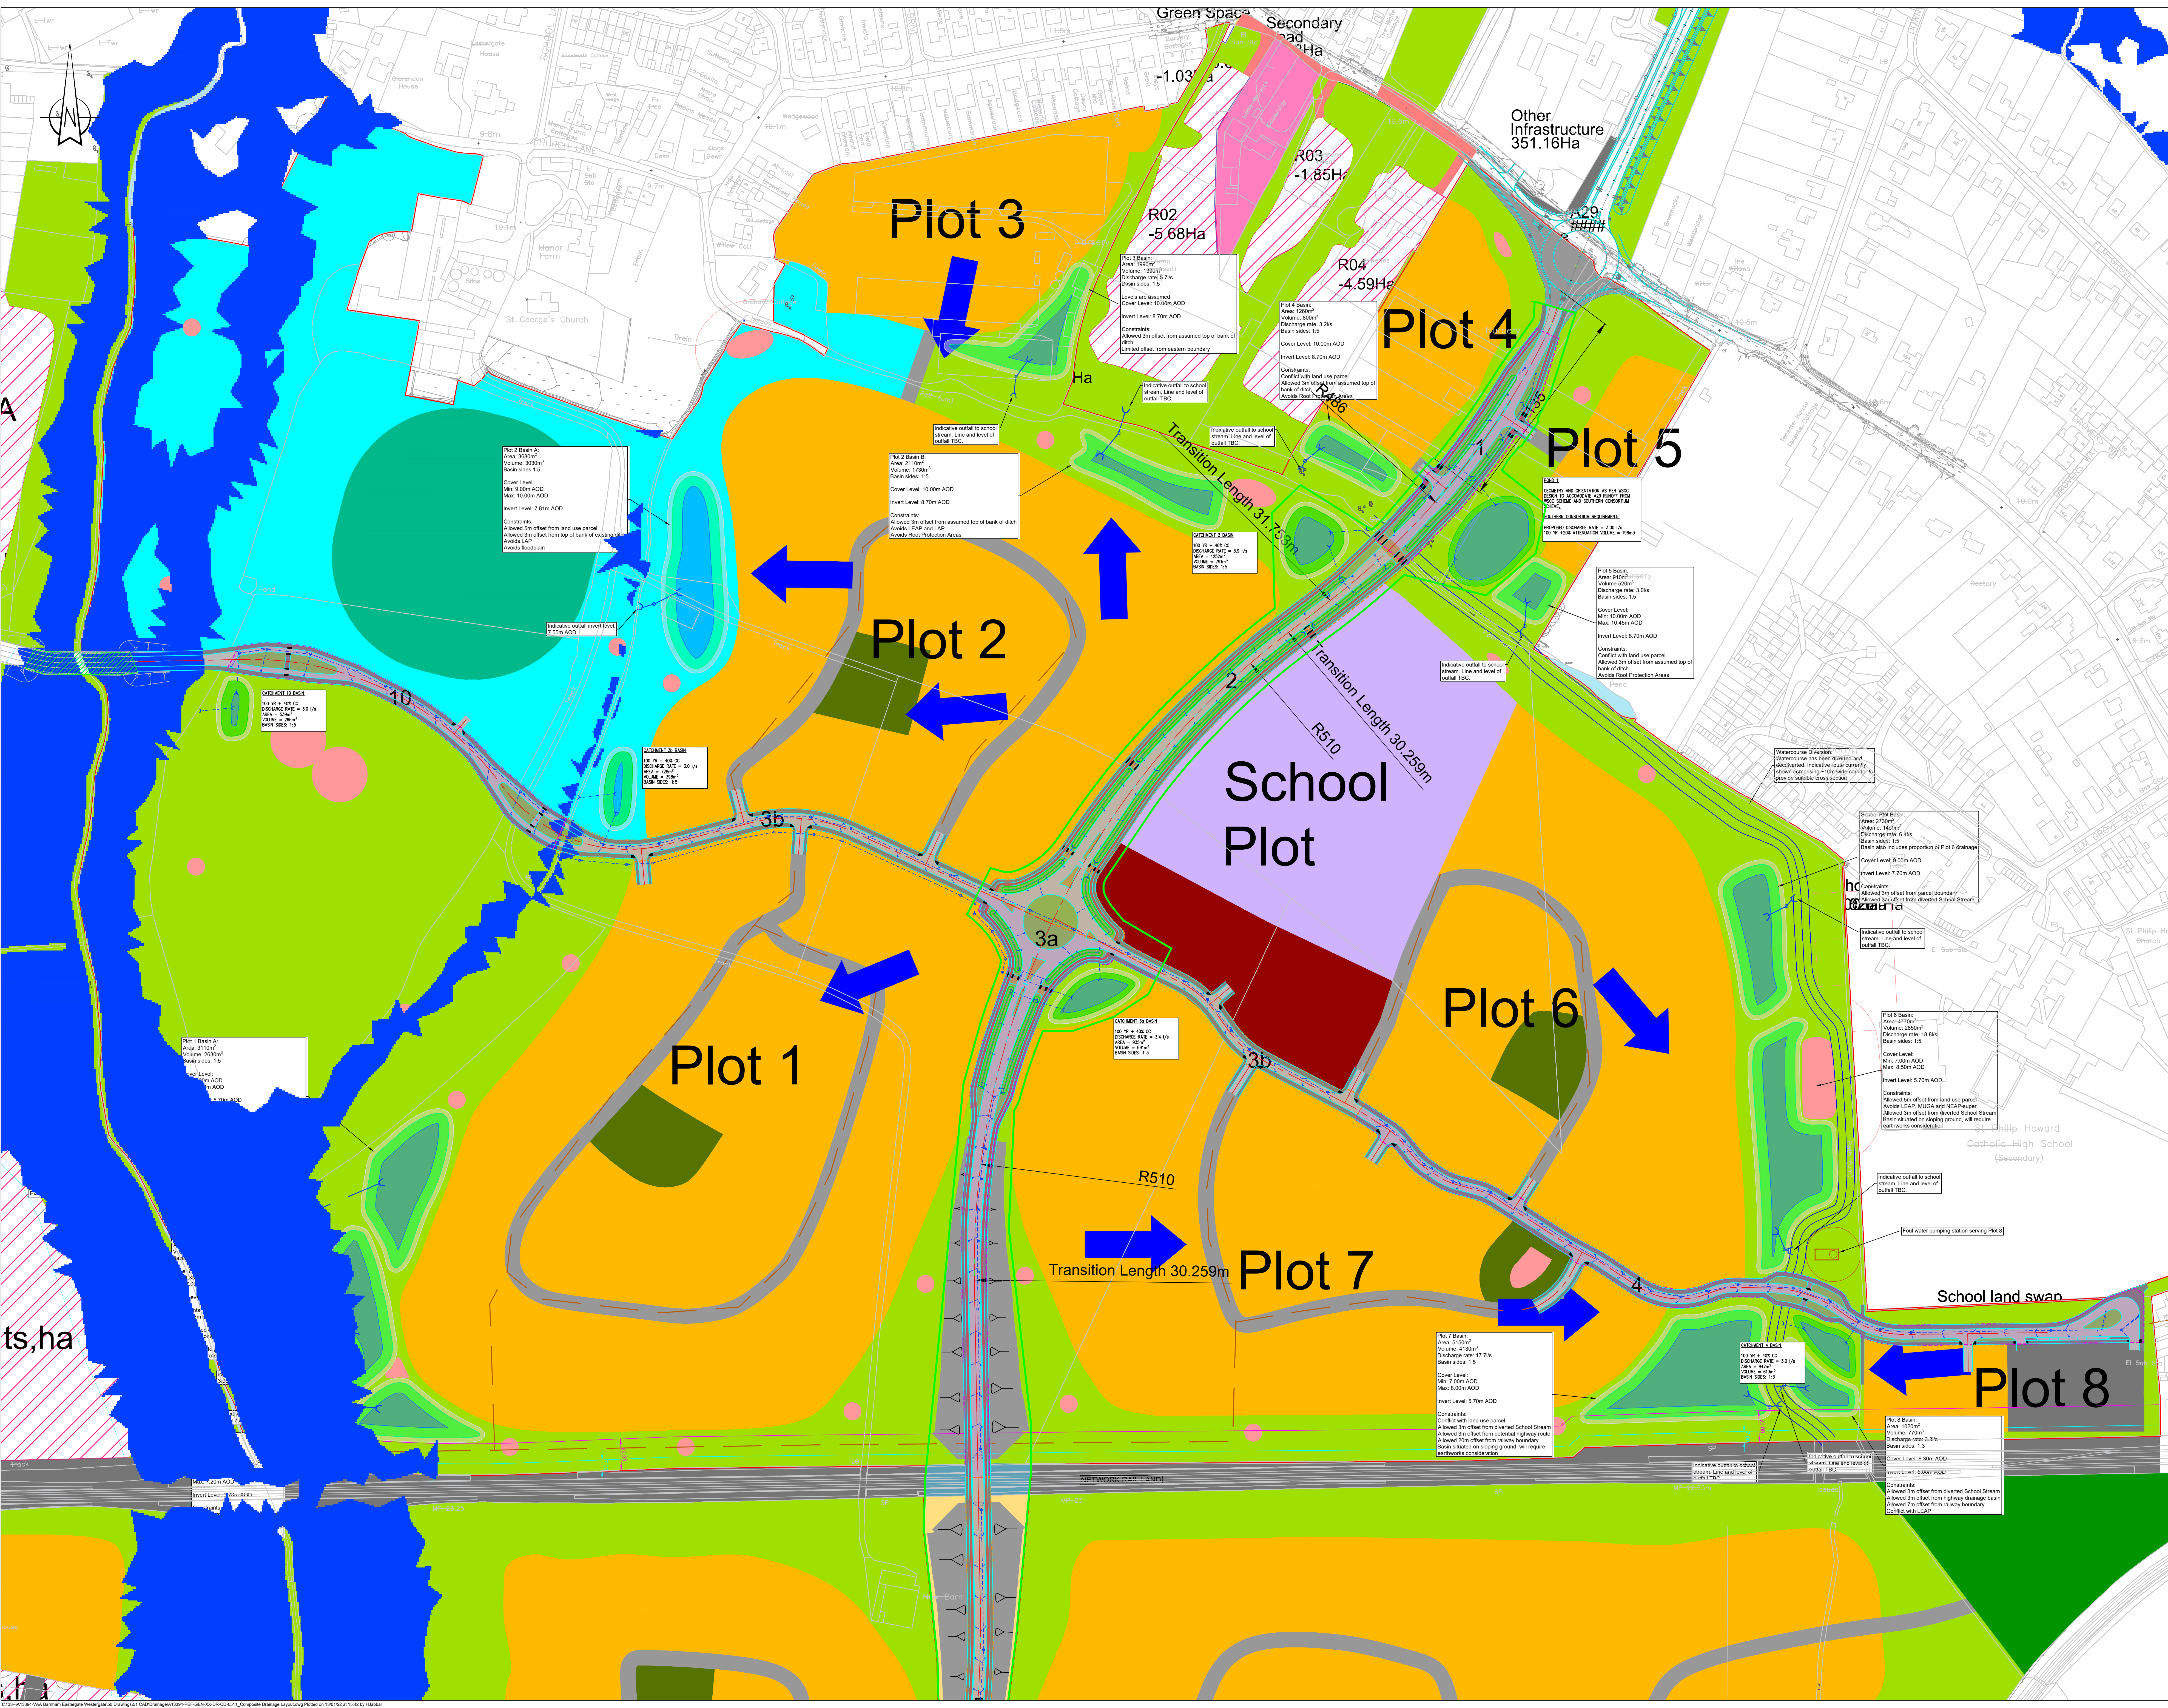

NOTES:

- Where the Contractor undertakes or engages a third party to undertake temporary works design, or varies the Pell Frischmann design in any way, then the Contractor will take full responsibility and liability for all design aspects, including a Design Risk Assessment. The Contractor shall inform Pell Frischmann of any proposed variances to the design.
- This drawing shall be read in conjunction with all other Electrical, Mechanical, Public Health & Architectural Drawings & The Specification.
- Topographical Information was provided by 3D Engineering Surveys and Pell Frischmann will not be held liable for any inaccuracies.
- Barham Road Roundabout and Northern Link Road designed by WSP, Pell Frischmann will not be held liable for any inaccuracies contained within this section.
- Partial Western Link Road designed by CALA, Pell Frischmann will not be held liable for any inaccuracies contained within this section.

PROPOSED DRAINAGE KEY:

- PROPOSED SURFACE WATER HIGHWAY SEWER
- PROPOSED SURFACE WATER HIGHWAY GULLY
- PROPOSED HIGHWAY SWALE
- PROPOSED HEADWALL
- PROPOSED BALANCING POND
- DEFINES HIGHWAY CATCHMENT AREA SPLIT FOR RUNOFF

P01	Client name updated	HJ	[DAR]	13.01.22	
P02	Client and project name updated	HJ	[DAR]	12/1/21	
P03	Client and project name updated	HJ	[L]	04.12.21	
P04	Development drainage updated	HJ	[YL]	[DAR]	13/08/21
P05	Updated highway and development drainage	HJ	[L]	[DAR]	07/08/21
P06	Preliminary Issue	HJ	[YL]	[DAR]	06/07/21
REV	DESCRIPTION	DRN	GHI	APP	DATE

Pell Frischmann
5 MANCHESTER SQUARE LONDON W1U 3PD
Telephone +44 (0)20 7486 3661
Email: pfrondan@pellfrischmann.com
www.pellfrischmann.com

Client
C.C Projects

Project
BEW Parcel SC1

Drawing Title
Composite Drainage Layout (North)

Drawn	Name	Date	Scale	NTS
Drawn	HJ	JULY 21	File No.	A13394-PEF-GEN-XX-DR-CD-0511
Designed	HJ	JULY 21	Drawing Status	Preliminary
Checked	YL	JULY 21	Revision	
Approved	DAR	JULY 21		

A13394-PEF-ZZ-XX-DR-CD-0511 **P6**