


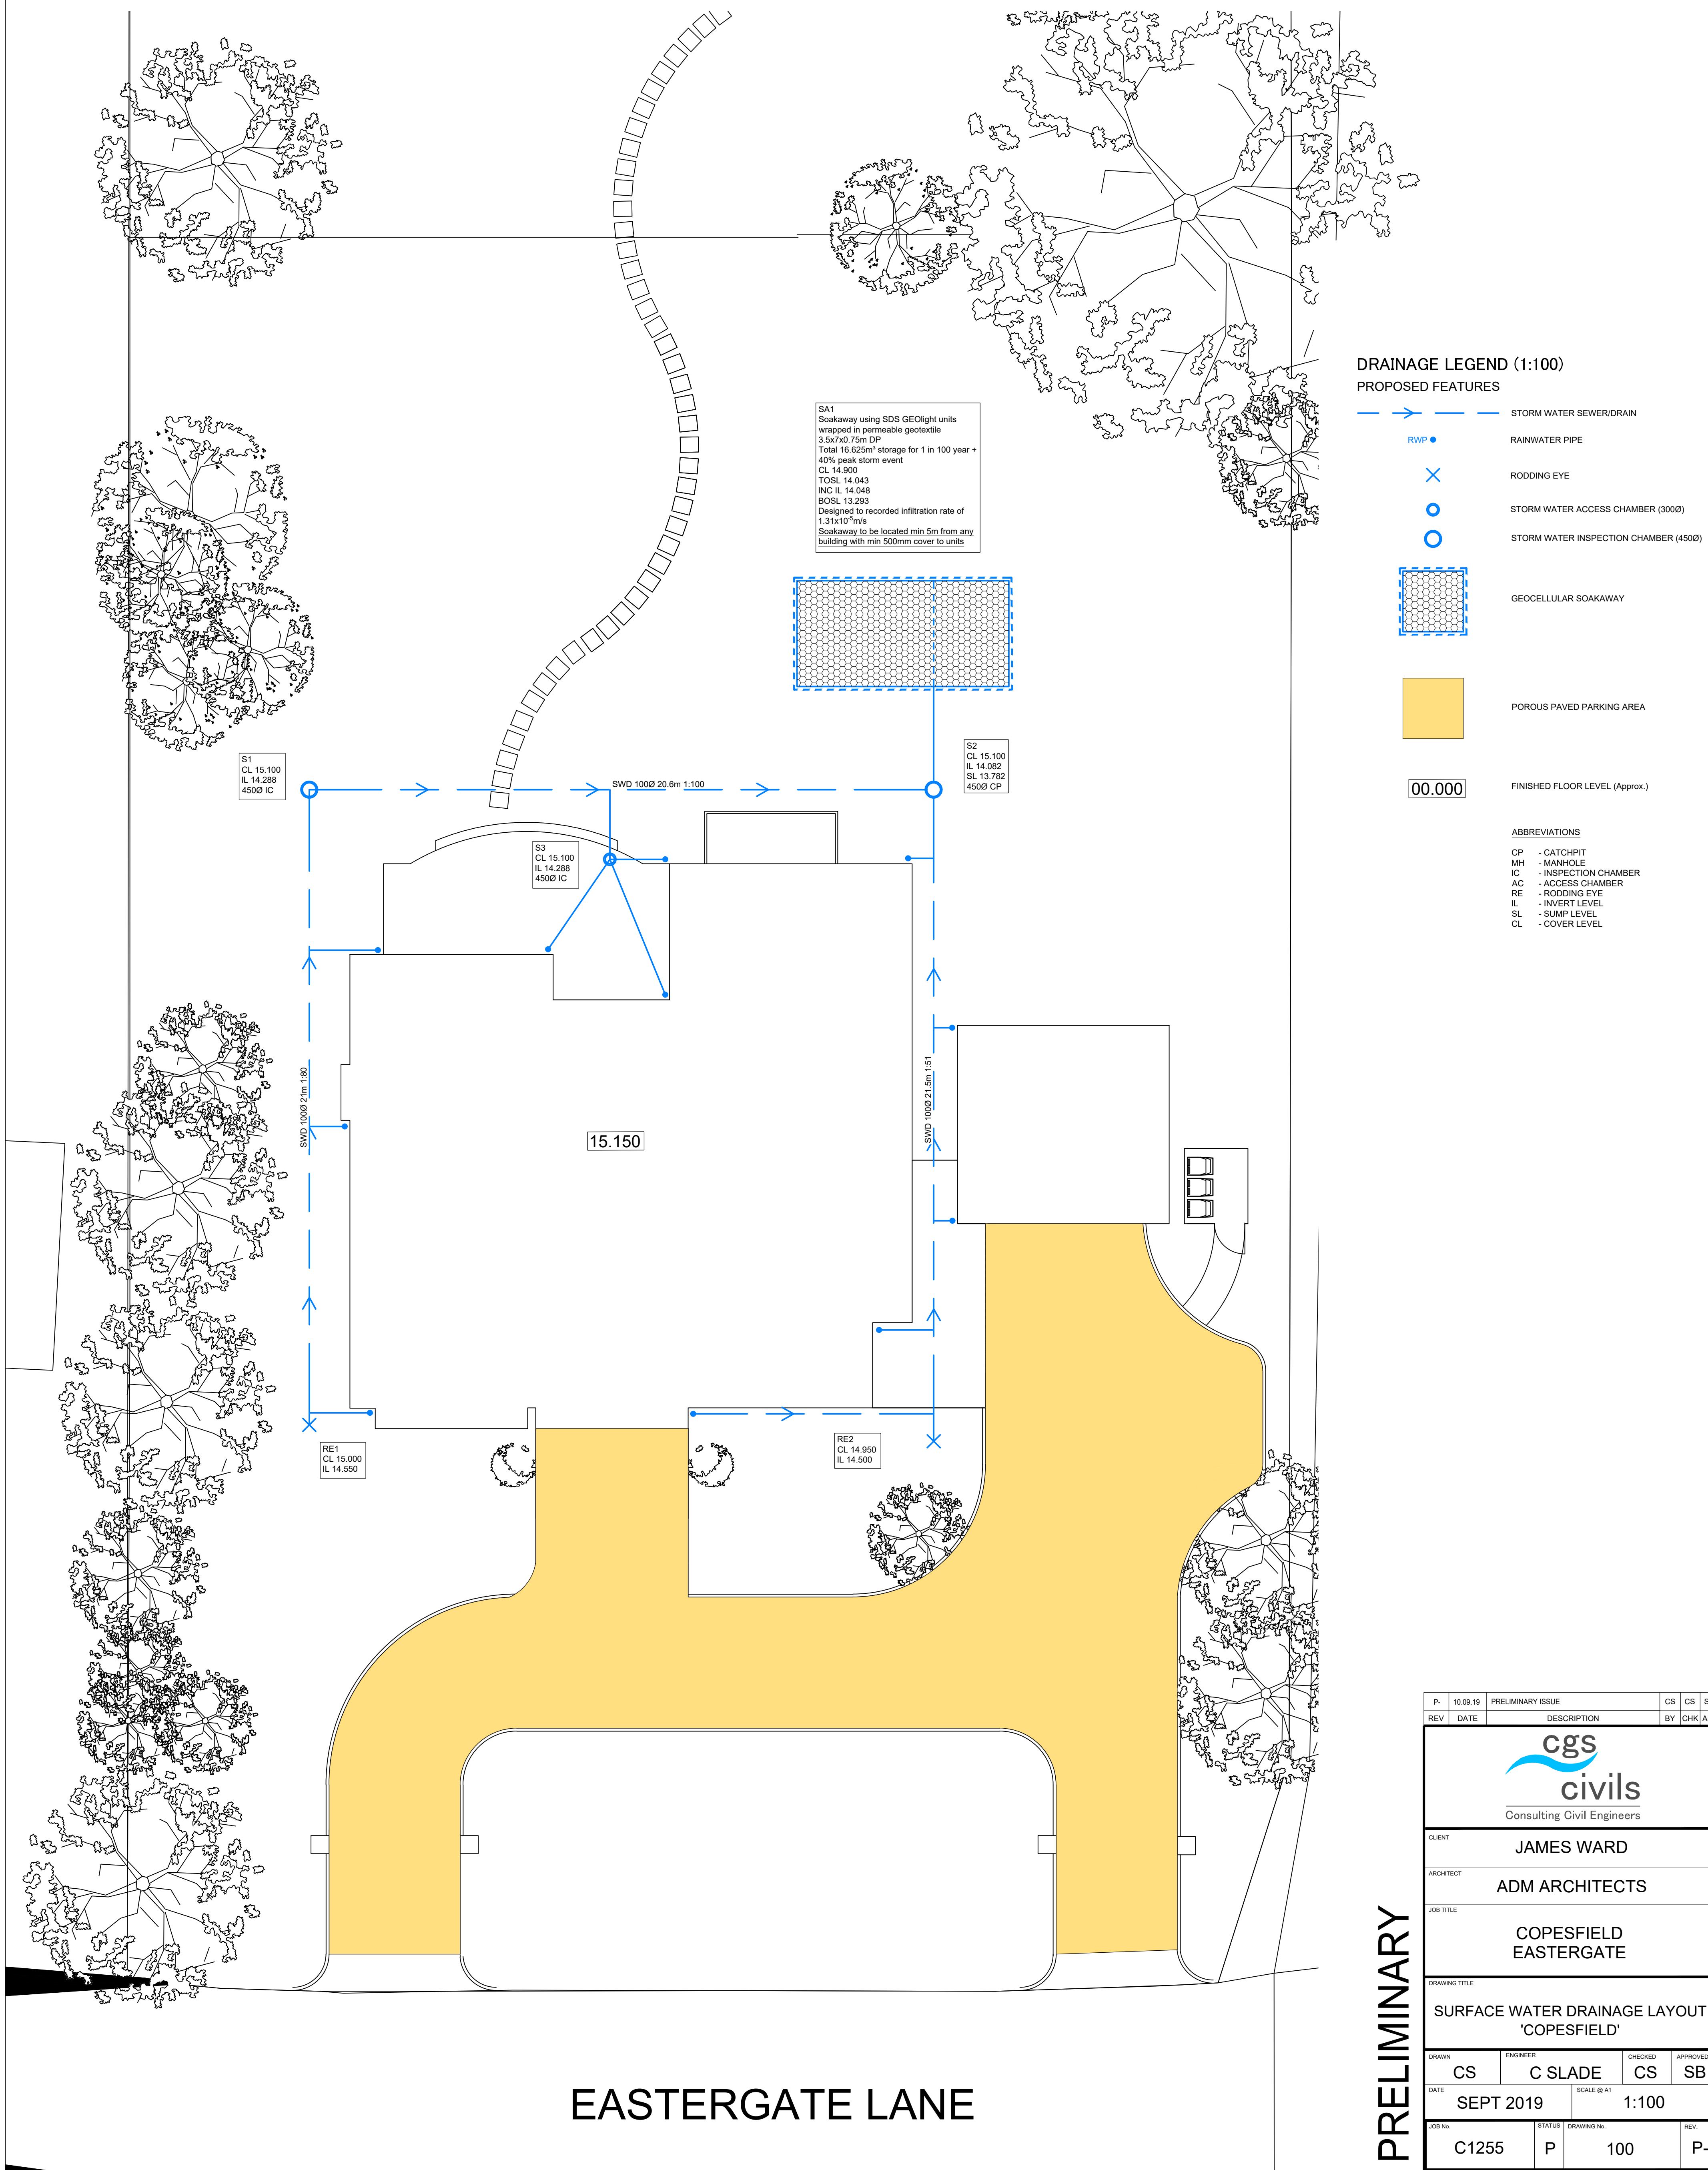

PRELIMINARY

P.	10.09.19	PRELIMINARY ISSUE		CS	SB	
REV	DATE	DESCRIPTION			BY	CHK/APP
 Consulting Civil Engineers						
CLIENT		JAMES WARD				
ARCHITECT		ADM ARCHITECTS				
JOB TITLE		COPESFIELD EASTERGATE				
DRAWING TITLE						
SURFACE WATER DRAINAGE LAYOUT 'COPESFIELD'						
DRAWN	ENGINEER		CHECKED	APPROVED		
CS	C SLADE		CS	SB		
DATE	SCALE @ A1		1:100			
SEPT 2019						
JOB No.		STATUS	DRAWING No.		REV.	
C1255		P	100		P-	

Downloaded from <http://ajphaphysocpharm.sagepub.com/>