




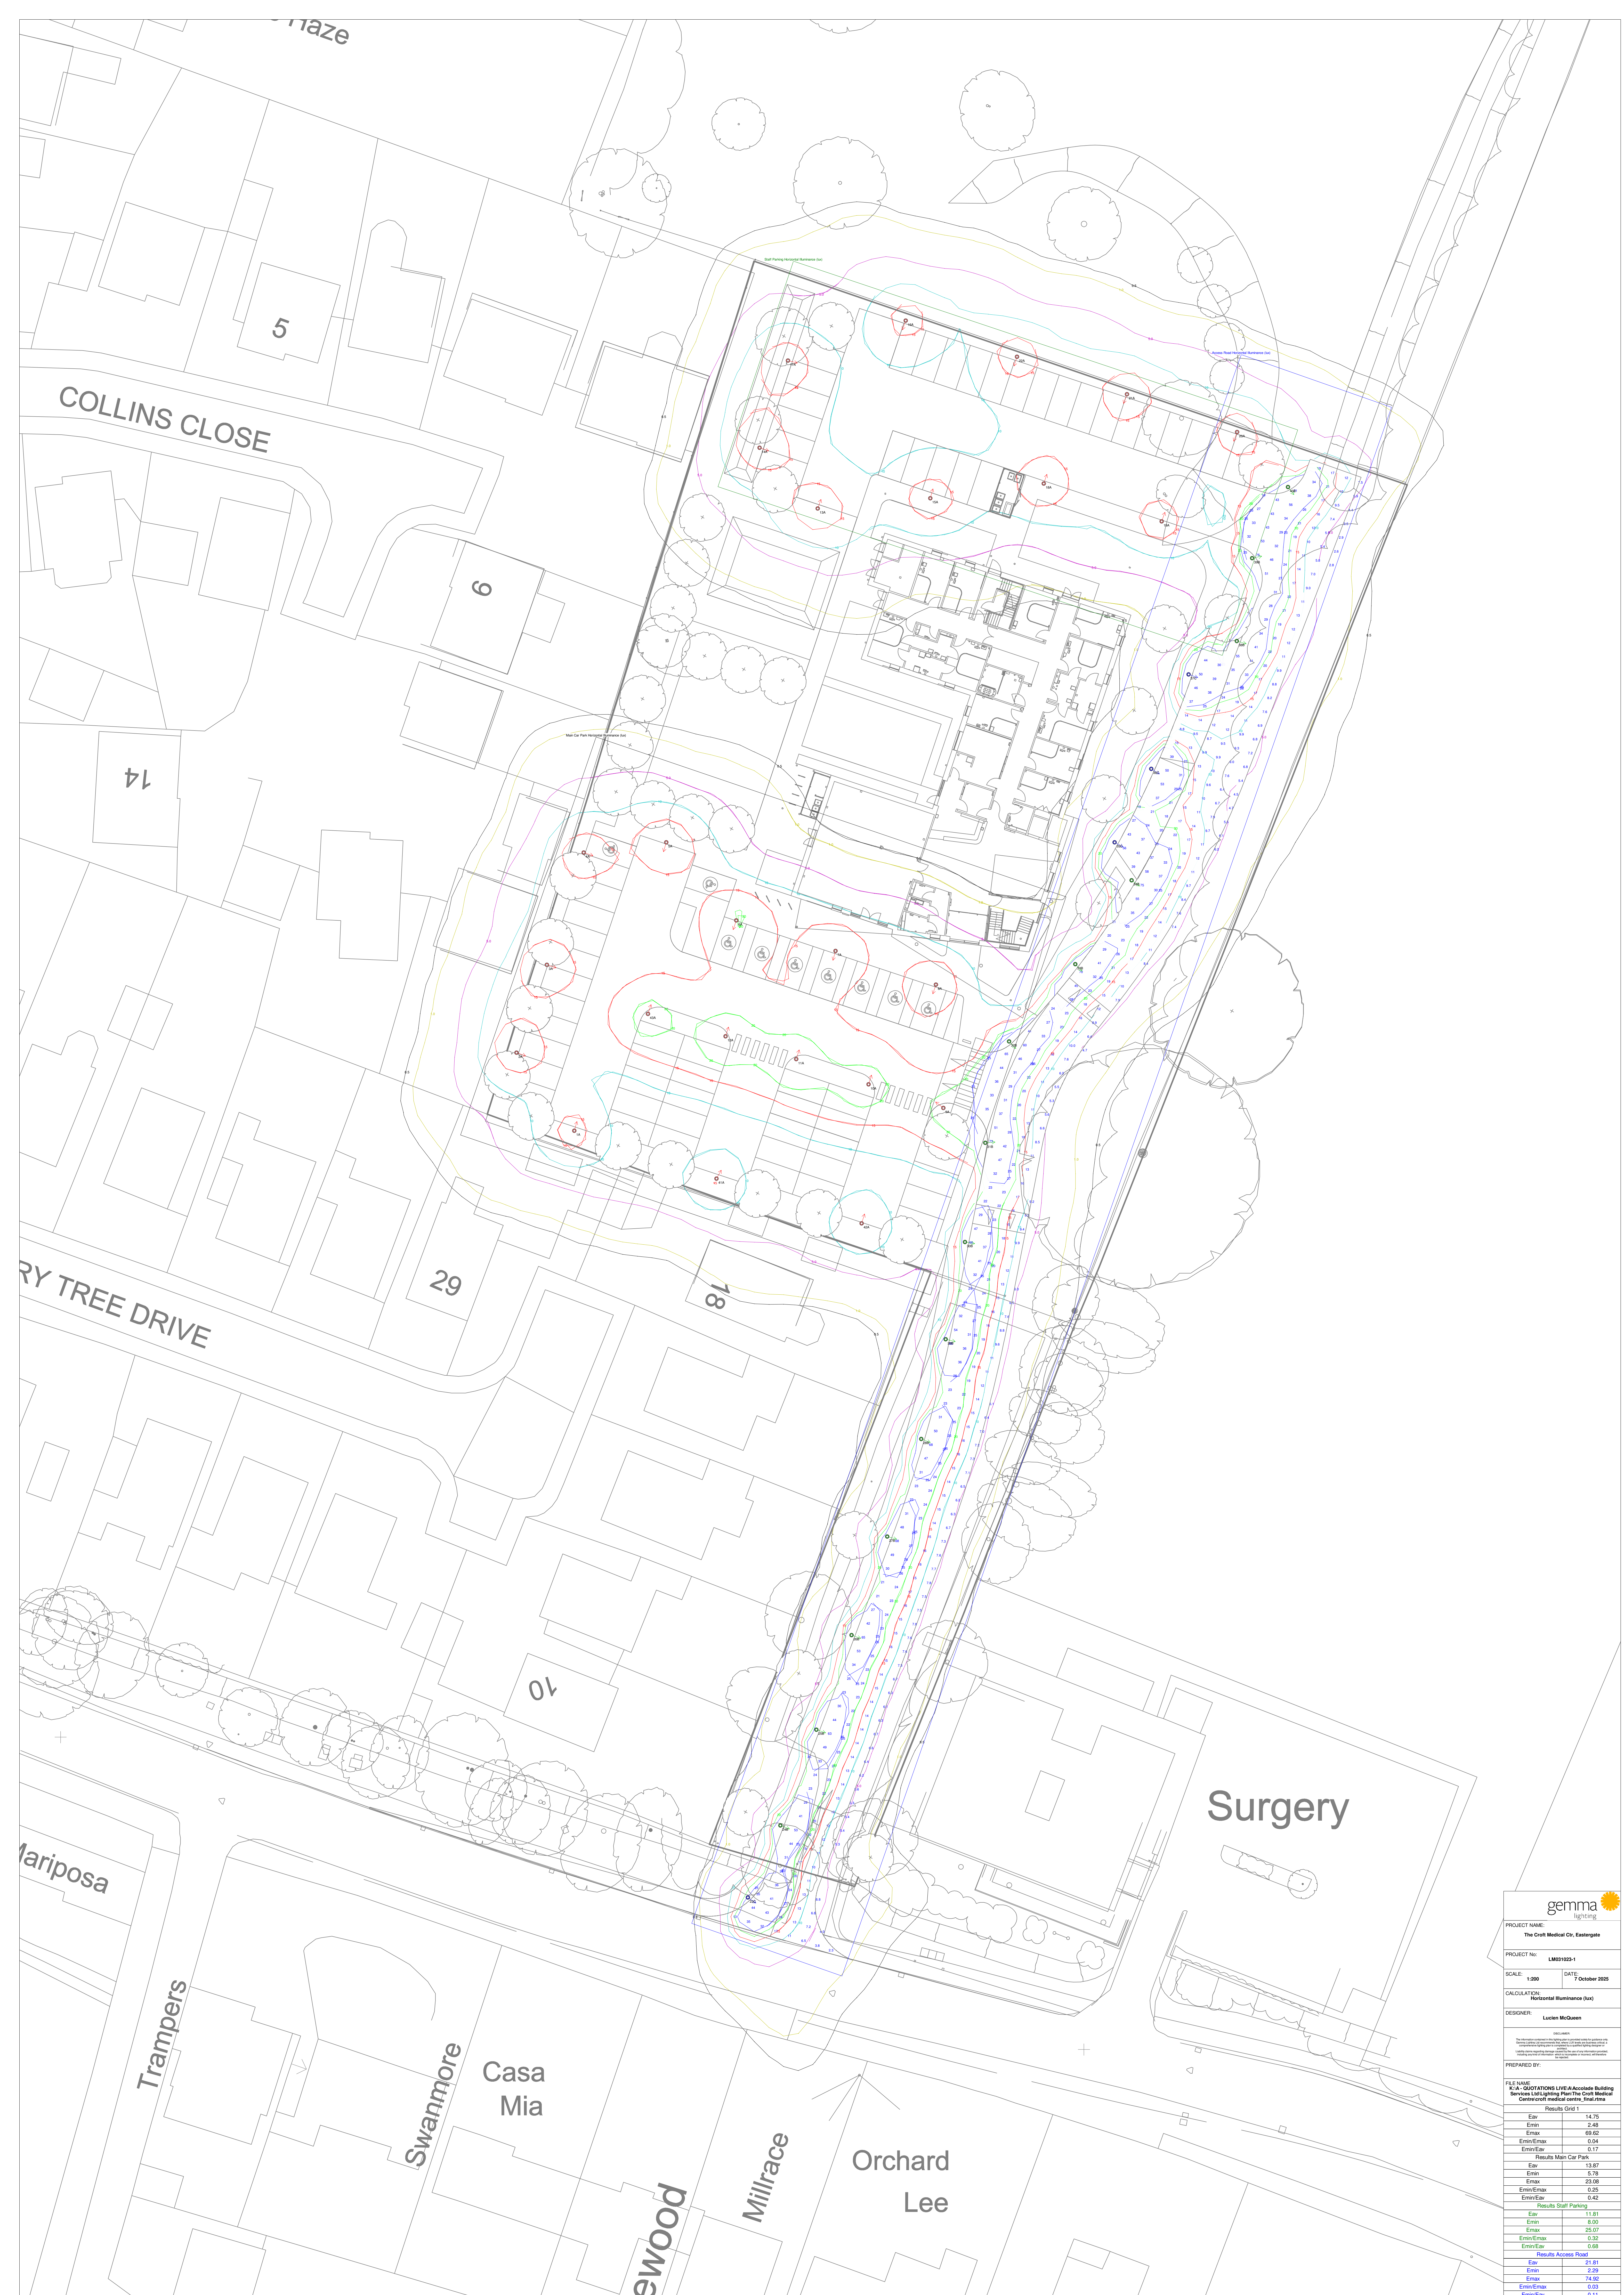

PROJECT NAME:
The Croft Medical Ctr, Eastergate

PROJECT No:
LM031025-1

SCALE: 1:200 DATE: 7 October 2025

CALCULATION:
Horizontal Illuminance (lux)

DESIGNER:
Lucien McQueen

PREPARED BY:
F.E. HANNA
K.I.A. QUOTATIONS LIVE-Accolade Building Services Ltd Lighting Plan-The Croft Medical Centre-croft medical centre_final.rvtm

Results Grid 1	
Eav	14.75
Emin	2.48
Emax	68.62
Emin/Emax	0.04
Emv/Eav	0.17

Results Main Car Park	
Eav	13.87
Emin	5.78
Emax	23.06
Emin/Emax	0.25
Emv/Eav	0.42

Results Staff Parking	
Eav	11.81
Emin	8.00
Emax	25.07
Emin/Emax	0.32
Emv/Eav	0.68

Results Access Road	
Eav	21.81
Emin	2.29
Emax	74.82
Emin/Emax	0.03
Emv/Eav	0.11