



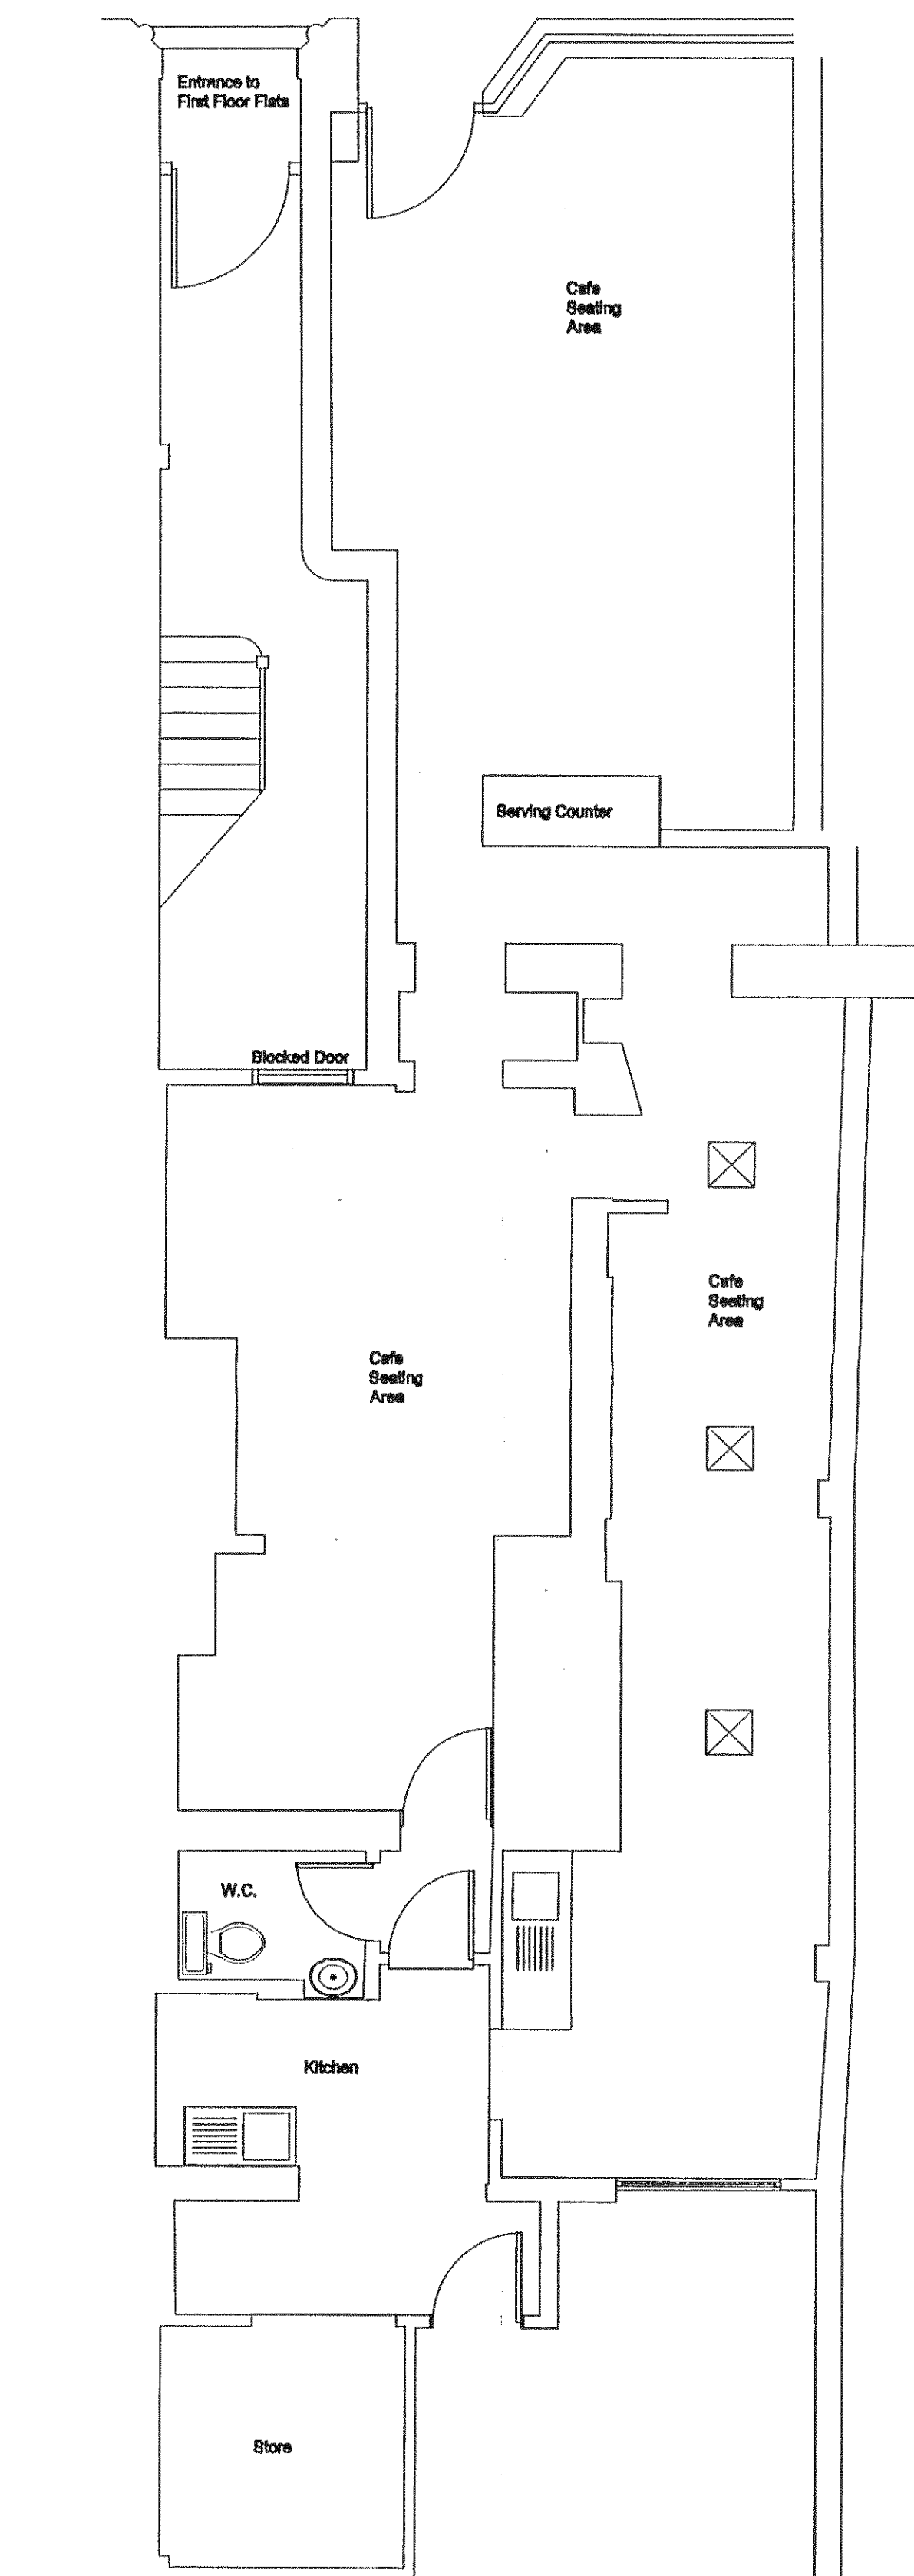

Existing Ground Floor Plan

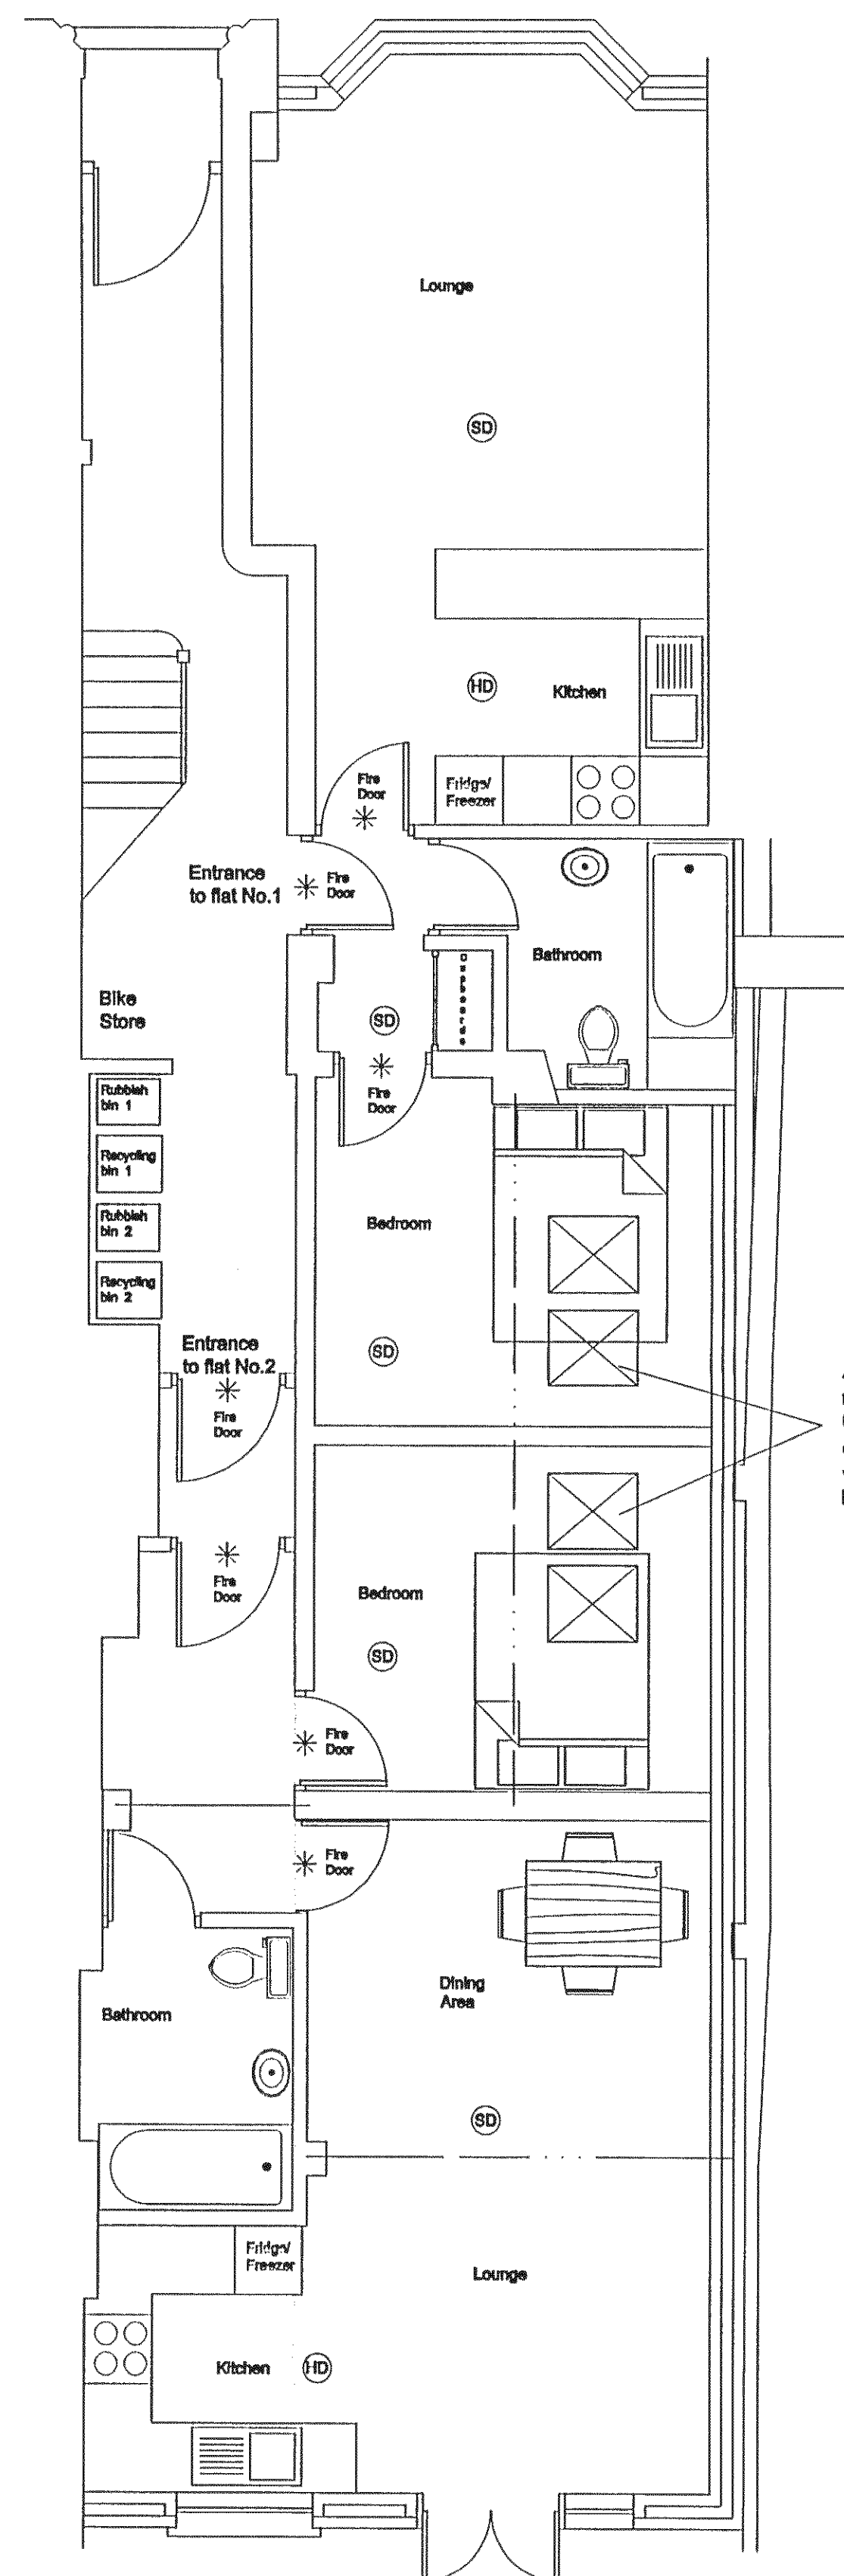

Proposed Ground Floor Plan

(SD) Smoke Detector

(HD) Heat Detector

Smoke & heat detectors will be hard wired, off a lighting ring main and have a battery back up.

* Fire Doors. 30 minute fire resistant doors, fitted with a self closing device.

4 No double glazed Velux roof-lights. Ref: FO4. (880 x 680mm each unit). Note: In excess of $\frac{1}{10}$ floor area in ventilation & $\frac{1}{10}$ floor area in light.

BUILDING REGULATION NOTES

	Date	Revisions
A	08.05.13	Planning amendments

Copyright

Graham Askew

Chartered Building Surveyor

Principal: Graham Askew MRICS, MSST, MBBag.

Bay Tree Cottage,
8 Hurston Grove
Hurston Lane, Storrington,
West Sussex, RH12 4HJ.
Tel/Fax: (01893) 743234
email: askewsurveyor@btvclub.net

Client

Mr E Jenkinson

Job Title

19 Lennox Street
Bognor Regis
West Sussex
PO21 1NA

Drawing Title

Existing & Proposed
Ground Floor Layouts

NOTE:
All dimensions must be checked on site and not scaled from this drawing

Scale 1:50

Date 27.5.11 Drawn by K.L.Carter

Dwg No.	In conjunction with:-	Rev.
2011/ 11/1		A